


Legend - Lighting	
 L1	Linear Fitting LED
 L1E	Emergency Linear Fitting LED

Notes

1. This drawing should be read in conjunction with the relevant specification sections and schedules.
2. The design intent for the MEP installation is defined by the specification AND the concept drawings.
3. The drawings show the minimum requirements for compliance and may contain elements which are not referred to in the specification.
4. All lighting positions are indicative only.
5. All details indicated are to be verified as part of the stage 4 Technical design.

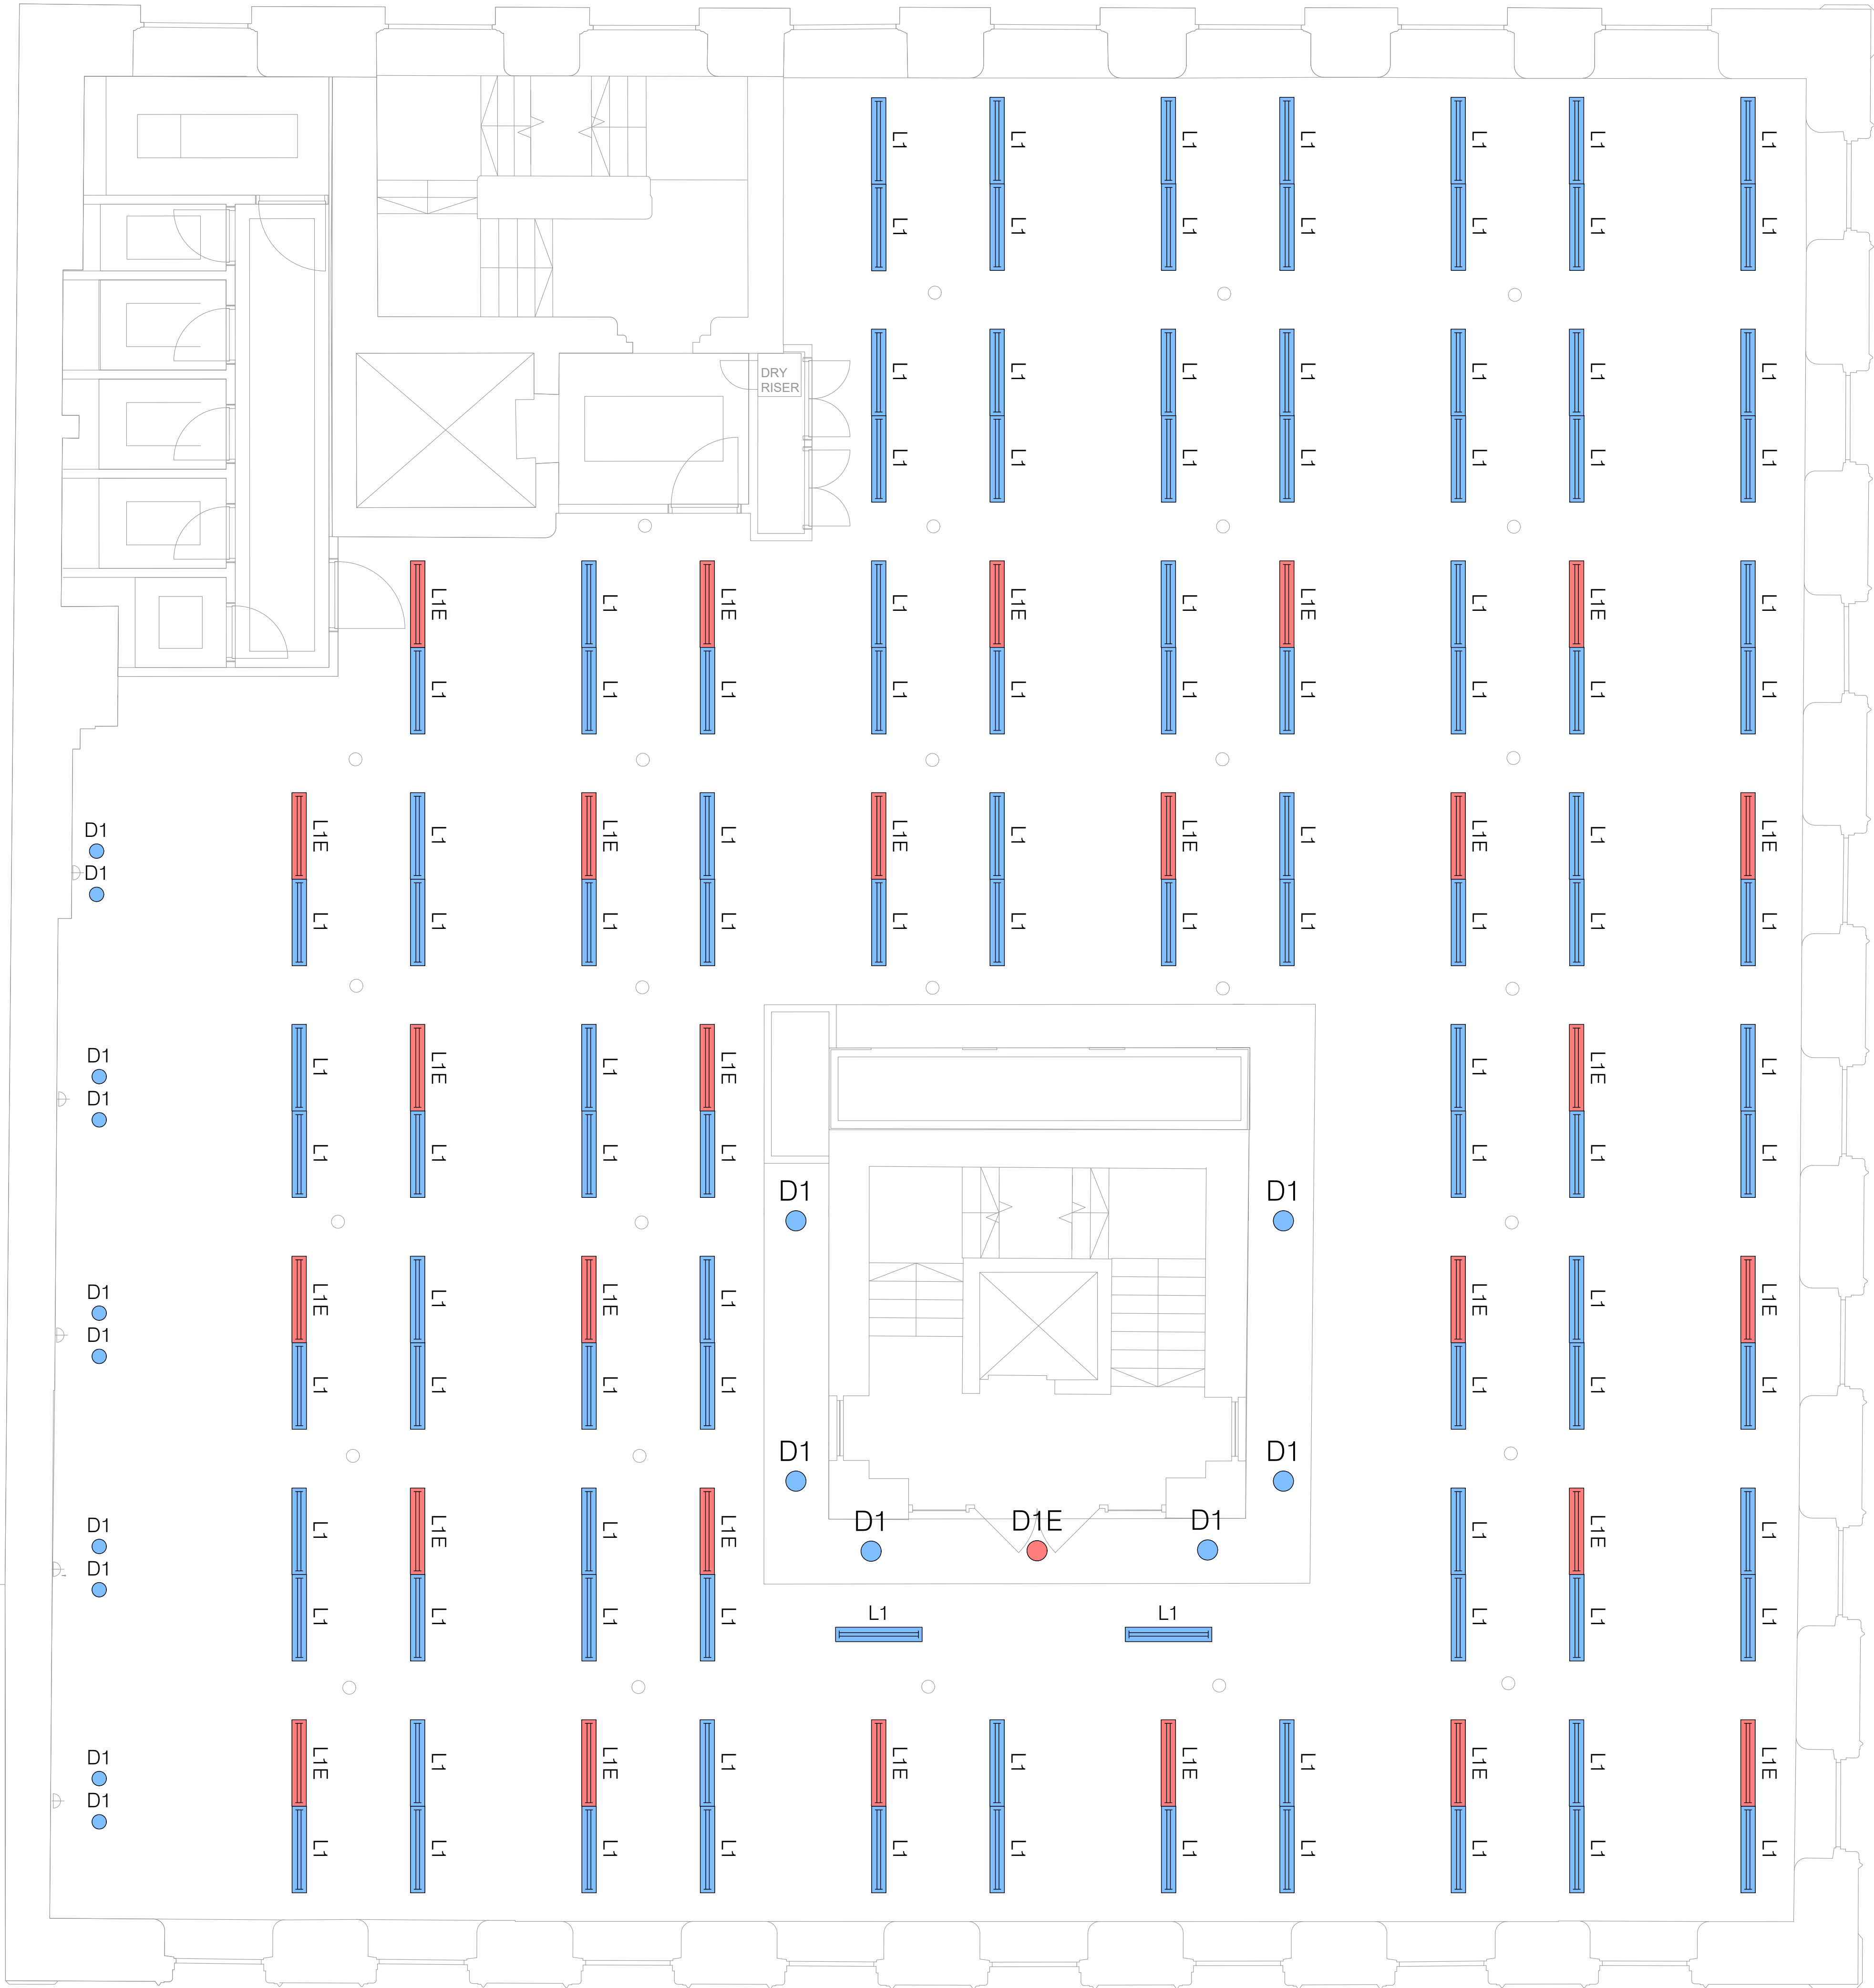

P3	31	Planning Issue	DG	JW
	01			
	22			
P2	28	Preliminary Issue - For Planning	SM	JW
	01			
	22			
P1	15	Preliminary Issue - Layout change in line with comments received, indicating containment.	SM	JW
	12			
	21			
Issue	Date	Description	Drawn	Checked
				
Hannan Associates MEP Design Solutions			Hannan Associates Ltd Beta House, Alphagate Drive, Manchester Road, Denton M34 3SH Tel : +44 (0)161 337 2200 Email : info@hannan-uk.com Web : www.hannan-uk.com	
Client				
Clearbell UK Strategic Limited Partnership				
Project				
Freetrade Exchange Refurbishment				
Design Stage				
Stage 2 'Concept Design'				
Drawing Title				
Typical Floor Office Lighting Layout				
Scale	1:50		Page Size	A1L
Status				
PLANNING ISSUE				
Project : Originator : Volume			Level : File Type : Role : Number	
3882 - HAN - ZZ			XX - DR - E - 04 00	
This drawing is the property of Hannan Associates. It must not be copied or lent to any third party without the written consent of Hannan Associates, and must be returned upon request.				