



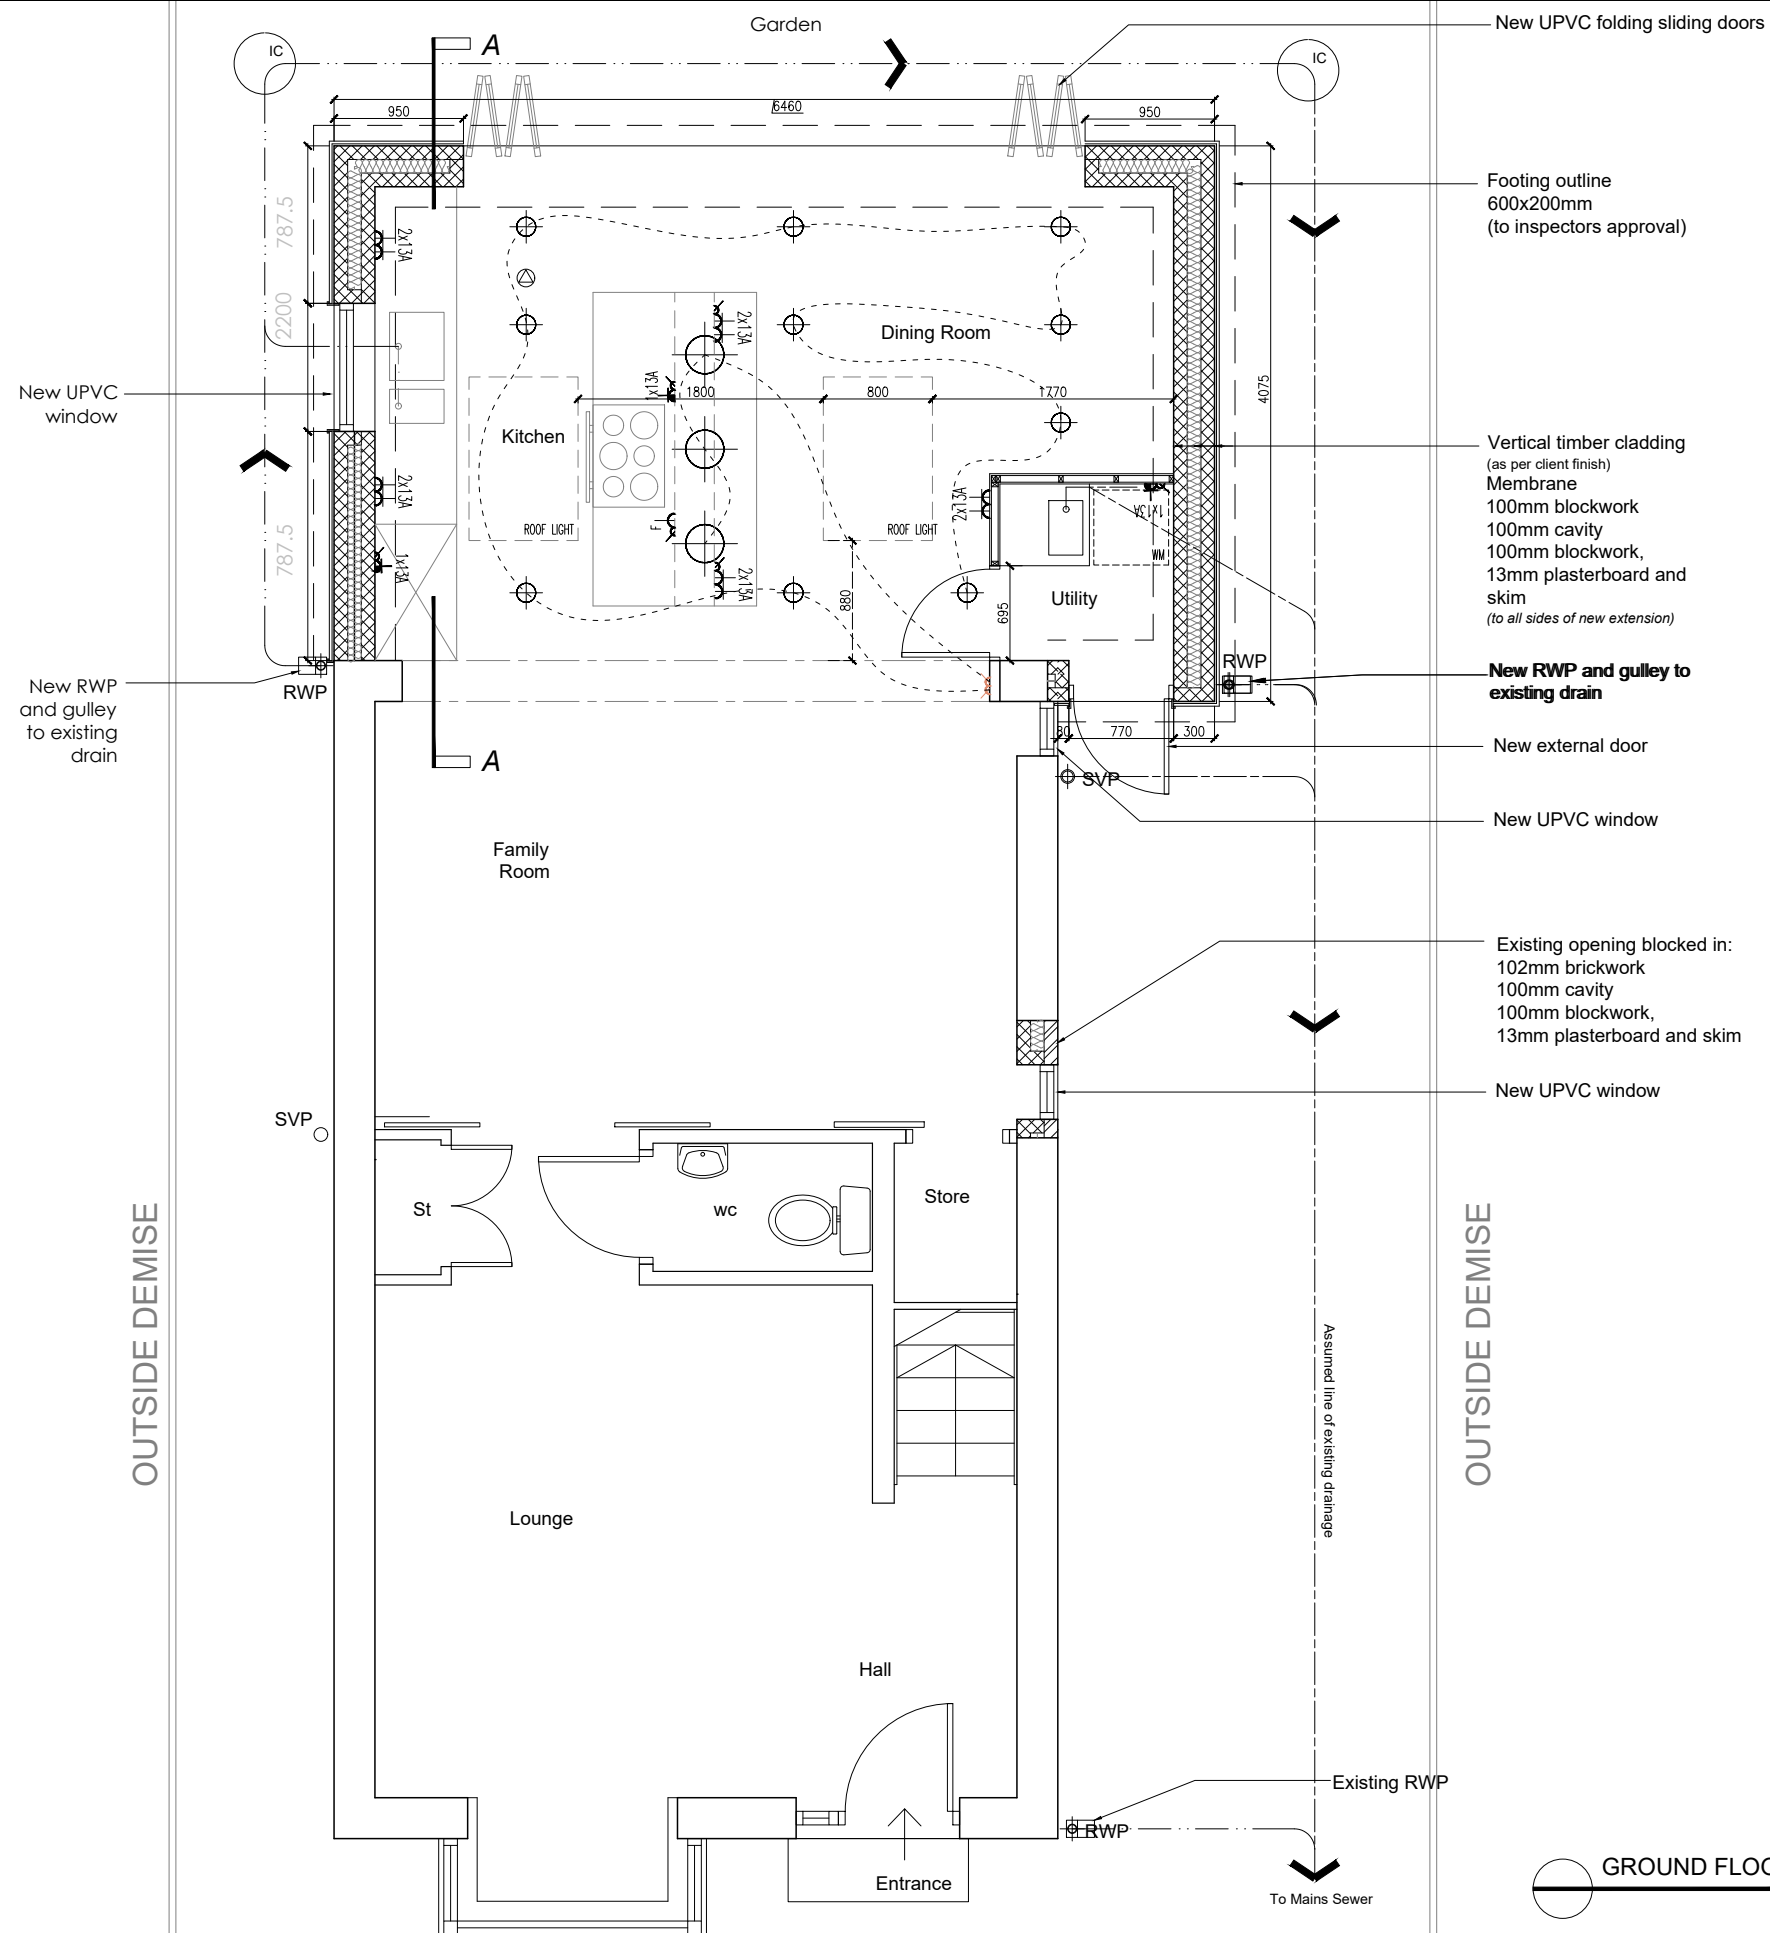

Notes:

1. Contractor/sub-contractor to verify all dimensions on site before commencing work. Skribbld is to be notified of any discrepancies in dimensions and setting out of work prior to starting on site.
2. Copyright of design shown is retained by this office. All rights reserved. This drawing must not be reproduced without prior permission.
3. Do not scale from the drawings.
4. All dimensions are in millimeters unless noted otherwise. All dimensions to be verified on site & approved by the engineer/contractor.
5. This drawing should be read in conjunction with other relevant architectural, structural, mechanical and electrical drawings and all relevant sections of the specifications.

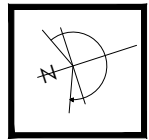

- 102mm brickwork construction
- 100mm blockwork construction

Electrical Legend

- 2x13A DOUBLE SWITCHED SOCKET
- 1x13A SINGLE SWITCHED SOCKET
- F F FUSED SPUR
- 1x13A SOCKET BELOW W/TOP
- LIGHT SWITCH
- PENDANT LIGHT
- RECESSED SPOT LIGHT
- SMOKE ALARM
- HEAT ALARM

REV.	DESCRIPTION:	BY:	DATE:
STATUS: BUILDING REGS			



SKRIBBLD
Manchester, UK
+44 79260 22288
www.skribbld.com
info@skribbld.com

CLIENT:	Ethan Ticehurst 9 Catchdale Close Blackley Manchester
---------	--

TITLE:	Proposed Plans Ground Floor
--------	--------------------------------

SCALE AT A1: 1:50@A3	DATE: 01.18.21	DRAWN: SM	CHECKED: HS
PROJECT NO: 2006	DRAWING NO: BR-PL-0012	REVISION: 1	