



NOTES:
All dimensions must be checked on
site and not scaled from this drawing.

LEVEL 00 - PLAN VIEW CRIDLINES HI12 - HI23 - SCALE 1:50

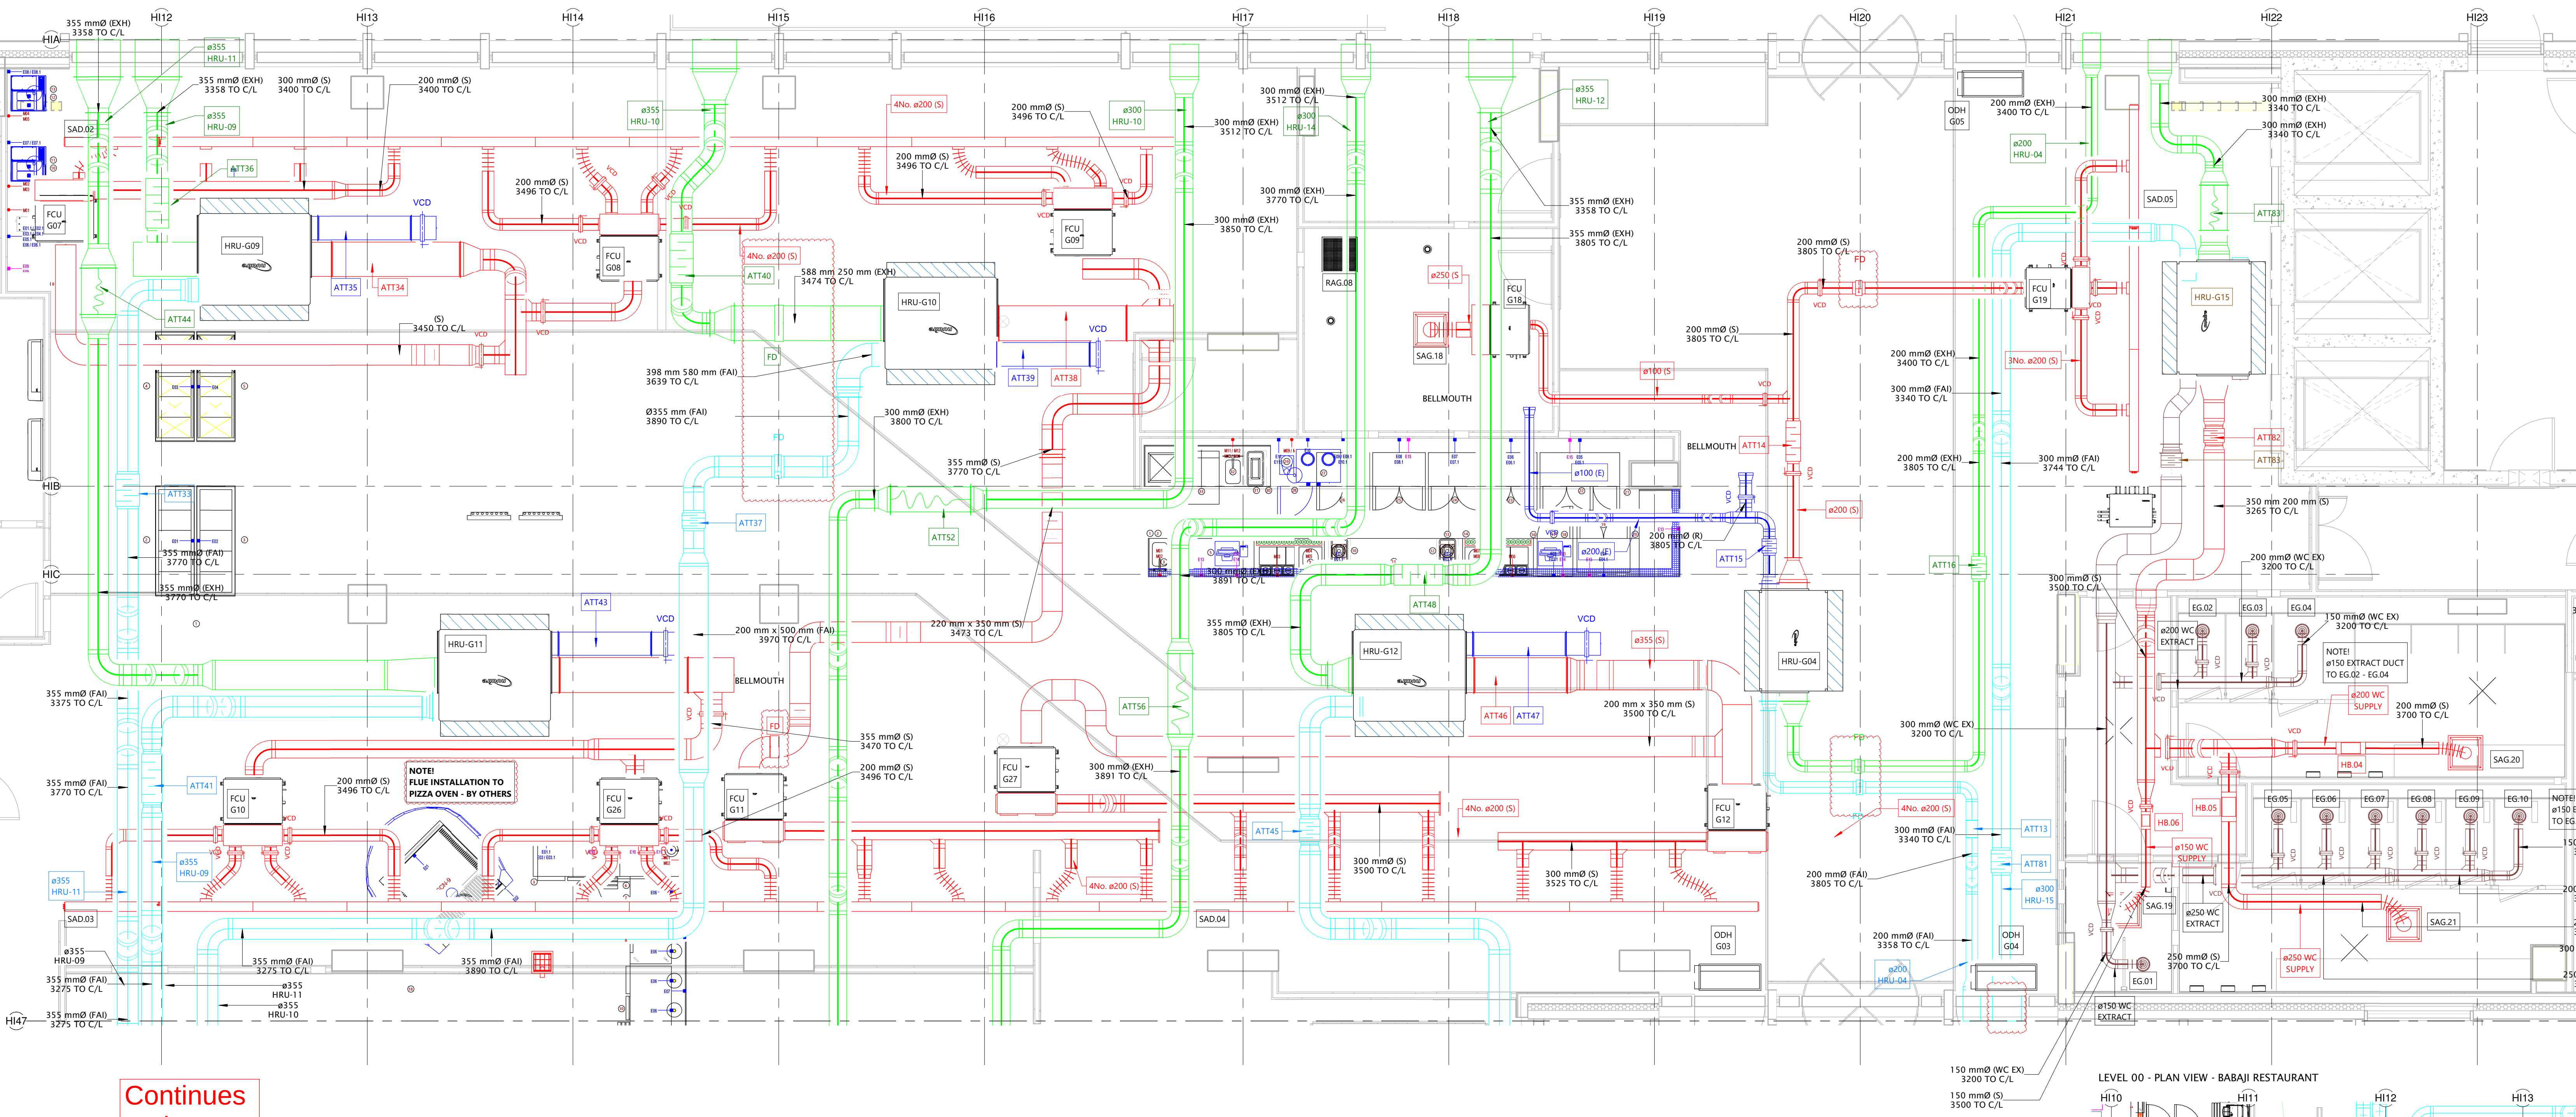


LEVEL 00 - PLAN VIEW - MEETING ROOMS

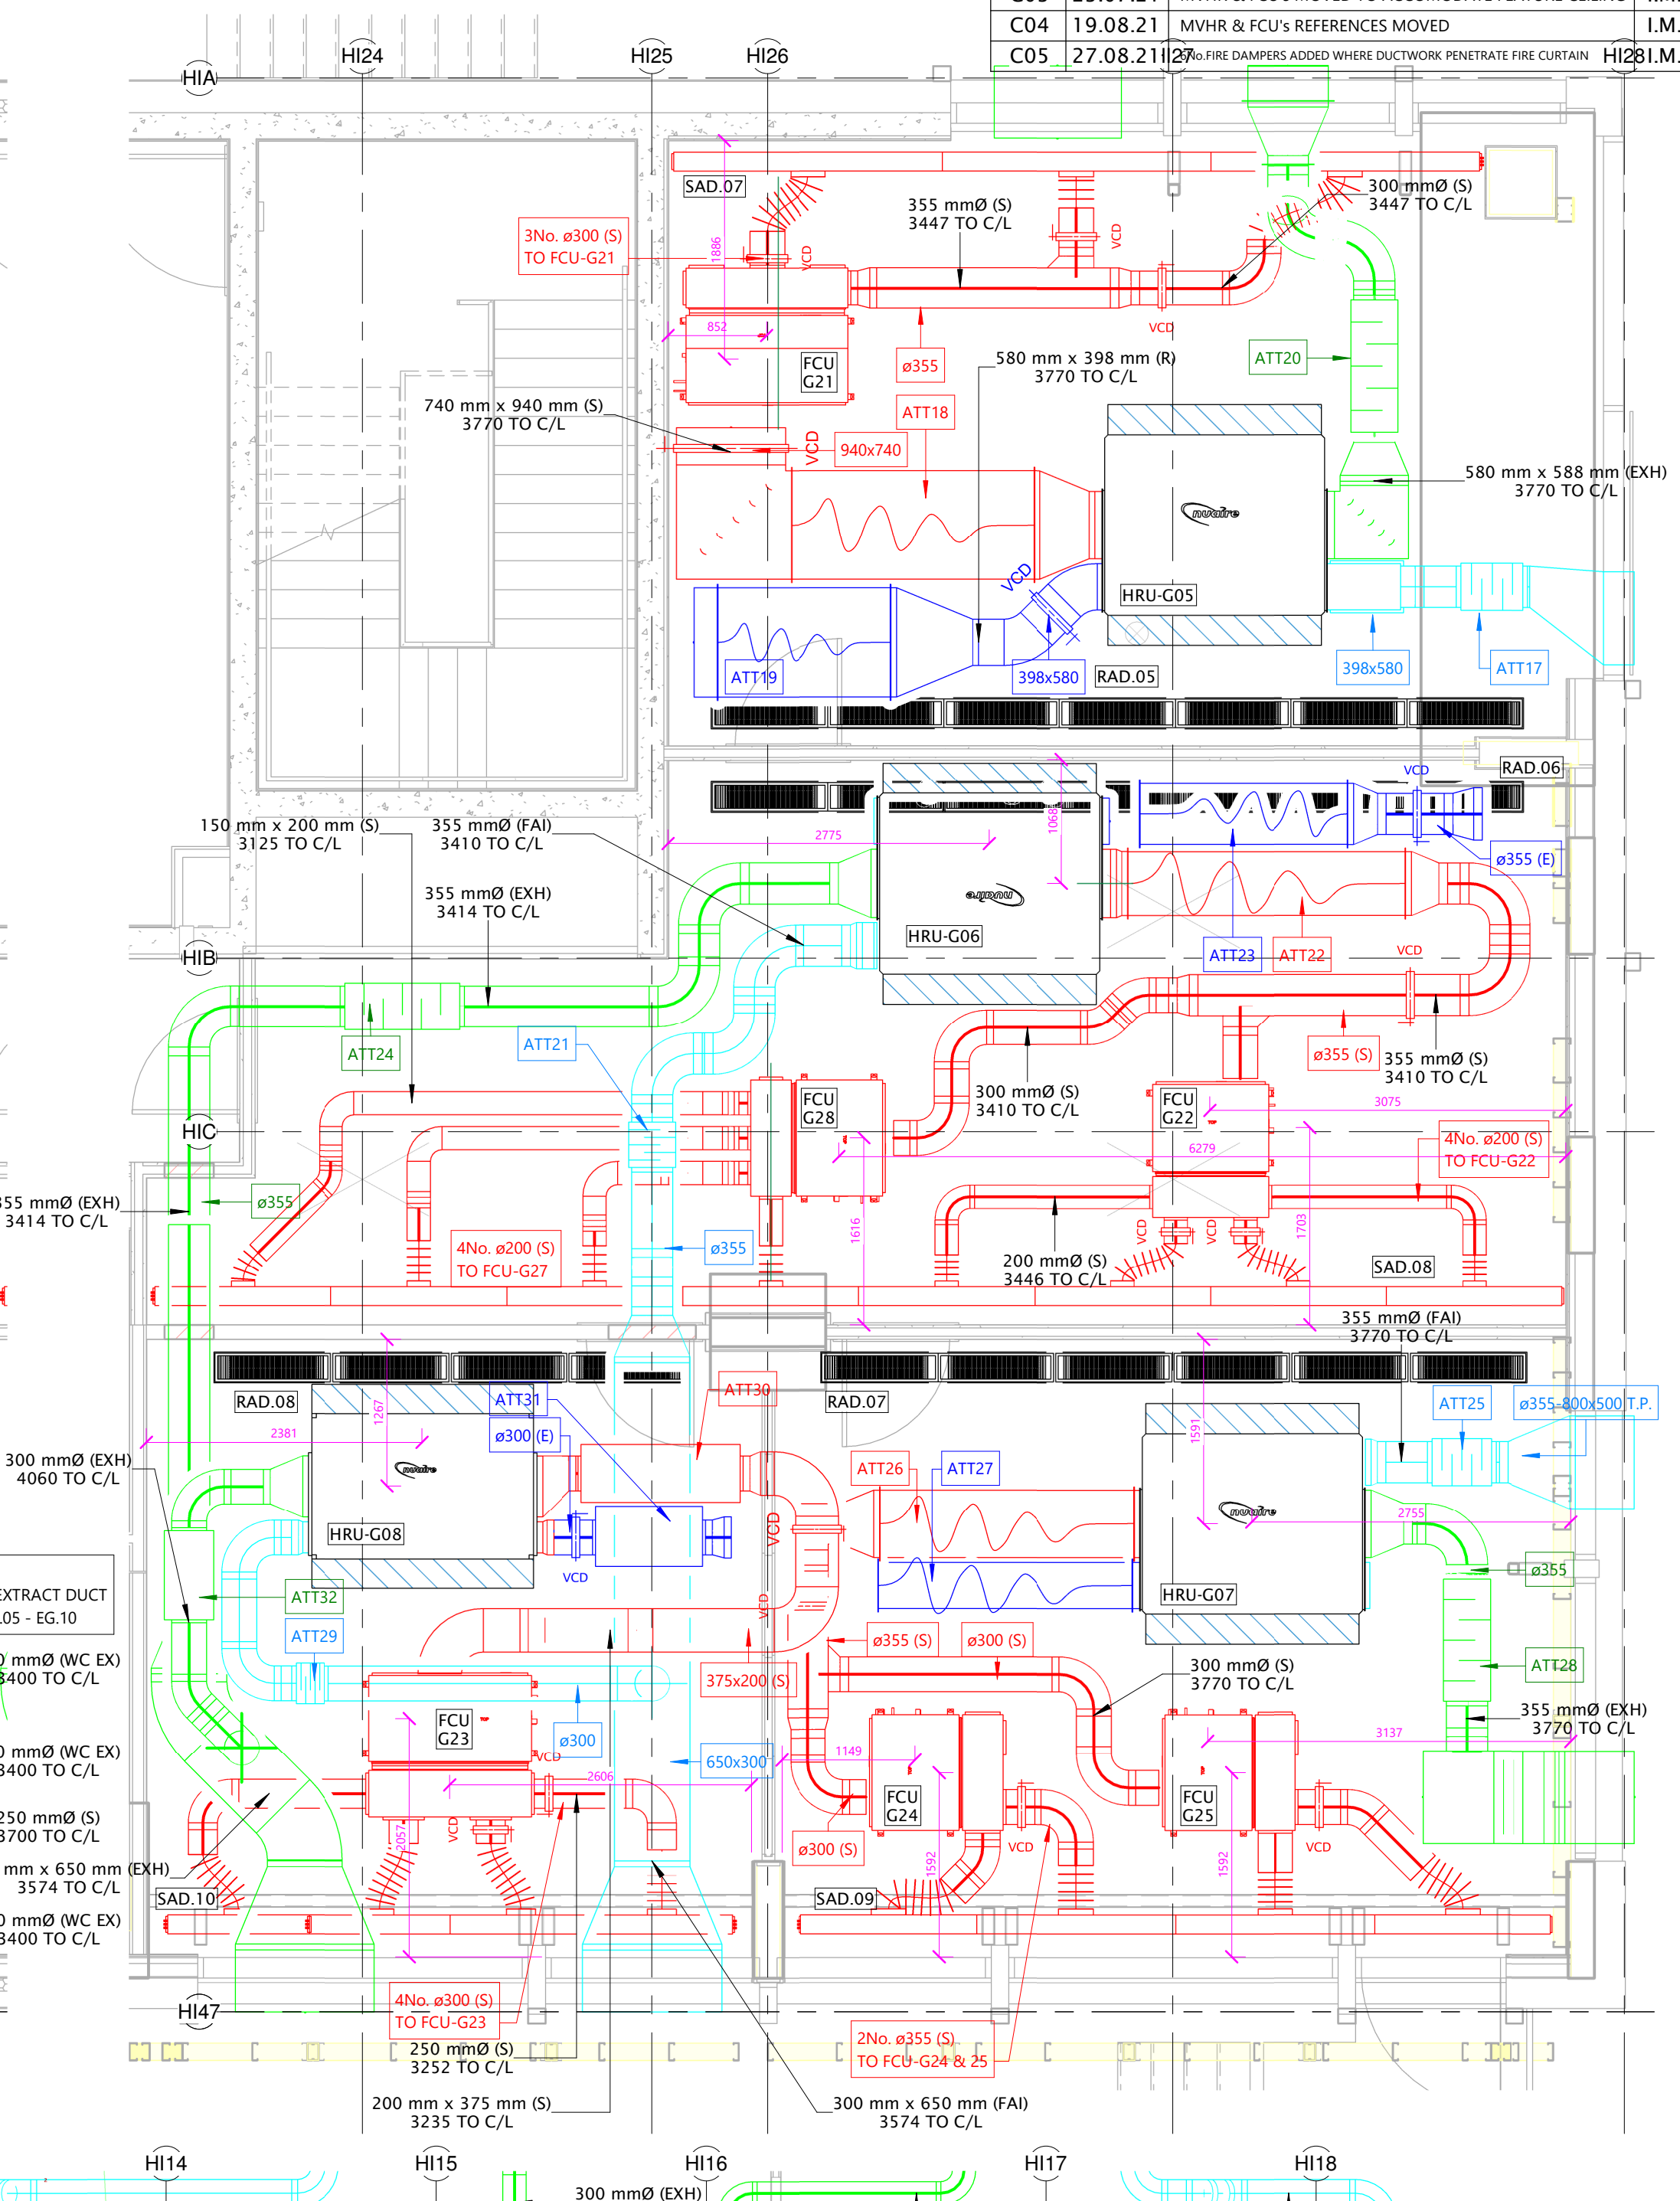


Ref.	Date	Revisions	By
P01	12.05.20	PRELIMINARY ISSUE	I.M.
C01	26.03.21	CONSTRUCTION ISSUE	I.M.
C02	21.06.21	INVERT LEVELS ADDED	I.M.
C03	23.07.21	MVHR & FCU'S MOVED TO ACCOMMODATE FEATURE CEILING	I.M.
C04	19.08.21	MVHR & FCU'S REFERENCES MOVED	I.M.
C05	27.08.21	20% FIRE DAMPERS ADDED WHERE DUCTWORK PENETRATES FIRE CURTAIN	H28 I.M.


LEVEL 00 - PLAN VIEW - SCALE 1:50

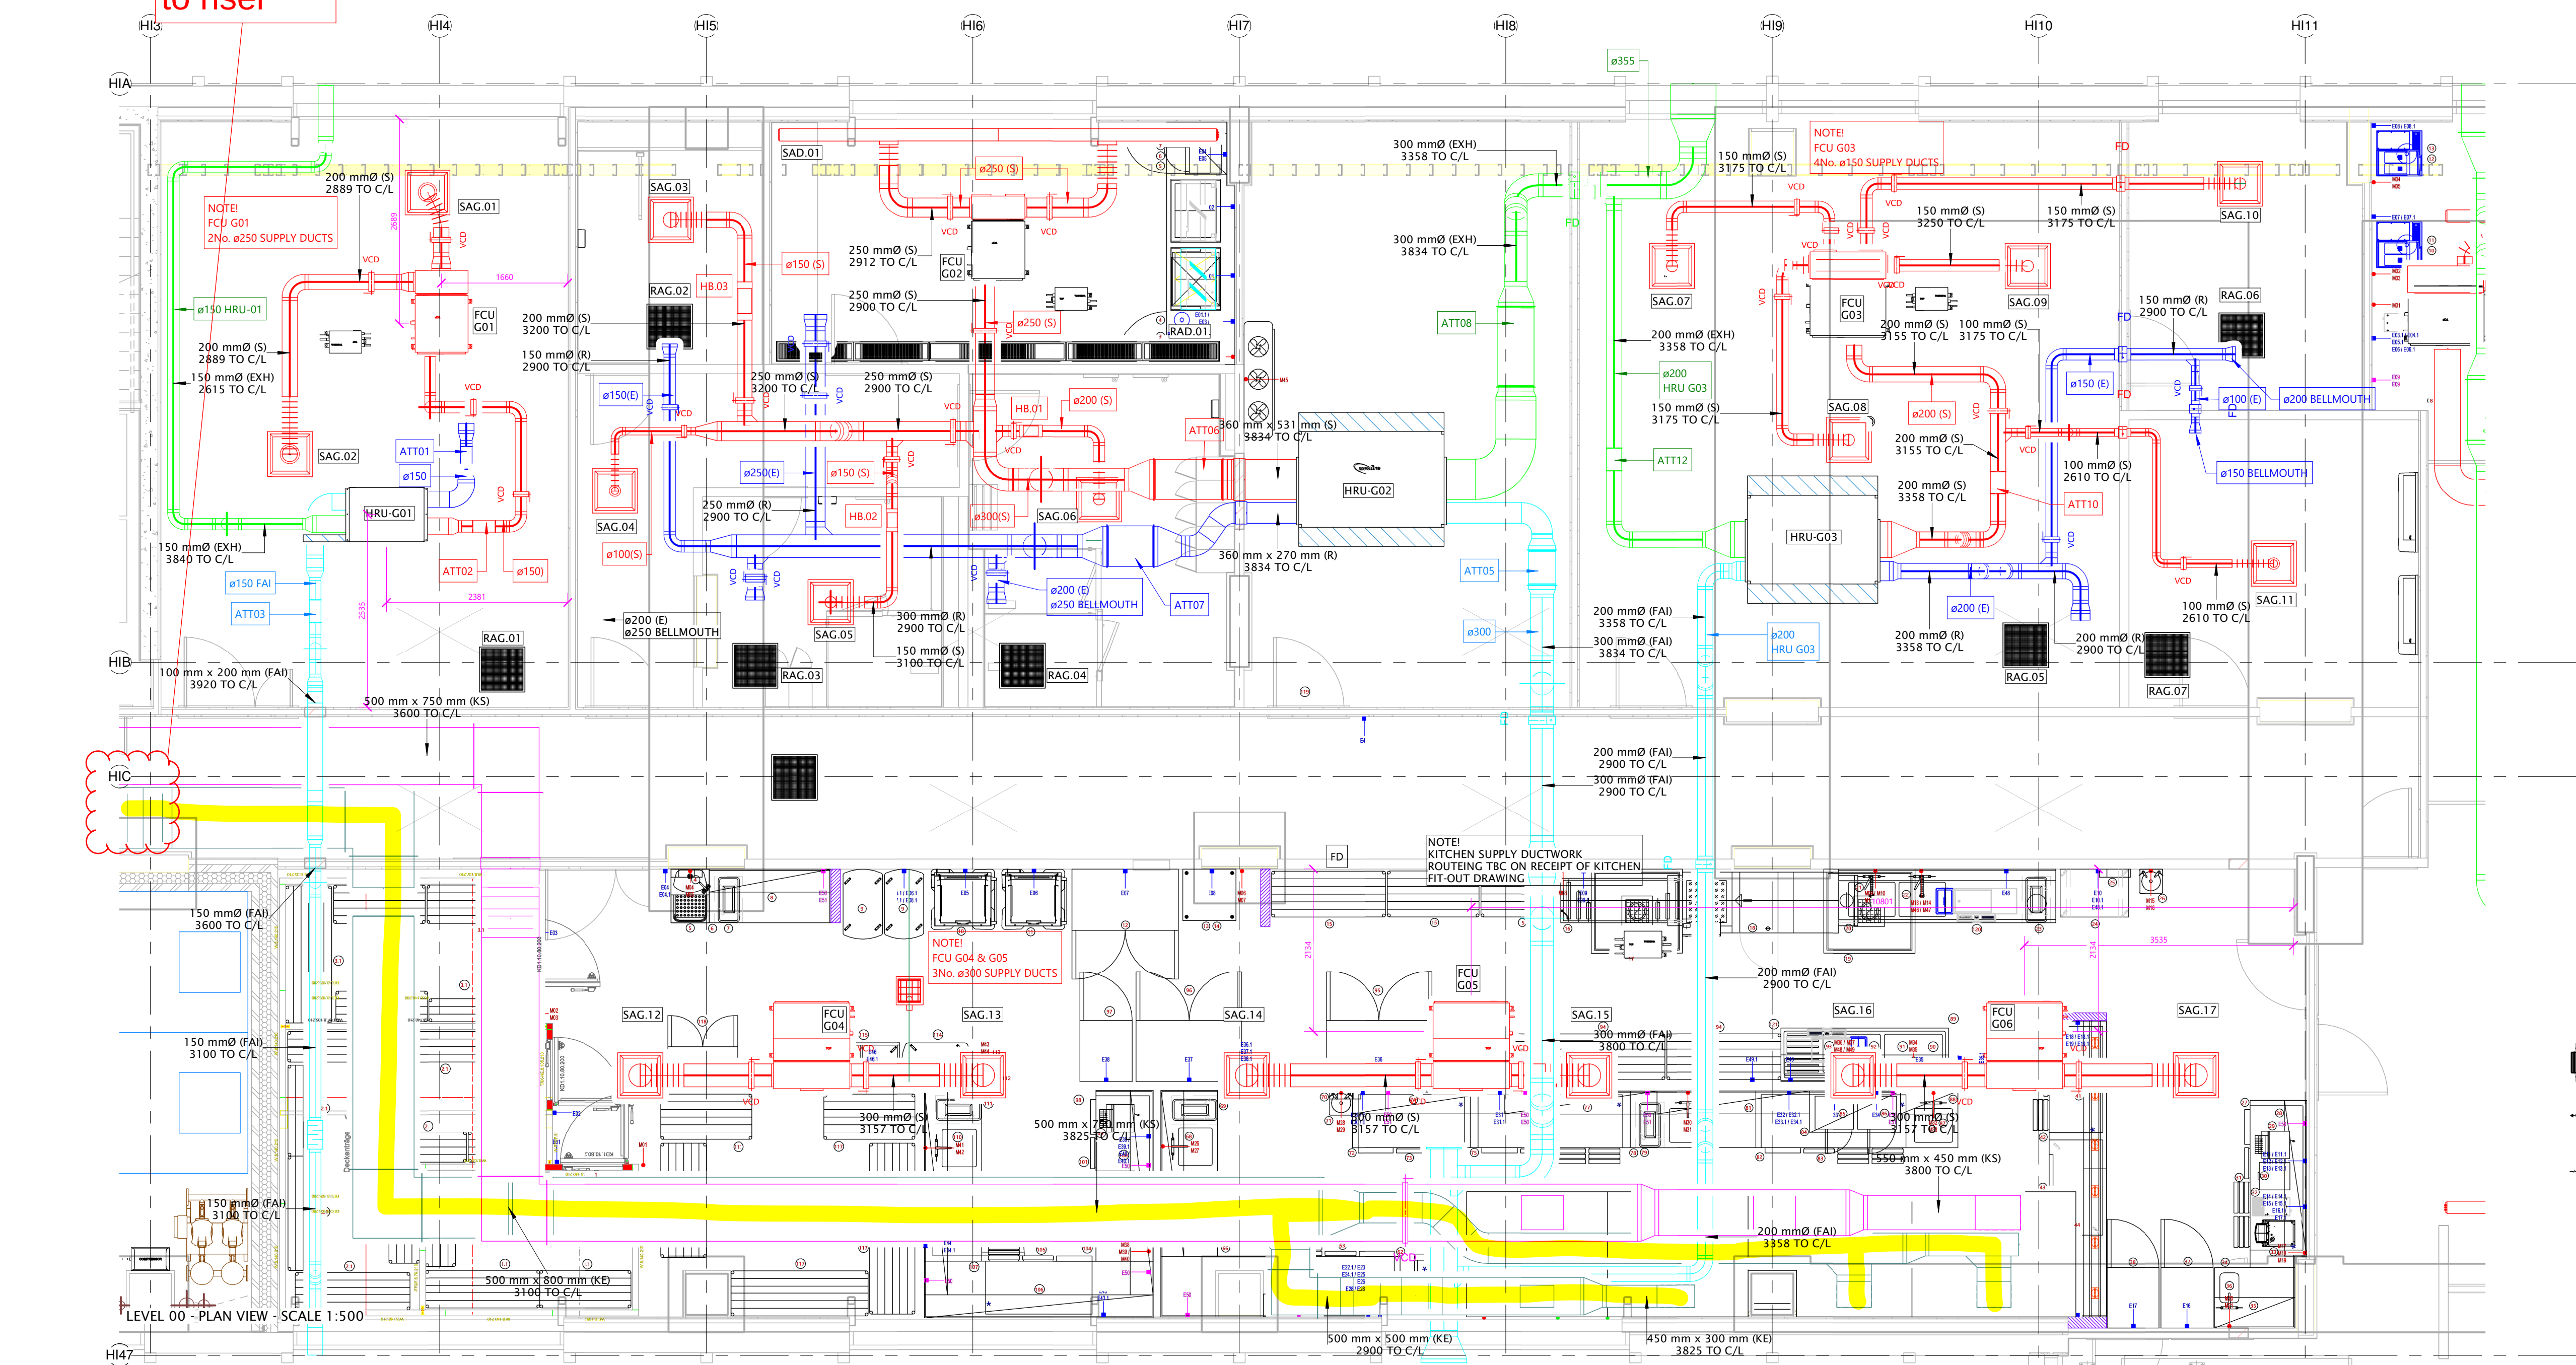

LEVEL 00 - PLAN VIEW - BABAJI RESTAURANT

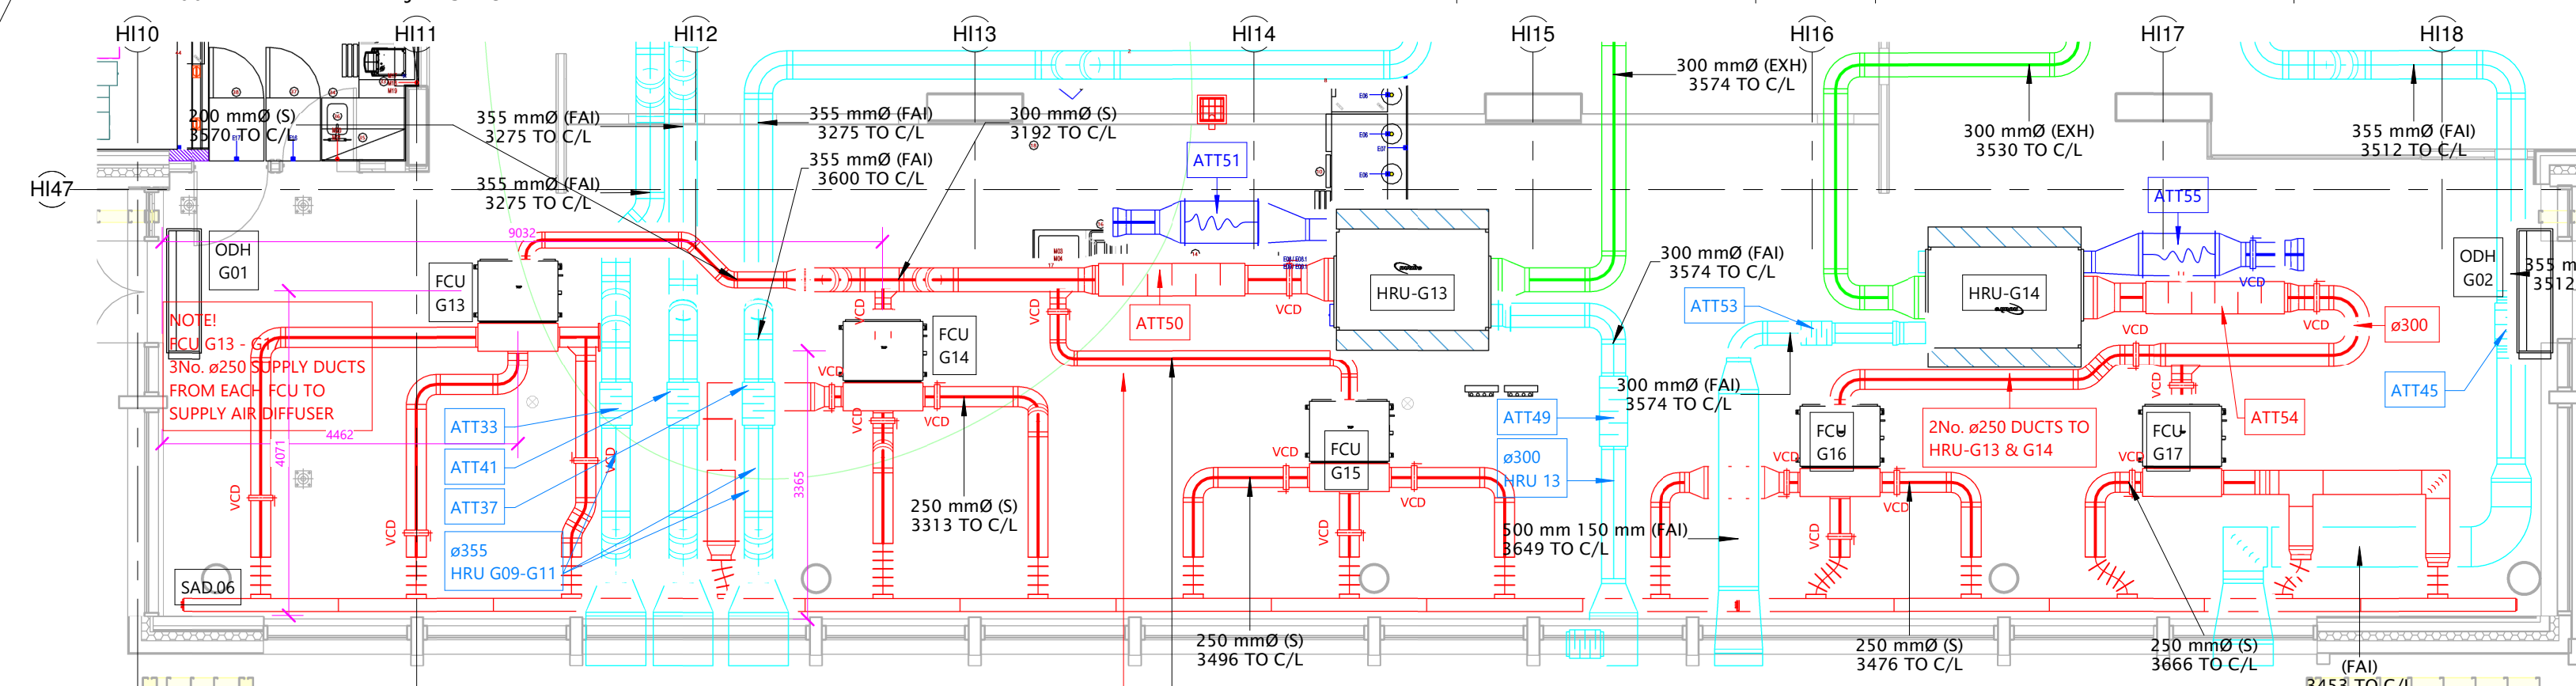

LEVEL 00 - PLAN VIEW - FLOOR PLAN

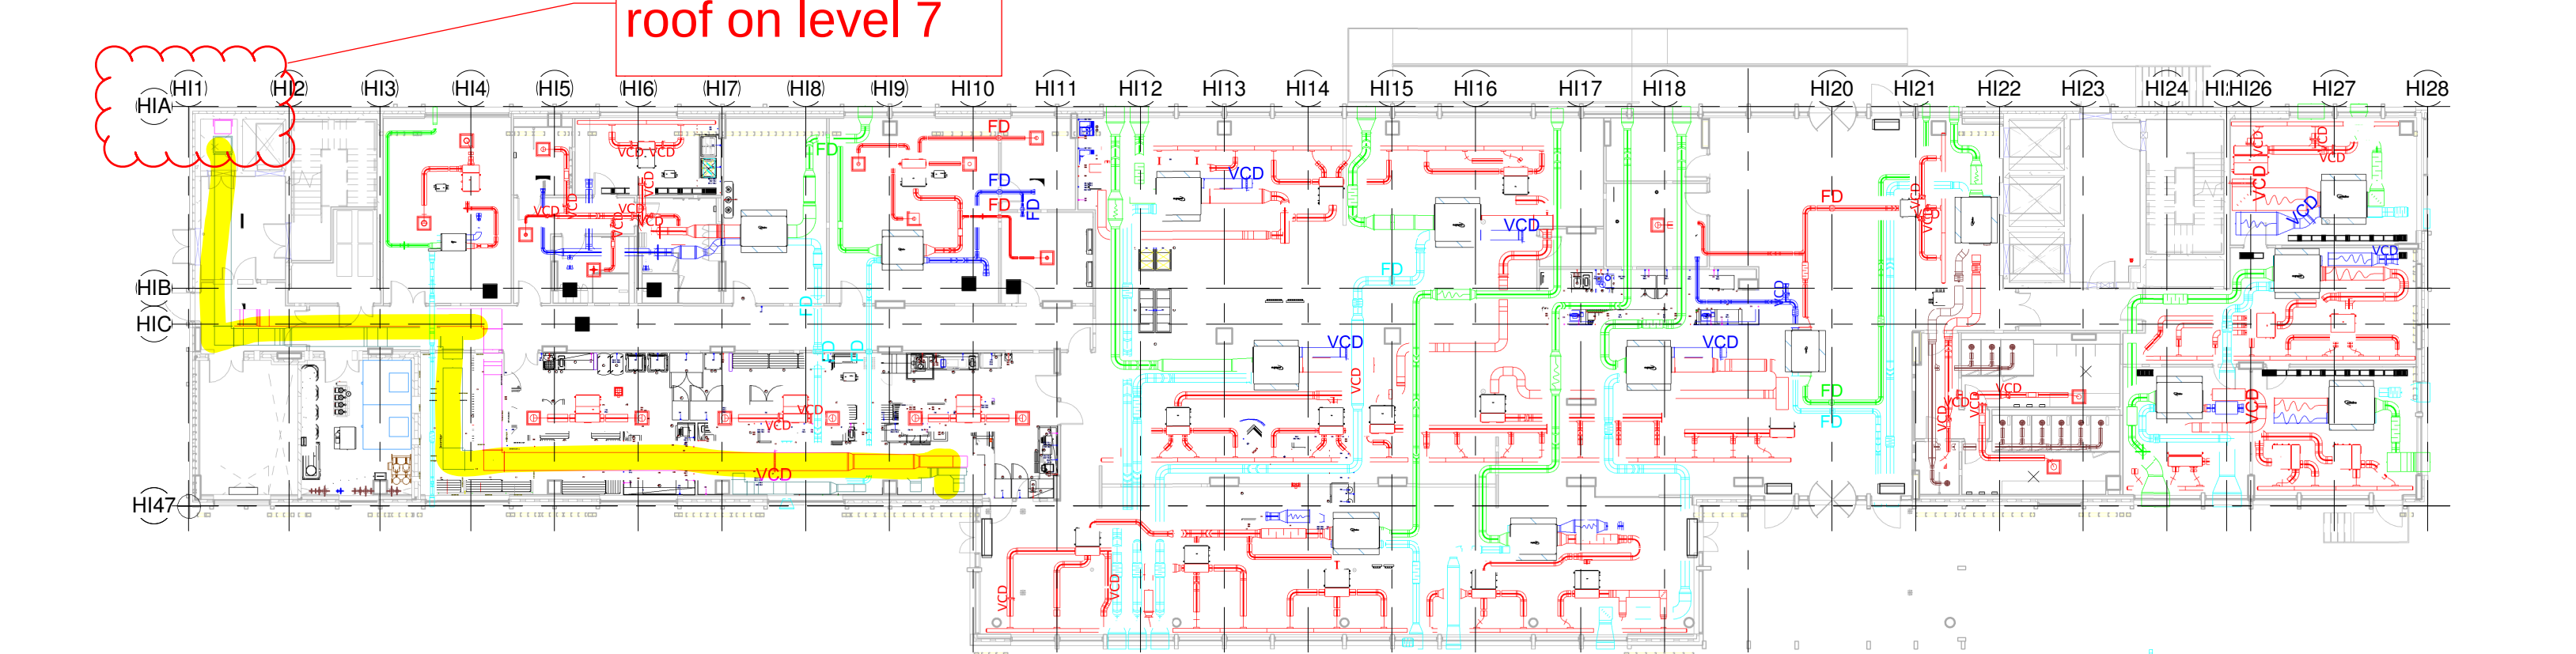

VENTILATION LEGEND:

- MECHANICAL VENTILATION HEAT RECOVERY UNIT
- INLINE EXTRACT FAN
- SUPPLY AIR GRILLE
- EXTRACT AIR GRILLE
- SUPPLY AIR VALVE
- EXTRACT AIR VALVE
- CEILING ACCESS HATCH FOR VCD ACCESS
- VCD - VOLUME CONTROL DAMPER
- FD - FIRE DAMPER

DUCTWORK KEY:

- SUPPLY DUCT
- EXTRACT DUCT
- EXHAUST DUCT
- FRESH AIR INTAKE DUCT
- WC EXTRACT

GENERAL NOTES:

- ALL DIMENSIONS ARE IN MILLIMETRES UNLESS OTHERWISE STATED.
- INSULATION INSTALLED ON ALL F.A.I. AND EXHAUST DUCTWORK.
- W.C. DOORS ARE UNDERCUT TO PROVIDE VENTILATION PATH ROUTES (10mm).
- ACCESS PANELS INSTALLED AS PER SECTION 20 & TABLE 25 OF DW/144 DOCUMENT.
- TO BE READ IN CONJUNCTION WITH 50 SERIES GUEST ROOM LAYOUTS

NOTE:
USE IN CONJUNCTION WITH THE FOLLOWING DRAWING:
MC1044-AME-HI-ZZ-M-57-007 - VENTILATION SCHEMATIC
MC1044-AME-HI-00-M-57-016 - LEVEL 00 - EXTERNAL LOUVRE BUILDERSWORK OPENING DETAILS
MC1044-AME-HI-07-M-57-017 - LEVEL 07 - EXTERNAL LOUVRE BUILDERSWORK OPENING DETAILS
MC1044-AME-HI-XX-M-57-018 - VENTILATION SCHEDULE DETAILS

DUCTWORK ACCESS PANELS INSTALLED AS BELOW:

- VOLUME CONTROL DAMPERS: BOTH SIDES
- ATTENUATORS: BOTH SIDES
- INLINE FAN: ONE SIDE
- CHANGE OF DIRECTION: ONE SIDE
- INLET / EXHAUST LOUVRE: ONE SIDE
- FIRE DAMPERS: BO

CONSTRUCTION ISSUE

0m 2m 4m 6m 8m 10m

VISUAL SCALE 1:100 @ A0



ACN P1 - HOLIDAY INN

Level 00 - Ventilation & AC Layout

ameon
Building Services Engineering
Unit 9-10 Olympic Court, Boardmans Way,
Whitehills Business Park, Blackpool, FY4 5GU
Tel: 01253 780160
E-mail: info@ameon.co.uk

Date	MAY 2020	Scale	As indicated	Drawn by	I.M.	Check by	I.M.
Drawing Number	API-AME-HI-00-DR-M-57-0001	Revision	C05				