


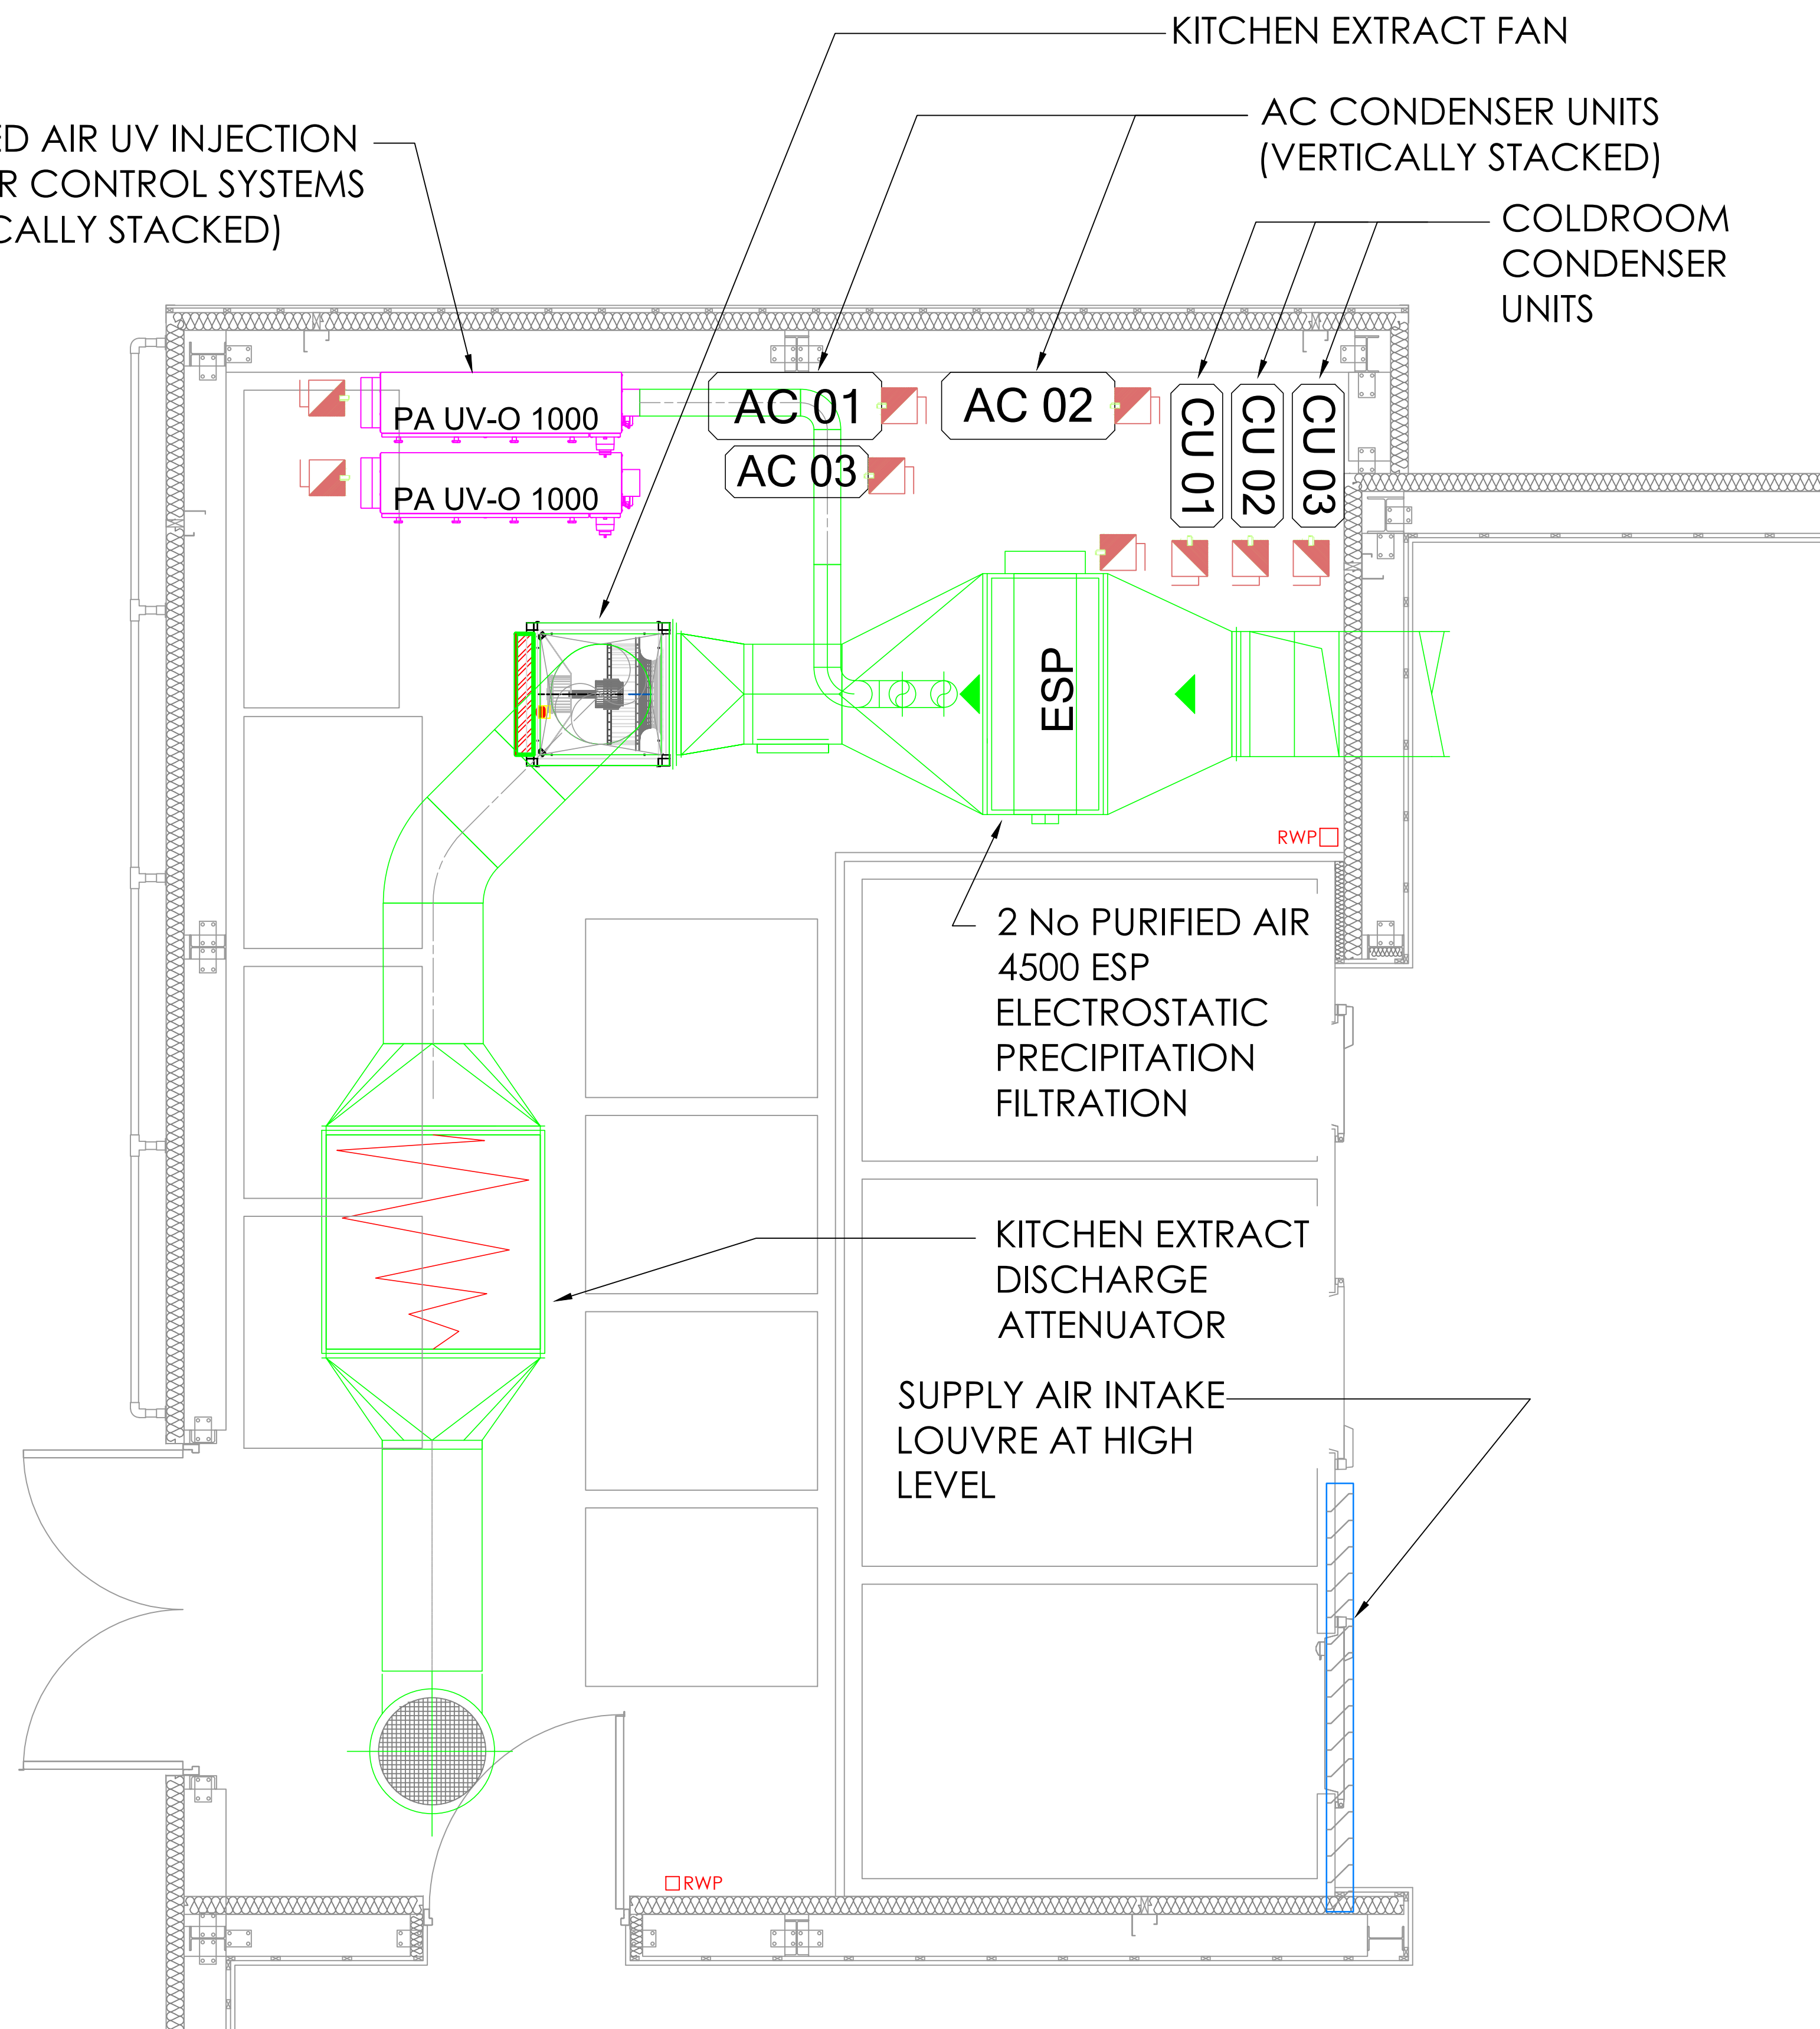

- NOTES
1. ALL DUCTWORK TO BE MANUFACTURED IN ACCORDANCE WITH HVCA DW 144.
 2. ALL PENETRATIONS EXTERNAL TO CONCESSION BY MAIN CONTRACTOR COMPLETE WITH FIRESTOPPING.
 3. CONTRACTOR TO INCLUDE FOR CO-ORDINATING HIS WORK WITH ALL OTHER TRADES.
 4. ALL DUCTWORK PASSING THROUGH FIRE WALLS TO BE COMPLETE WITH FIRE/SMOKE DAMPERS INCLUDING BUILDING IN FRAMES.
 5. ALL NEW DUCTWORK TO BE COMPLETE WITH ACCESS PANELS AT REGULAR INTERVALS FOR CLEANING. ACCESS PANELS TO BE PROVIDED AT 3 METRE INTERVALS & AT ALL BRANCH CONNECTIONS. ACCESS PANELS TO BE PROVIDED BOTH SIDES OF FIRE/SMOKE DAMPERS & VOLUME CONTROL DAMPERS.
 6. ALL GRILLES & DIFFUSERS TO BE SUPPORTED INDEPENDENTLY OF THE FALSE CEILING GRID.
 7. THE FIRE/SMOKE DAMPER INSTALLATION METHOD MUST HAVE BEEN TESTED AND COMPLY WITH BSEN 1366-2 AND DW145. CONTRACTOR TO CHECK DAMPER MANUFACTURERS LATEST TESTED AND APPROVED INSTALLATION METHODS PRIOR TO INSTALLATION.
 8. FINAL CONNECTIONS TO GRILLES/DIFFUSERS & LOUVRE MAY BE CARRIED OUT IN FLEXIBLE DUCTWORK TO A MAXIMUM LENGTH OF 500mm.

ELECTRICAL AND MECHANICAL FITTINGS AND/OR APPLIANCES, CONDUITS, PIPES, DUCTS, CABLES, ETC ARE INDICATED FOR TENDERING PURPOSES AND GUIDANCE DURING INSTALLATION. EXACT POSITIONS AND ROUTES SHALL BE SETTLED ON SITE IN RELATION TO OTHER SERVICES AND FIXTURES AND TO THE ARCHITECTS DETAILED ROOM LAYOUTS WHERE ISSUED OR APPROPRIATE, OR WHERE DIMENSIONS ARE GIVEN (ON THE DRAWING OR IN THE SPECIFICATION). FINAL POSITIONS OF LIGHTING, POINTS, MECHANICAL AND ELECTRICAL FITTINGS, FIXTURES AND/OR APPLIANCES MUST BE CHECKED WITH THE CLIENT OR HIS REPRESENTATIVE BEFORE PROCEEDING.

This Drawing is copyright of DENMECH LTD and should not be reproduced without permission. All dimensions should be checked on site and any discrepancies notified prior to the commencement of work.

LEGEND

SWIRL SUPPLY DIFFUSER

EXTRACT VALVE

VOLUME CONTROL DEVICE

V-C VENTILATION CONTROLLER

AC-C AC CONTROLLER

AC 02/1 EQUIPMENT REFERENCE

ISOLATOR

REV.	DETAIL OF AMENDMENT	QA'D BY	DATE
P01	PRELIMINARY ISSUE	MD	19.11.21

GROSS INTERNAL AREAS (SQ.M)

GIA BUILDING	SITE AREA

BASIS OF DRAWING: **PRELIMINARY**

NOTES:

SITE ADDRESS
TESCO CAR PARK, ALTRINCHAM ROAD,
BAGULEY, MANCHESTER, M23 9TJ

PROJECT
KFC DT BAGULEY

DRAWING TITLE
EXTERNAL MECHANICAL PLANT LAYOUT

PROJECT NO.	DRWG NO.	DRAWN BY
J1010	DML-XX-GF-DR-M-5001	CB

SCALE	CHECK'D BY	DATE	REVISION
1:25 @ A1	MD	19.11.21	P01

KEY PLAN
(Scale 1:200 @A1)

