


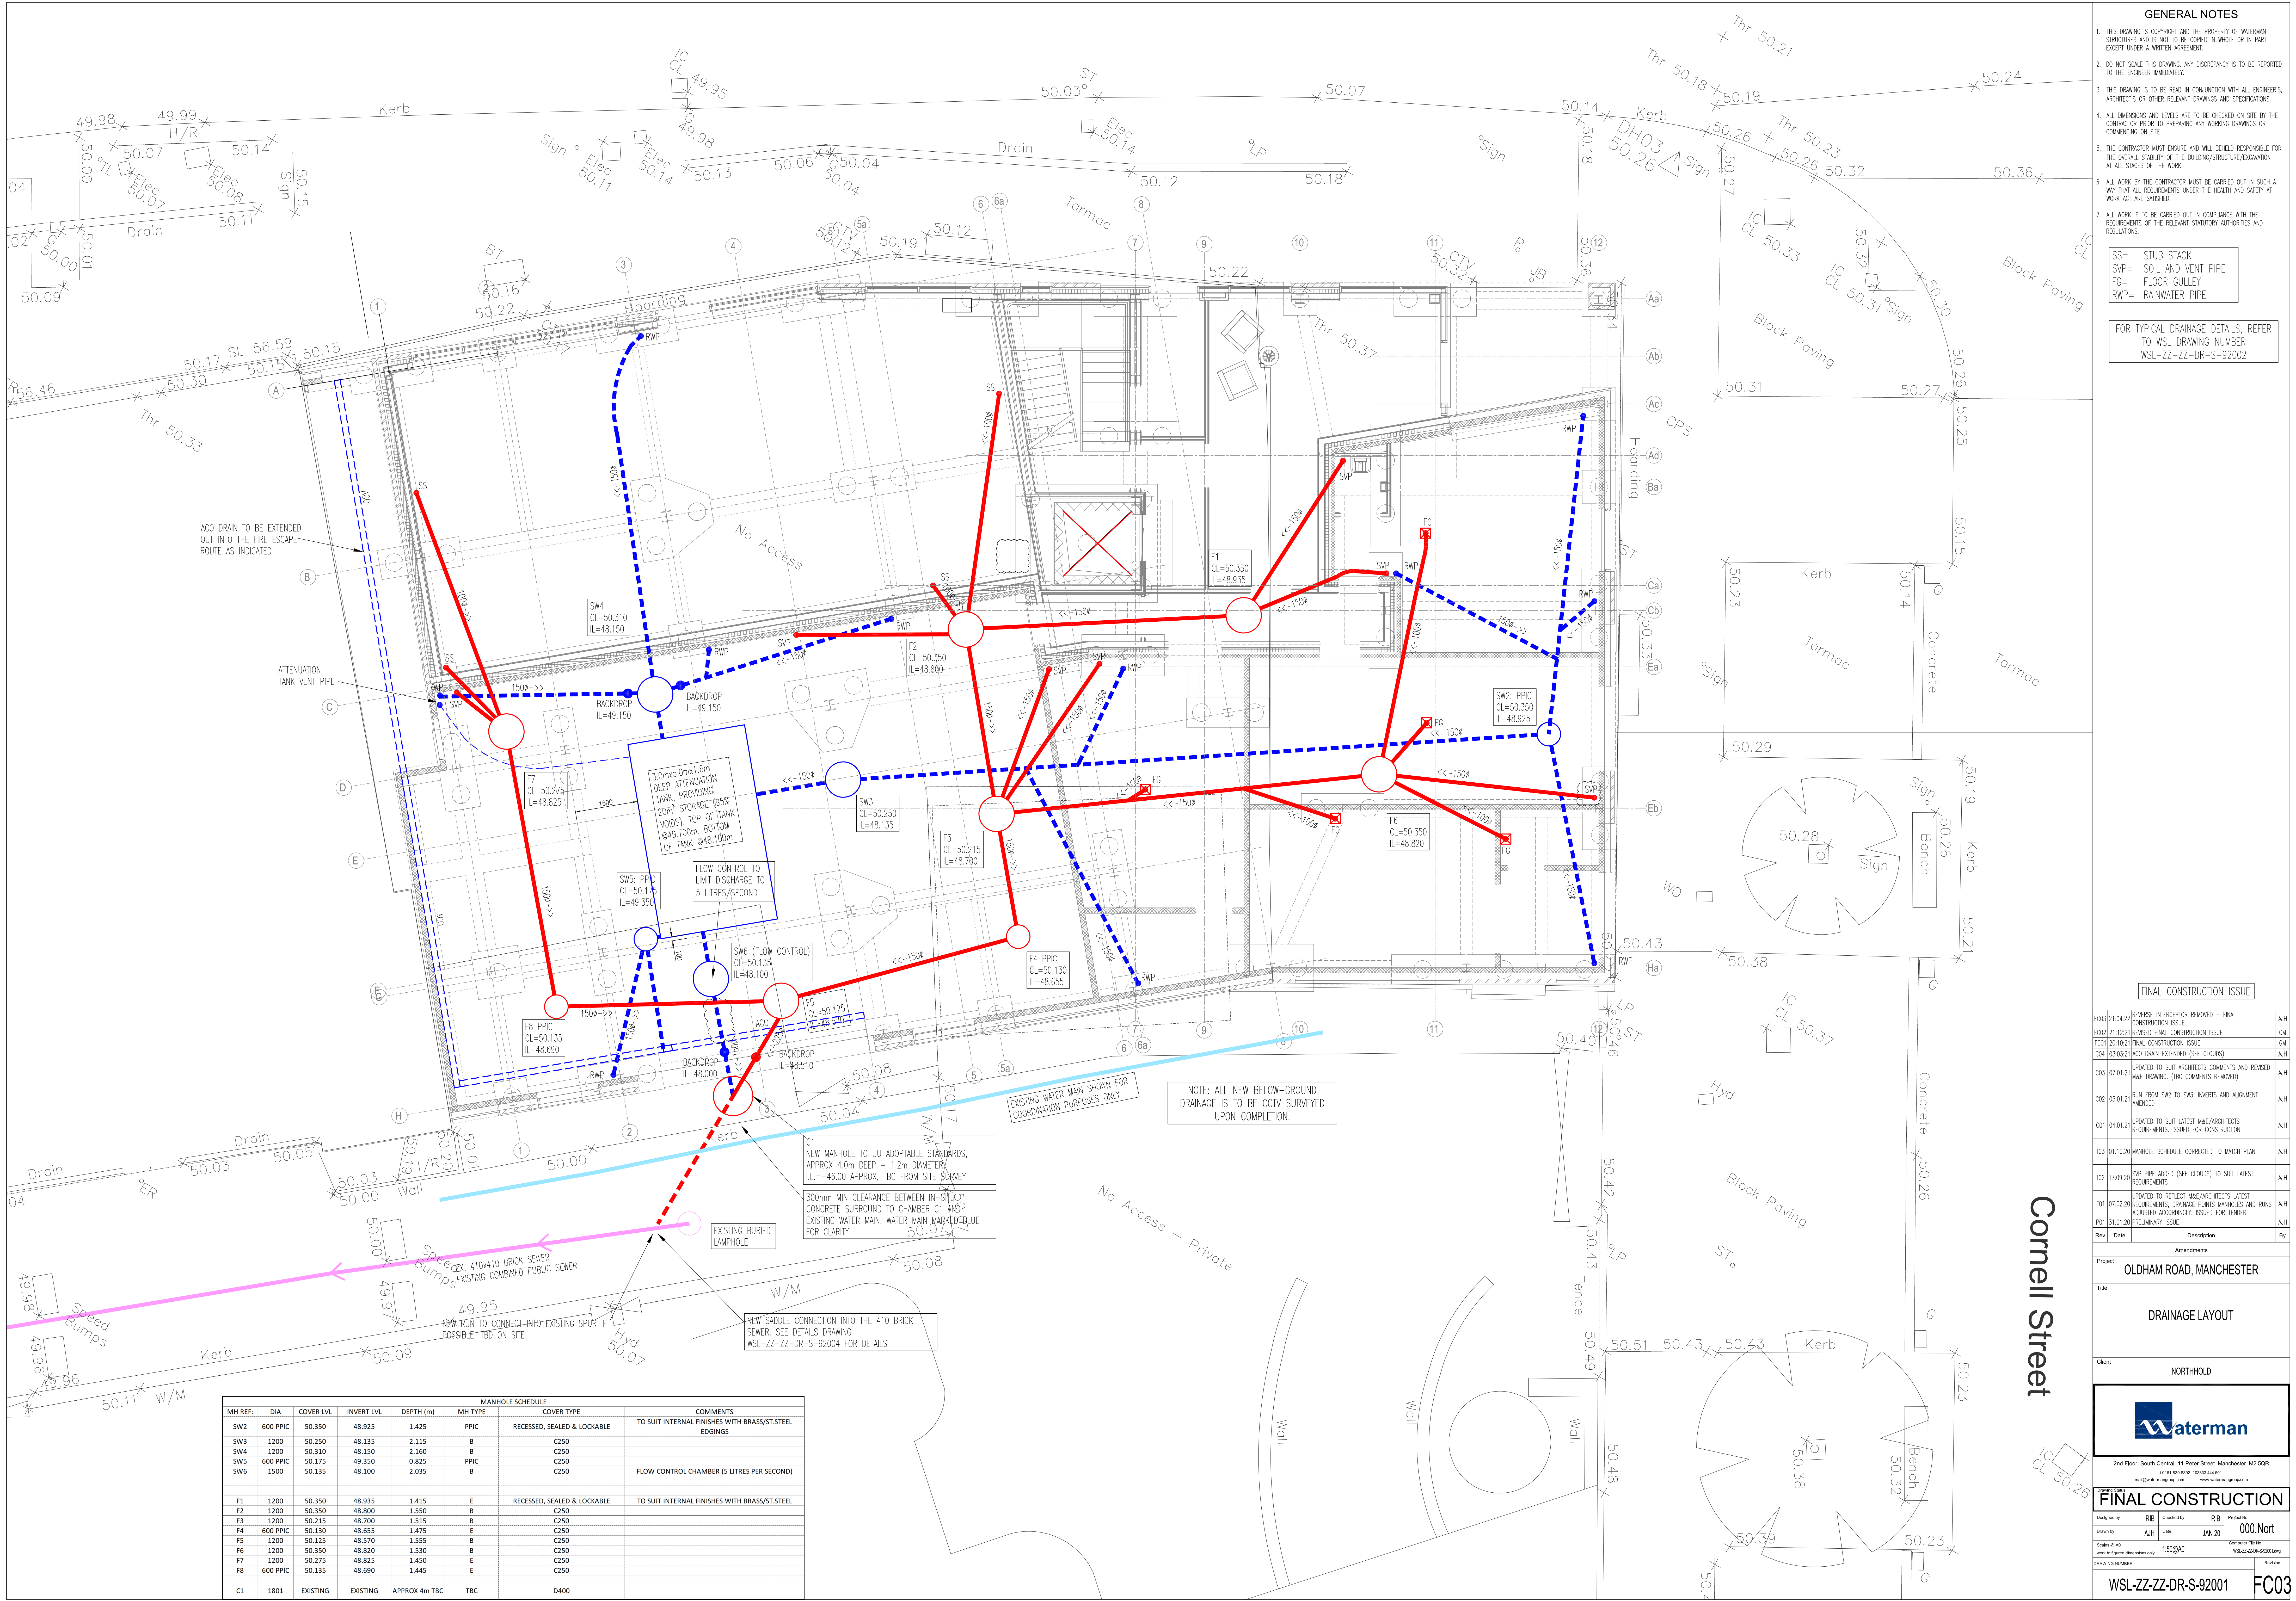

GENERAL NOTES

1. THIS DRAWING IS COPYRIGHT AND THE PROPERTY OF WATERMAN STRUCTURES AND IS NOT TO BE COPIED IN WHOLE OR IN PART EXCEPT UNDER A WRITTEN AGREEMENT.

2. DO NOT SCALE THIS DRAWING. ANY DISCREPANCY IS TO BE REPORTED TO THE ENGINEER IMMEDIATELY.

3. THIS DRAWING IS TO BE READ IN CONJUNCTION WITH ALL ENGINEER'S, ARCHITECT'S OR OTHER RELEVANT DRAWINGS AND SPECIFICATIONS.

4. ALL DIMENSIONS AND LEVELS ARE TO BE CHECKED ON SITE BY THE CONTRACTOR PRIOR TO PREPARING ANY WORKING DRAWINGS OR COMMENCING ON SITE.

5. THE CONTRACTOR MUST ENSURE AND WILL BE HELD RESPONSIBLE FOR THE OVERALL STABILITY OF THE BUILDING/STRUCTURE/EXCAVATION AT ALL STAGES OF THE WORK.

6. ALL WORK BY THE CONTRACTOR MUST BE CARRIED OUT IN SUCH A WAY THAT ALL REQUIREMENTS UNDER THE HEALTH AND SAFETY AT WORK ACT ARE SATISFIED.

7. ALL WORK IS TO BE CARRIED OUT IN COMPLIANCE WITH THE REQUIREMENTS OF THE RELEVANT STATUTORY AUTHORITIES AND REGULATIONS.

SS= STUB STACK

SVP= SOIL AND VENT PIPE

FG= FLOOR GULLEY

RWP= RAINWATER PIPE

FOR TYPICAL DRAINAGE DETAILS, REFER TO WSL DRAWING NUMBER WSL-ZZ-ZZ-DR-S-92002

FINAL CONSTRUCTION ISSUE

FC03	21.04.22	REVERSE INTERCEPTOR REMOVED - FINAL CONSTRUCTION ISSUE	AJH
FC02	21.12.21	REVISED FINAL CONSTRUCTION ISSUE	CM
FC01	20.10.21	FINAL CONSTRUCTION ISSUE	CM
C04	03.03.21	ACO DRAIN EXTENDED (SEE CLOUDS)	AJH
C03	07.01.21	UPDATED TO SUIT ARCHITECTS COMMENTS AND REVISED WAE DRAWING. (TBC COMMENTS REMOVED)	AJH
C02	05.01.21	RAN FROM SW2 TO SW3 INVERTS AND ALIGNMENT AMENDED	AJH
C01	04.01.21	UPDATED TO SUIT LATEST WAE/ARCHITECTS REQUIREMENTS. ISSUED FOR CONSTRUCTION	AJH
T03	01.10.20	MANHOLE SCHEDULE CORRECTED TO MATCH PLAN	AJH
T02	17.09.20	SVP PIPE ADDED (SEE CLOUDS) TO SUIT LATEST REQUIREMENTS	AJH
T01	07.02.20	UPDATED TO REFLECT WAE/ARCHITECTS LATEST REQUIREMENTS. DRAINAGE POINTS MANHOLES AND RUNS ADJUSTED ACCORDINGLY. ISSUED FOR TENDER	AJH
P01	31.01.20	PRELIMINARY ISSUE	AJH
Rev	Date	Description	By

Project

OLDHAM ROAD, MANCHESTER

Title

DRAINAGE LAYOUT

Client

NORTHOLD

2nd Floor South Central 11 Pater Street Manchester M2 5QR

15181 859 8392 • 03533 444 501

info@watermangroup.com • www.watermangroup.com

waterman

WATERMAN GROUP

FINAL CONSTRUCTION

Designed by	RIB	Checked by	RIB	Project No.	000.Nort
Drawn by	AJH	Date	JAN 20	Contract Ref No.	WSL-ZZ-ZZ-DR-S-92001
Scale (if any)	1:500@A0	Scale to be used on site only	1:500@A0	Revision	

DRAWING NUMBER WSL-ZZ-ZZ-DR-S-92001

FC03

Cornell Street