


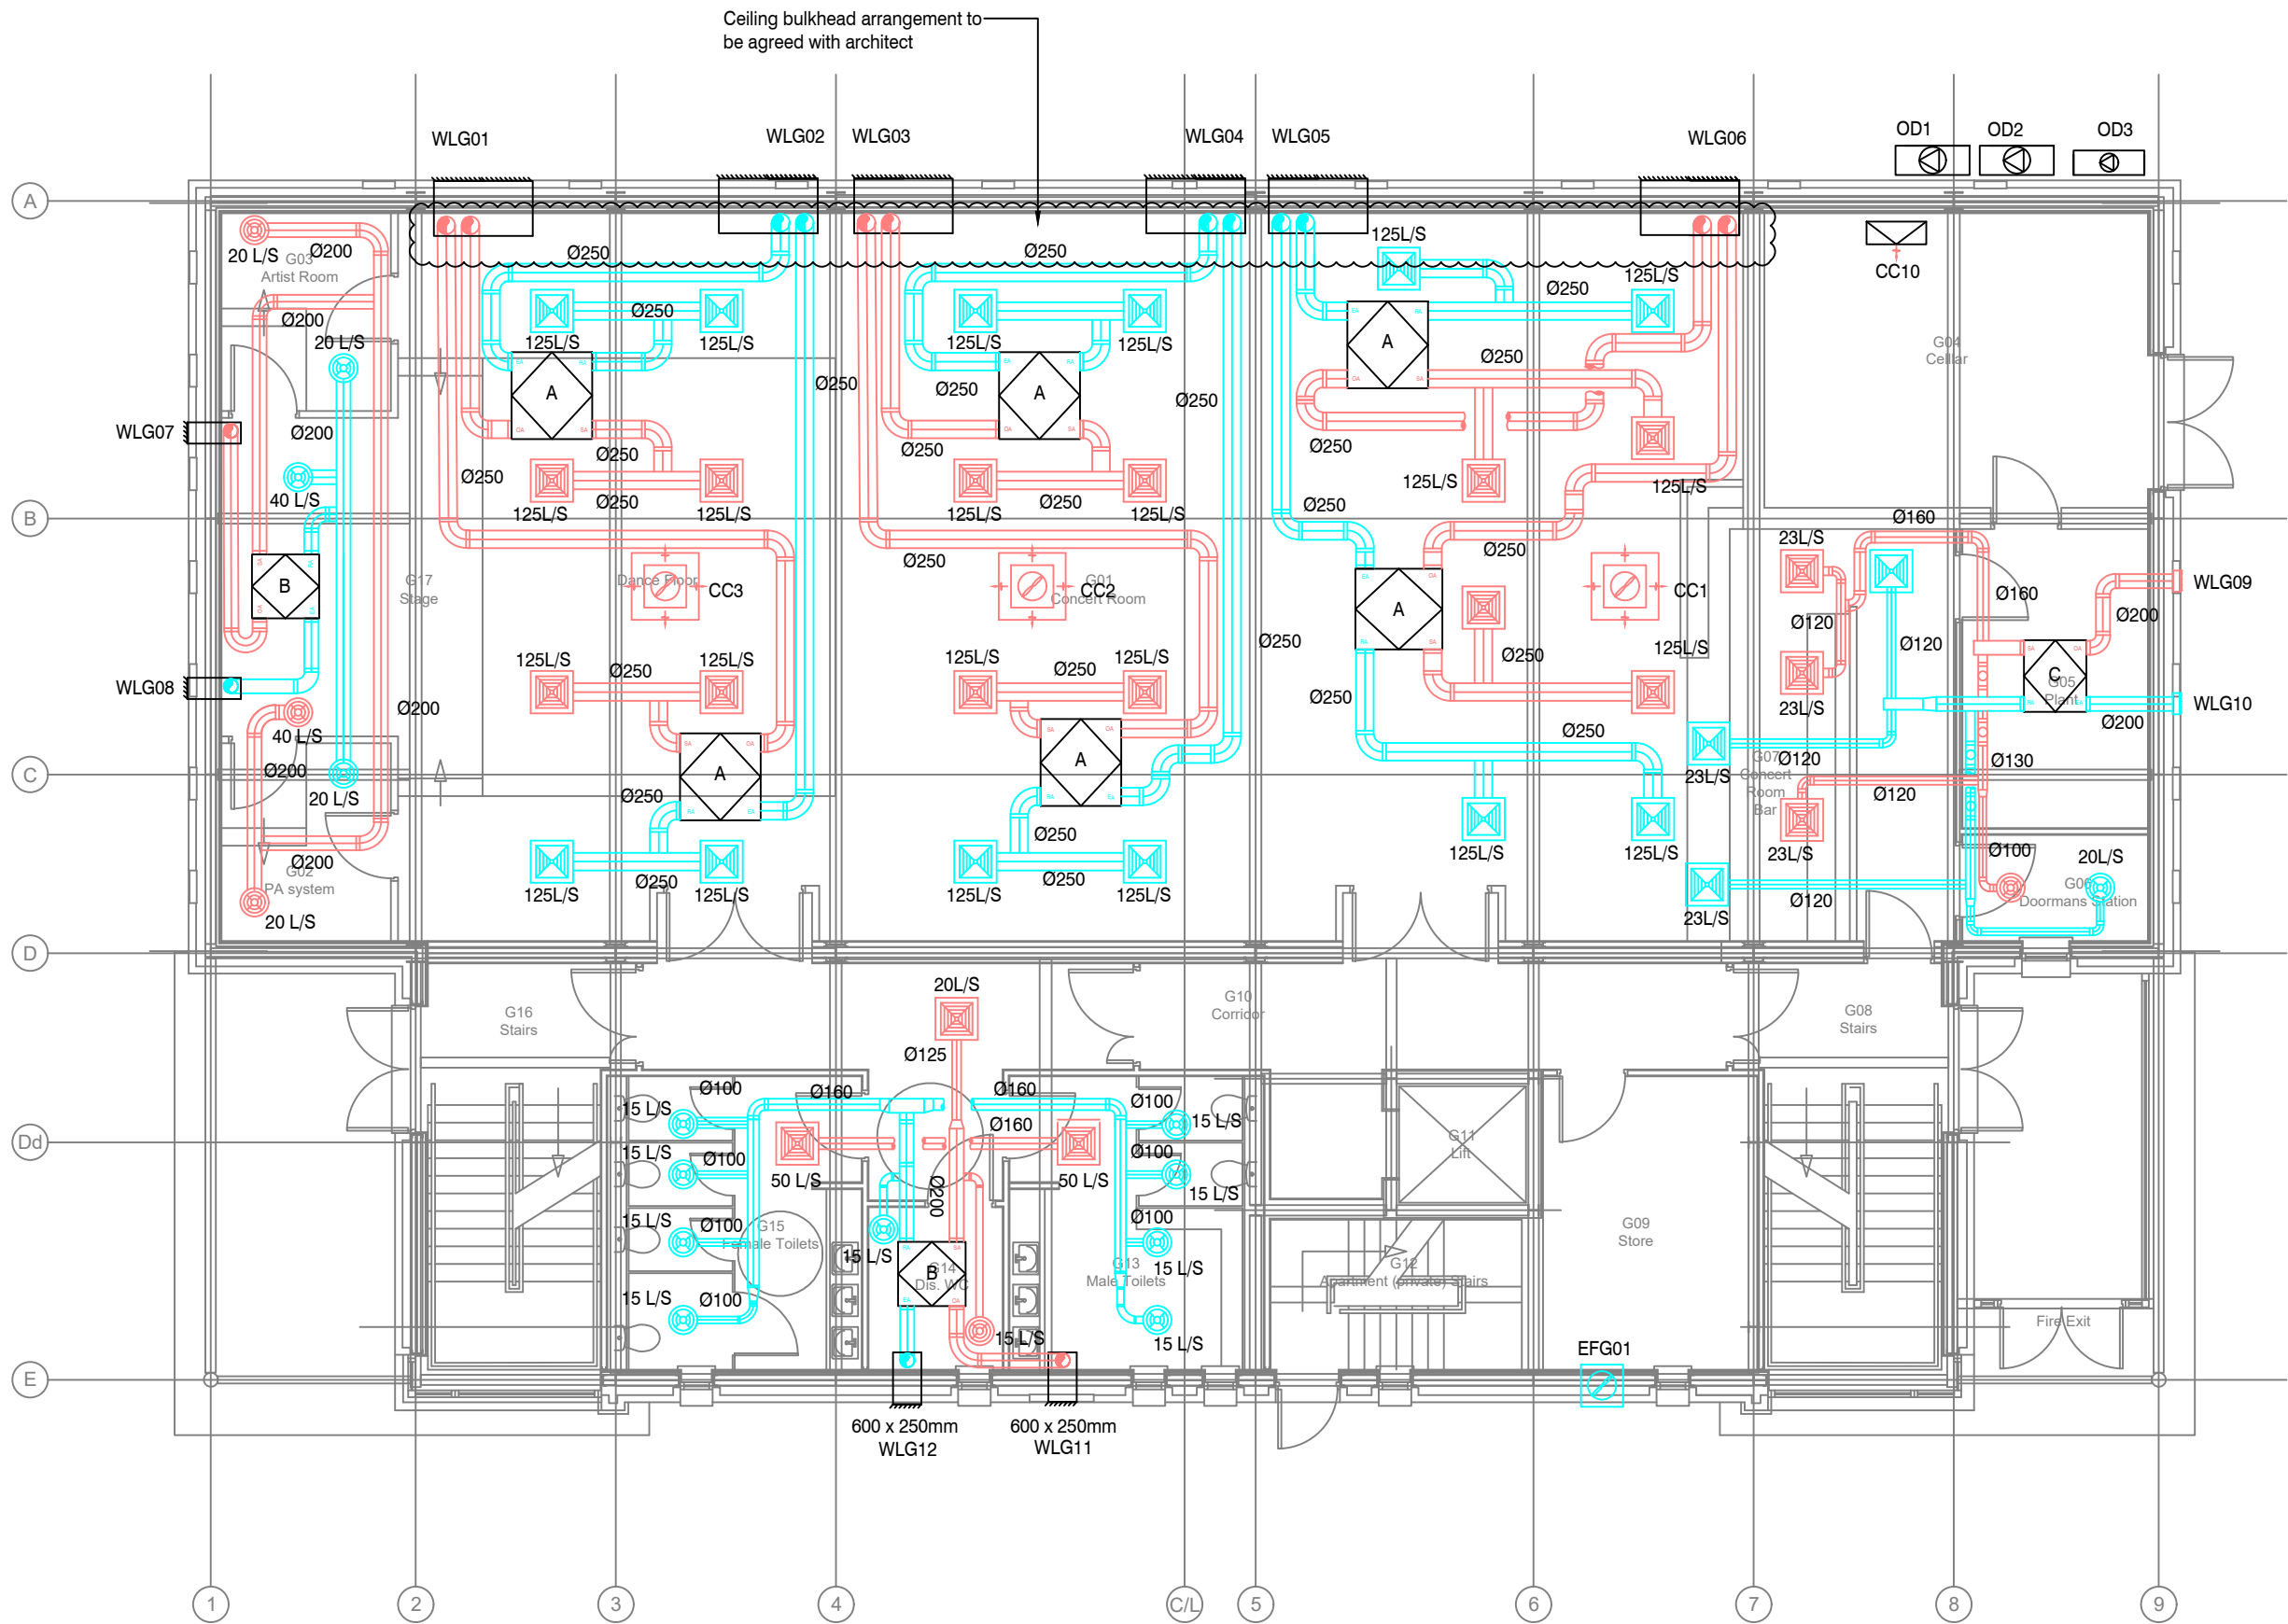

GENERAL NOTES

1. Drawings are to be read in conjunction with all relevant specifications, engineers, architects & services drawings, including approved builders work drawings. Contractor to notify engineer of discrepancies between structural drawings & specifications or other drawings.
2. All dimensions are in millimeters unless noted otherwise.
3. Do not scale from the drawings or the computer digital data, only figured dimensions are to be used.



This drawing and its contents are strictly the copyright of GLD



Certificate Number 16602-Q15-001
ISO 9001

LEGEND



HRU Mitsubishi Lossnay LGH100RVX-E



HRU Mitsubishi Lossnay LGH65RVX-E



HRU Mitsubishi Lossnay LGH50RVX-E



Comfort conditioner 4 way blow recessed unit PLTY 100VEM-E



Extract grille



Supply grille



Extract valve



Supply valve



Extractor fan



Plenum box with louver



Outdoor Condensing unit



Comfort conditioner (beer cellar)

T1	11.05.2021	Grilles modified	RW	PC
P3	27.11.2020	Updated to suit co-ordinated drawing	VG	PC
P2	16.10.2020	Updated to suit revised layout	VG	PC
P1	30.07.2020	Preliminary Issue	RW	PC
Rev:	Date:	Amendment:	Drawn:	Check:
Drwn:	RW	Date: 30.07.2020	Scale: 1:100 @ A3	
Chkd:	PC	Date: 30.07.2020	X Ref: 4050 - GA Club Base	

Client:



Project Title:
The Whitehouse Club

Drawing Title:
Ground Floor
HVAC Layout

Status:
TENDER



Damhouse, Astley Hall Drive
Astley, Manchester, M29 7TX
W: www.gldtechnicalconsulting.co.uk
T: 01942889535 / 01616417097

Drawing No:
J115-GLD-00-DR-M-5700-001

Rev:
T1