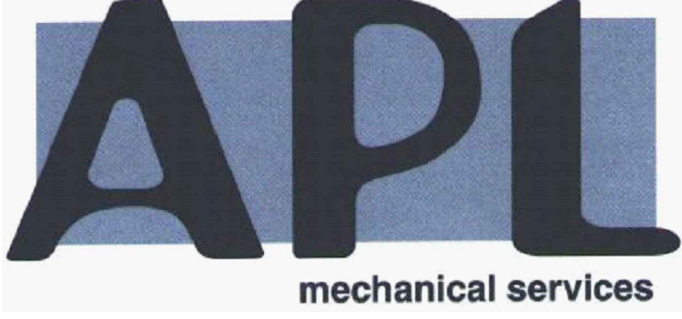


[illegible]

Rev/Date	Description
Client: J WILKINSON	
Job Title: SWAN STREET FREEHOUSE 40 SWAN STREET MANCHESTER M4 5JG	
Dwg Title: PROPOSED MECHANICAL LAYOUT PLANS	
Date: 16-09-20	Drawn By: DB
Scale: 1:100@A1	Checked By: AG
Dwg No: JW-SS-MAN-00	Rev: D
 APL mechanical services	
Atbey Plumbing Ltd 3 Whitehills Drive Whitehills Business Park Blackpool, FY4 5LW Tel: 01253 698 159 Email: admin@aplimechanical.co.uk	