


SITE LOCATION



 
Reproduced by permission of Ordnance Survey on behalf of the Controller of Her Majesty's Stationary Office
All rights reserved. © Crown Copyright licence no. 100062043

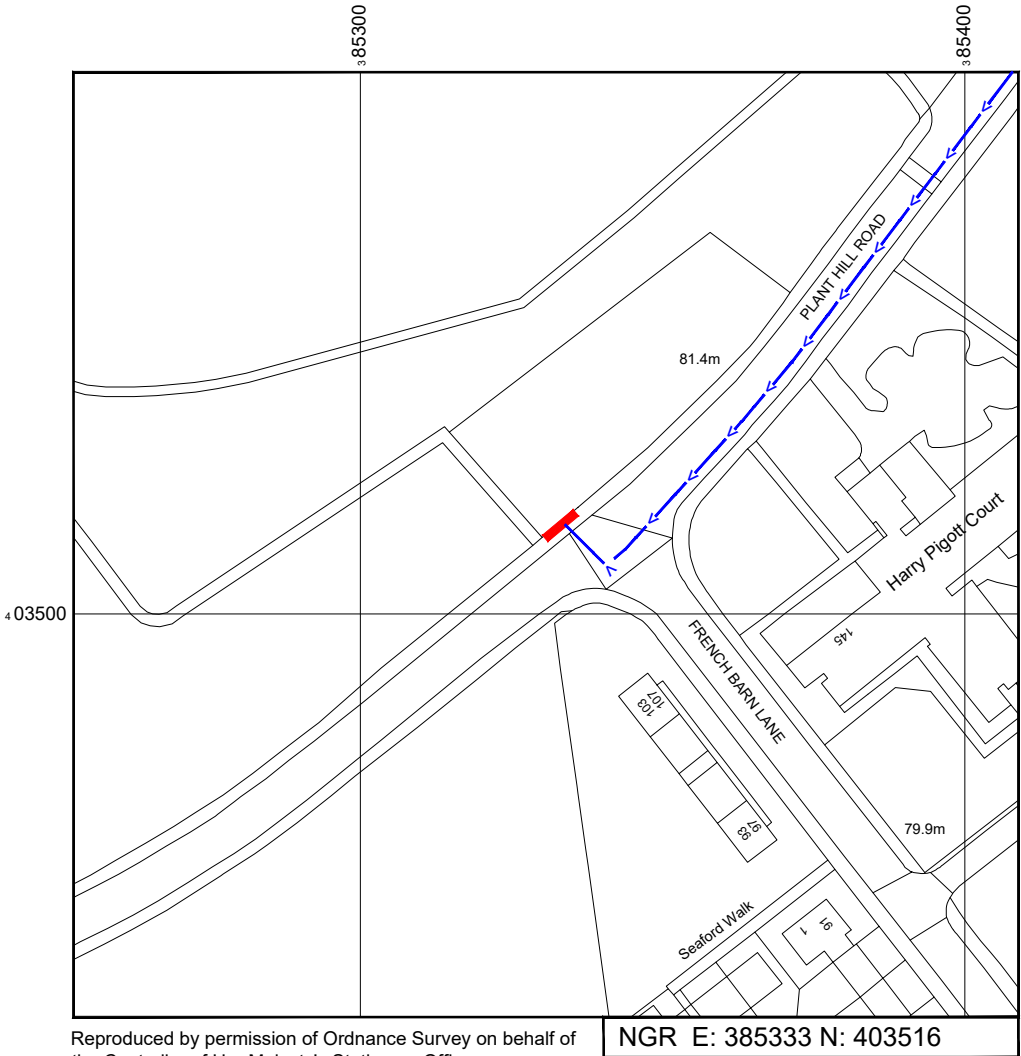

Reproduced by permission of Ordnance Survey on behalf of the Controller of Her Majesty's Stationary Office
All rights reserved. © Crown Copyright licence no. 100062043


NGR E: 385333 N: 403516

SITE AREA PLAN



SITE PHOTOGRAPH

 SITE LOCATION PLAN



GOOGLE MAPS QR CODE

GOOGLE MAPS - <https://goo.gl/maps/Bv7apqNJQRaW7NaeA>

GOOGLE STREETVIEW - <https://goo.gl/maps/1RgGMXB7N98NvBLg7>

NOTES:

1. ALL DIMENSIONS IN MM UNLESS OTHERWISE NOTED.
- DIRECTIONS TO SITE:
Head west on M60. At junction 19, take the A576 exit to Middleton. At Rhodes Interchange, take the 1st exit onto Middleton Rd/A576. Turn left onto Victoria Ave/A6104. At the roundabout, take the 2nd exit onto Plant Hill Rd. Follow Plant Hill Road and site location is on the right hand side.



Master:	MBNL / EE:	Project:	Purpose of Issue:	Issue:
M003	MBNL	3UK DNSW	Planning	C
Date:	05/04/2022	Revision / Upgrade Description:		
Drawn:	CDN	Pole location amended		
Checked:	DH			
Approved:	SD			
Master:	MBNL / EE:	Project:	Purpose of Issue:	Issue:
M002	MBNL	3UK DNSW	Planning	B
Date:	20/09/2021	Revision / Upgrade Description:		
Drawn:	CDN	Pole location amended		
Checked:	DH			
Approved:	SD			
Master:	MBNL / EE:	Project:	Purpose of Issue:	Issue:
M001	MBNL	3UK DNSW	Planning	A
Date:	15/07/2020	Revision / Upgrade Description:		
Drawn:	CDN	First Issue - Site nomination dated: TBC		
Checked:	DH			
Approved:	SD			

CK Hutchison Networks (UK) Limited

Great Brighams Mead,
Vastern Road, Reading,
Berkshire, England,
RG1 8DJ

Design Consultant & Principal Contractor:



WHP Telecoms
Unit 1 Maple Park,
Low Fields Avenue, Leeds
LS12 6HH

Tel: 01133023550
e-mail: info@whptelecoms.com

Site Name:
PLANT HILL ROAD STREETWORKS

Site ID:
MAN12600

Address:
PLANT HILL ROAD, BLACKLEY,
MANCHESTER, GREATER MANCHESTER,
NORTH WEST ENGLAND, ENGLAND,
M9 8LU


Title:
002 SITE LOCATION PLAN

Project:
3UK DNSW

Purpose of Issue:
PLANNING

EE Cell ID: 65778	MBNL Cell ID: MAN477	Cell ID: M0169
----------------------	-------------------------	-------------------

Master Drawing No: MAN12600_M003	Issue: C
-------------------------------------	-------------

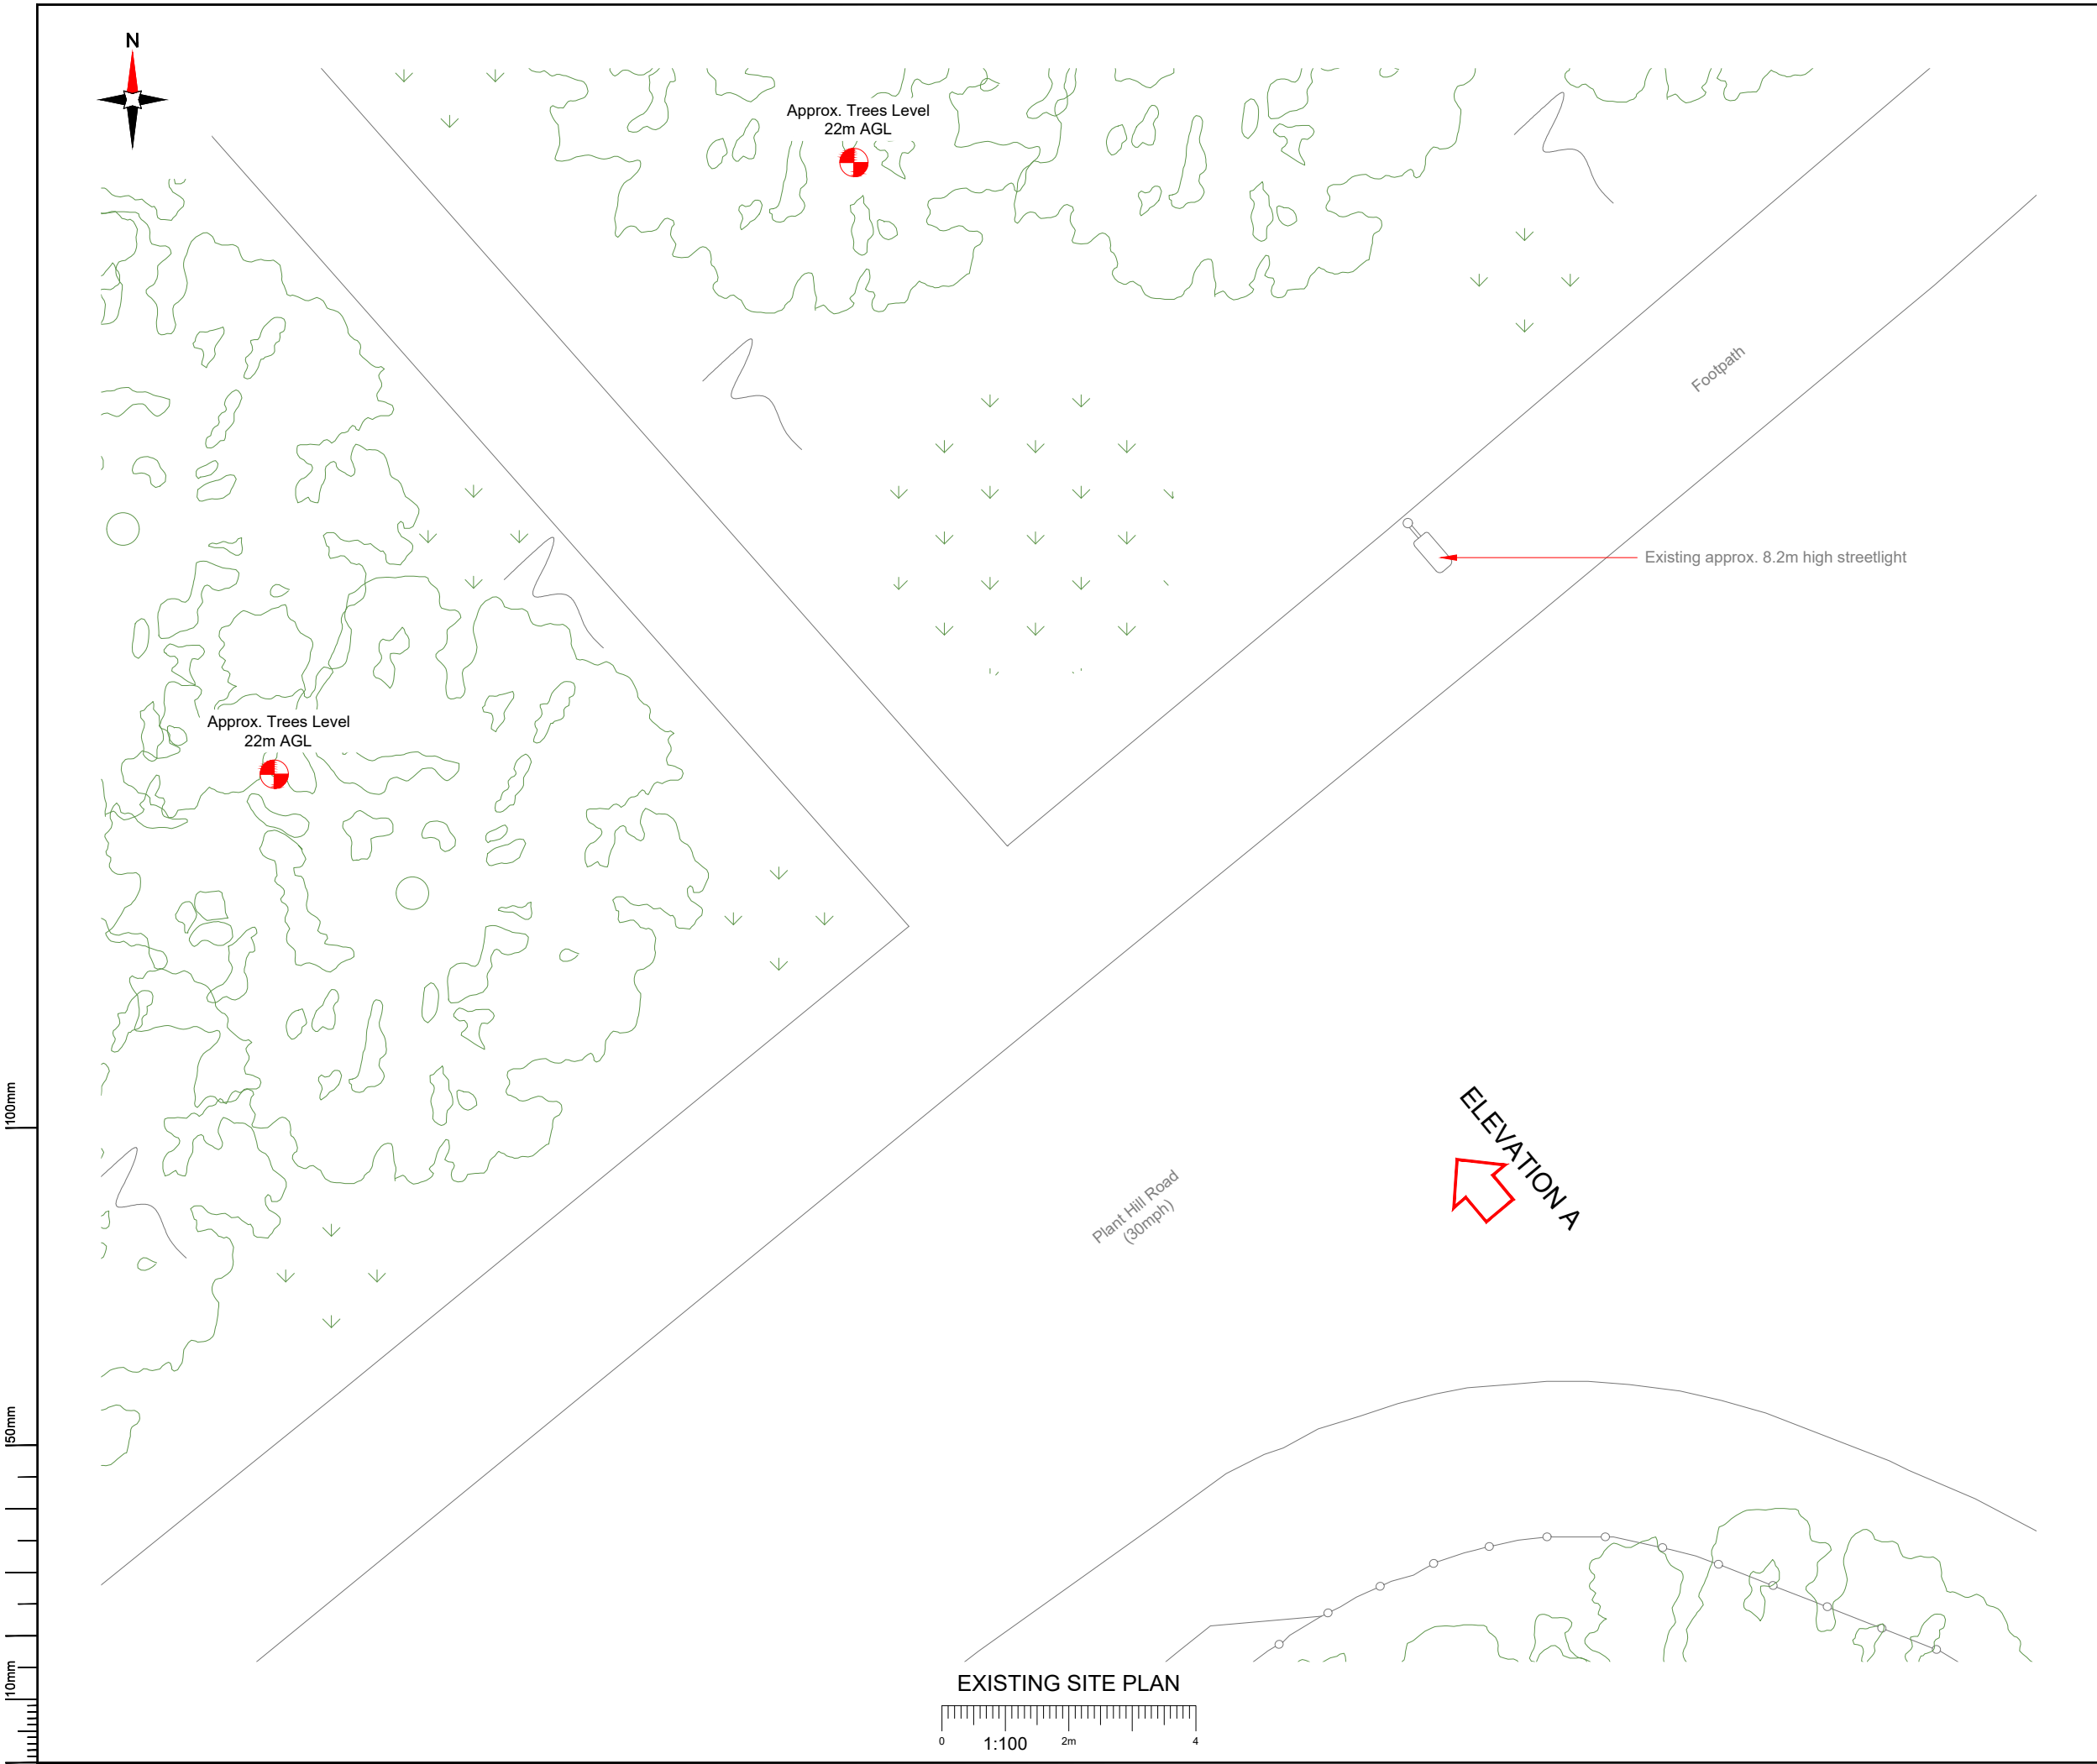

- NOTES:
- ALL DIMENSIONS IN MM UNLESS OTHERWISE NOTED.

Master:	MBNL / EE:	Project:	Purpose of Issue:	Issue:
M003	MBNL	3UK DNSW	Planning	C
Date:	05/04/2022	Revision / Upgrade Description:		
Drawn:	CDN	Pole location amended		
Checked:	DH			
Approved:	SD			
Master:	MBNL / EE:	Project:	Purpose of Issue:	Issue:
M002	MBNL	3UK DNSW	Planning	B
Date:	20/09/2021	Revision / Upgrade Description:		
Drawn:	CDN	Pole location amended		
Checked:	DH			
Approved:	SD			
Master:	MBNL / EE:	Project:	Purpose of Issue:	Issue:
M001	MBNL	3UK DNSW	Planning	A
Date:	15/07/2020	Revision / Upgrade Description:		
Drawn:	CDN	First Issue - Site nomination dated: TBC		
Checked:	DH			
Approved:	SD			

CK Hutchison
Networks (UK)
Limited

Great Brighams Mead,
Vastern Road, Reading,
Berkshire, England,
RG1 8DJ

Design Consultant & Principal Contractor:



WHP Telecoms
Unit 1 Maple Park,
Low Fields Avenue, Leeds
LS12 6HH

Tel: 01133023550
e-mail: info@whptelecoms.com

Site Name:
PLANT HILL ROAD STREETWORKS

Site ID:
MAN12600

Address:
PLANT HILL ROAD, BLACKLEY,
MANCHESTER, GREATER MANCHESTER,
NORTH WEST ENGLAND, ENGLAND,
M9 8LU

Title:
100 EXISTING SITE PLAN

Project:
3UK DNSW

Purpose of Issue:
PLANNING


EE Cell ID:	MBNL Cell ID:	Cell ID:
65778	MAN477	M0169

Master Drawing No:	Issue:
MAN12600_M003	C

100mm

50mm

10mm

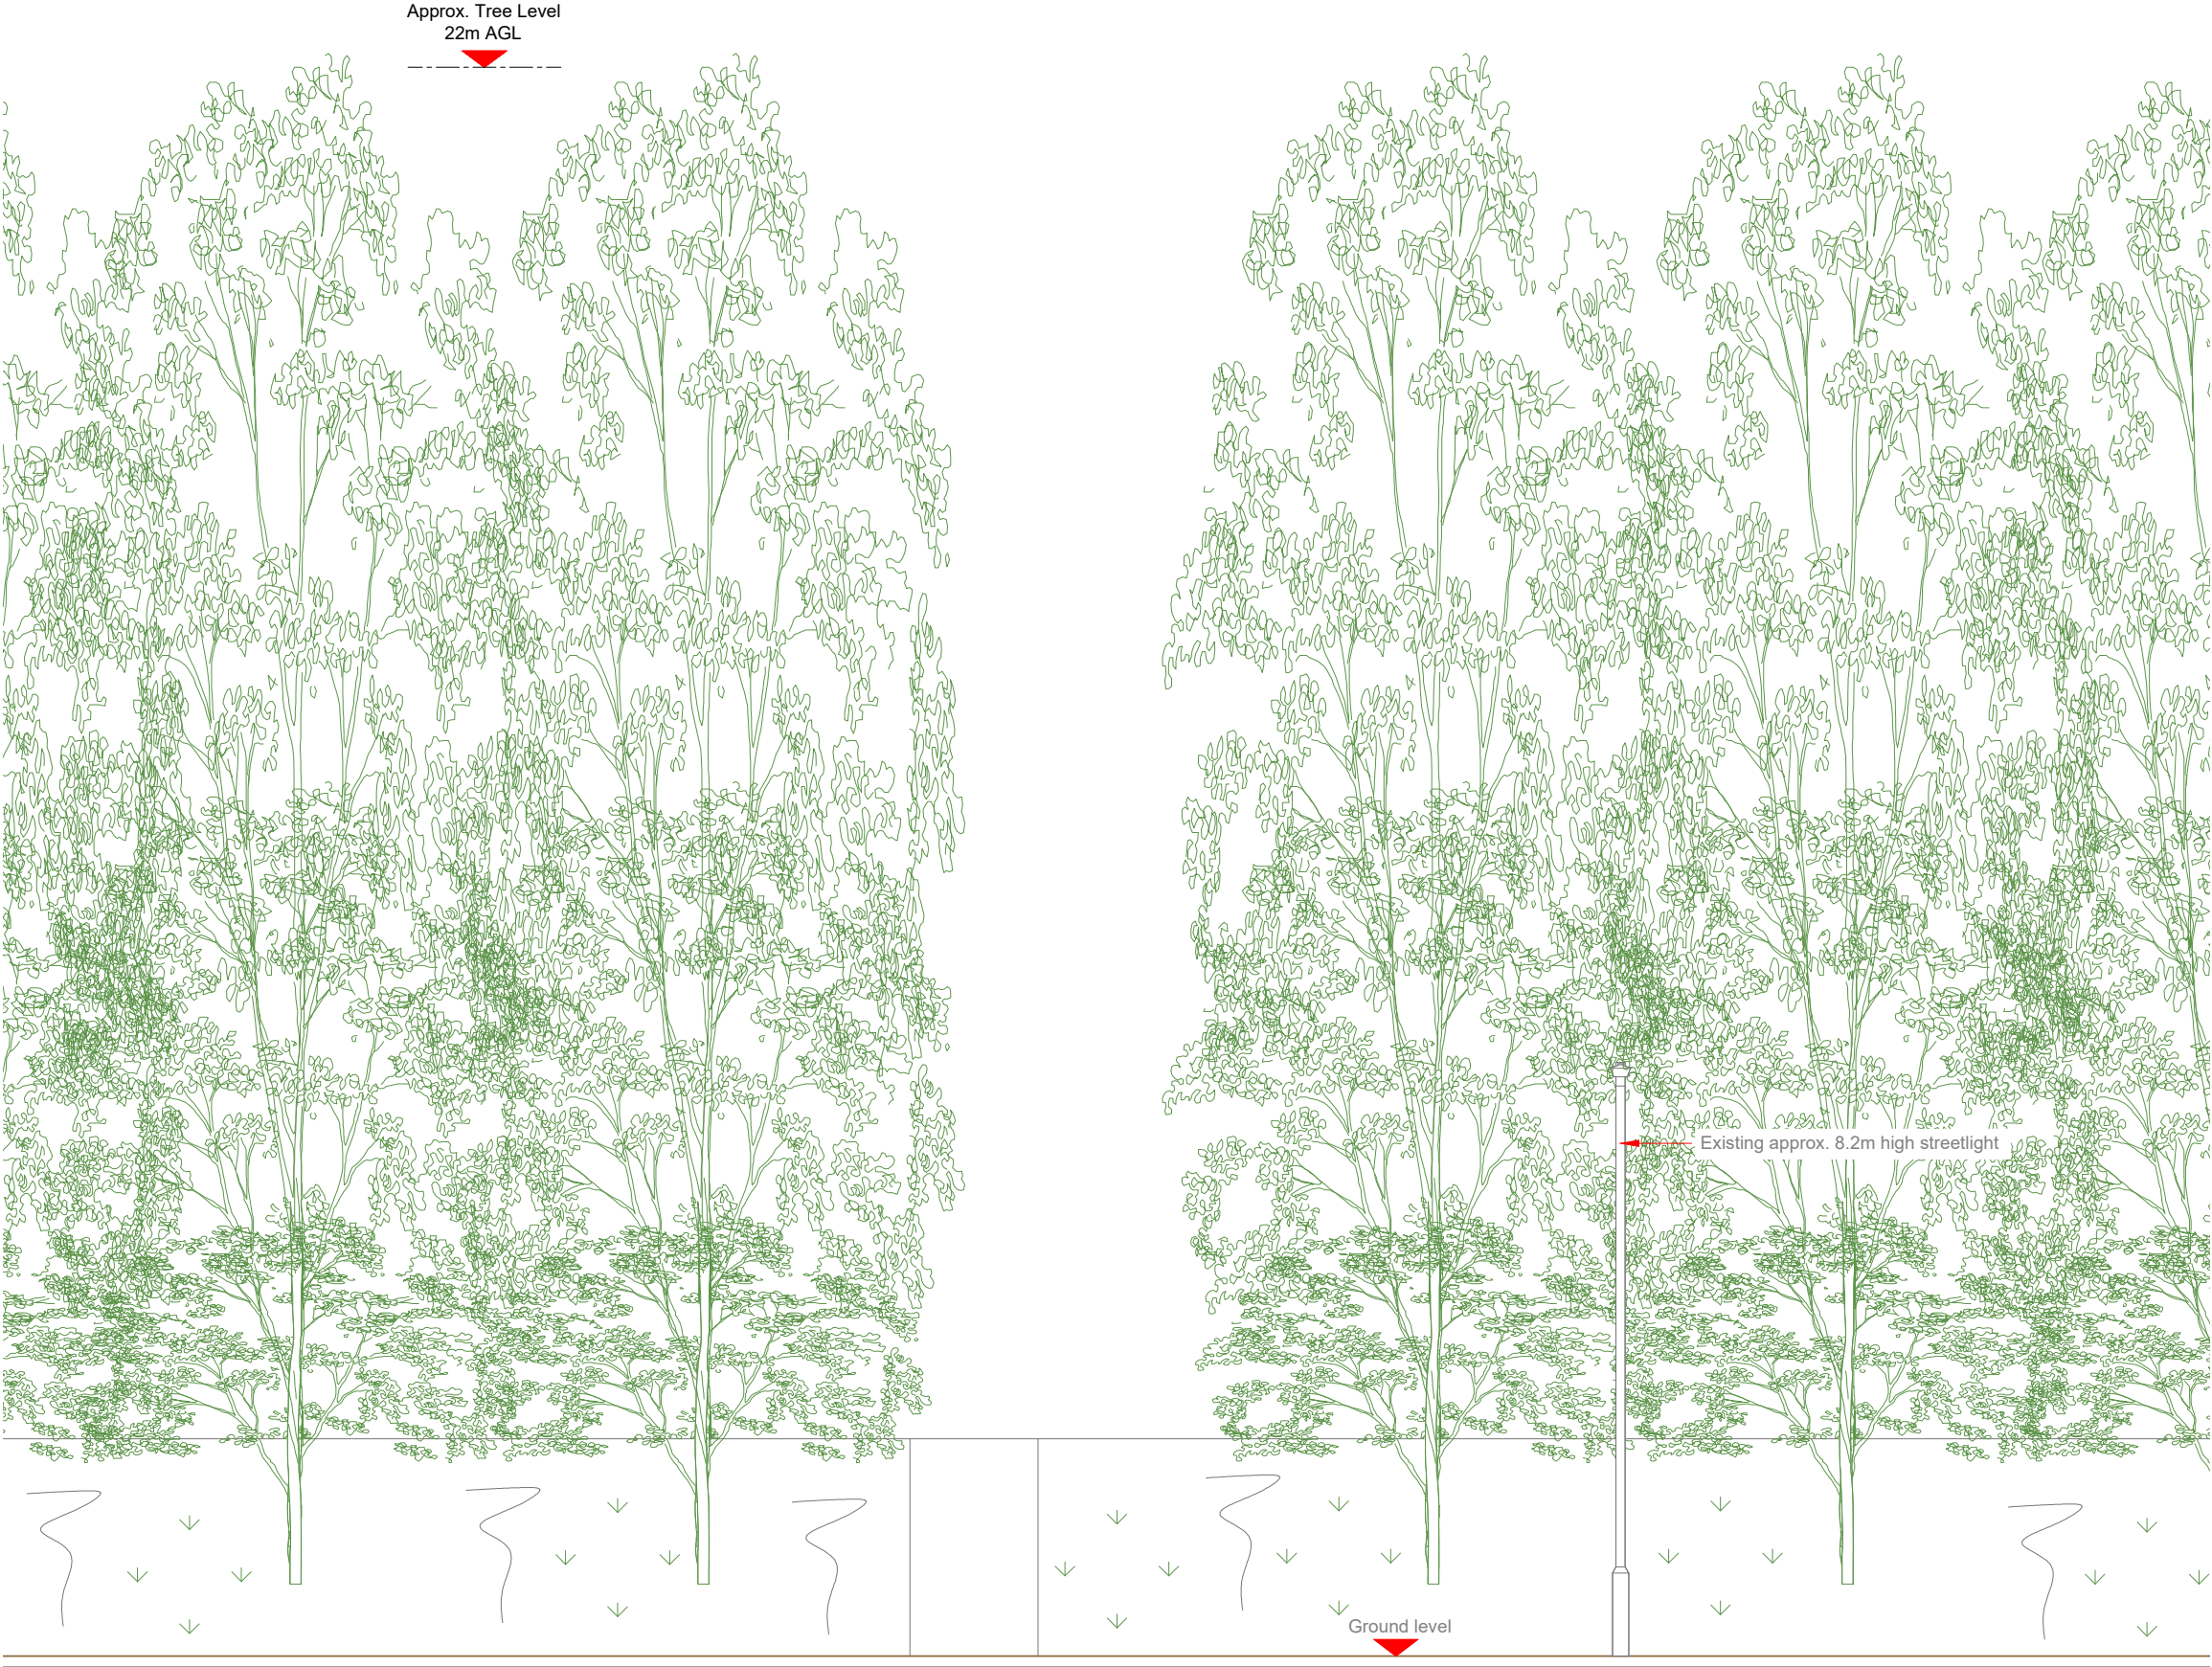


Approx. Tree Level
22m AGL

Existing approx. 8.2m high streetlight

Ground level

 EXISTING ELEVATION A



NOTES:

1. ALL DIMENSIONS IN MM UNLESS OTHERWISE NOTED.

Master:	MBNL / EE:	Project:	Purpose of Issue:	Issue:
M003	MBNL	3UK DNSW	Planning	C
Date:	05/04/2022	Revision / Upgrade Description:		
Drawn:	CDN	Pole location amended		
Checked:	DH			
Approved:	SD			
Master:	MBNL / EE:	Project:	Purpose of Issue:	Issue:
M002	MBNL	3UK DNSW	Planning	B
Date:	20/09/2021	Revision / Upgrade Description:		
Drawn:	CDN	Pole location amended		
Checked:	DH			
Approved:	SD			
Master:	MBNL / EE:	Project:	Purpose of Issue:	Issue:
M001	MBNL	3UK DNSW	Planning	A
Date:	15/07/2020	Revision / Upgrade Description:		
Drawn:	CDN	First Issue - Site nomination dated: TBC		
Checked:	DH			
Approved:	SD			

CK Hutchison
Networks (UK)
Limited

Great Brighams Mead,
Vastern Road, Reading,
Berkshire, England,
RG1 8DJ

Design Consultant & Principal Contractor:



WHP Telecoms

Unit 1 Maple Park,
Low Fields Avenue, Leeds
LS12 6HH

Tel: 01133023550
e-mail: info@whptelecoms.com

Site Name:
PLANT HILL ROAD STREETWORKS

Site ID:
MAN12600

Address:
PLANT HILL ROAD, BLACKLEY,
MANCHESTER, GREATER MANCHESTER,
NORTH WEST ENGLAND, ENGLAND,
M9 8LU


Title:
150 EXISTING ELEVATION A

Project:
3UK DNSW

Purpose of Issue:
PLANNING

EE Cell ID: 65778	MBNL Cell ID: MAN477	Cell ID: M0169
----------------------	-------------------------	-------------------

Master Drawing No: MAN12600_M003	Issue: C
-------------------------------------	-------------

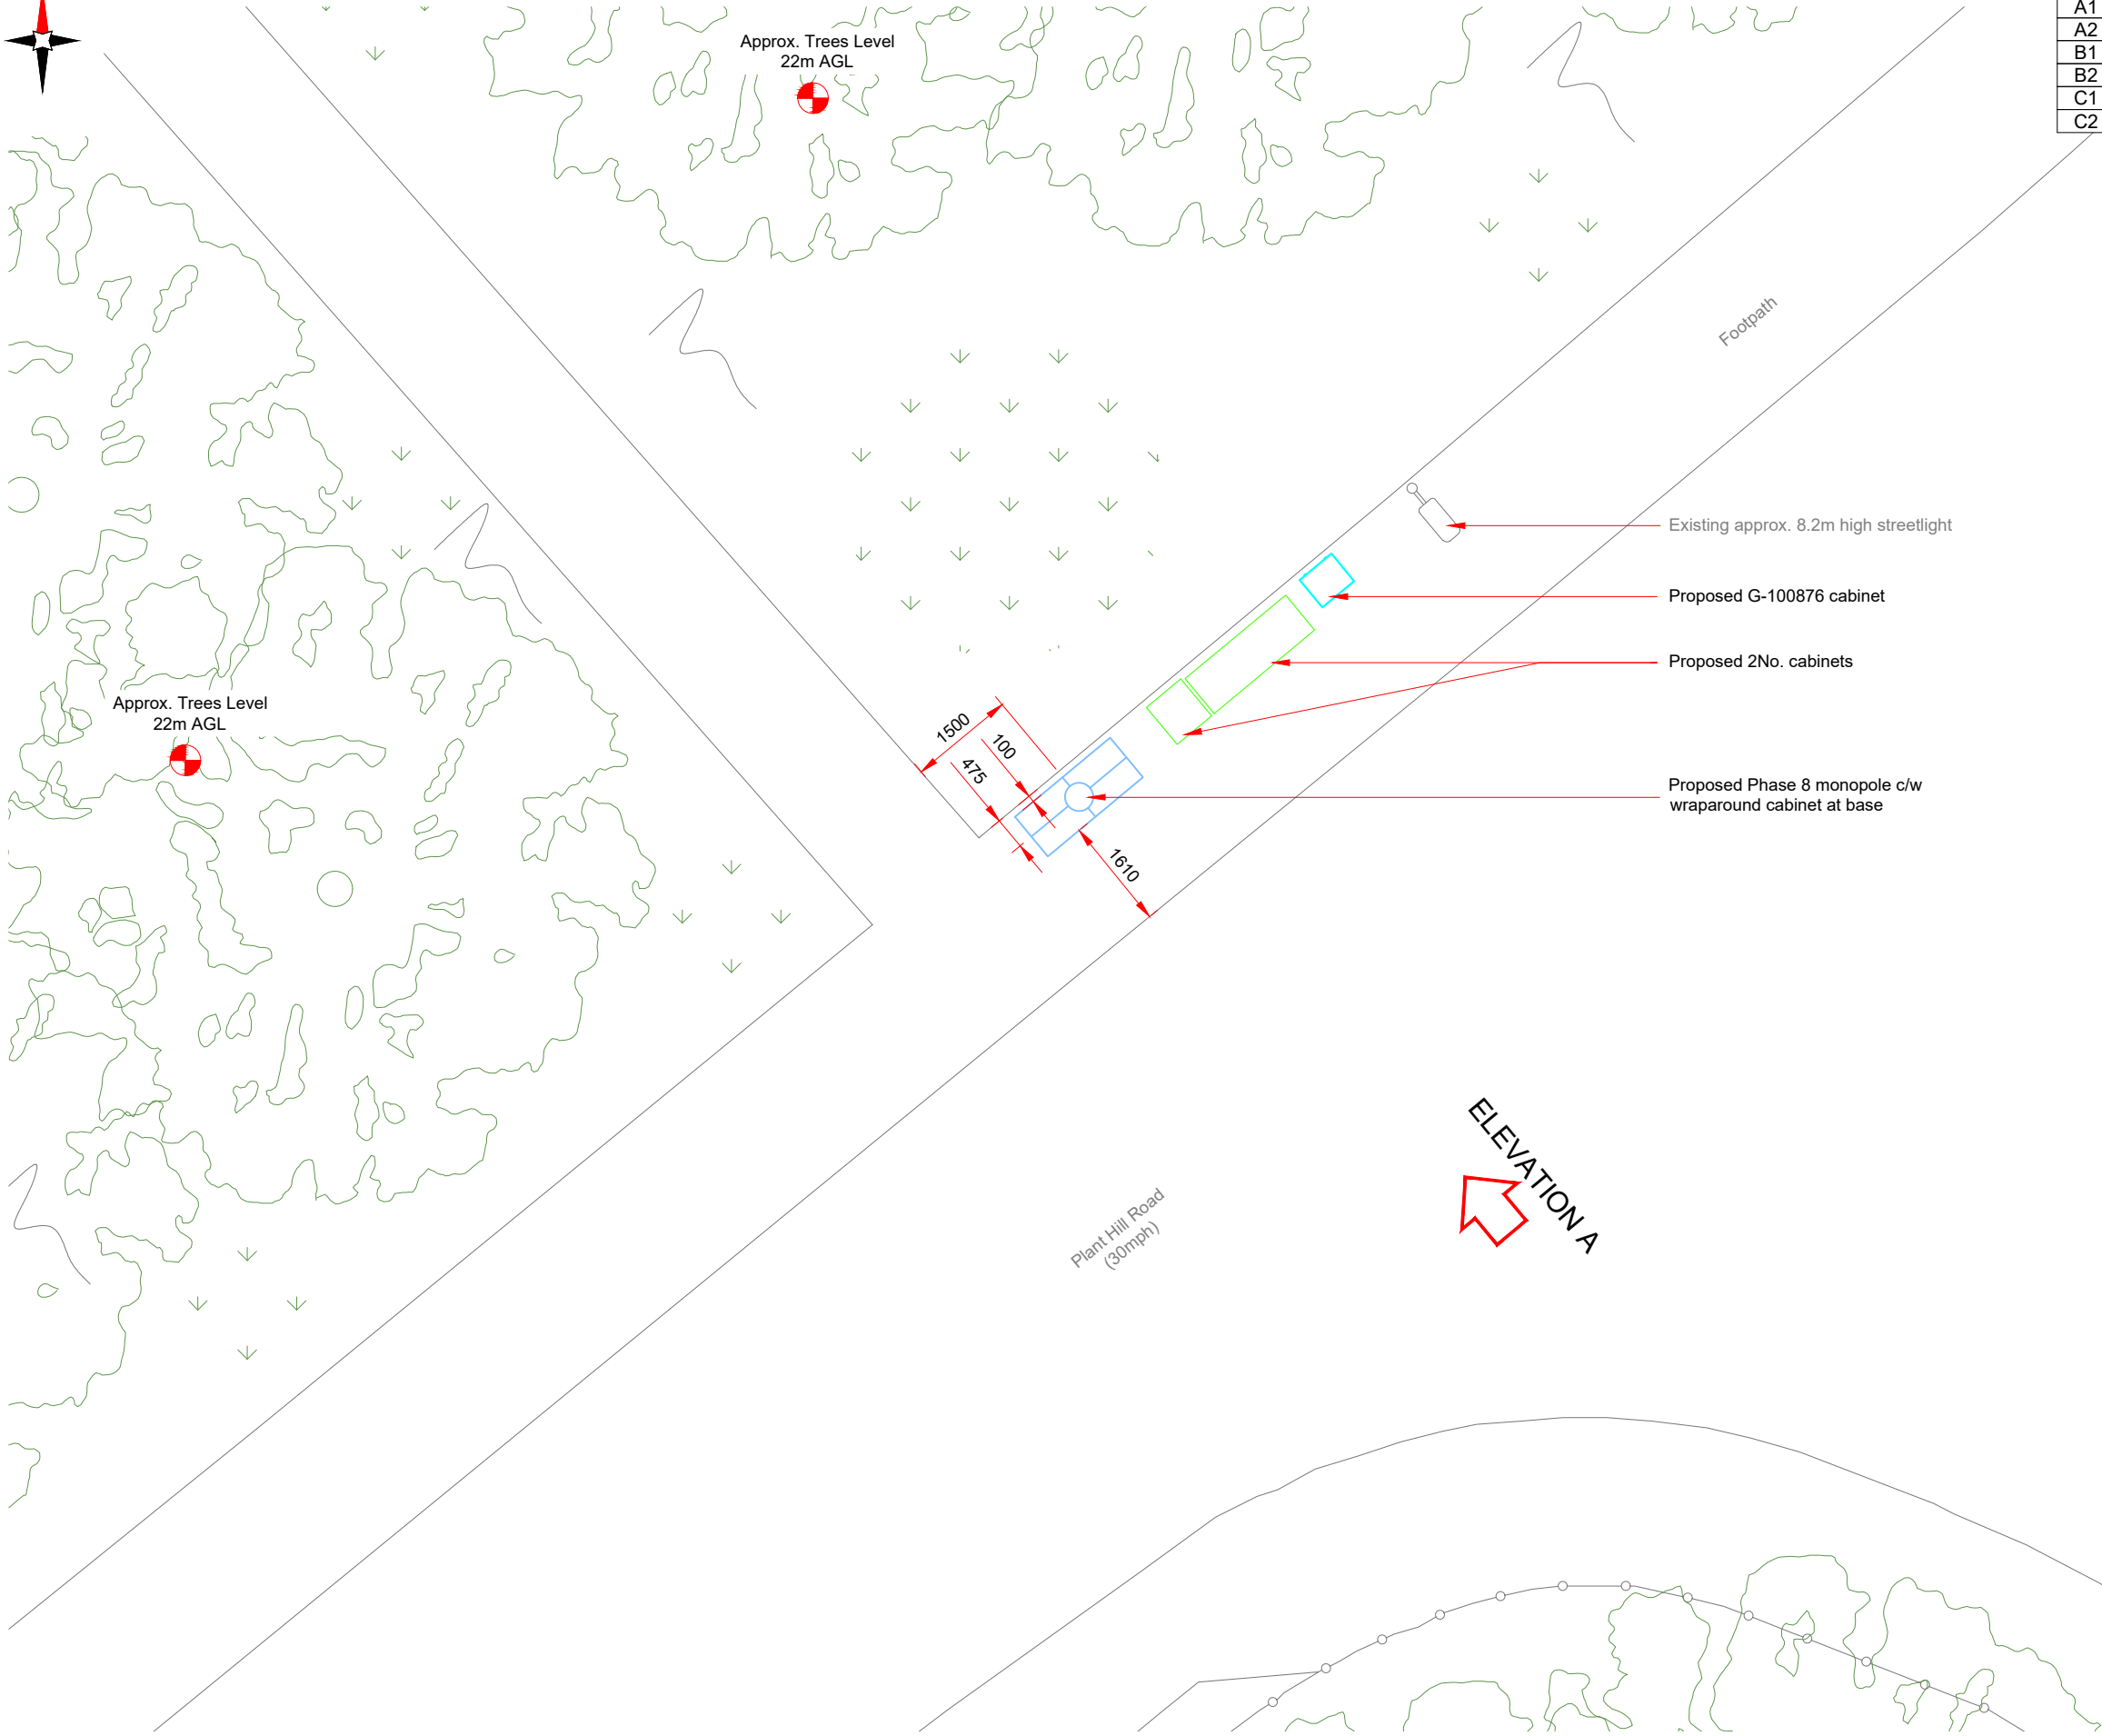

Antenna Aperture ID	Proposed 4G/5G Bearing
A1	30°
A2	30°
B1	150°
B2	150°
C1	270°
C2	270°

NOTES:

1. ALL DIMENSIONS IN MM UNLESS OTHERWISE NOTED.

Master:	MBNL / EE:	Project:	Purpose of Issue:	Issue:
M003	MBNL	3UK DNSW	Planning	C
Date:	05/04/2022	Revision / Upgrade Description:		
Drawn:	CDN	Pole location amended		
Checked:	DH			
Approved:	SD			
Master:	MBNL / EE:	Project:	Purpose of Issue:	Issue:
M002	MBNL	3UK DNSW	Planning	B
Date:	20/09/2021	Revision / Upgrade Description:		
Drawn:	CDN	Pole location amended		
Checked:	DH			
Approved:	SD			
Master:	MBNL / EE:	Project:	Purpose of Issue:	Issue:
M001	MBNL	3UK DNSW	Planning	A
Date:	15/07/2020	Revision / Upgrade Description:		
Drawn:	CDN	First Issue - Site nomination dated: TBC		
Checked:	DH			
Approved:	SD			

CK Hutchison Networks (UK) Limited
Great Brighams Mead,
Vastern Road, Reading,
Berkshire, England,
RG1 8DJ

Design Consultant & Principal Contractor:



WHP Telecoms
Unit 1 Maple Park,
Low Fields Avenue, Leeds
LS12 6HH

Tel: 01133023550
e-mail: info@whptelecoms.com

Site Name:
PLANT HILL ROAD STREETWORKS

Site ID:
MAN12600

Address:
**PLANT HILL ROAD, BLACKLEY,
MANCHESTER, GREATER MANCHESTER,
NORTH WEST ENGLAND, ENGLAND,
M9 8LU**

Title:
210 PROPOSED SITE PLAN

Project:
3UK DNSW


Purpose of Issue:
PLANNING

EE Cell ID: 65778	MBNL Cell ID: MAN477	Cell ID: M0169
Master Drawing No: MAN12600_M003		Issue: C

100mm

50mm

10mm

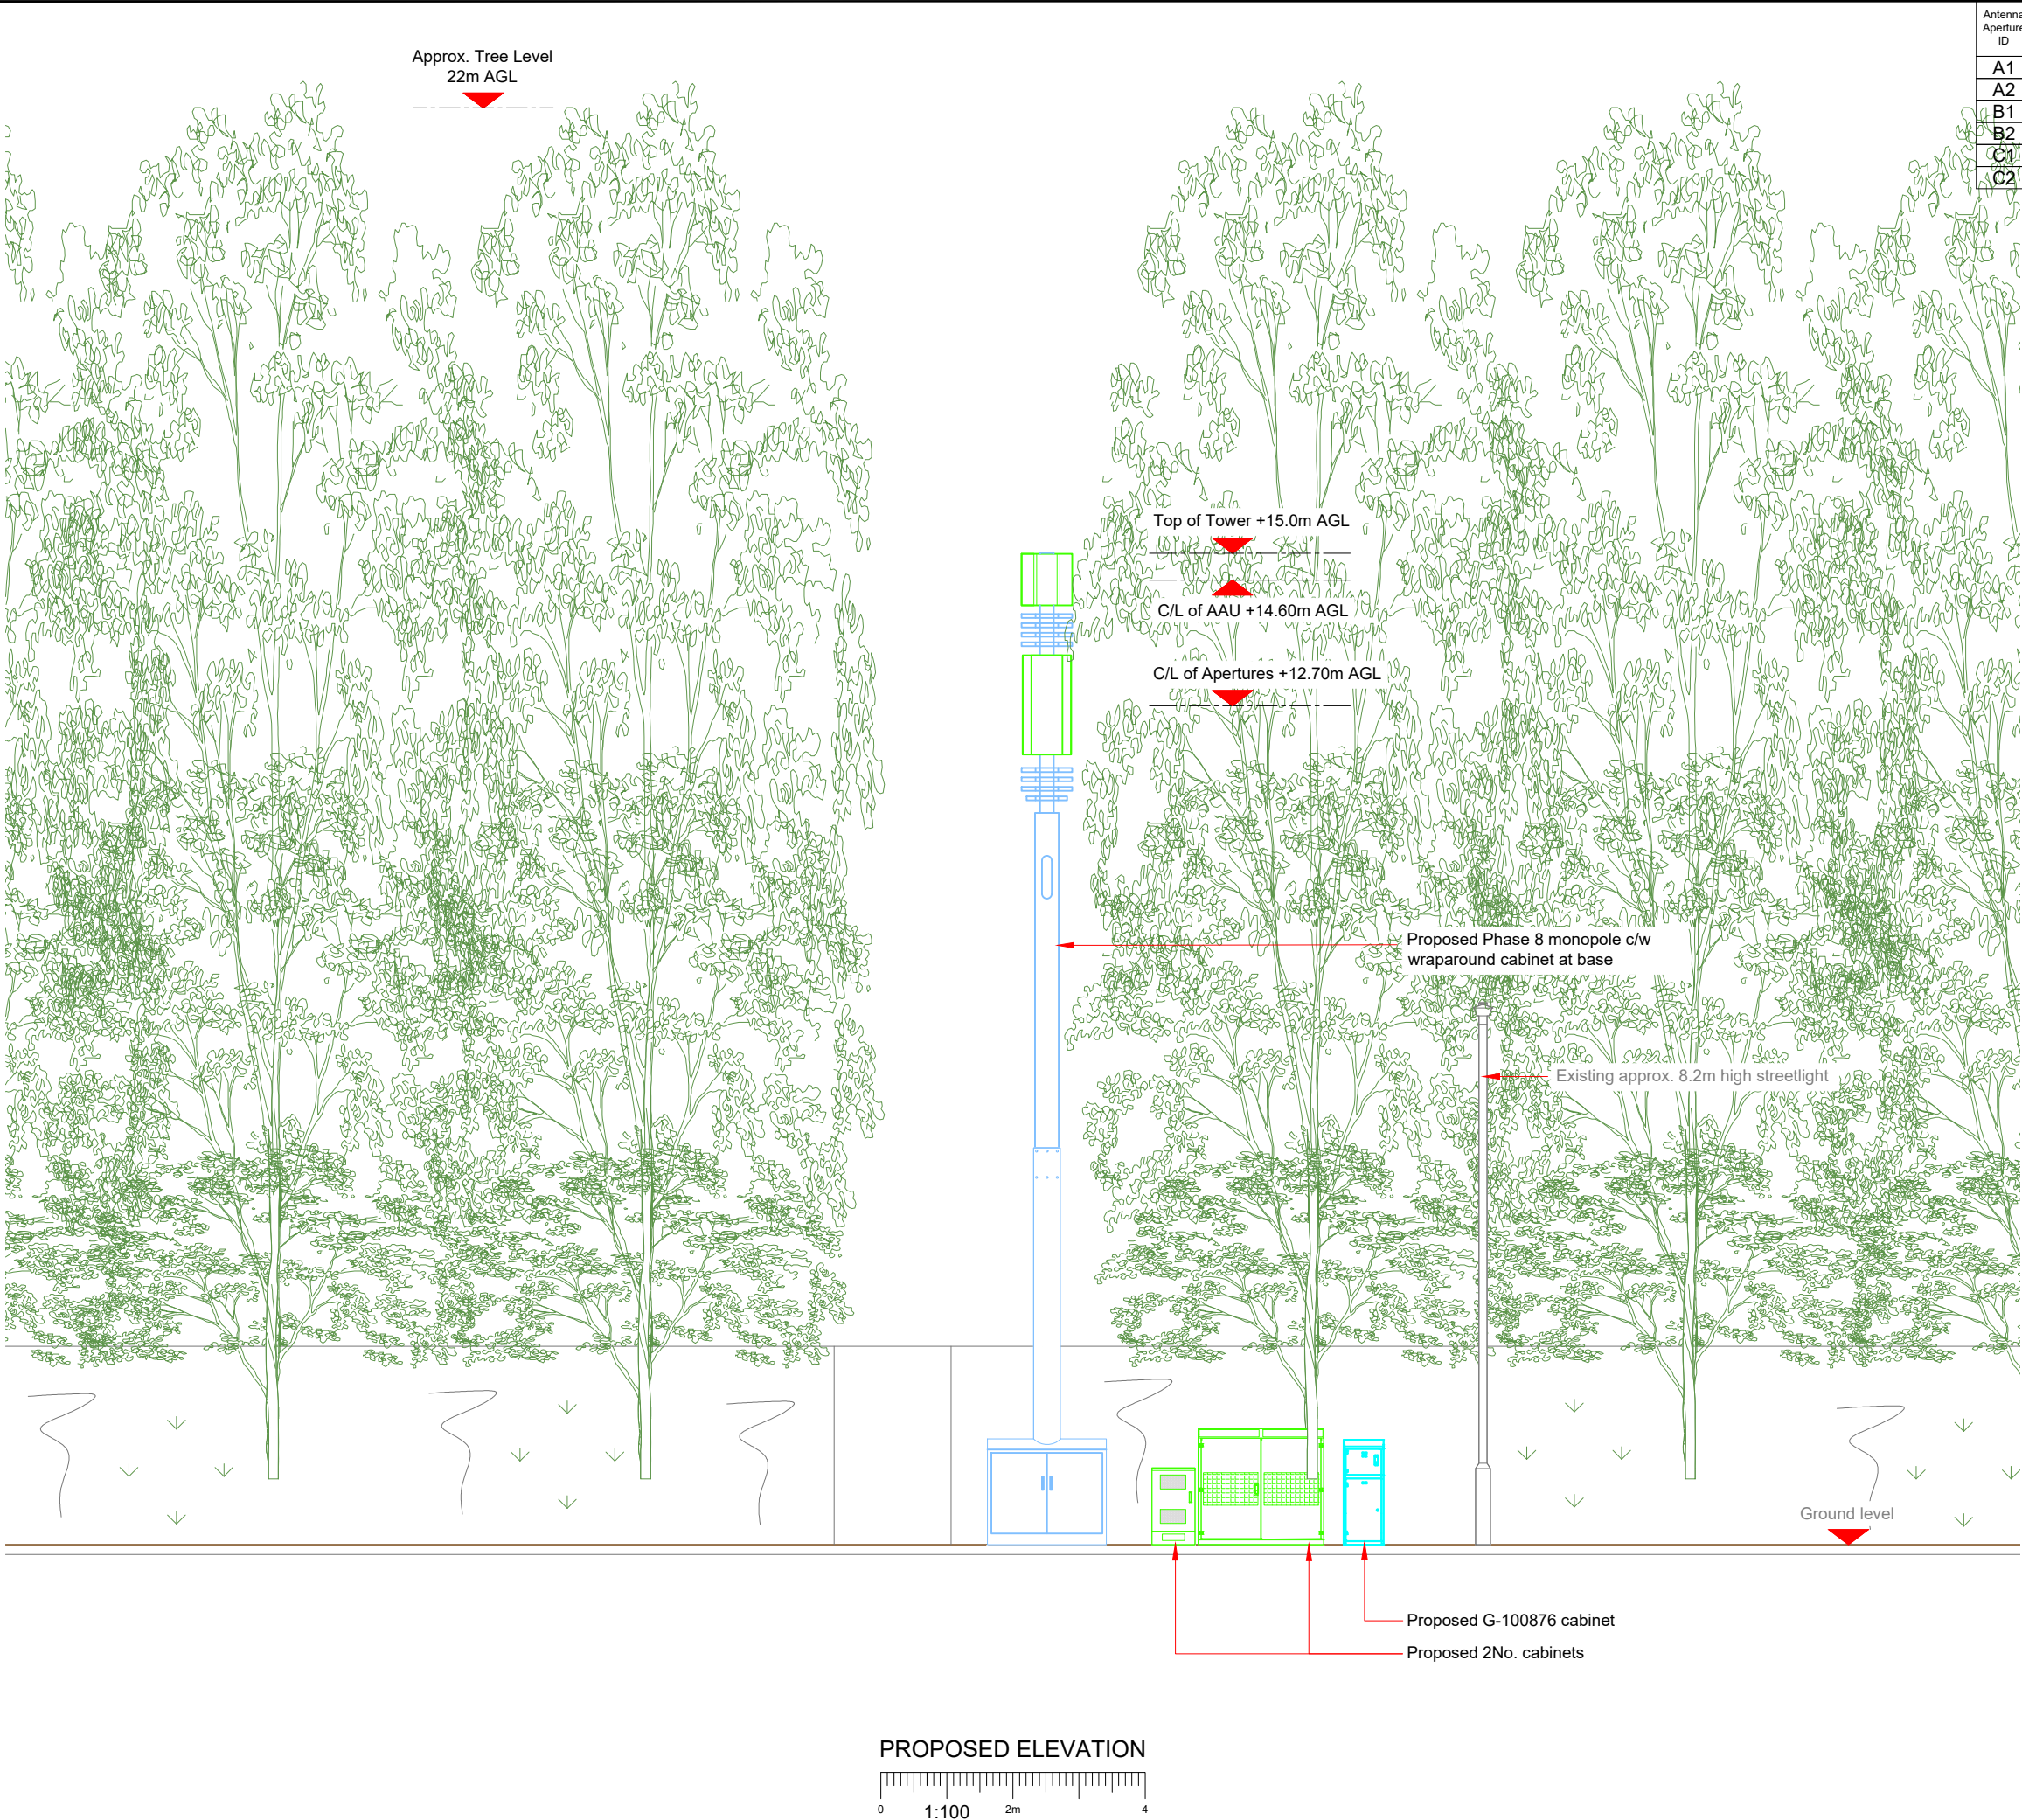

Antenna Aperture ID	Proposed 4G/5G Bearing
A1	30°
A2	30°
B1	150°
B2	150°
C1	270°
C2	270°

NOTES:

1. ALL DIMENSIONS IN MM UNLESS OTHERWISE NOTED.

Master:	MBNL / EE:	Project:	Purpose of Issue:	Issue:
M003	MBNL	3UK DNSW	Planning	C
Date:	05/04/2022	Revision / Upgrade Description:		
Drawn:	CDN	Pole location amended		
Checked:	DH			
Approved:	SD			
Master:	MBNL / EE:	Project:	Purpose of Issue:	Issue:
M002	MBNL	3UK DNSW	Planning	B
Date:	20/09/2021	Revision / Upgrade Description:		
Drawn:	CDN	Pole location amended		
Checked:	DH			
Approved:	SD			
Master:	MBNL / EE:	Project:	Purpose of Issue:	Issue:
M001	MBNL	3UK DNSW	Planning	A
Date:	15/07/2020	Revision / Upgrade Description:		
Drawn:	CDN	First Issue - Site nomination dated: TBC		
Checked:	DH			
Approved:	SD			

**CK Hutchison
Networks (UK)
Limited**

Great Brighams Mead,
Vastern Road, Reading,
Berkshire, England,
RG1 8DJ

Design Consultant & Principal Contractor:

 **WHP Telecoms**
Unit 1 Maple Park,
Low Fields Avenue, Leeds
LS12 6HH

Tel: 01133023550
e-mail: info@whptelecoms.com

Site Name:
PLANT HILL ROAD STREETWORKS

Site ID:
MAN12600

Address:
**PLANT HILL ROAD, BLACKLEY,
MANCHESTER, GREATER MANCHESTER,
NORTH WEST ENGLAND, ENGLAND,
M9 8LU**

Title:
260 PROPOSED ELEVATION

Project:
3UK DNSW

Purpose of Issue:
PLANNING

EE Cell ID: 65778	MBNL Cell ID: MAN477	Cell ID: M0169
-----------------------------	--------------------------------	--------------------------

Master Drawing No:
MAN12600_M003

Issue:
C