
 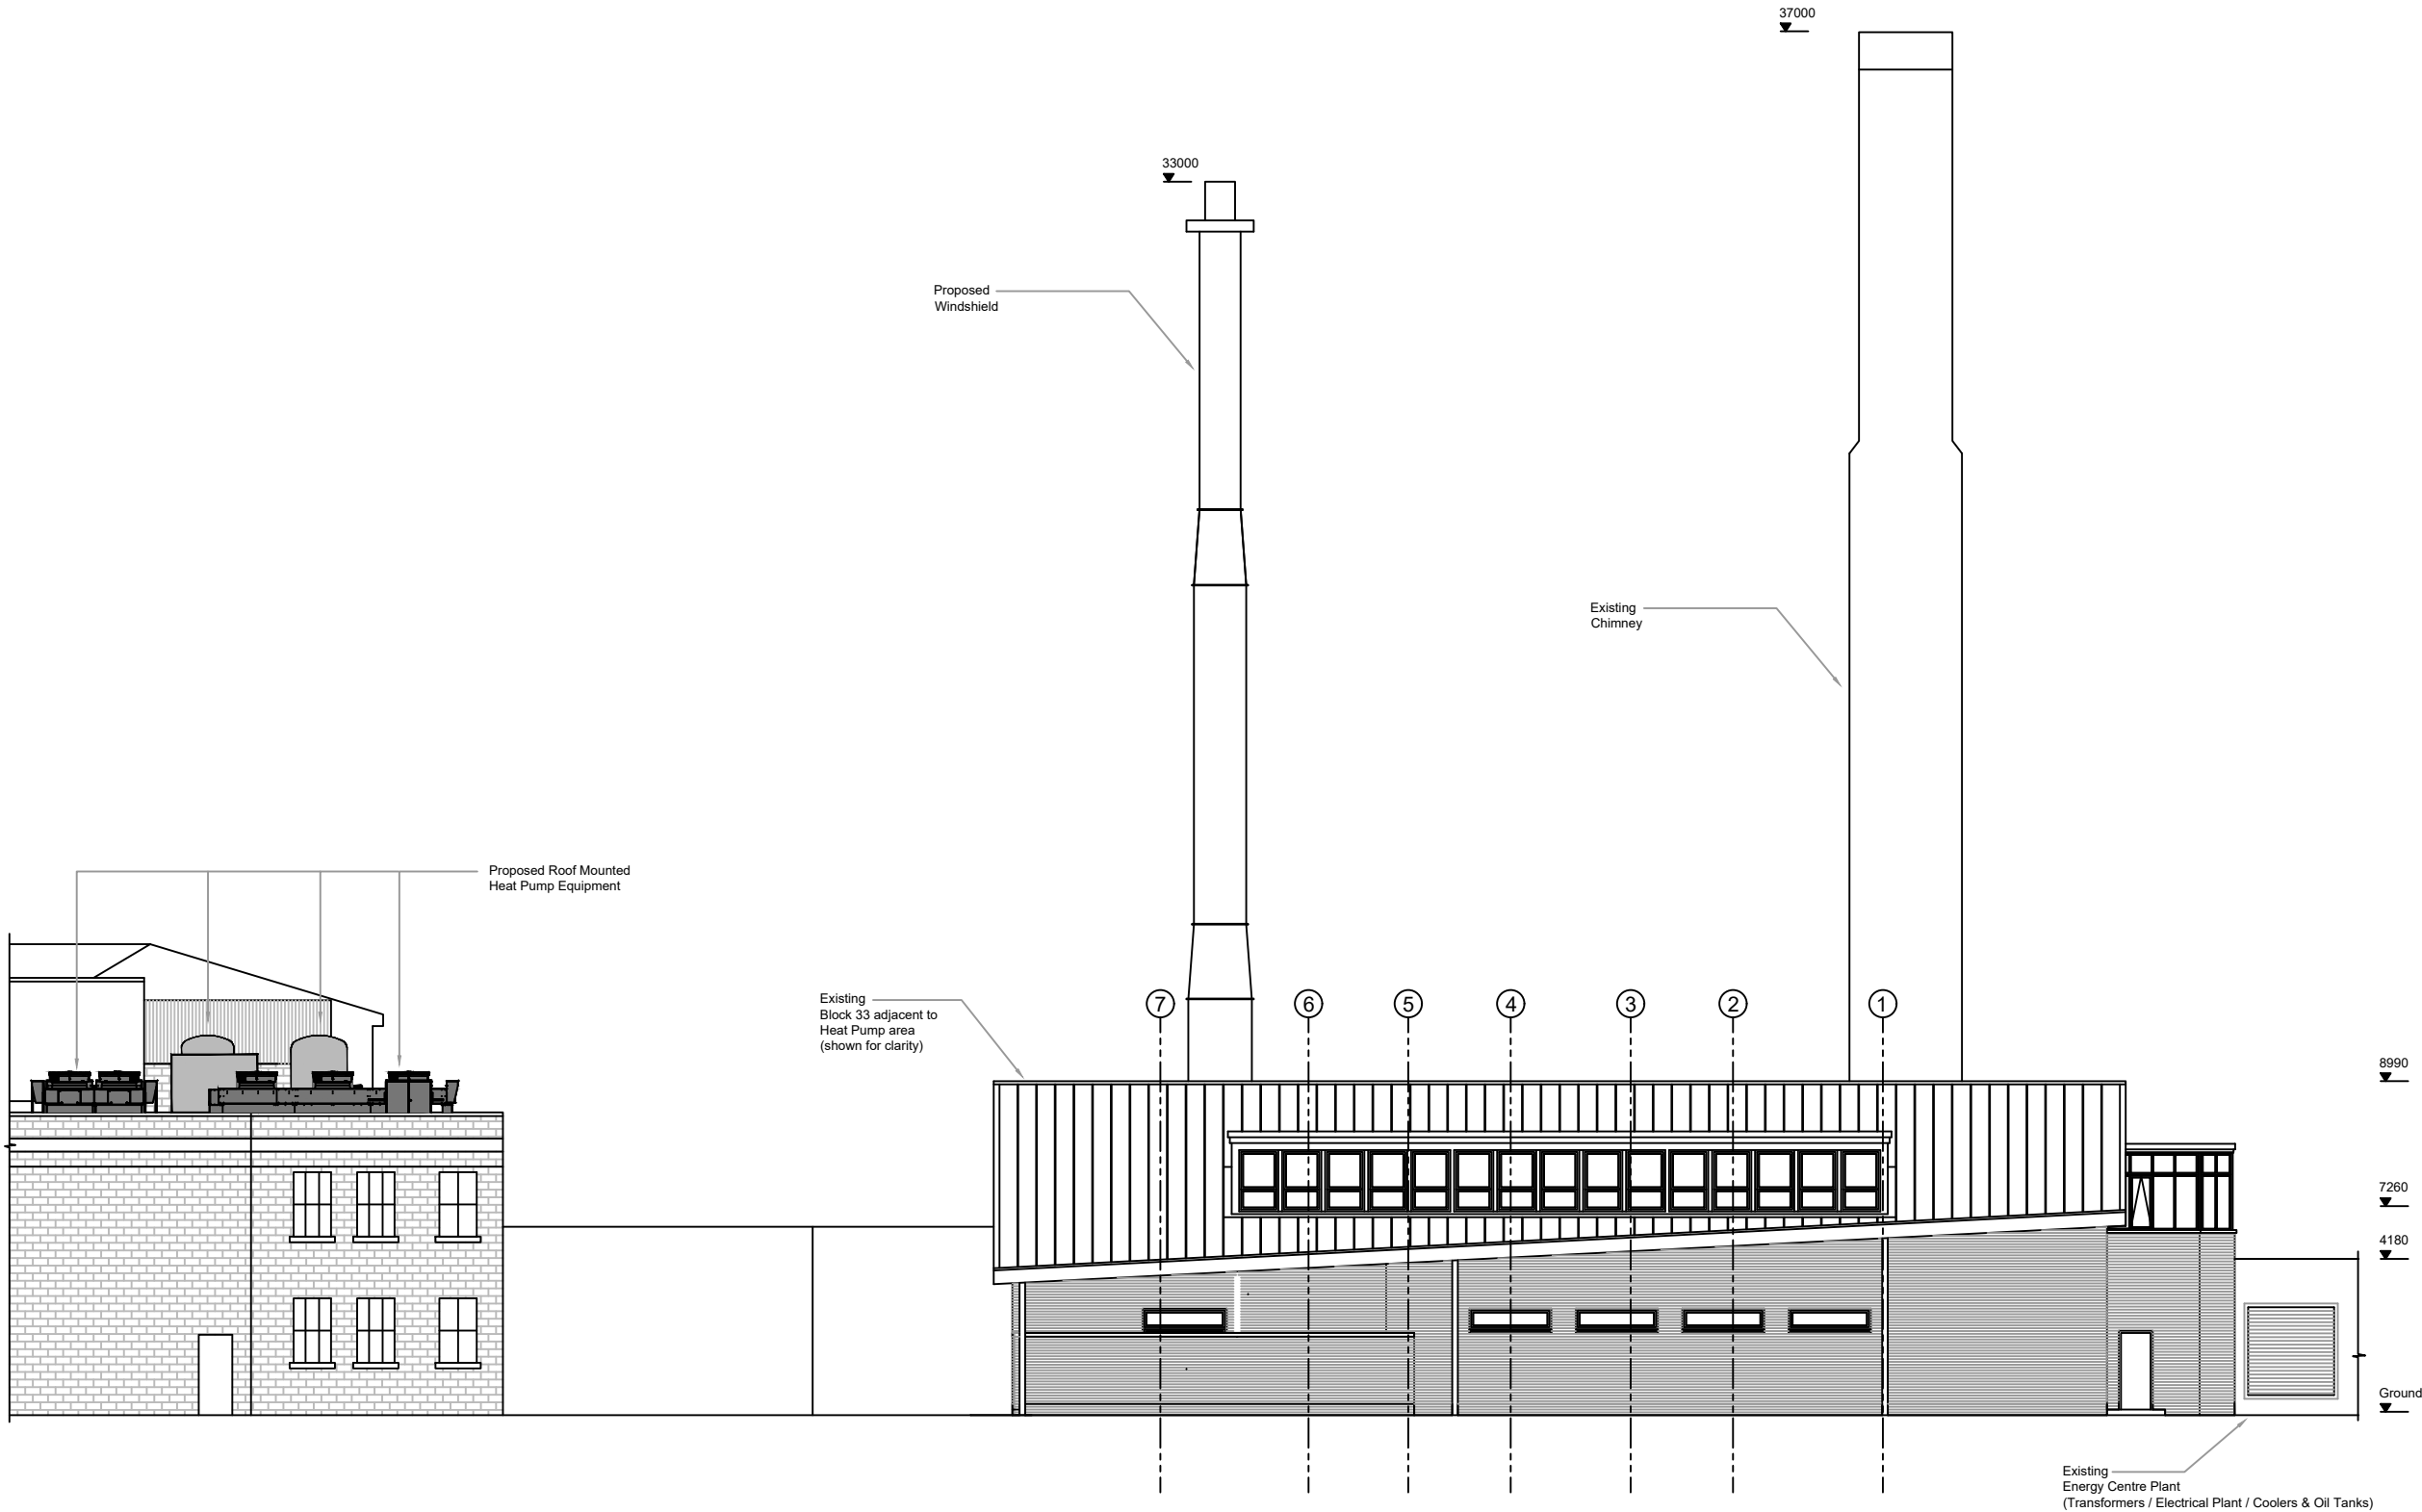





North Elevation
Scale (1:100)

REFERENCE DRAWINGS:

NOTES:

1. All dimensions in millimeters unless otherwise stated.
2. All levels in meters unless otherwise stated.
3. This drawing shall be read in conjunction with all project documentation including: Civil, Structural, Mechanical and Electrical drawings, Schedules and specifications unless otherwise stated.
4. No dimensions / measurements or levels are to be scaled from this drawing.

KEY:

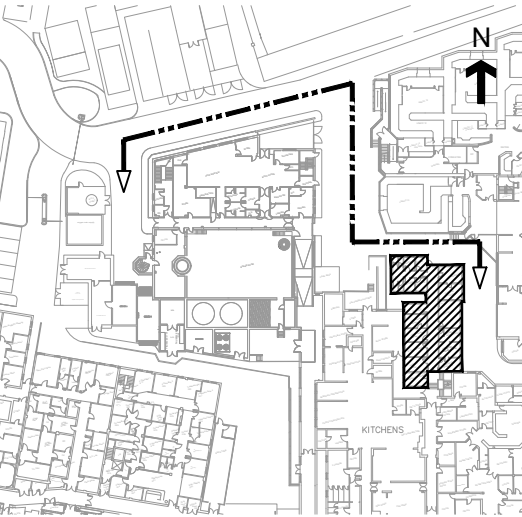

North Elevation
(Existing Block 33 shown for height clarity)

01	16.08.2021	Issued for Information	DPG	AY	TW	
Rev	Date	Description	Drawn	Design	Ch'k'd	App'd

VITAL
ENERGI

VITAL ENERGI Century House, Roman Road, Blackburn, Lancashire,
United Kingdom, BB1 2LD. Tel: +44 (0) 1254 296 000 Fax: +44 (0) 1254 296 040



Process Solutions
with a Quality Installation.
Serving the Energy, Food &
Pharmaceutical Industry
Dedicated to Excellence

[Process Installations & Maintenance Services Ltd](#)

Waterworks Lane, Glinton, Peterborough PE6 7LP

Tel: 01406 430030 - Fax: 01406 331379 - www.processinstallations.net

Project Title
**The Christie
NHS Trust Foundation**

Drawing Title
**Proposed Heat Pump &
Associated Plant
North Elevation**

Designed	AY		Checked		
Drawn	DPG		Approved		
Scale	As Noted	Status	Information	Date	Job No.
				16/08/2021	PI 348
Drawing No.	VI 21 CHR LAY 015				Rev
					01