


FIRST FLOOR PLAN: CABLE RUN

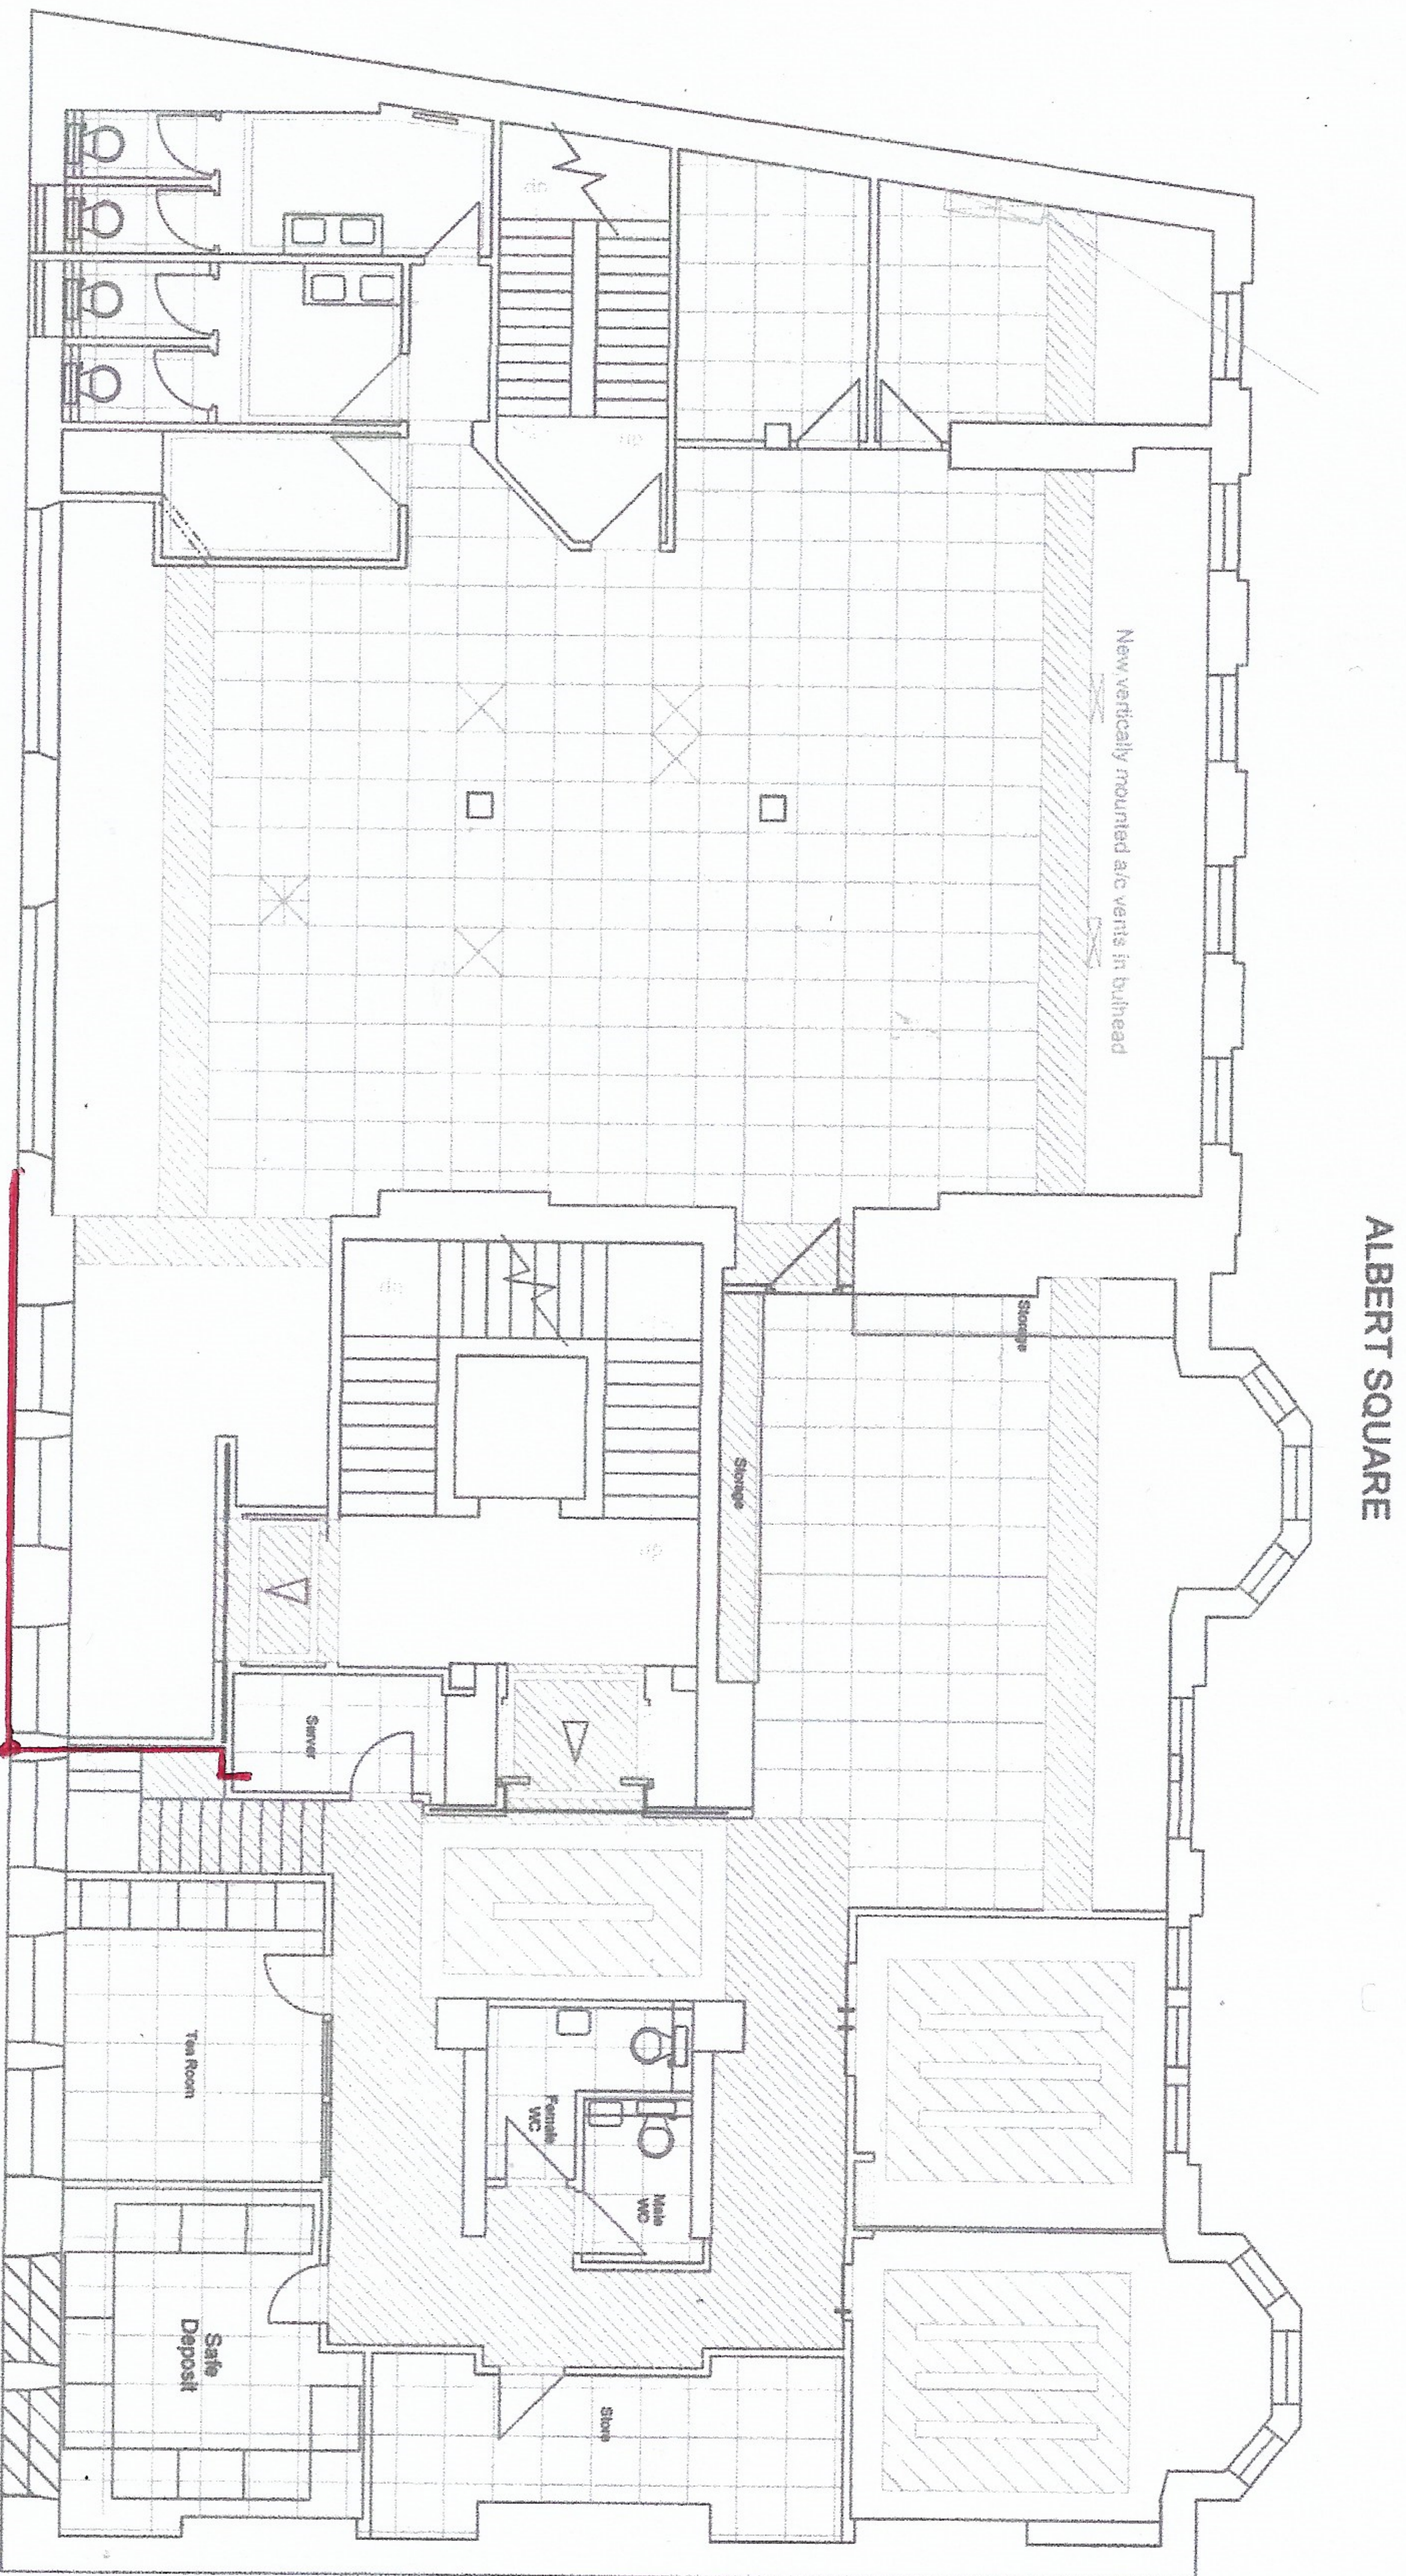

ALBERT SQUARE

COUNTY STREET

Cable —

Scale 1:100 @ A3