


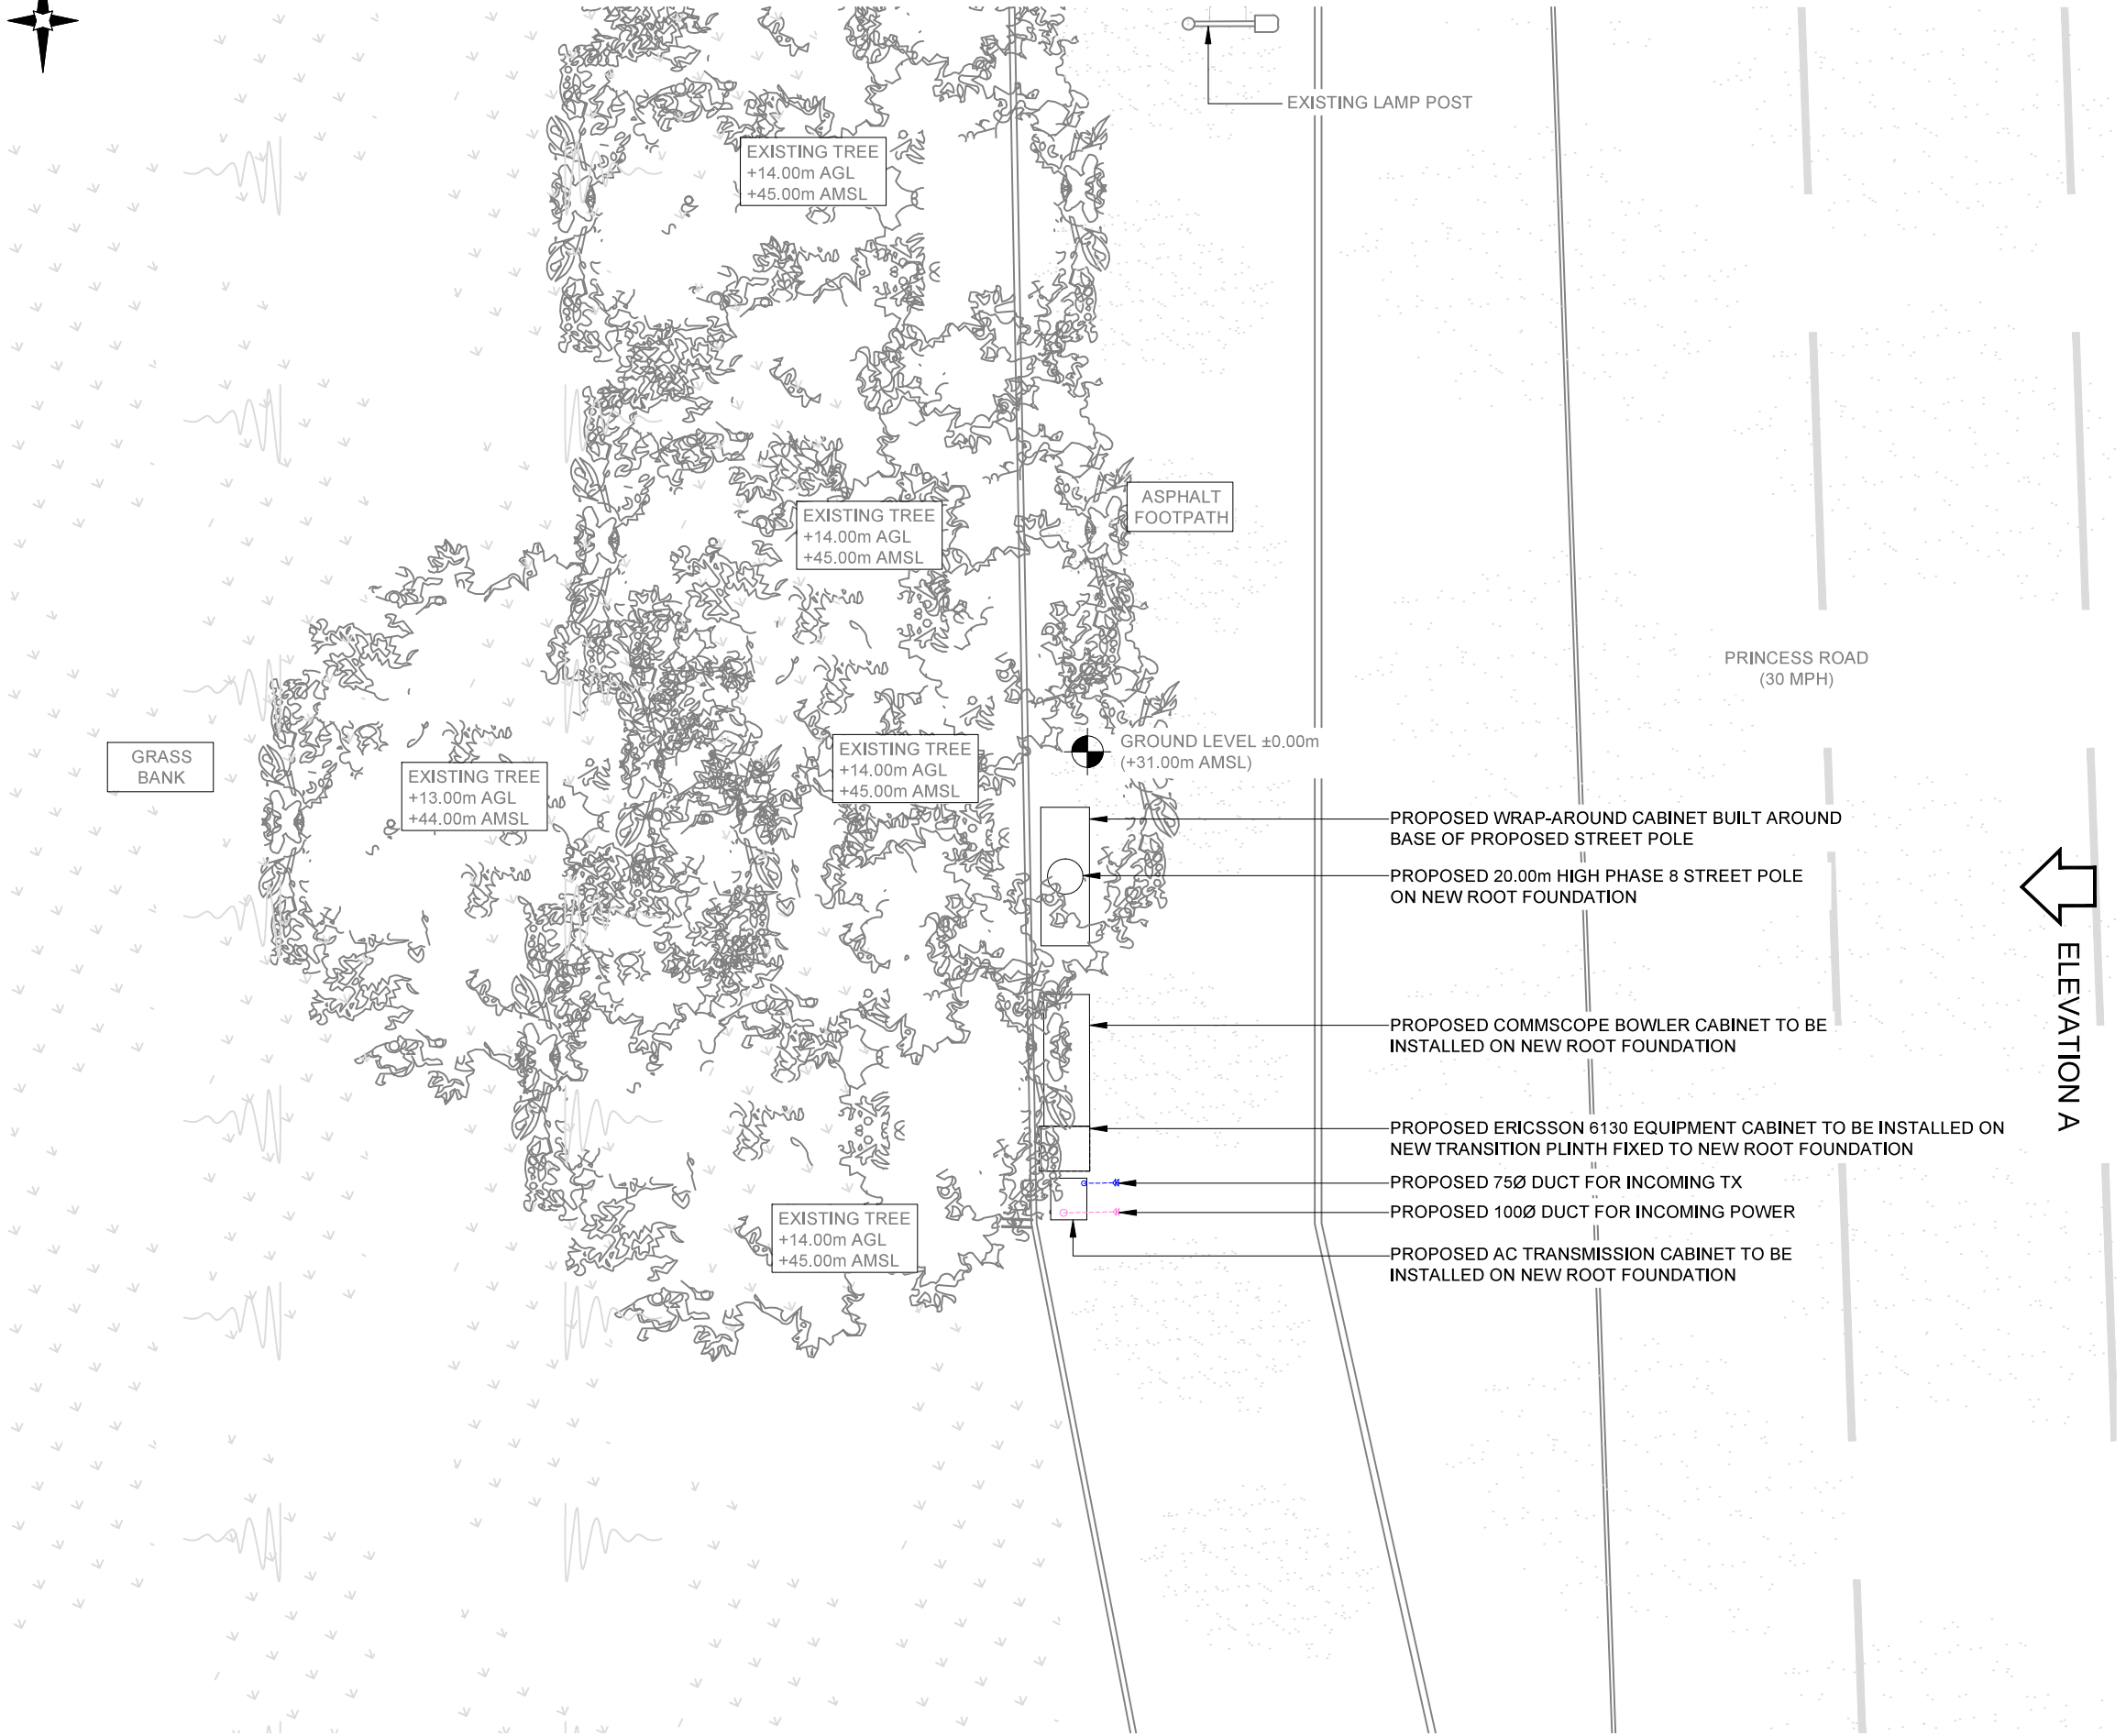

EXISTING LAMP POST

ASPHALT FOOTPATH

PRINCESS ROAD  
(30 MPH)

GROUND LEVEL ±0.00m  
(+31.00m AMSL)

EXISTING TREE  
+14.00m AGL  
+45.00m AMSL

EXISTING TREE  
+14.00m AGL  
+45.00m AMSL

EXISTING TREE  
+14.00m AGL  
+45.00m AMSL

EXISTING TREE  
+13.00m AGL  
+44.00m AMSL

EXISTING TREE  
+14.00m AGL  
+45.00m AMSL

PROPOSED WRAP-AROUND CABINET BUILT AROUND  
BASE OF PROPOSED STREET POLE

PROPOSED 20.00m HIGH PHASE 8 STREET POLE  
ON NEW ROOT FOUNDATION

PROPOSED COMMSCOPE BOWLER CABINET TO BE  
INSTALLED ON NEW ROOT FOUNDATION

PROPOSED ERICSSON 6130 EQUIPMENT CABINET TO BE INSTALLED ON  
NEW TRANSITION PLINTH FIXED TO NEW ROOT FOUNDATION

 
PROPOSED 75Ø DUCT FOR INCOMING TX

PROPOSED 100Ø DUCT FOR INCOMING POWER

PROPOSED AC TRANSMISSION CABINET TO BE  
INSTALLED ON NEW ROOT FOUNDATION

ELEVATION A

PROPOSED SITE PLAN



NOTES:

1. ALL DIMENSIONS IN MM UNLESS OTHERWISE NOTED.

|     |                     |    |     |      |
|-----|---------------------|----|-----|------|
|     |                     |    |     |      |
|     |                     |    |     |      |
|     |                     |    |     |      |
|     |                     |    |     |      |
| A   | Issued for Planning |    | TJP | RWB  |
| REV | MODIFICATION        | BY | CH  | DATE |

CK Hutchison  
Networks (UK)  
Limited

Great Brighams Mead,  
Vastern Road, Reading,  
Berkshire, England,  
RG1 8DJ

Design Consultant & Principal Contractor:



Great British Communications  
Lapwing House, Block 3 Forward Point,  
Tan House Lane, Widnes, Cheshire, WAB 0SL  
t. 44 (0)151 420 4128  
www.gbcservices.co.uk

Site Name: PRINCESS ROAD

3UK Nominal ID: MAN13709

Address: PRINCESS ROAD  
FALLOWFIELD TRIANGLE  
MOSS SIDE  
GREATER MANCHESTER  
M14 4RB

Title: 215 PROPOSED SITE PLAN

Project: UNILATERAL SW

Purpose of Issue: PLANNING

MBNL/TM/H3G Cell ID:  
MAN519/80823/M0931

Drawing No: MAN13709\_MAN519\_80823\_M0931\_GA\_REV\_A

Issue: A