



NOTES:
1. All dimensions must be checked on site and not scaled from this drawing.

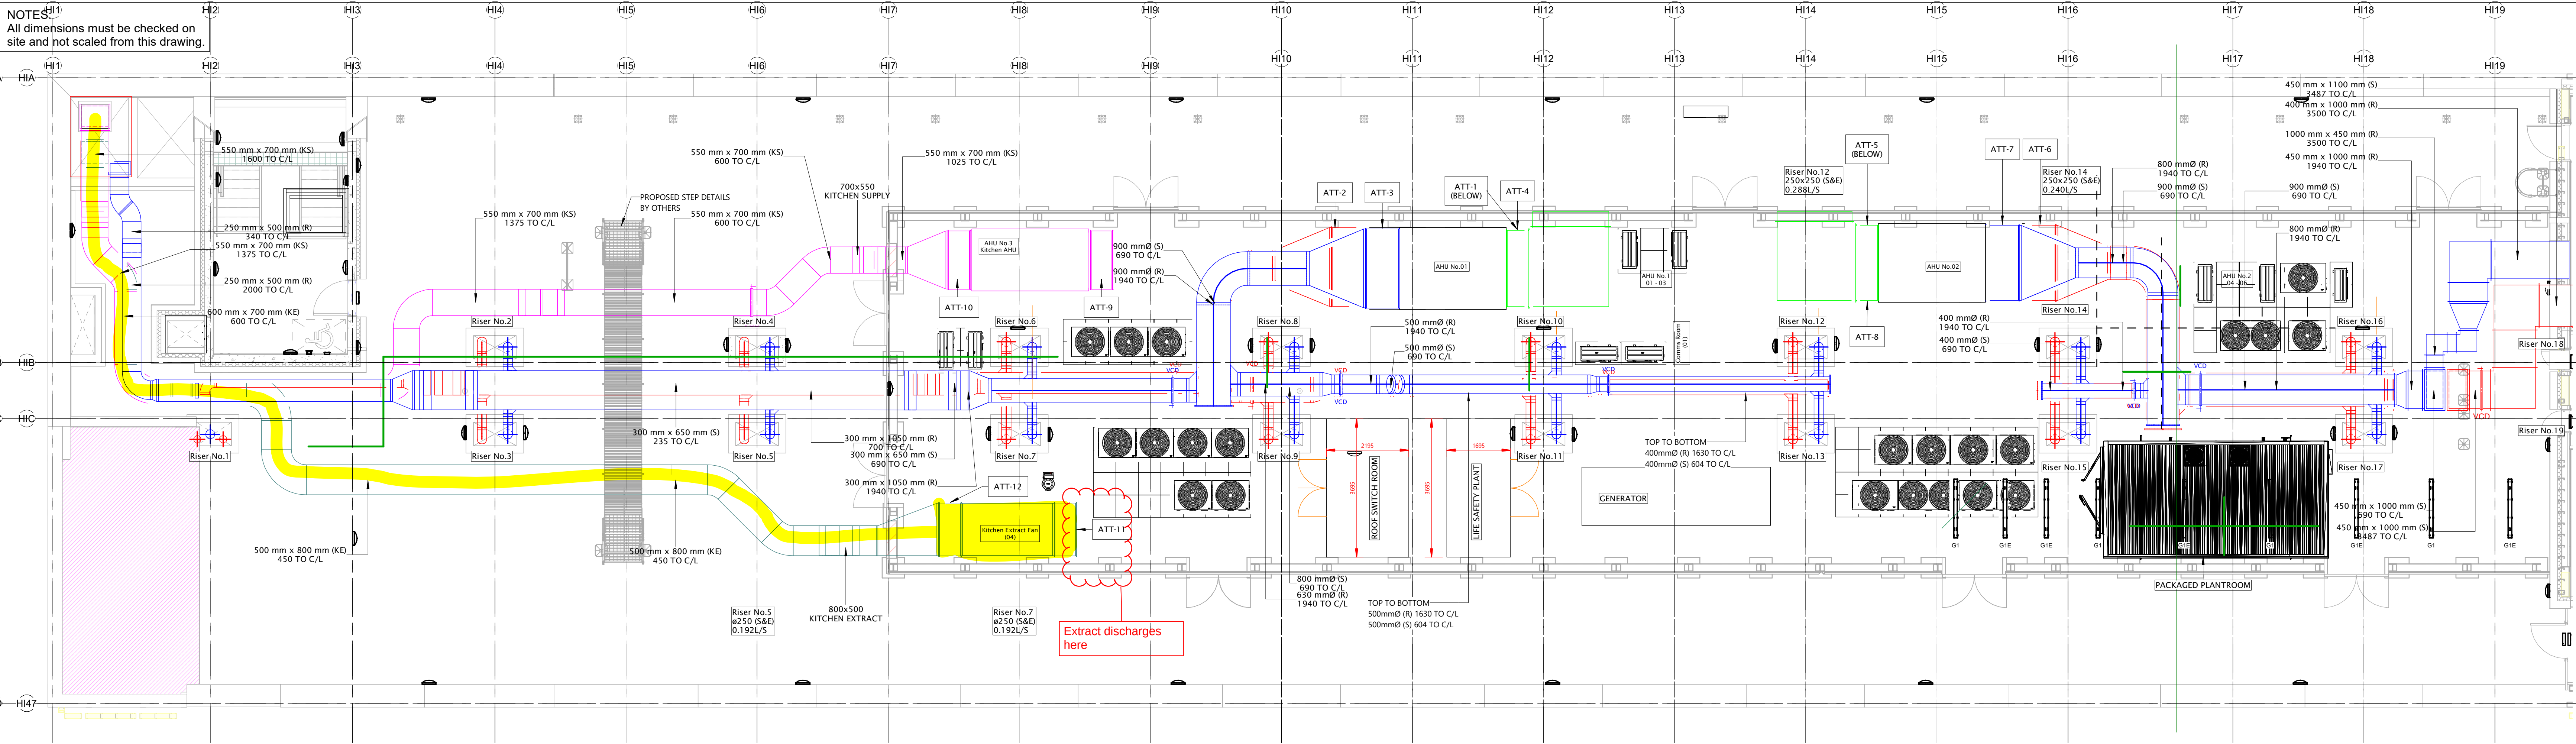

GENERAL NOTES:

- ALL DIMENSIONS ARE IN MILLIMETRES UNLESS OTHERWISE STATED.
- INSULATION INSTALLED ON ALL F.A.I AND EXHAUST DUCTWORK.
- W.C. DOORS ARE UNDERCUT TO PROVIDE VENTILATION PATH ROUTES (10mm).
- ACCESS PANELS INSTALLED AS PER SECTION 20 & TABLE 25 OF DW/144 DOCUMENT.
- TO BE READ IN CONJUNCTION WITH 50 SERIES GUEST ROOM LAYOUTS

VENTILATION LEGEND:

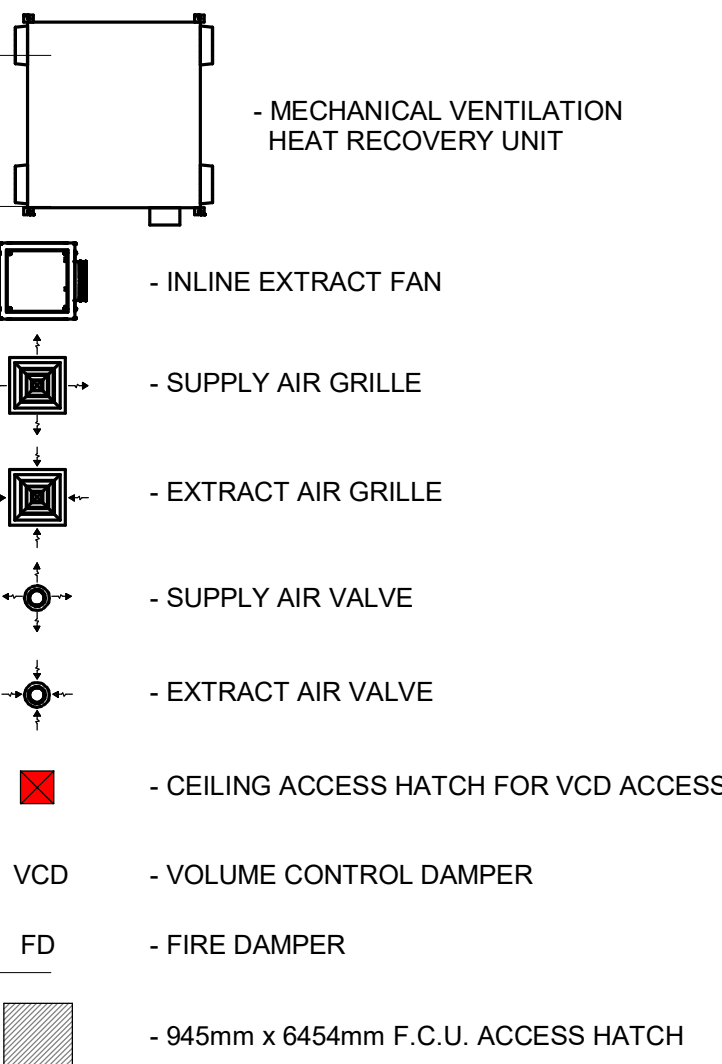





DUCTWORK ACCESS PANELS INSTALLED AS BELOW:

- VOLUME CONTROL DAMPERS- BOTH SIDES
- ATTENUATORS- BOTH SIDES
- INLINE FAN- ONE SIDE
- CHANGE OF DIRECTION- ONE SIDE
- INLET / EXHAUST LOUVER- ONE SIDE
- FIRE DAMPERS- BOTH SIDES

DUCTWORK KEY:



NOTE:
USE IN CONJUNCTION WITH THE FOLLOWING DRAWING:
NC1044-AME-HI-ZZ-M-57-0007 - VENTILATION SCHEMATIC
NC1044-AME-HI-00-M-57-016 - LEVEL 00 - EXTERNAL LOUVRE BUILDERSWORK OPENING DETAILS
NC1044-AME-HI-07-M-57-017 - LEVEL 07 - EXTERNAL LOUVRE BUILDERSWORK OPENING DETAILS
NC1044-AME-HI-XX-M-57-018 - VENTILATION SCHEDULE DETAILS
AHTW 1725-5050-FG-WP - AHU 01
AHTW 1675-5050-FG-WP - AHU 02
AH 1600-5050-FG-WP - KITCHEN SUPPLY FAN
BDA 900 - KITCHEN EXTRACT FAN

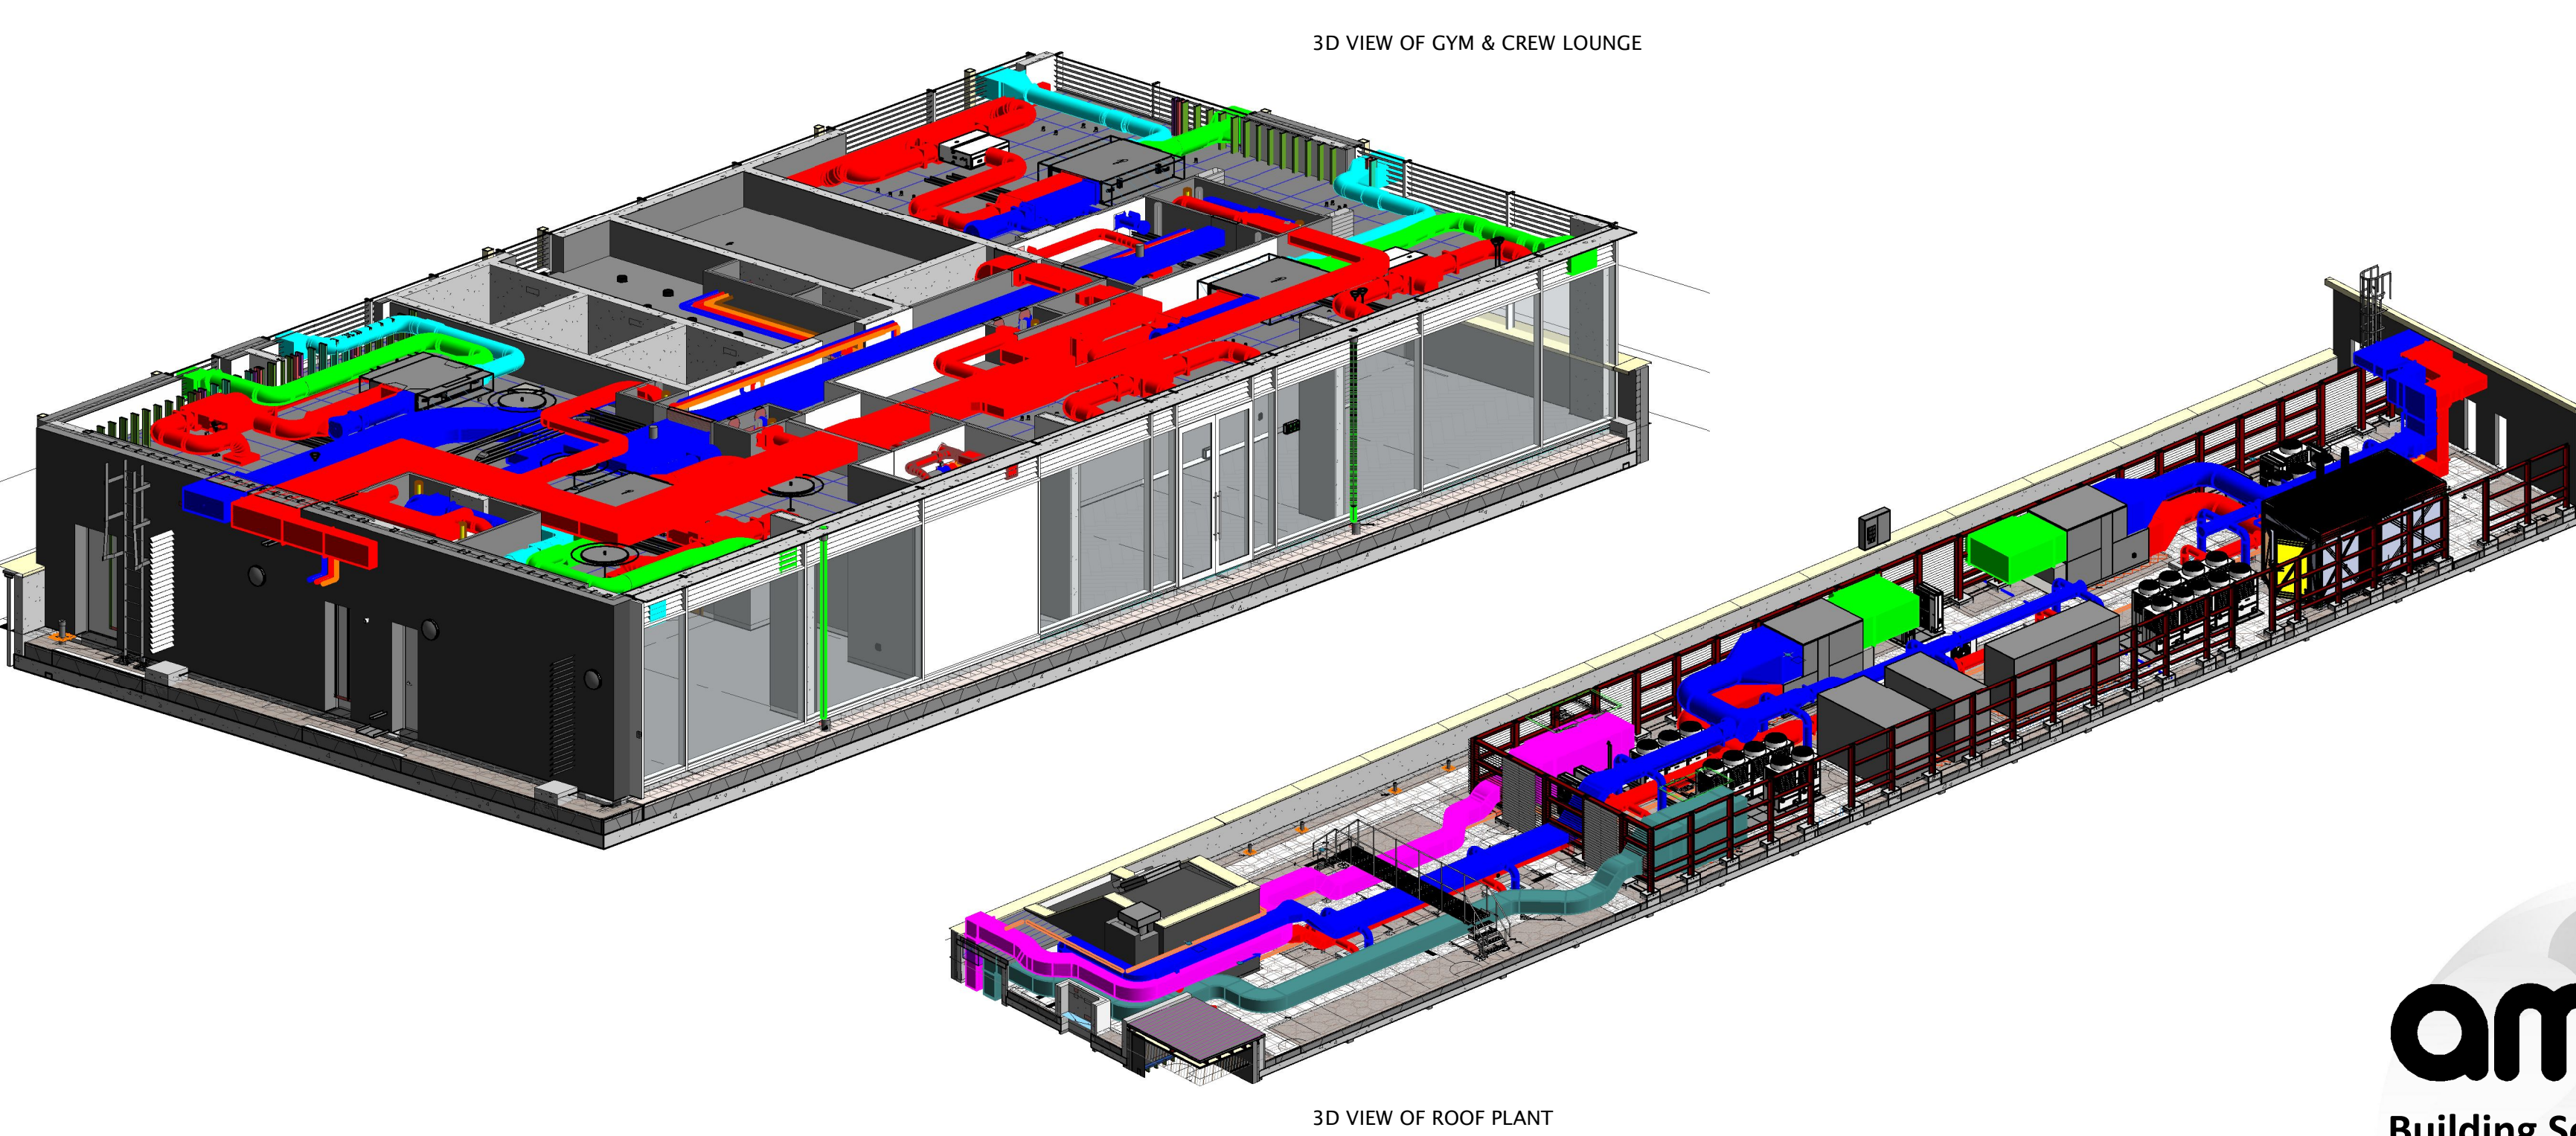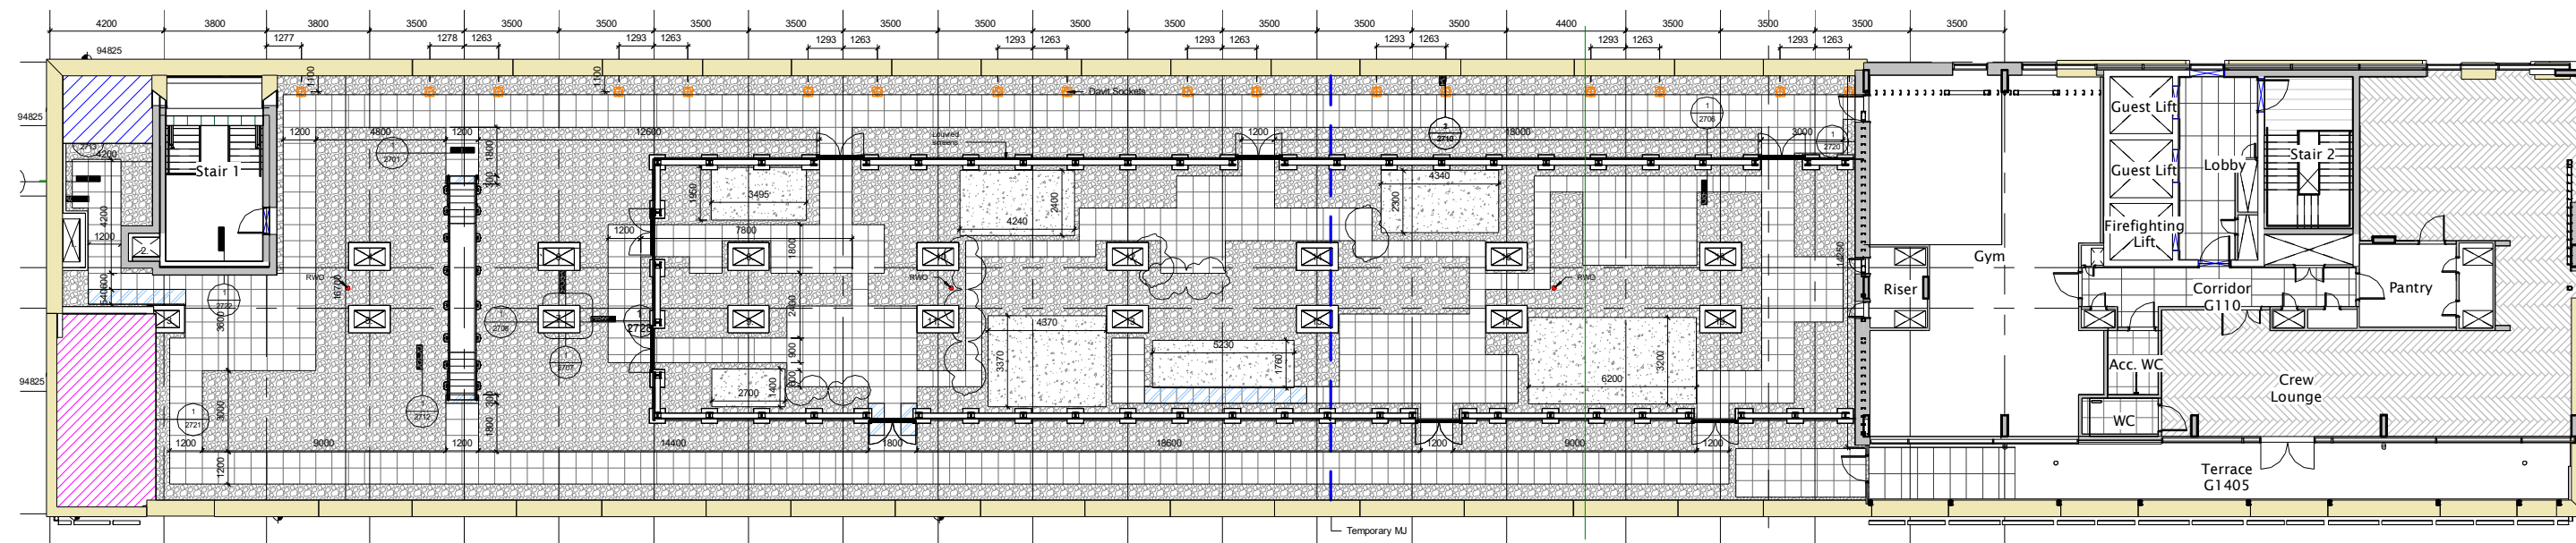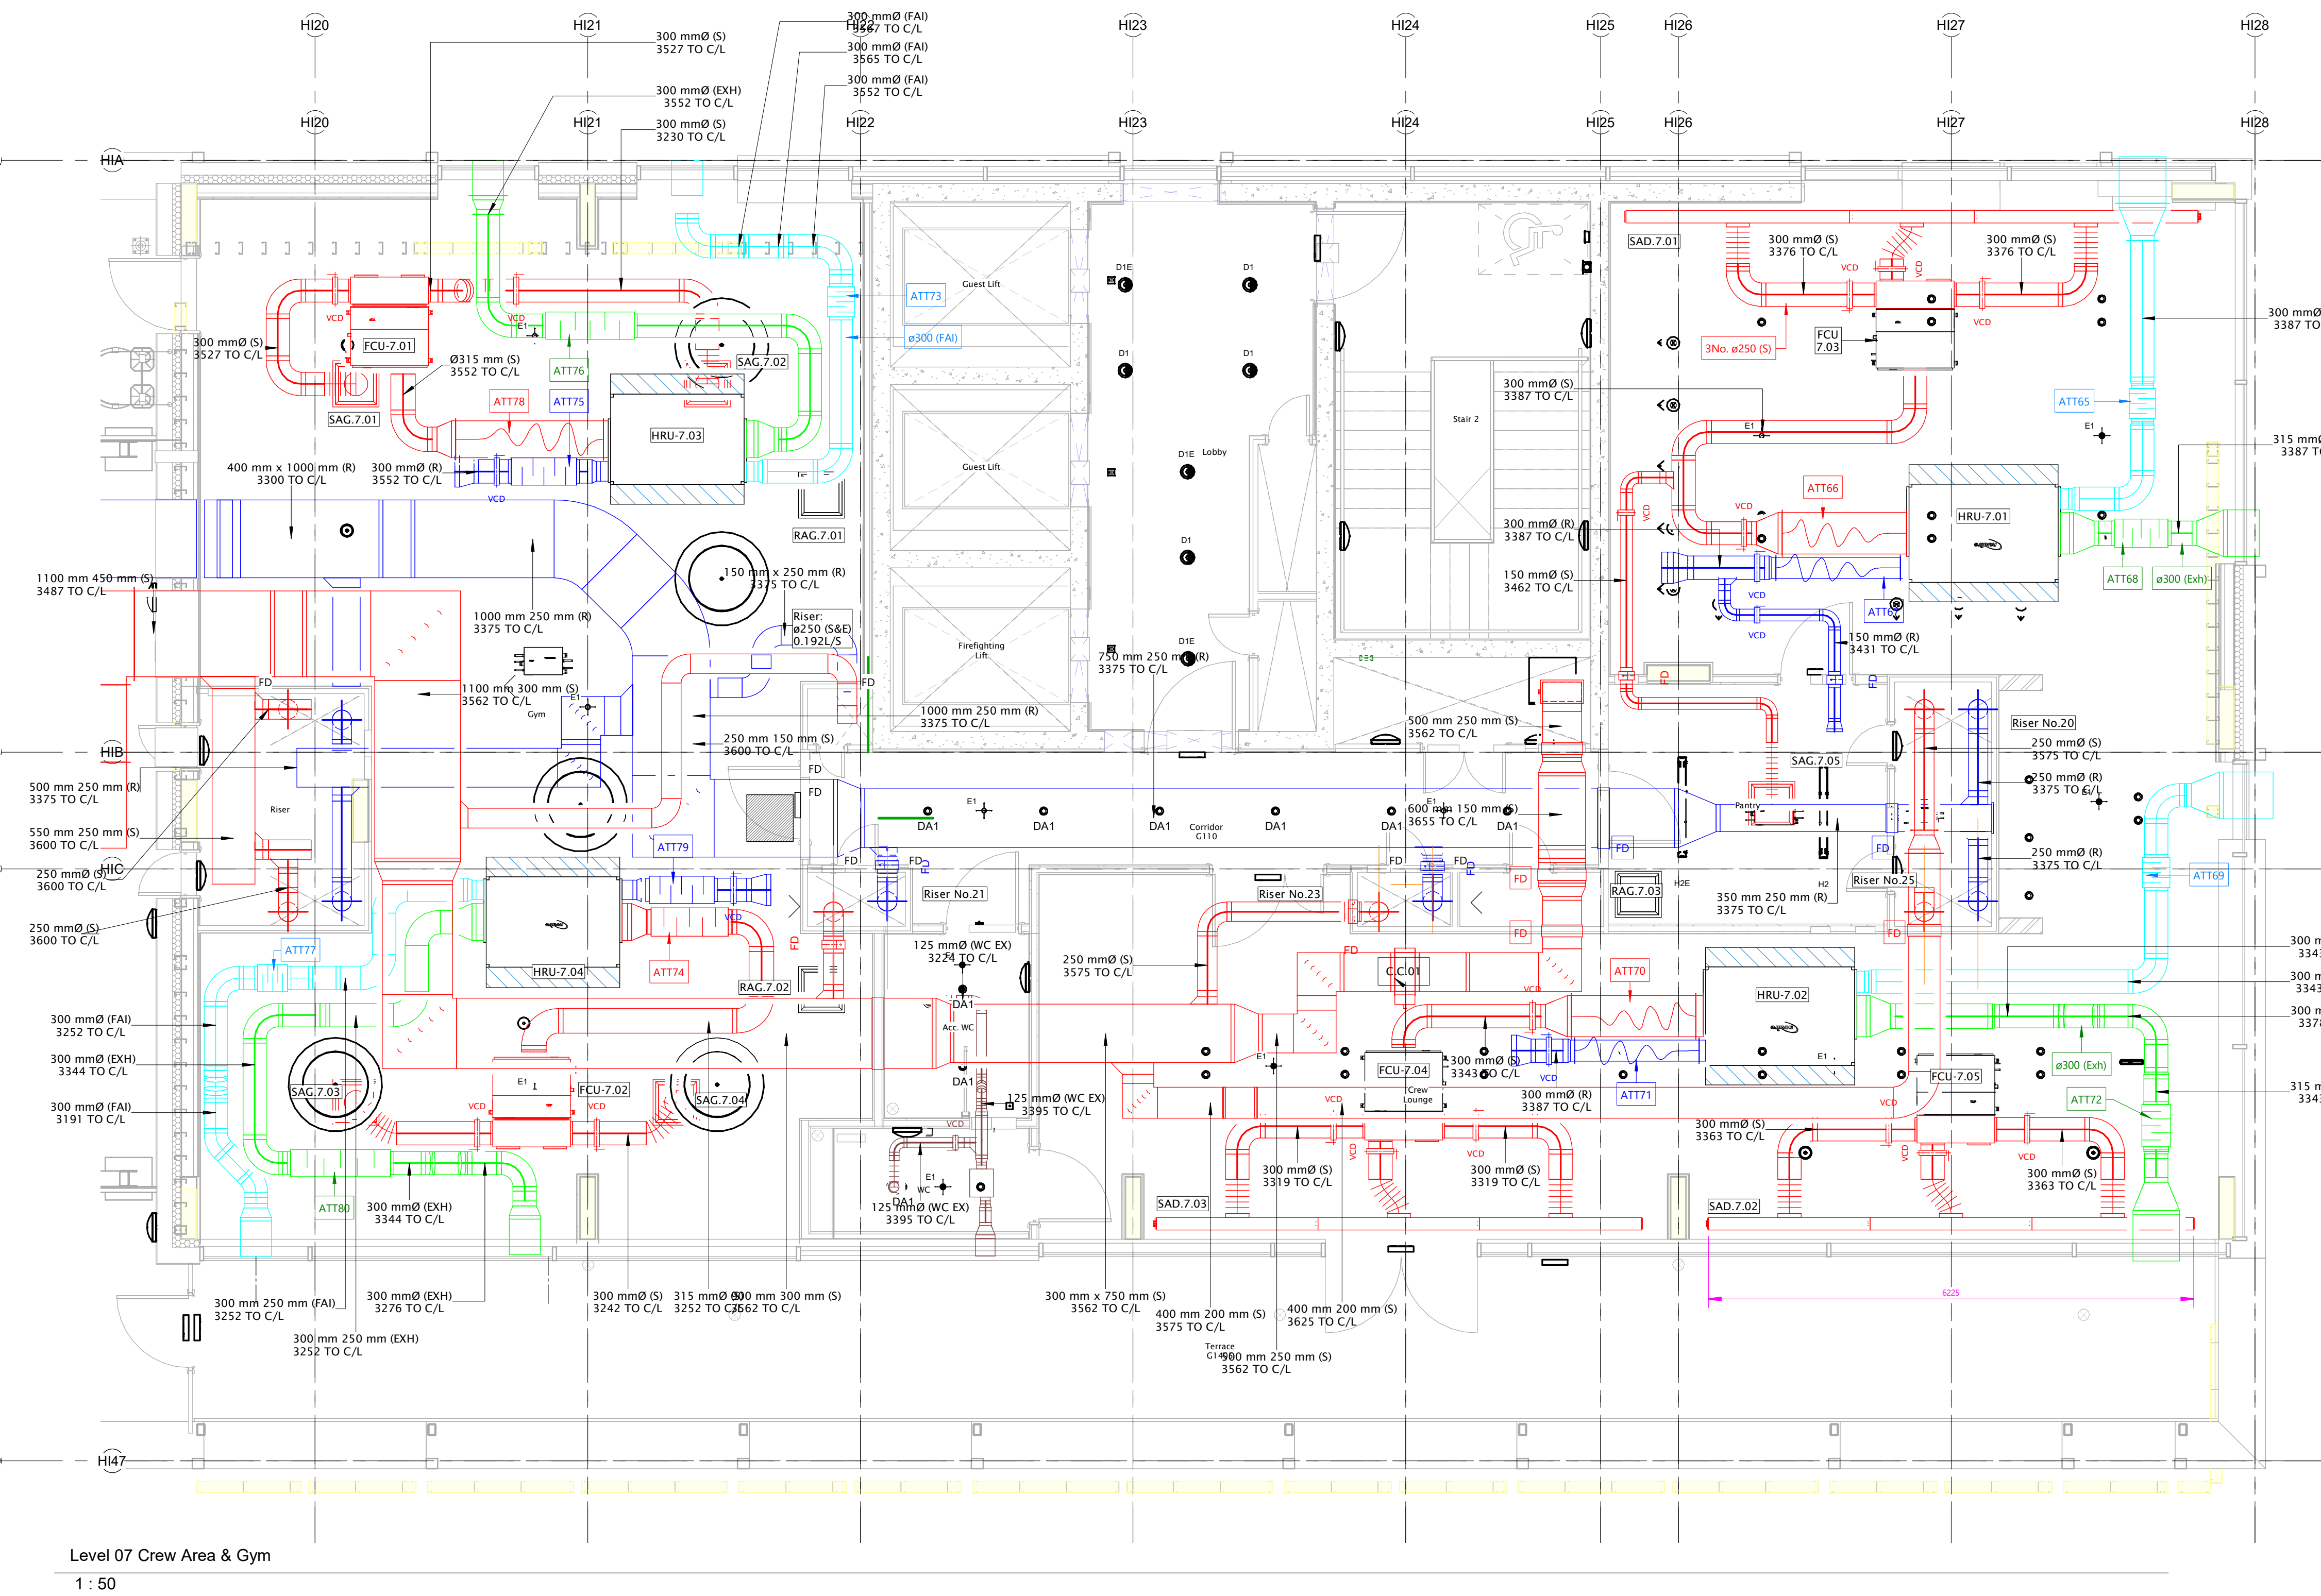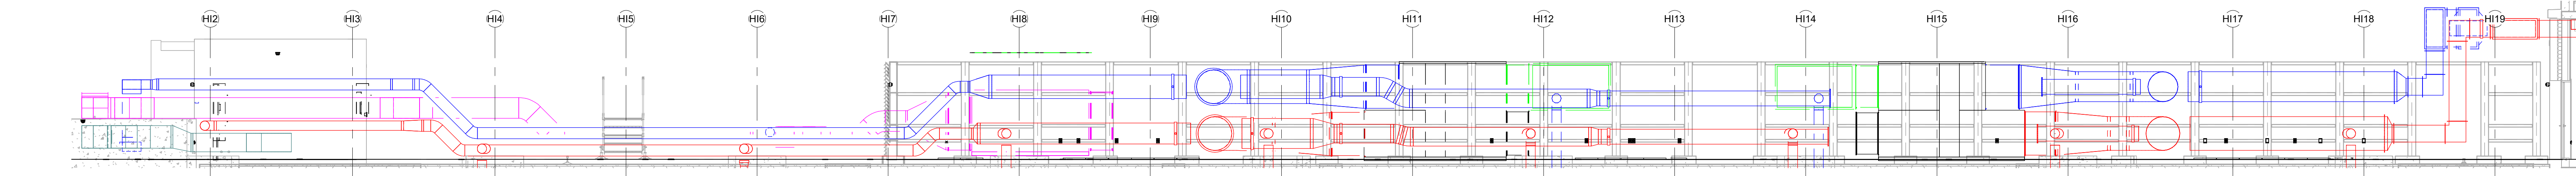

CONSTRUCTION ISSUE

Client	Job Title	Drawing Title	Date
BCEGI 北京建工国际	ACN P1 - HOLIDAY INN	Level 07 & Roof Areas - Ventilation & AC Layout	MAY 2020
			Scale # A0
			As indicated
			Drawn by I.M.
			Check by I.M.
			Drawing Number
			API-AME-HI-ZZ-DR-M-57-0003
			Revision
			C05