


NOTE:
VCD HANDLES TO BE POSITIONED
TO SUIT ACCESS PANEL LOCATIONS

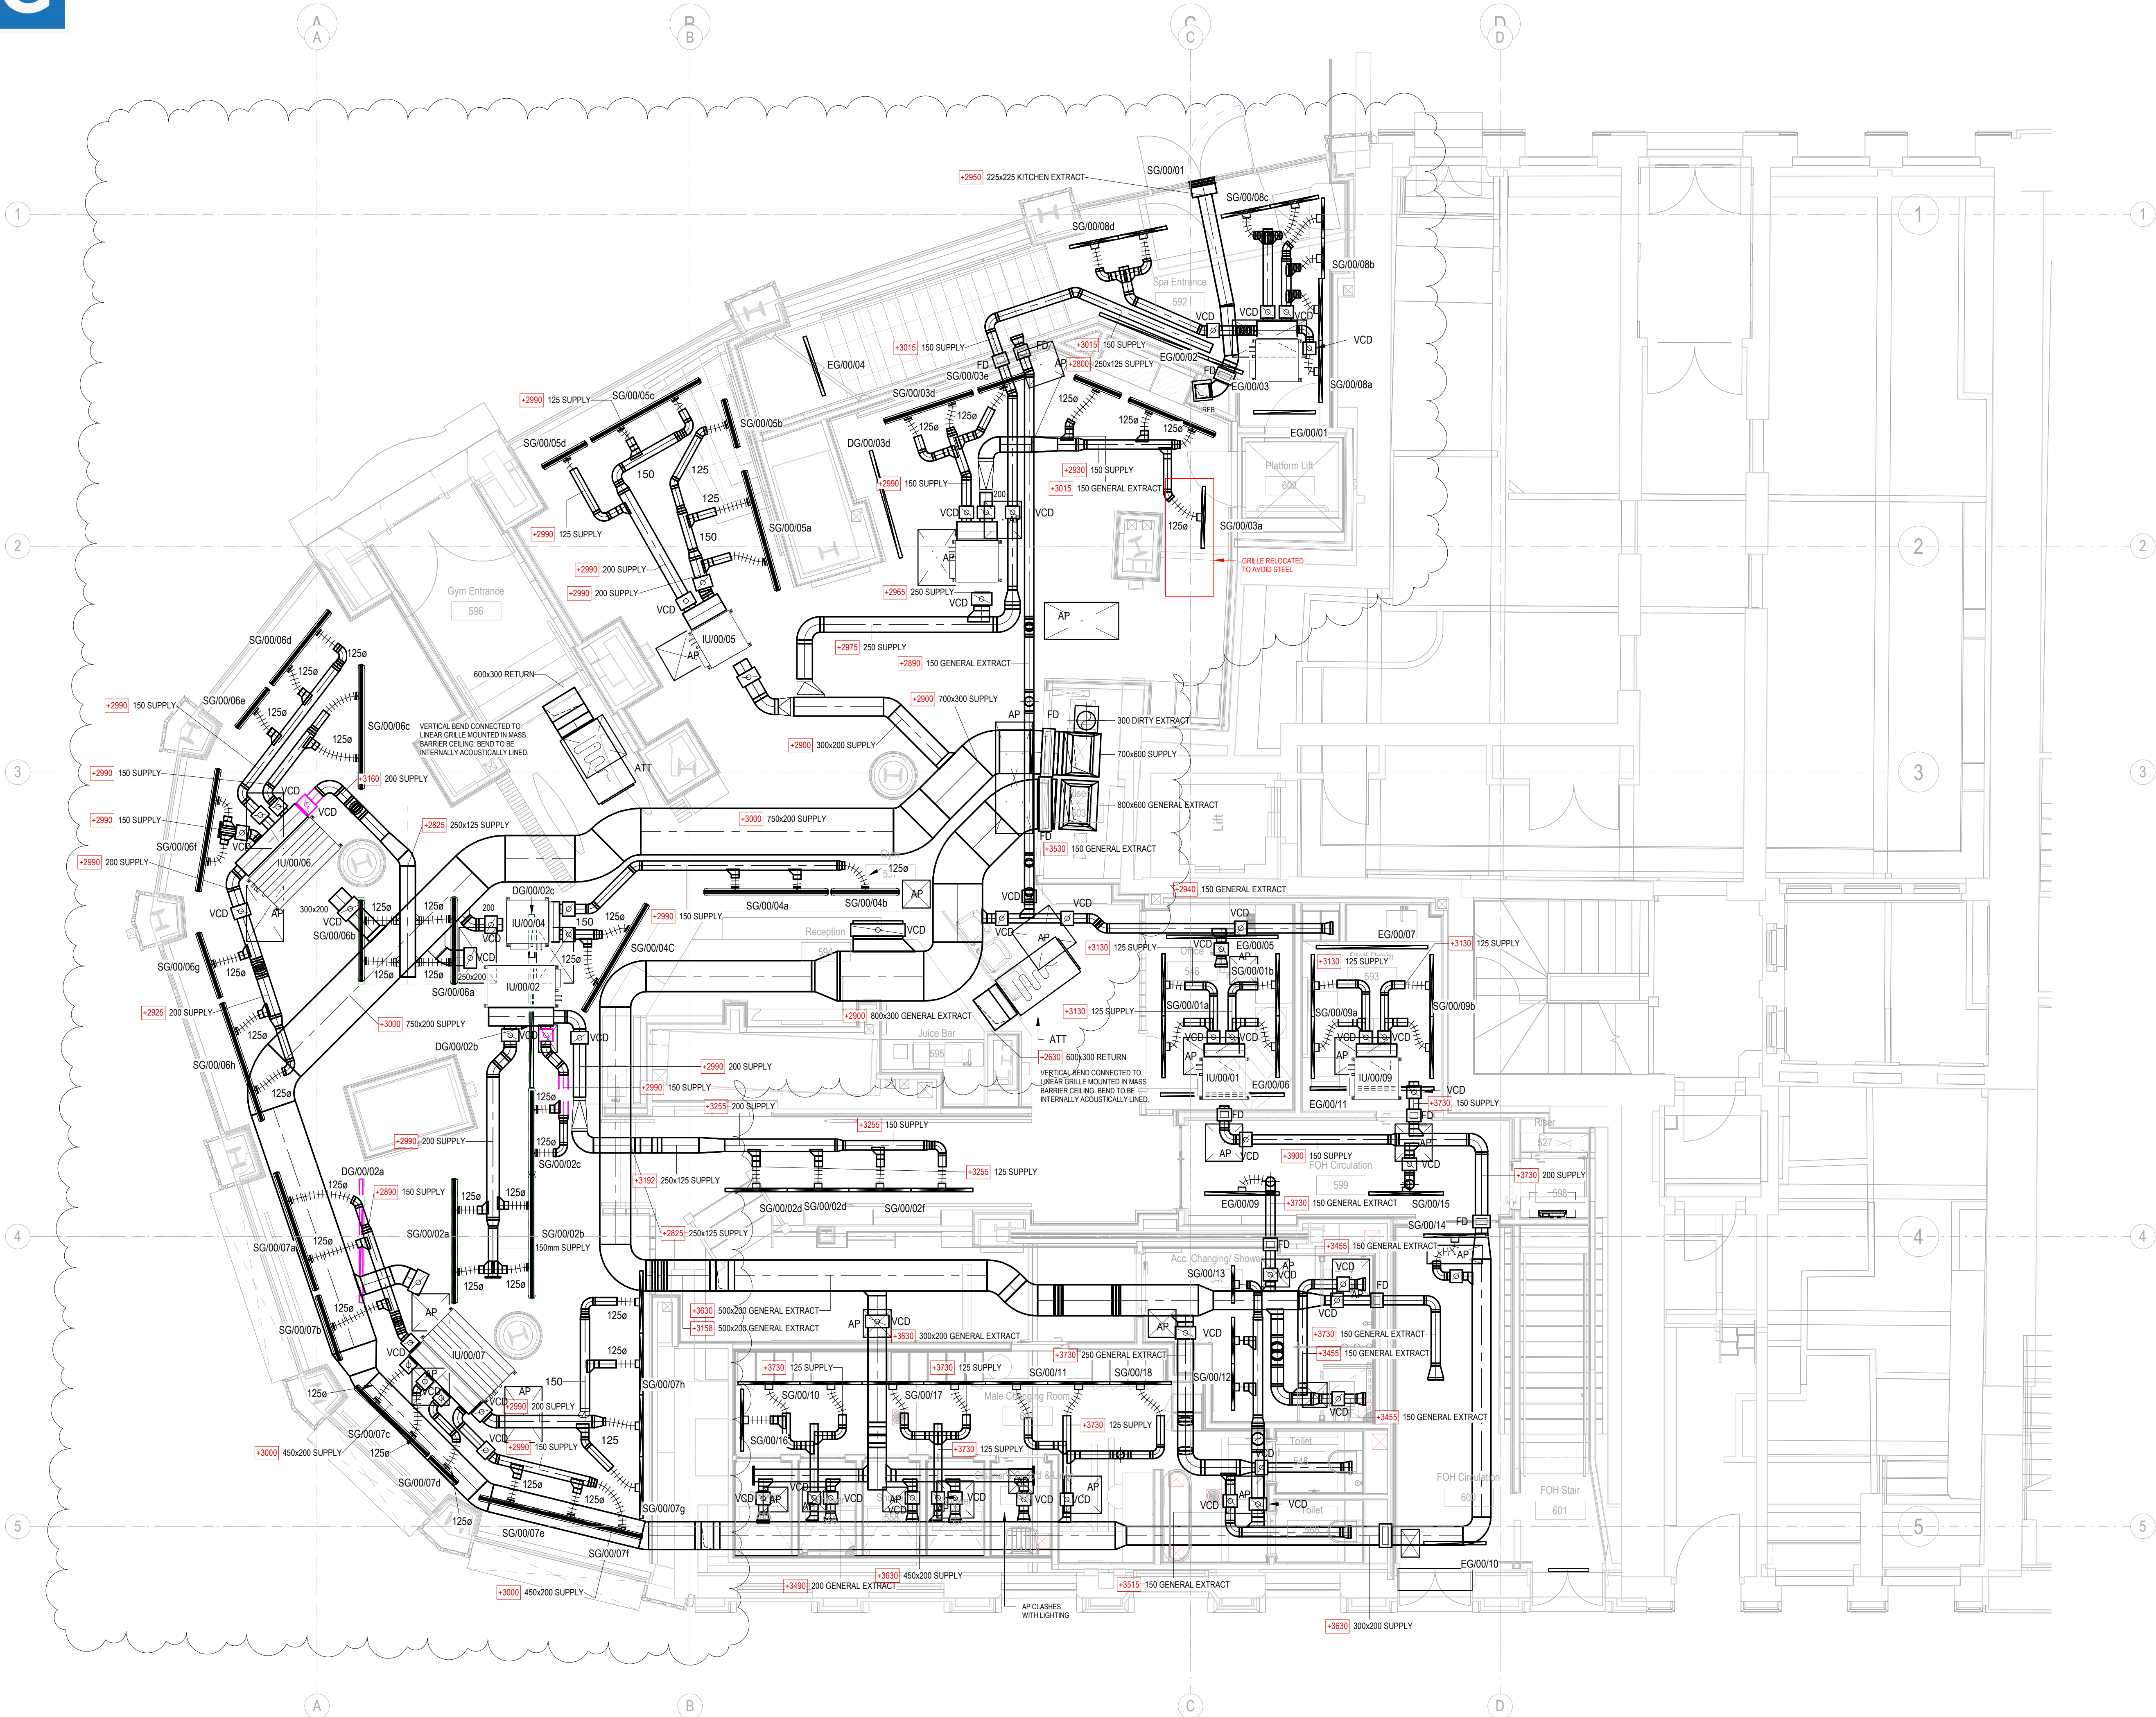

P01	GYM VENTILATION UPDATED TO SUIT SITE CONDITIONS & REISSUED FOR APPROVAL	27.07.2021	CG	JMG
REV	DESCRIPTION	DATE	BY	CHKD
REVISION SCHEDULE				
STATUS				
FOR APPROVAL				
PROJECT TITLE				
SPA@KSTH				
DRAWING TITLE				
GROUND FLOOR VENTILATION LAYOUT				
DRAWING NUMBER		REV	SIZE	SCALE
THG-FGM-BS-GF-DR-M-570101		P01	A1	1:50
DRAWN BY	DATE	CHECKED BY	DATE	
	23.06.2021		23.06.2021	