
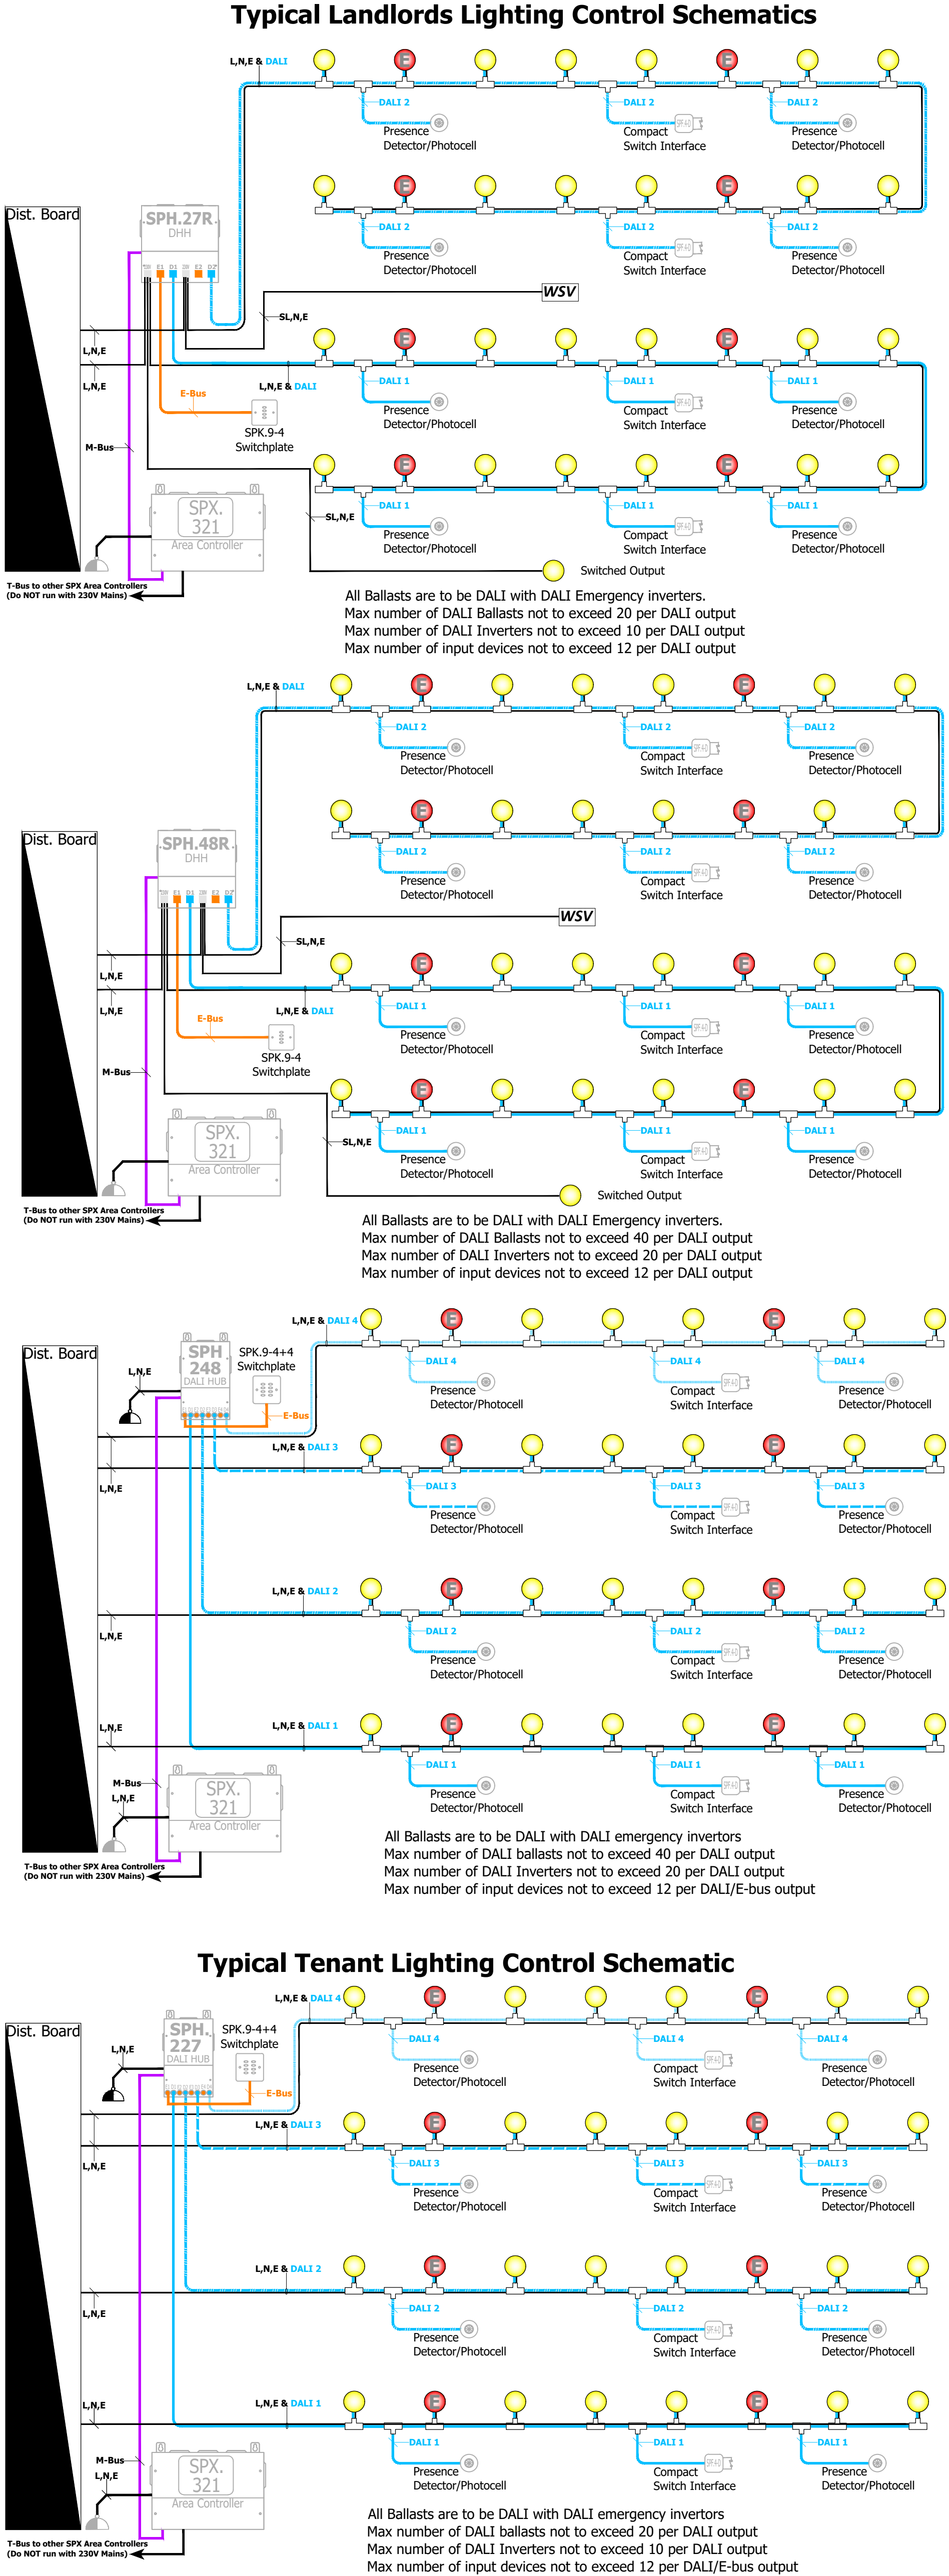


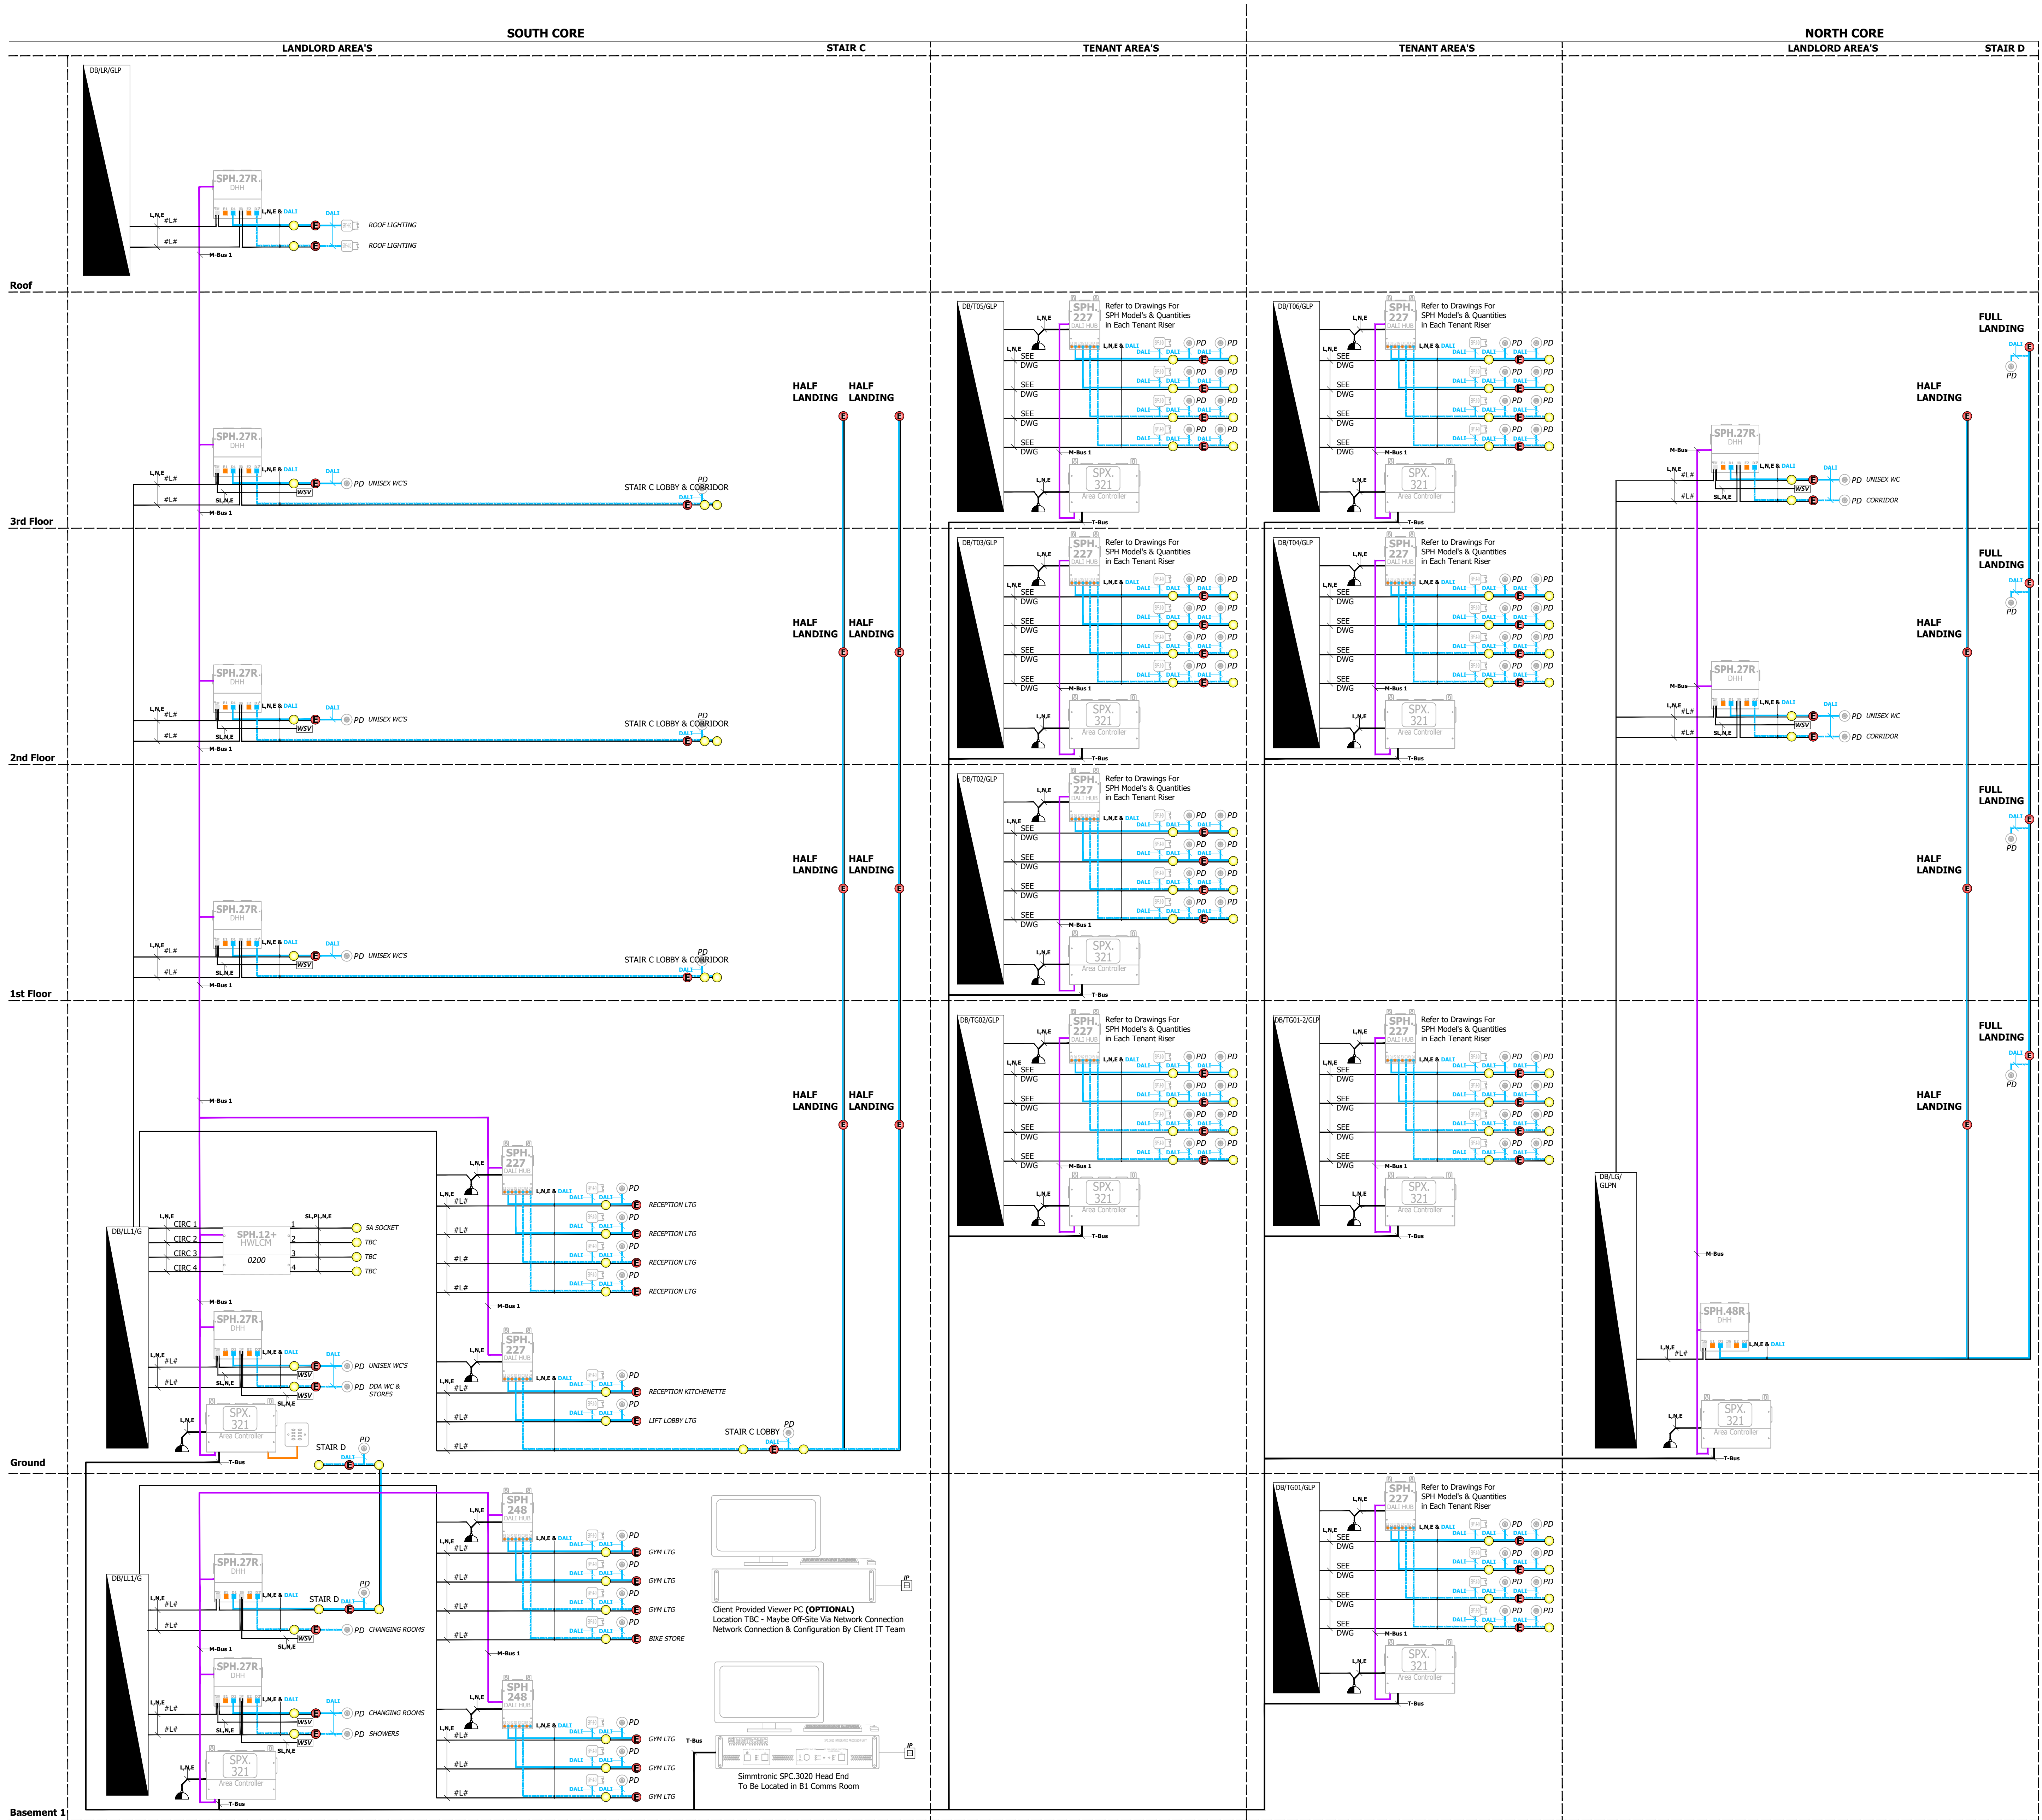

Do not scale from this drawing.
Verify dimensions by site measurement.
Read this drawing in conjunction with the latest architectural and structural drawings.
This drawing is based on the following information:-

- Notes
1. This drawing to be read in conjunction with all mechanical, electrical & public health drawings for this contract.
 2. All services work to be carried out in accordance with the relevant Engineering Specification for this contract.

01	29/04/22	Stage 4 Tender Issue.	RMF	RMF
Revision	Date	Description	Drawn	Checked

HIM
hilsonmoran.com info@hilsonmoran.com

Client
Bruntwood

Project
38 - 42 Mosley Street
Grade 2*
Listed Building Refurbishment

Drawing Title
Electrical Services
Lighting Control Schematic

Scale	Sheet Size	Checked	Approved
N.T.S	A0	RMF	SR
Status			HM Project No.
RIBA STAGE 4 TENDER ISSUE			27618
Drawing No.			Rev
27618-HM-ZZ-ZZ-DR-ES-2100			01