


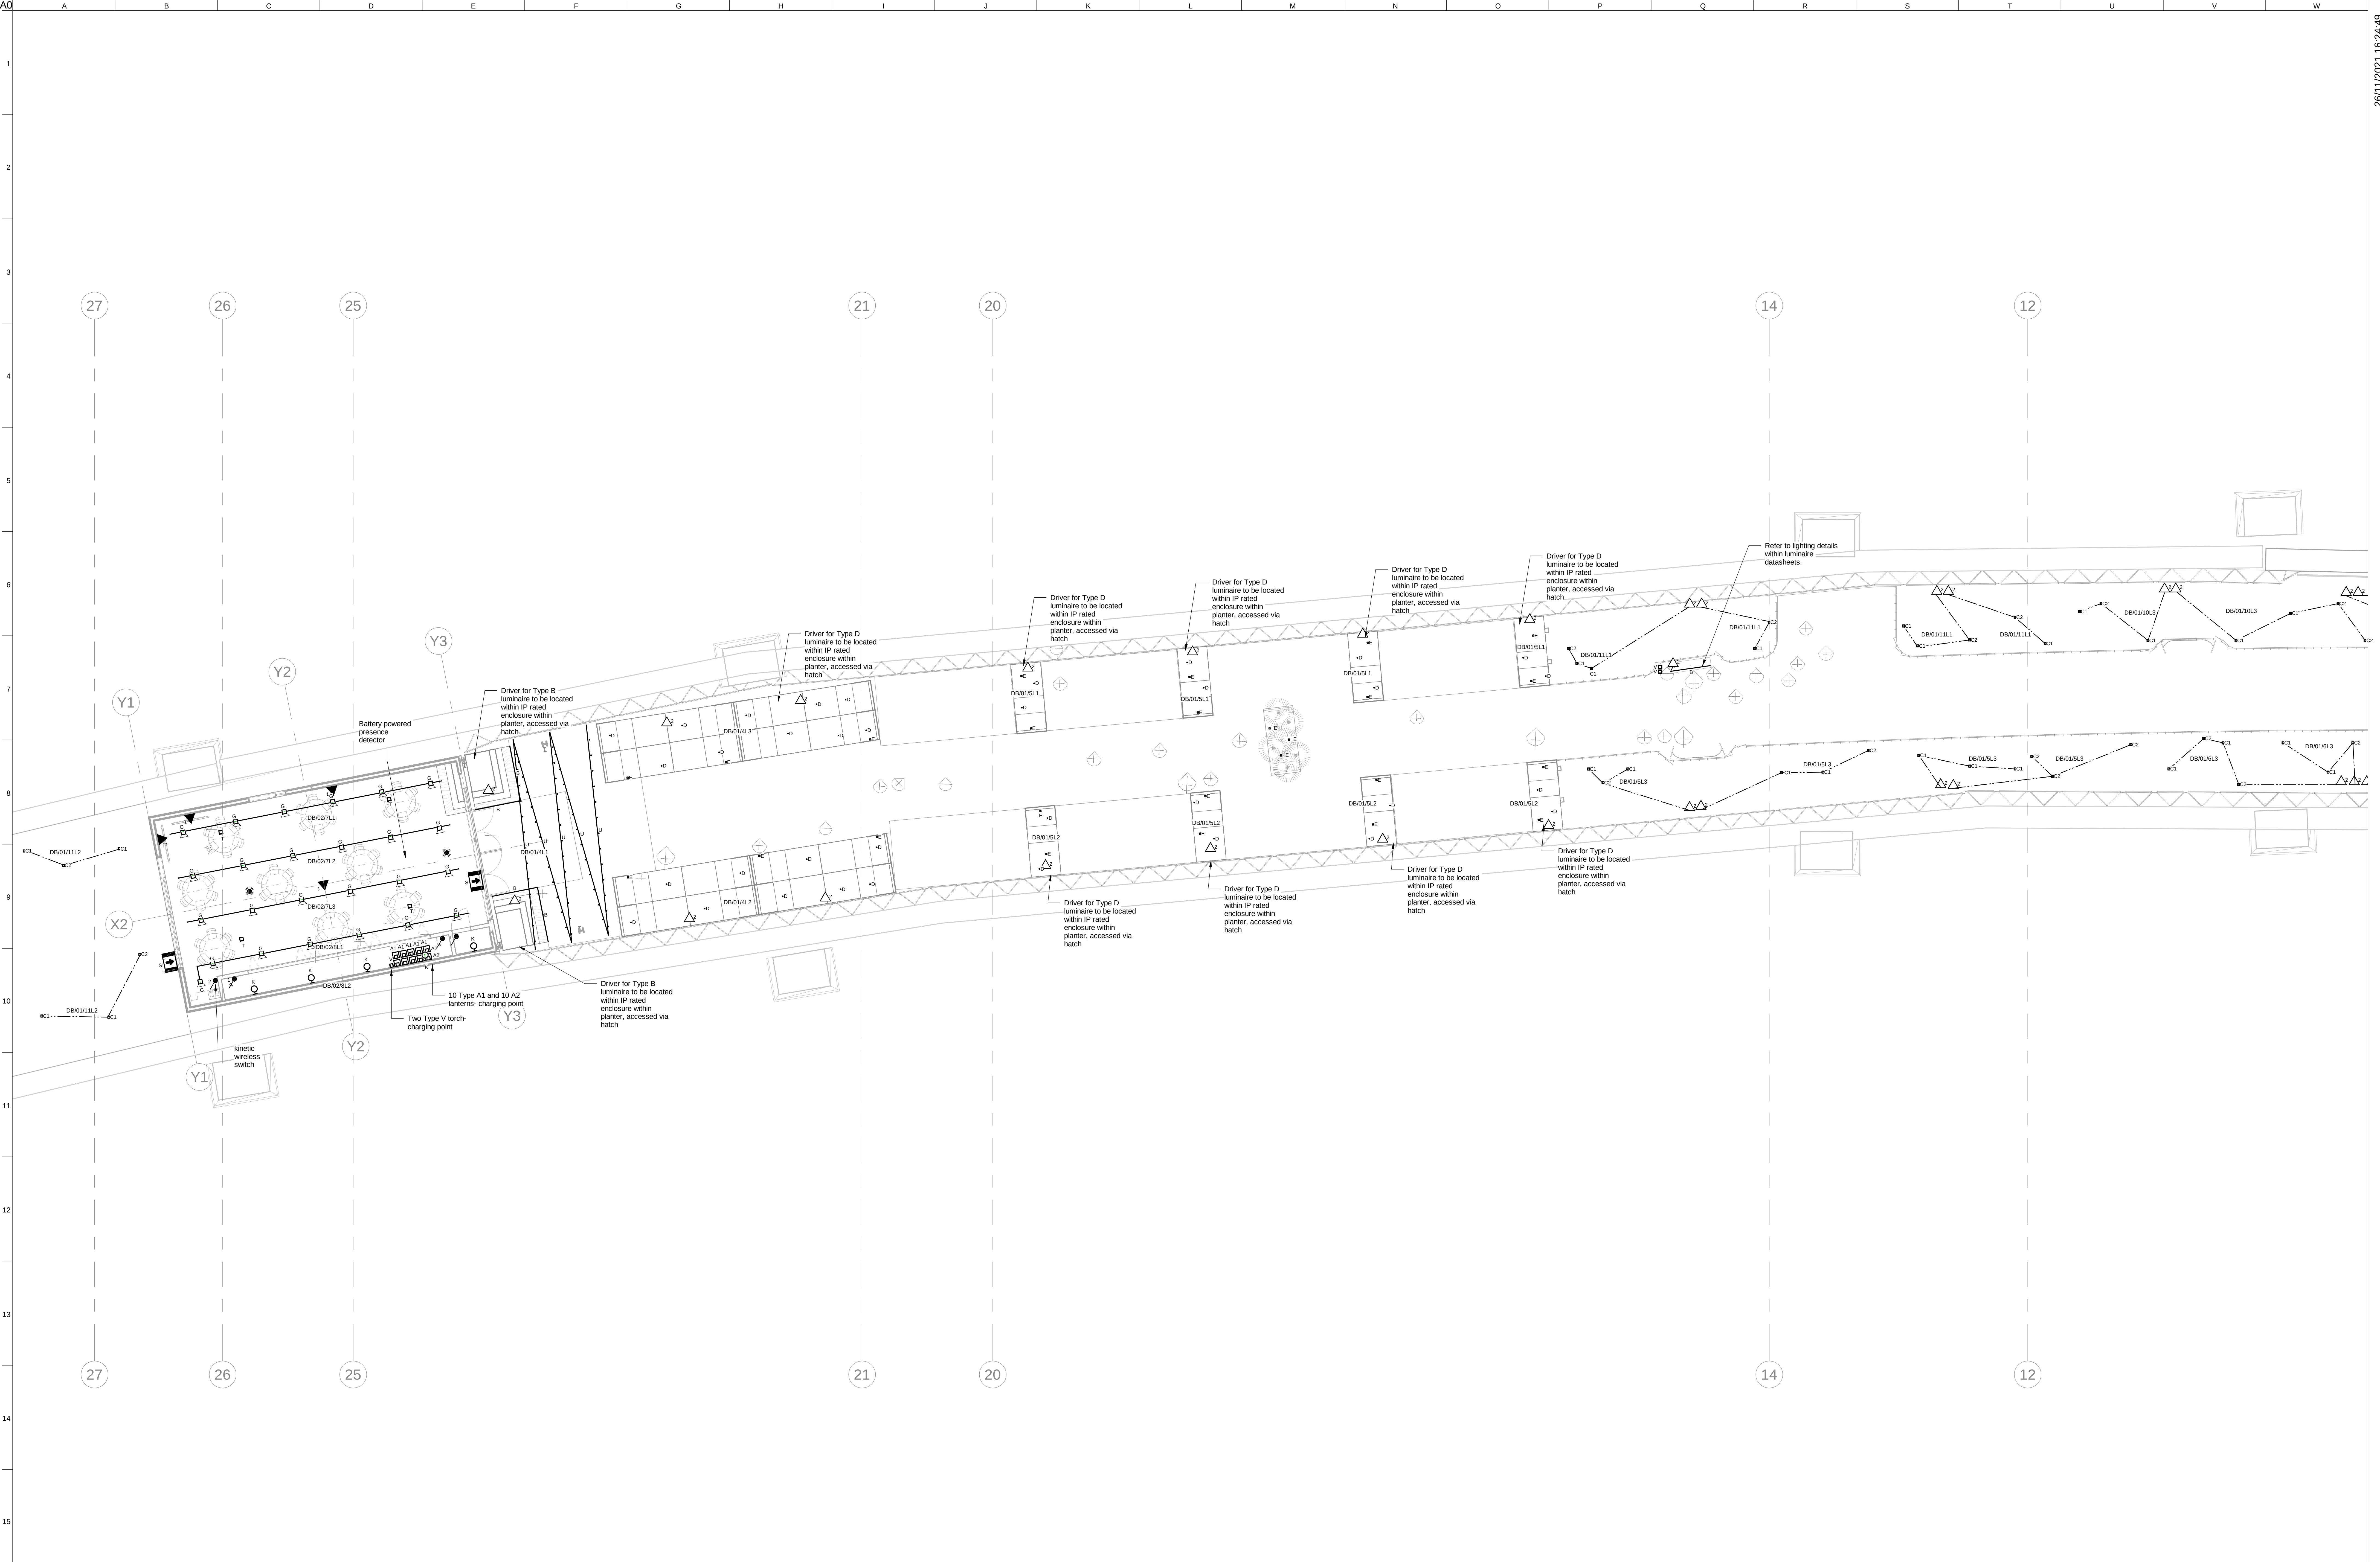

General Notes

1. This drawing shall be read in conjunction with all other relevant Arup drawings, details specifications and reports.

2. All dimensions are illustrated in mm, unless otherwise stated.

3. Do not scale from this drawing.

4. Layout based on architectural Revit model received on 10/11/2021.

5. This Drawing is not an Installation Drawing.

6. All drivers located within plastic IP65 enclosure. Driver locations and quantities are indicative and exact location to be determined on site.

7. Refer to luminaire data sheets for detailed specification of luminaires, mounting requirements and attachments/accessories.

8. Planter spot lights, Type D, are indicatively placed in this drawing, final location to be determined on site.

9. Type B shall be mounted to underside of bench, detail of this can be found in the luminaire schedule.

10. Type C1 and C2 are sculptural reed lights to highlight the presence of soft planting within landscape areas.

- Legend**
- Type A1 Lantern Luminaire
 - Type A2 Lantern Luminaire
 - Type B Linear LED tape
 - Type C1 and C2 Reed lighting
 - Type D Spike mounted spot light
 - Type E Bollard luminaire
 - Type F Surface mounted Linear LED
 - Type G Track and Spot lights
 - Type K Wall mounted bulk head
 - Type S Illuminated exit sign
 - Type T Surface mounted emergency light
 - Type U Festoon lighting
 - Type V Torch
 - Driver
 - Presence Detector
 - Manual Switch

PO1	26/11/21	WS4 Issue
Issue	Date	

ARUP

6th Floor, 3 Piccadilly Place
Manchester M1 3BN
T: +44(0)161 229 3331 Fax: +44(0)161 229 6979
www.arup.com

Client
The National Trust

Project Title
Castlefield Viaduct

Drawing Title
Lighting Layout
Sheet 1

Scale at A0	1 : 100	By / Chkd / Appd	SR/LB/DL
Date	Electrical	Status	S2 - Issued for Information
Arup Job No	282210	Rev	P01
ID	CVI-ARUP-ZZ-GF-DR-E-002501		