



Notes

- This drawing to be read in conjunction with all mechanical, electrical & public health drawings for this contract.
- All services work to be carried out in accordance with the relevant Engineering Specification for this contract.
- All existing Mechanical Services installations shall be isolated, disconnected and stripped out throughout the entire building unless stated otherwise. All stripped out materials to be disposed of in accordance with WEEE regulations.

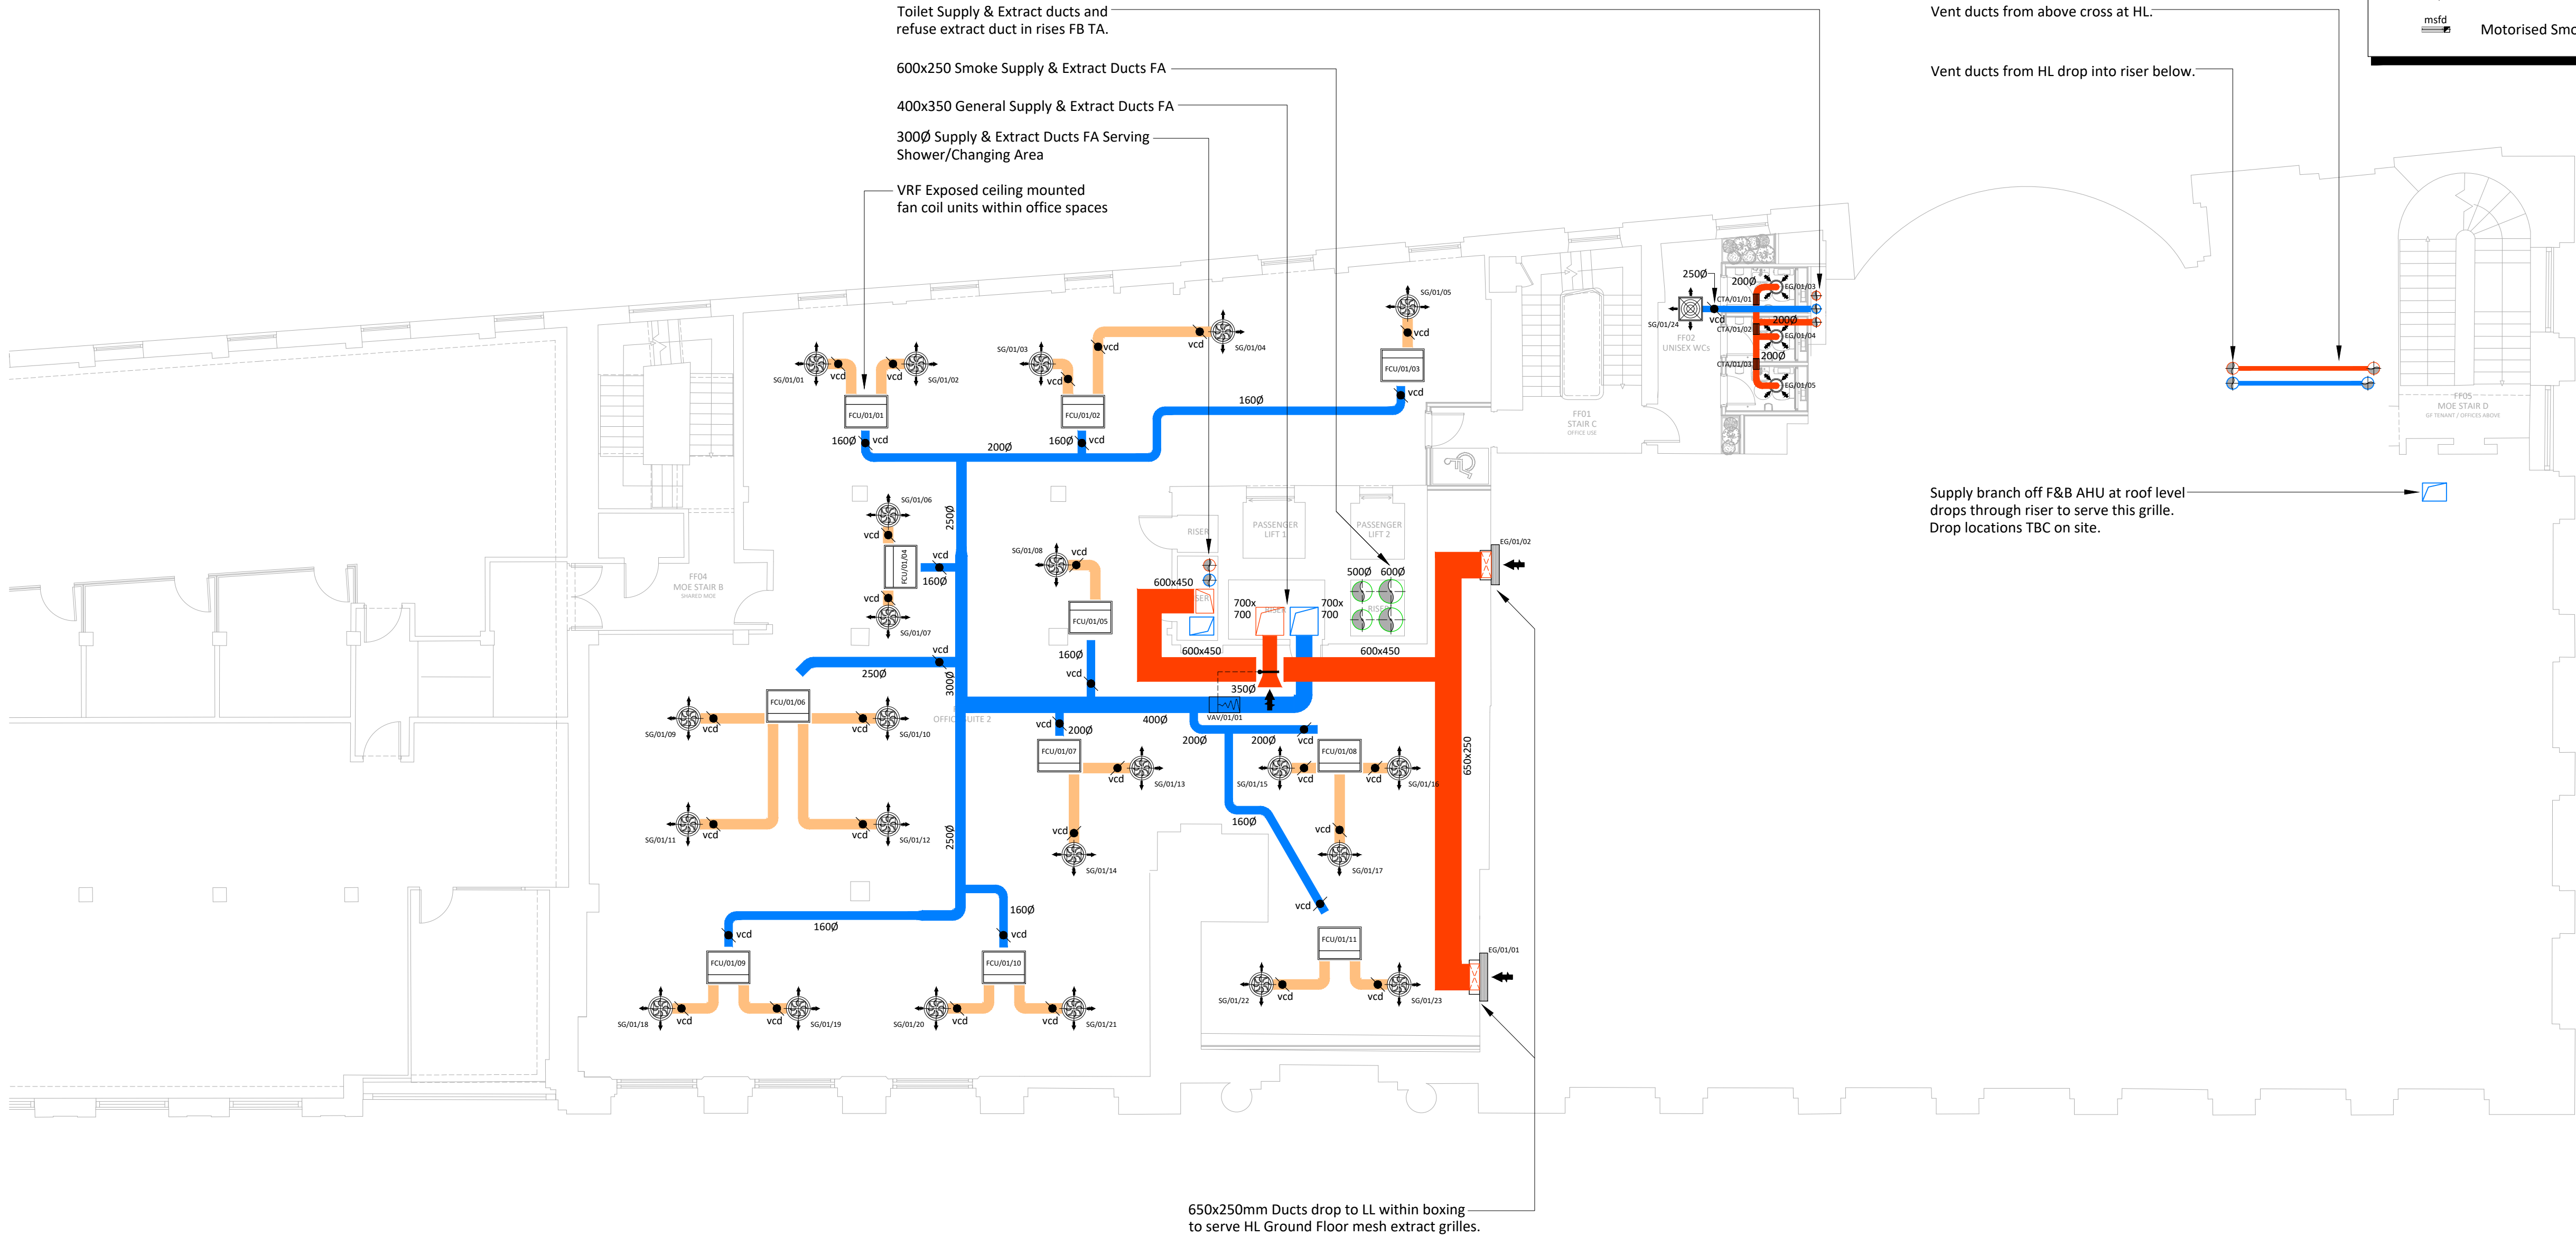

02	29/04/22	Stage 4 Tender Issue.	MR	SH
01	31/03/22	Stage 3 Issue.	RG	SH
Revision	Date	Description	Drawn	Checked

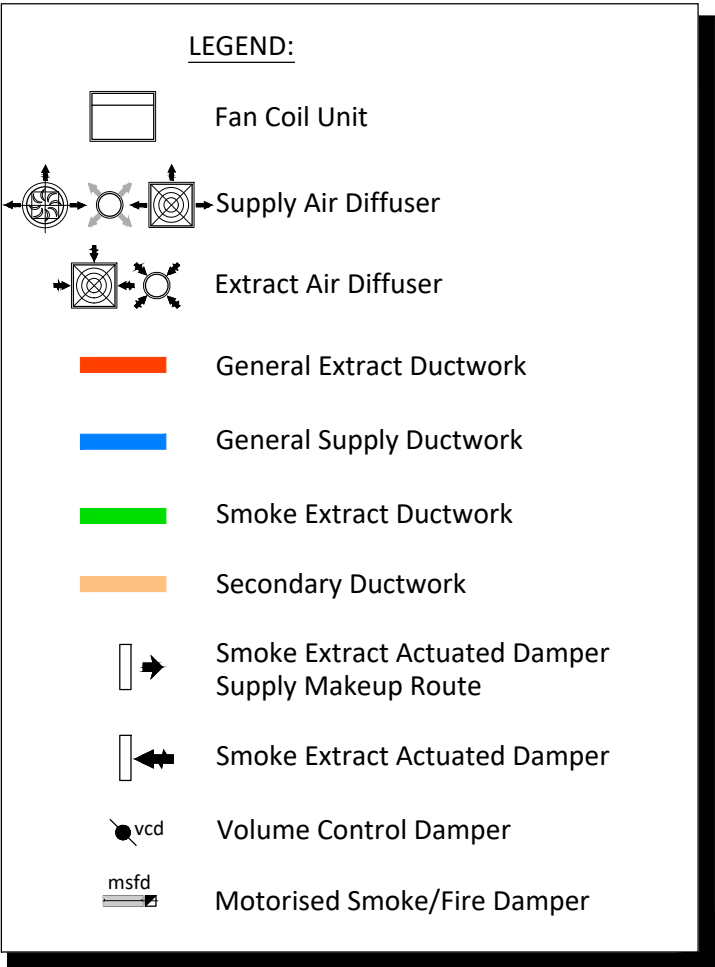

hilsonmoran.com info@hilsonmoran.com

Client
Bruntwood

Project
**38-42 Mosley Street
Grade 2* Listed Building Refurbishment**

Drawing Title
**Mechanical Services
First Floor
Ventilation Layout**

Scale 1:100	Sheet Size A1	Checked SH	Approved SR
Status RIBA STAGE 4 TENDER ISSUE	HM Project No. 27618		
Drawing No. 27618-HM-ZZ-01-DR-MS-2202	Rev 02		