


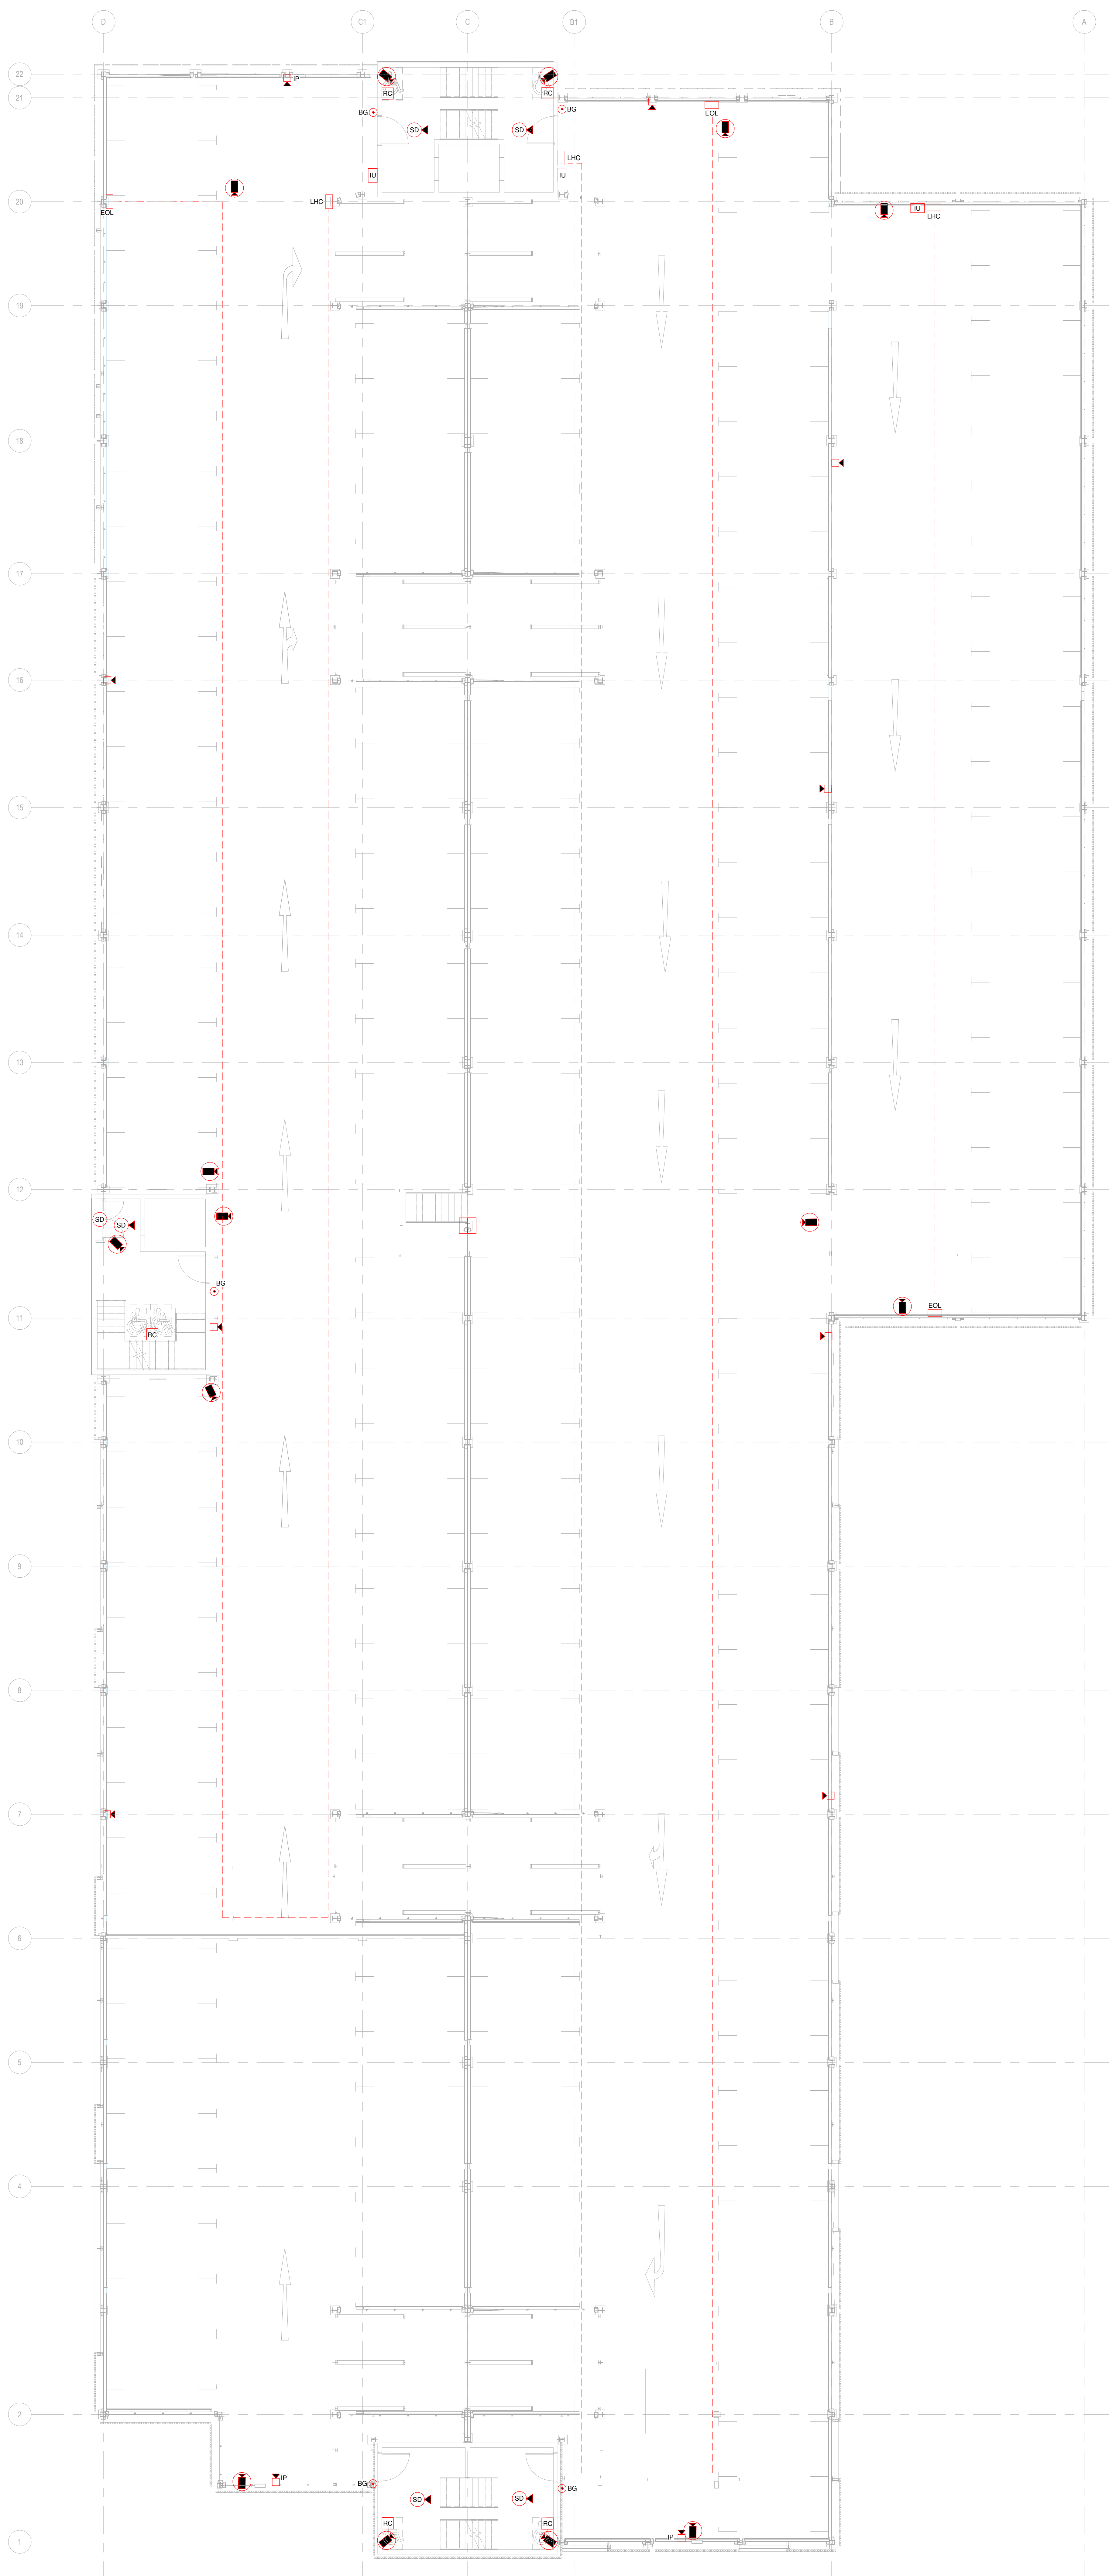

© DRAWINGS & THE COPYRIGHT OF © JCBM THIS DOCUMENT IS UNCLASSIFIED AND NOT CONTROLLED BY THE NATIONAL ARCHIVES. UNCLASSIFIED EXEMPTION CODE: 25X. ALL INFORMATION ARE UNCLASSIFIED EXCEPT WHERE SHOWN OTHERWISE. FOR MORE INFORMATION ON THIS DOCUMENT CONTACT THE NATIONAL ARCHIVES AT 866-963-6422	
NOTES - #7 FIRE ALARM & SECURITY NOTES	
1.	ALL SUPPORT SYSTEMS & BRACKETRY SHALL BE DESIGNED & CO-ORDINATED WITH THE BUILDING FABRIC & MECHANICAL SERVICES BY THE ELECTRICAL CONTRACTOR.
2.	SIGNAL CABLES SHALL BE USED FOR ALL POWER CABLES WHEN CLIPPED TO LADDER OR TRAY.
3.	THE ELECTRICAL CONTRACTOR SHALL BE RESPONSIBLE TO ENSURE THAT THE FIRE ALARM INTERFACE UNIT FULLY COMPLIES WITH EN50131.
4.	THE ELECTRICAL CONTRACTOR SHALL BE RESPONSIBLE TO ENSURE THAT THE DOOR ENTRY ACCESS SYSTEM FULLY COMPLIES WITH BS6868.
FIRE ALARM & SECURITY LEGEND	
	SMOKE DETECTOR WITH SOUNDER BASE
	SMOKE DETECTOR
	HEAT DETECTOR WITH SOUNDER BASE
	HEAT DETECTOR
	BREAK GLASS UNIT
	BREK GLASS UNIT (IP65 RATED)
	DOOR ENTRY SYSTEM - EMERGENCY PUSH TO LOCK DOWN
	DOOR ACCESS SYSTEM - GREEN MUSHROOM HEADED PUSH TO EXIT BUTTON
	WALL MOUNTED FIRE ALARM SYSTEM
	WALL MOUNTED FIRE ALARM SYSTEM (IP65 RATED)
	FIRE ALARM INTERFACE UNIT FOR DOOR ACCESS
	FIRE ALARM INTERFACE UNIT FOR LIFT
	FIRE ALARM INTERFACE UNIT FOR MECHANICAL PANEL
	FIRE ALARM INTERFACE UNIT FOR FIRE ALARM ASPIRATOR
	FIRE ALARM INTERFACE UNIT FOR LINEAR HEAT CONTROLLER
	DISABLED REFUGE PANEL
	FIRE ALARM PANEL
	LINEAR HEAT CONTROLLER
	LINEAR HEAT END OF LINE
	INTRUDER ALARM PANEL
	ACCESS CONTROL PANEL (FINAL LOCATION TBD)
	DISABLED REFUGEE INTERCOM UNIT
	DOOR ACCESS SYSTEM / DOOR HOLD MAG LOCK UNIT
	SECURITY INTRUDER ALARM CONCEALED DOOR CONTACT
	DOOR ACCESS SYSTEM - WALL MOUNTED FOR READER
	CCTV CAMERA
	EMERGENCY HELP POINT
	LINEAR HEAT TATE

P01	CONSTRUCTION ISSUE	OK	KH
P02	STAGE 4 - FOR STAKEHOLDER PRESENTATION	19/05/21	RB
P03	PRELIMINARY ISSUE	16/06/21	RB
		16/06/21	RB
		20/05/21	RB
Doc	Amendment	20/05/21	RB
		20/05/21	RB
		20/05/21	RB

H E Simm

ENGINEERING EXCELLENCE

HEAD OFFICE
 Suresh S & G Spennaker House
 1-11 Salford Street
 Liverpool L1 5SN

TEL: 0151 707 3222
Email: info@hesim.co.uk
hesim.co.uk

Project Name:
THE CHRISTIE TIERED CAR PARK

Sheet Title:
LEVEL 04 & 03
PROPOSED FIRE ALARM & SECURITY INSTALLATION

Scale (© AD): **Drawn:** **RIBA Stage:**
 1:100 **OK** **5**

B51192 Document Number:
TCF-HES-XS-ZZ-DR-E-670003

Status:
A5
Revision:
C01