




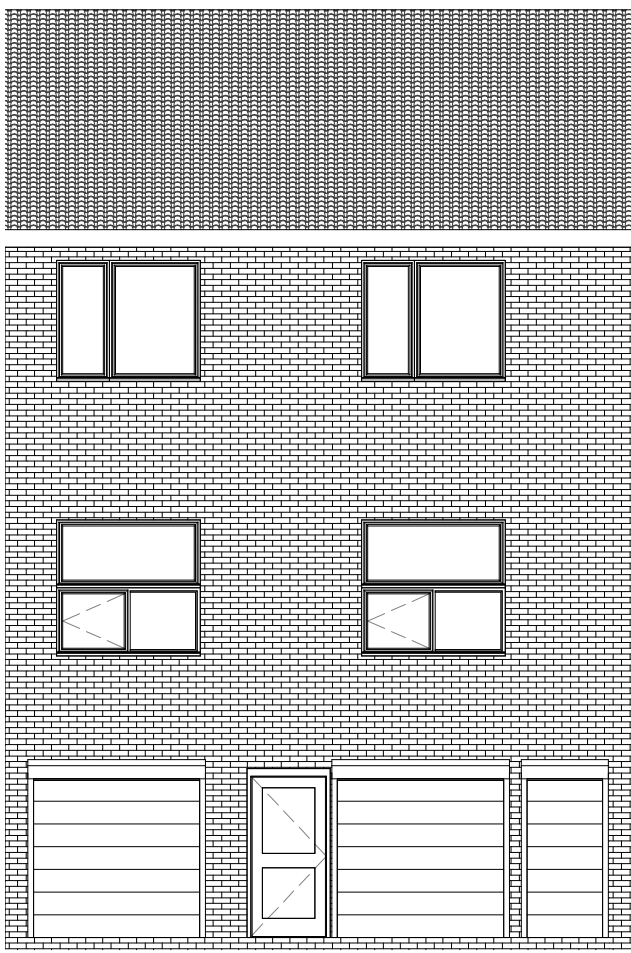


Proposed Front
1 : 100

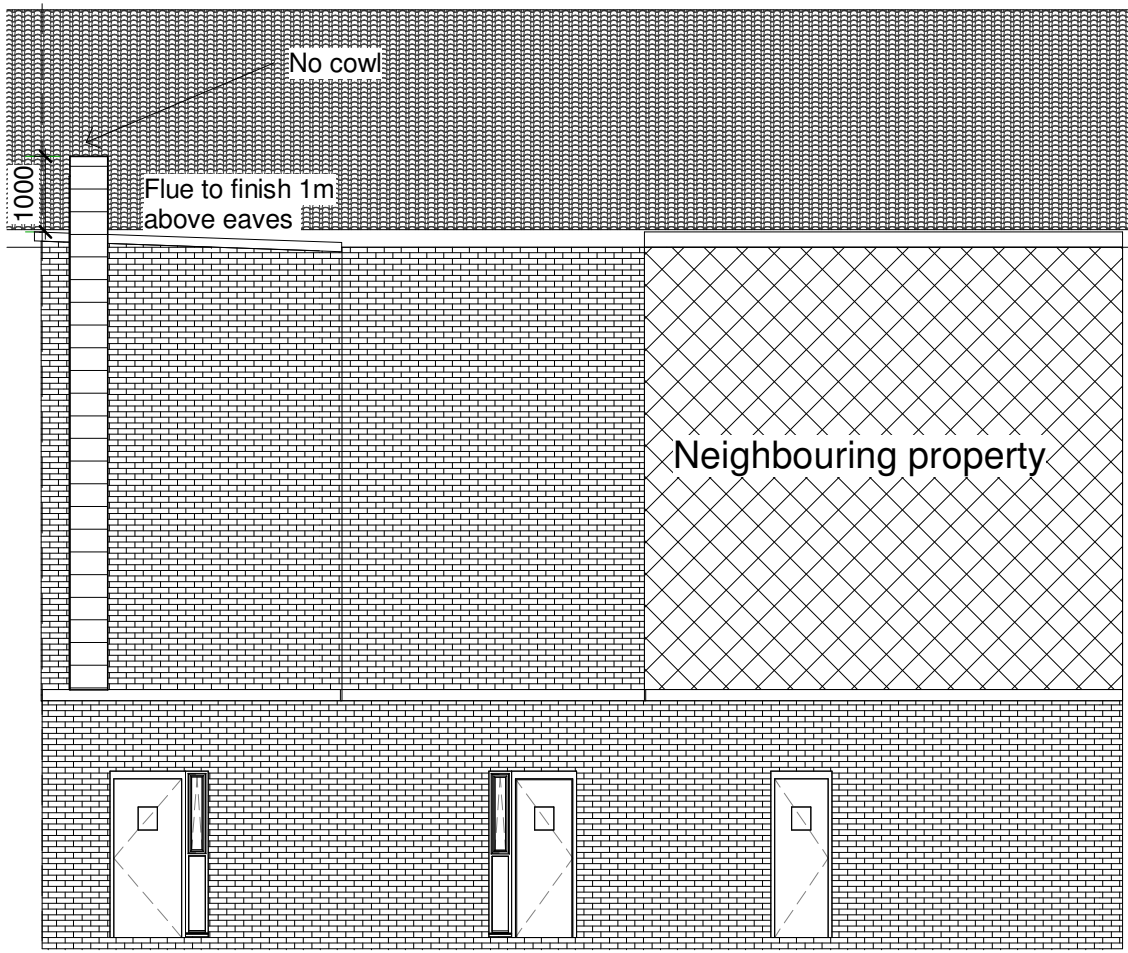

Proposed Rear
1 : 100

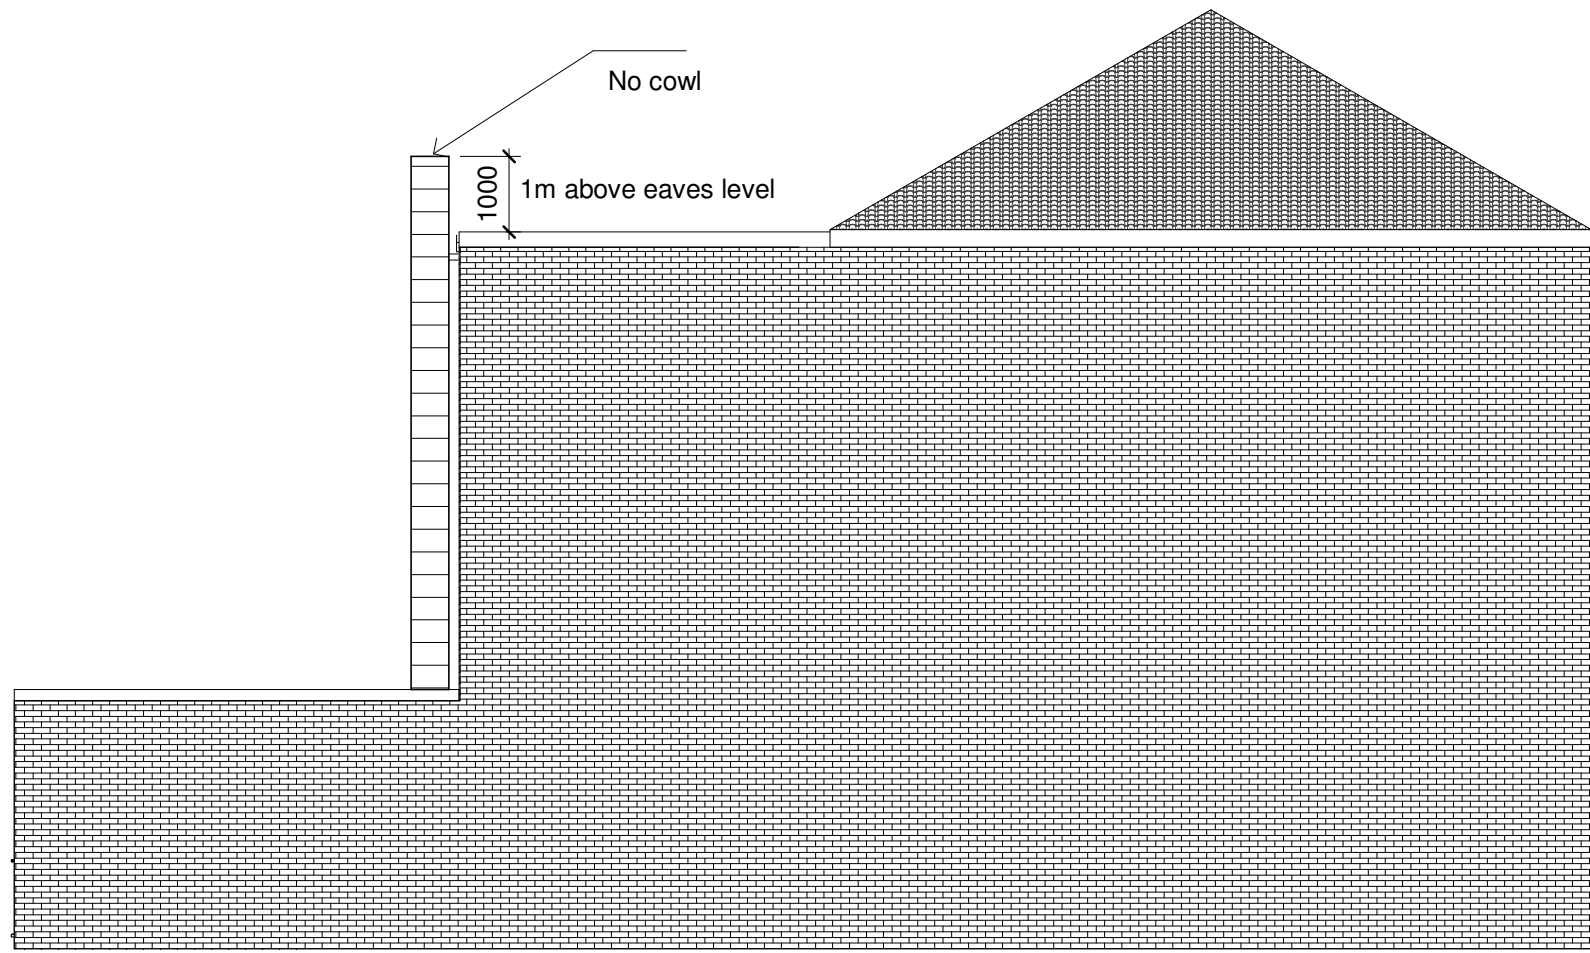


Proposed Side
1 : 100

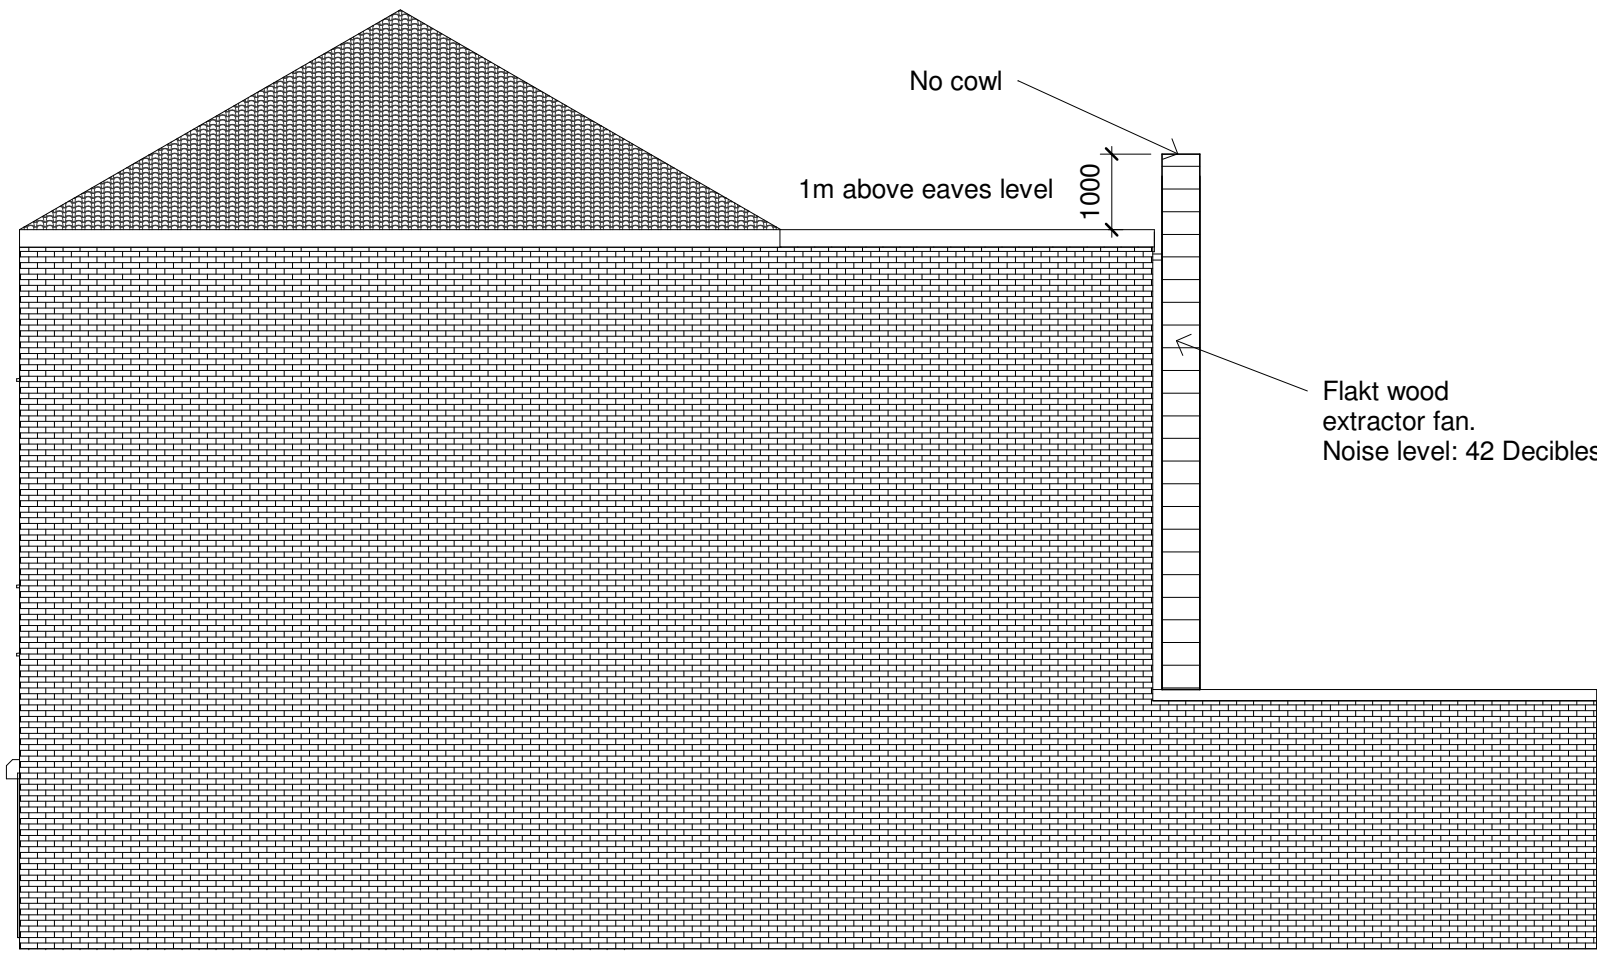

Proposed Side (2)
1 : 100


Scale: @ A1.
Do NOT scale from this drawing.
If in doubt, ask.
Dimensions must be checked by contractor before work is commenced.

This drawing remains the property of Belal Rashid Technical Architecture and should not be reproduced in full or in part without prior consent from Belal Rashid Technical Architecture.

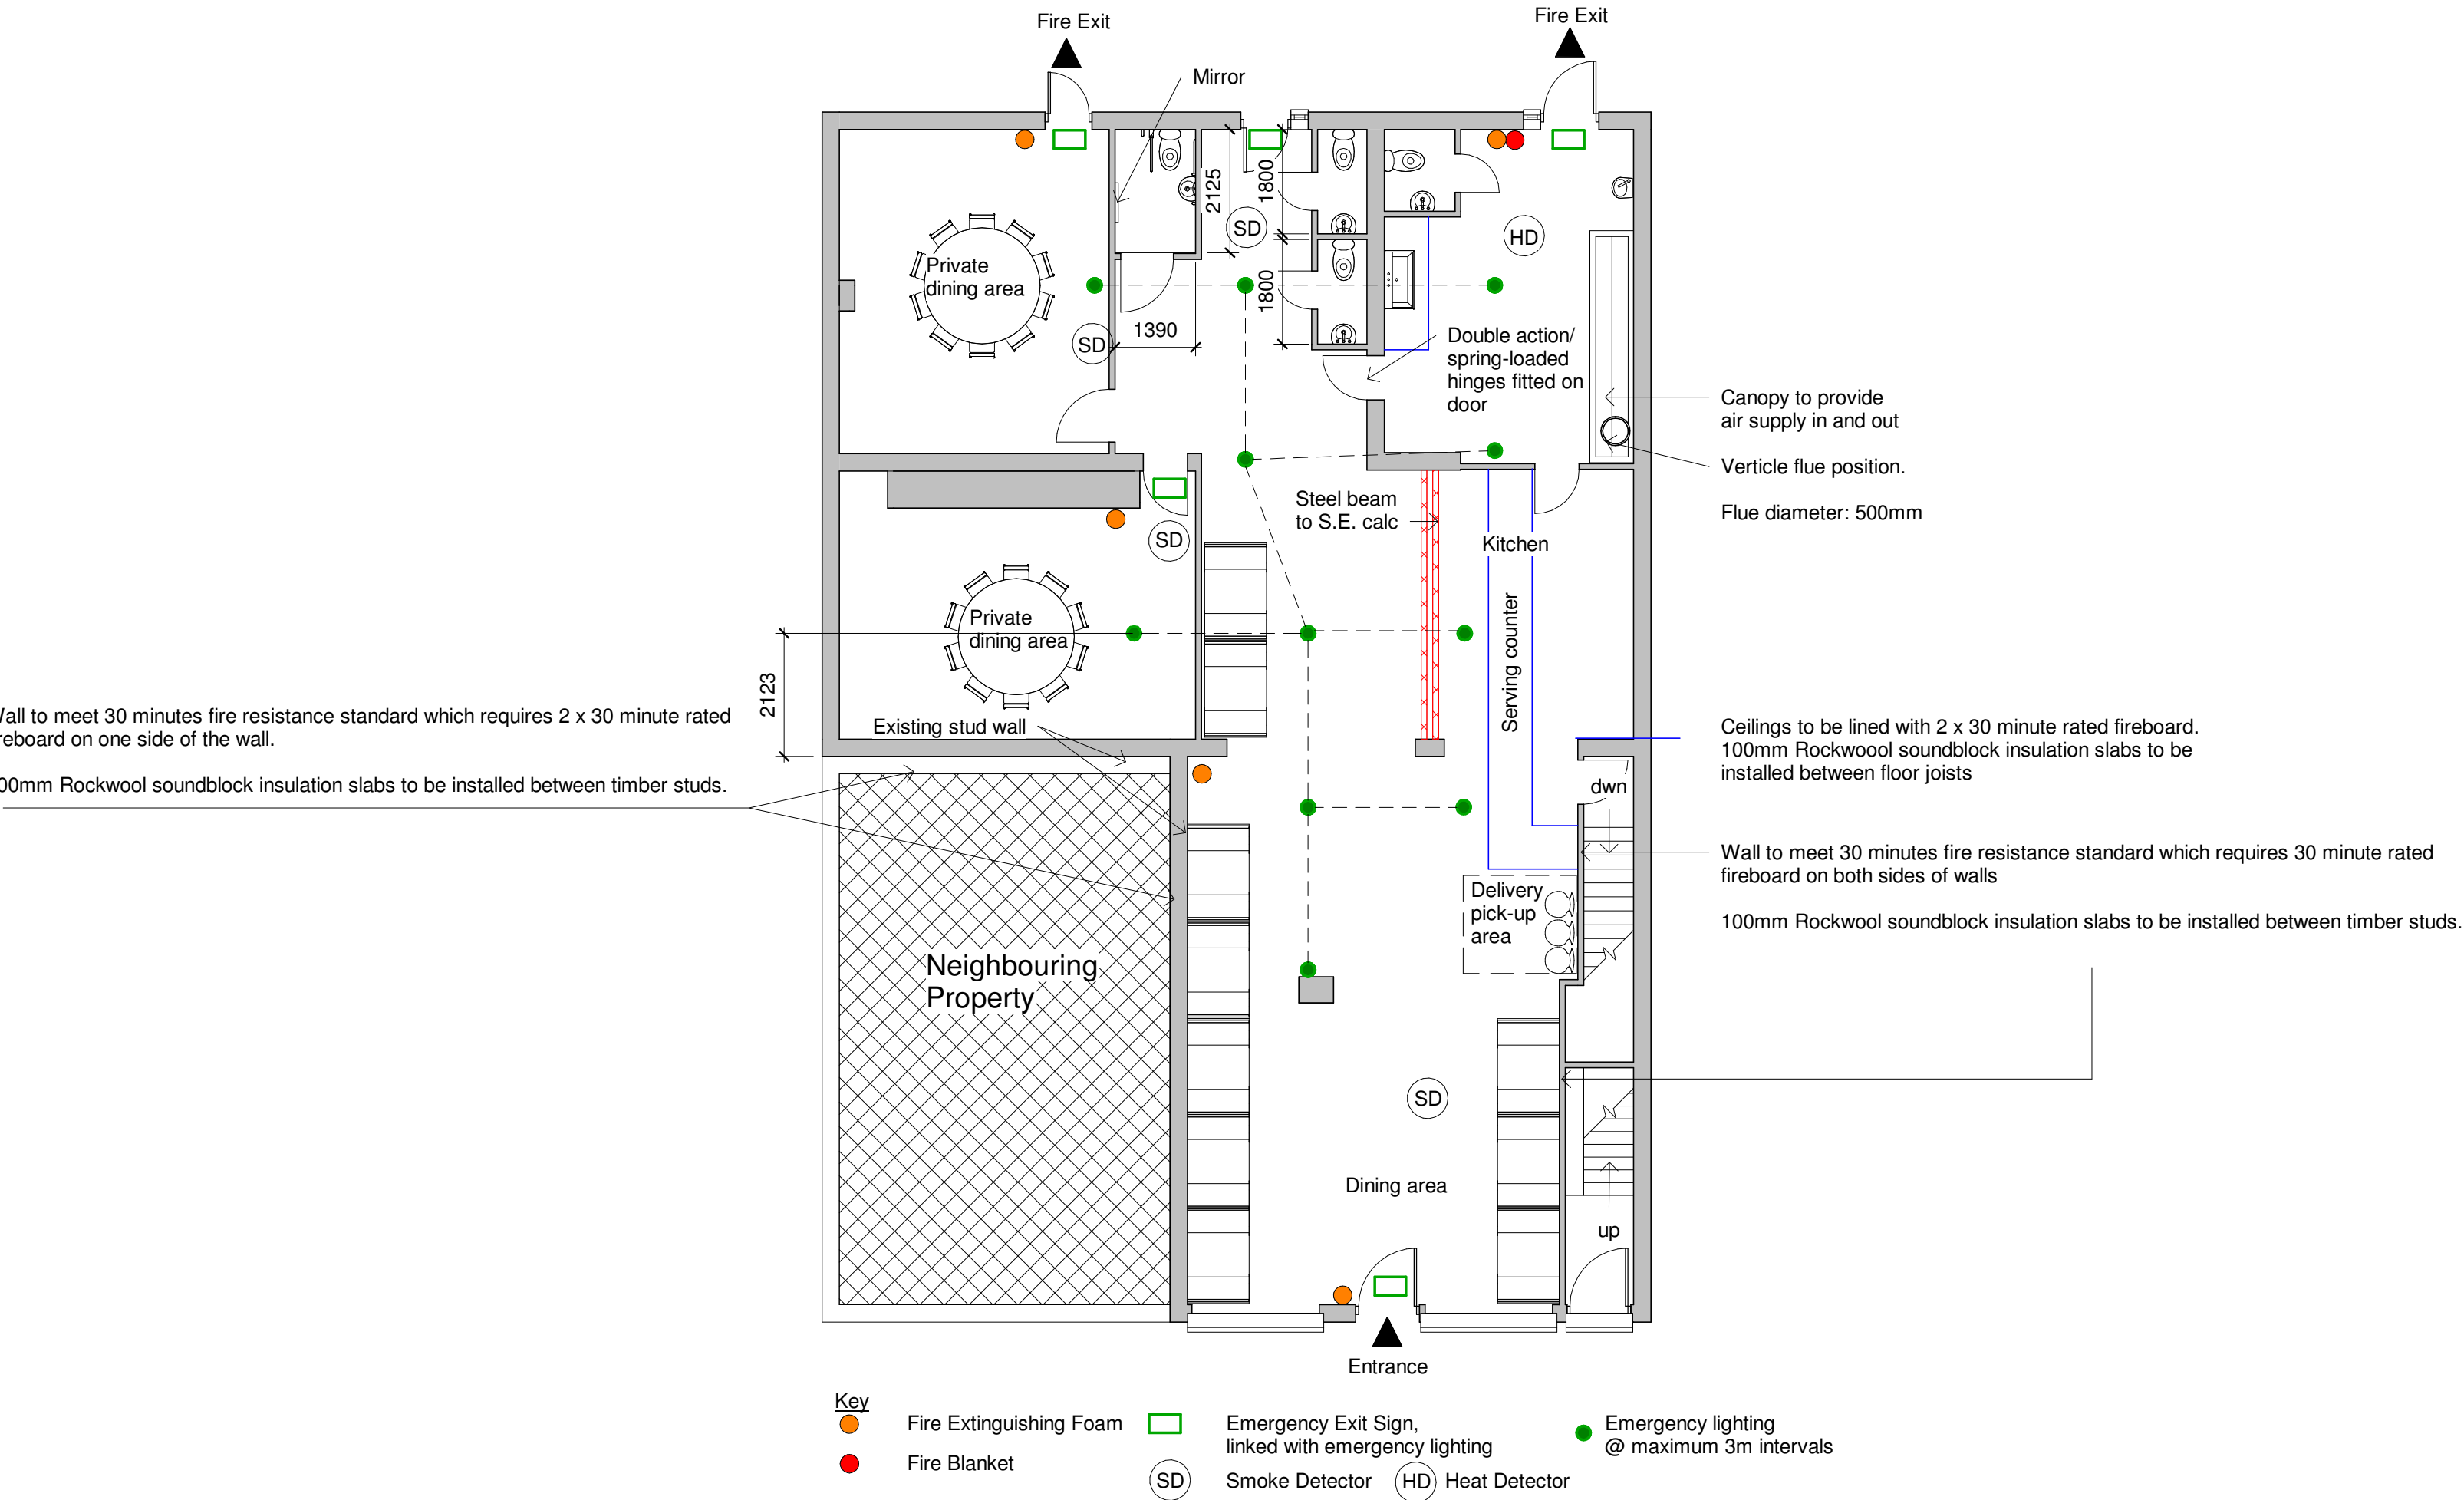

- Notes**
- Sink to be fitted with grease trap.
 - Canopy: Removable baffle grease filters to be used.
 - 500mm x 500mm ducting, with axial fan.
 - Flakt wood extractor fan x 2 fitted with slincer x 2.
 - Carbon box filter, 0.3 to 0.4 second resistance time.
 - Gas pipework size to be determined by a Gas Safe engineer. Gas supply to be fitted with an interlock system.
 - Heat and smoke detectors interlinked.
 - Vibration mounts inside and out.

Proposed Ground Floor
1 : 100

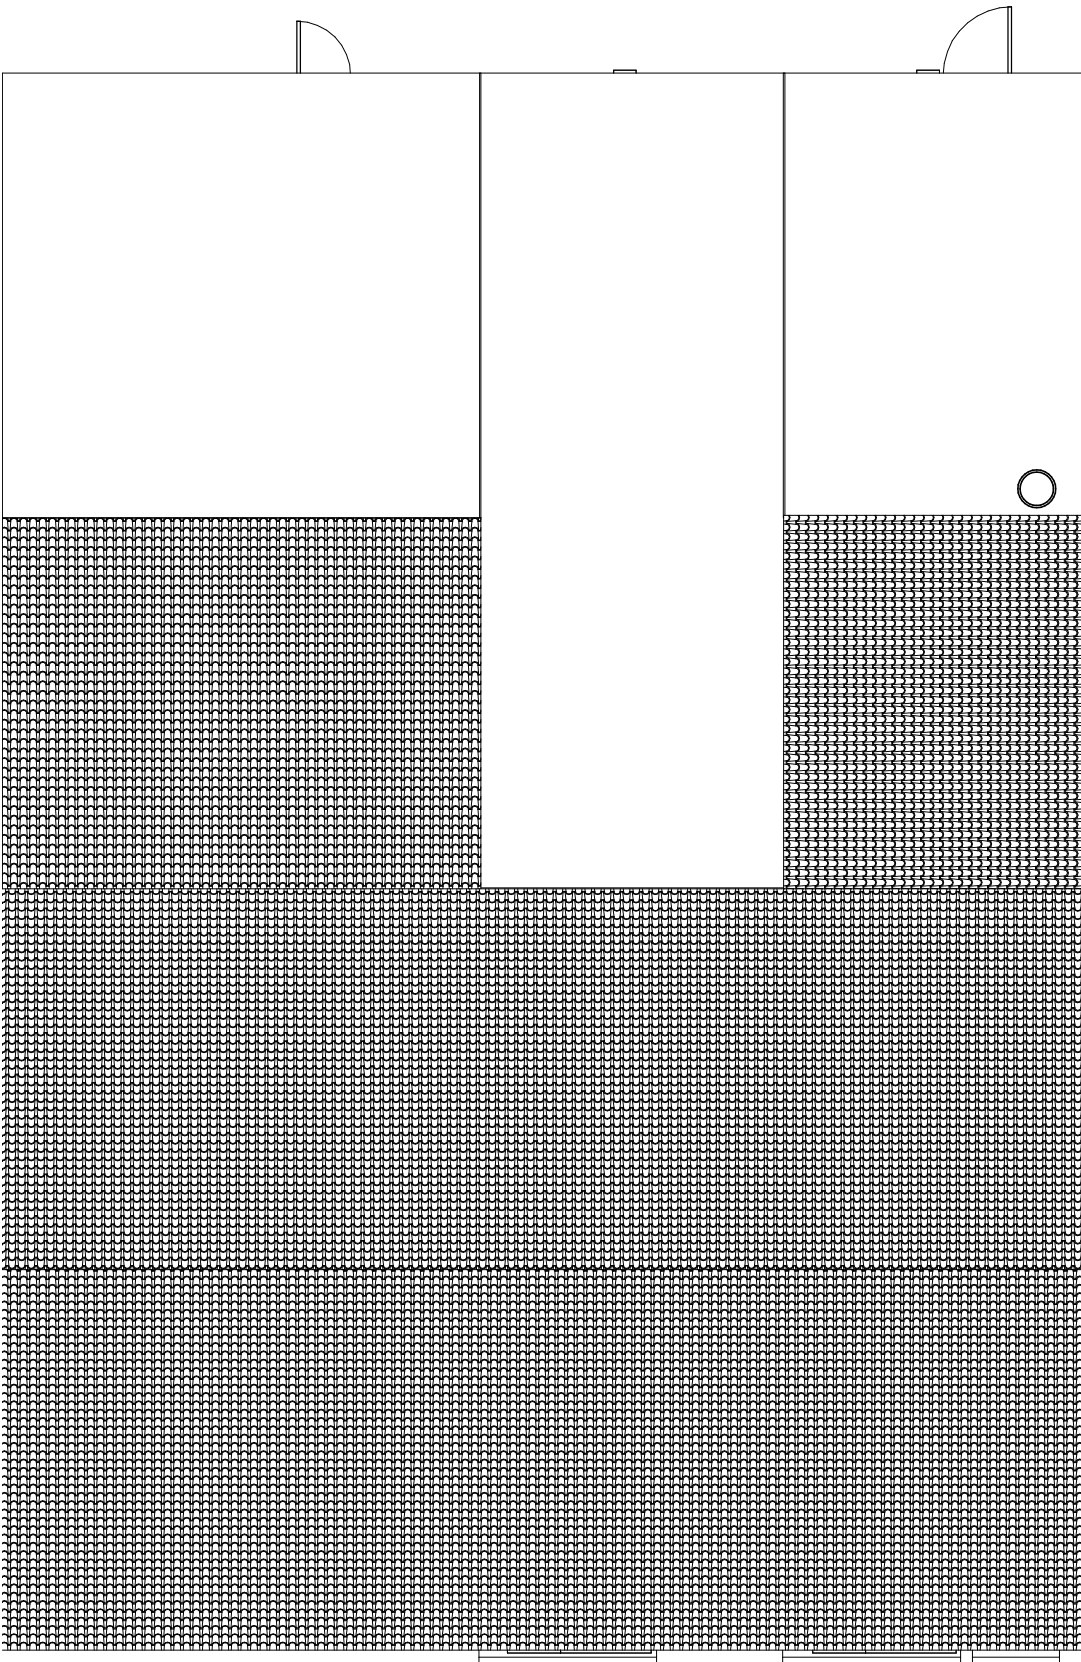

Proposed Roof Plan
1 : 100

Client:
Arslan Younis

Project:
Project Name
Project Address:
460 Cheetham Hill Road
Manchester M8 9JW

Drawing Name: Proposed
Drawing Number: A102
Drawing Date: 03/12/21
Author: N.Shah, B.Rashid

Belal Rashid Technical Architecture
Office 12
Falcon Business Centre
Victoria Street
Oldham
OL9 OHB

Email: belal.brta@outlook.com
Mobile: 07794529361

