


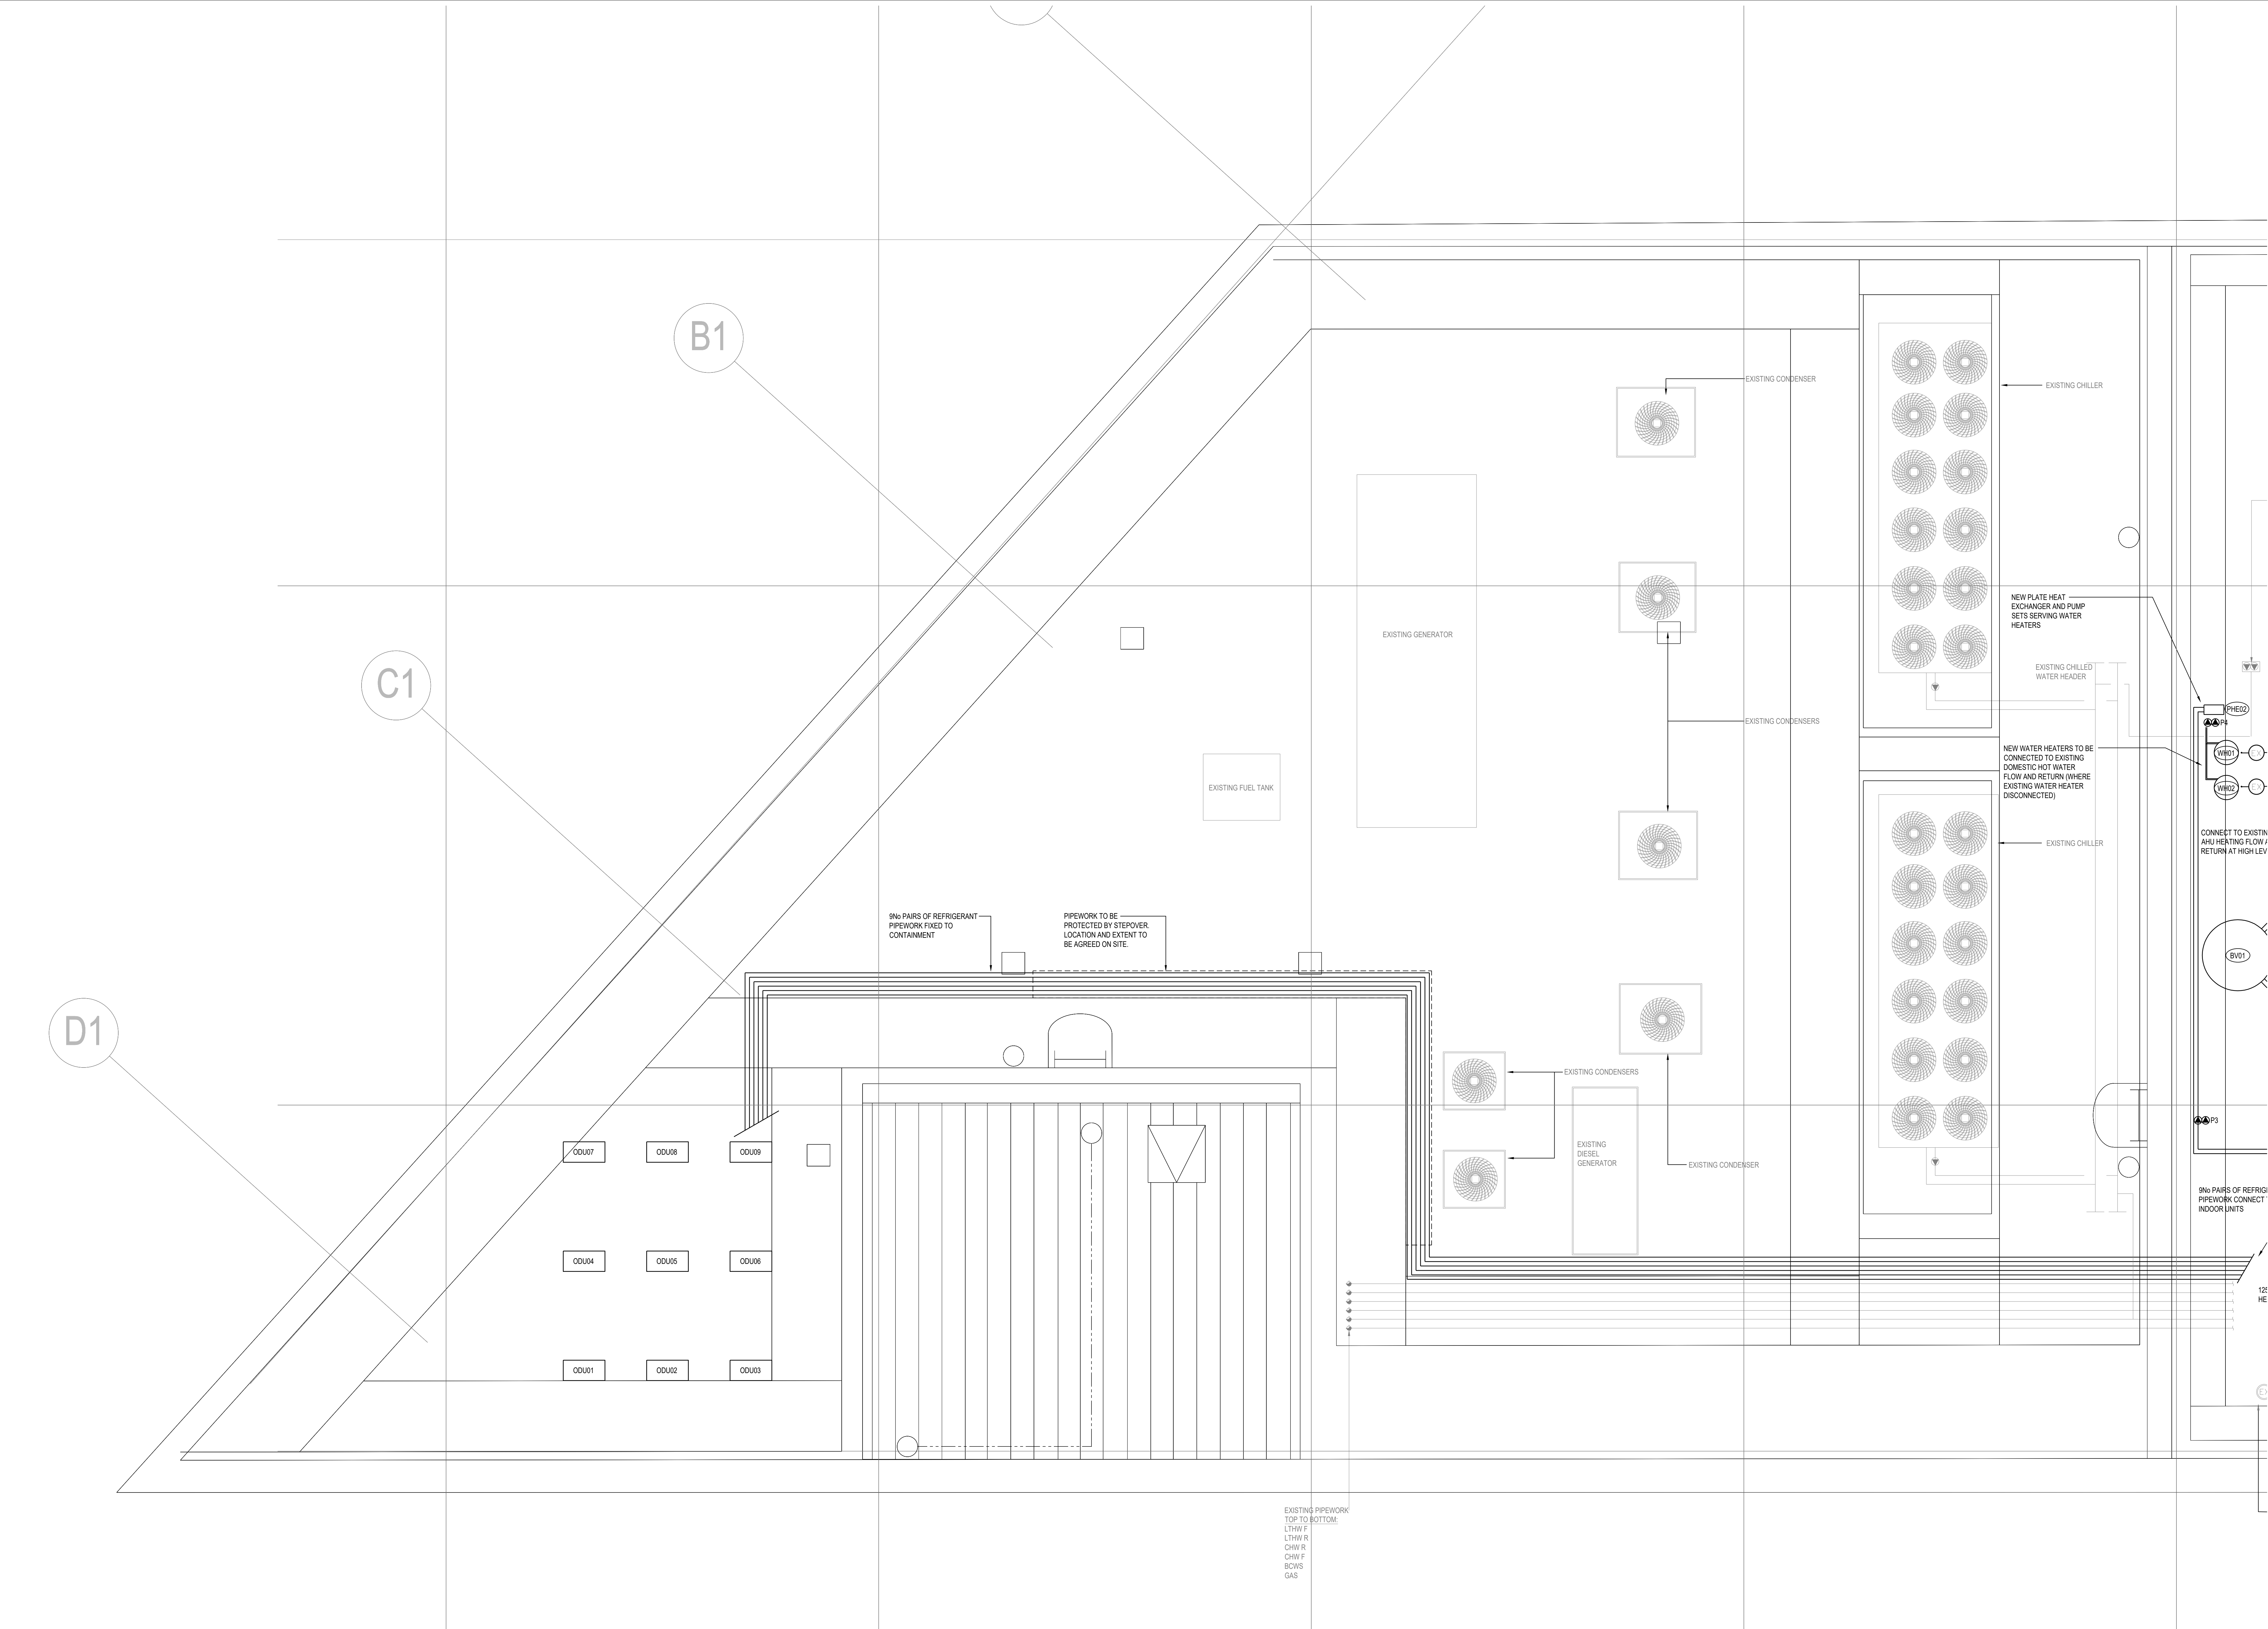

- NOTES
1. ALL SERVICE ROUTES DETAILED ARE APPROXIMATE. THE CONTRACTOR SHALL BE RESPONSIBLE FOR DETERMINING THE EXACT ROUTES AND POSITIONS OF ALL INSTALLED SERVICES AND EQUIPMENT.
 2. THE EXACT POSITION OF ALL SERVICES AND EQUIPMENT SHALL BE AGREED BY THE CONTRACT ADMINISTRATOR.
 3. THE CONTRACTOR SHALL BE RESPONSIBLE FOR FULLY COORDINATING ANY SERVICES INSTALLED WITH THE BUILDING FABRIC AND SERVICES INSTALLED BY OTHERS.
 4. THIS DRAWING SHALL BE READ IN CONJUNCTION WITH ALL MECHANICAL, ELECTRICAL, ARCHITECTURAL AND STRUCTURAL DRAWINGS, CONTRACT DOCUMENTATION AND SPECIFICATION FOR THE WORKS.
 5. THIS DRAWING FORMS PART OF THE SPECIFICATION FOR THE WORKS.
 6. ALL DIMENSIONS SHOWN ARE IN MILLIMETRES.
 7. DO NOT SCALE FROM THIS DRAWING.
 8. EXISTING SERVICES SHOWN FANT.

- LEGEND
- XXXXXX EXISTING EQUIPMENT TO BE STRIPPED OUT.
- ///// EXISTING EQUIPMENT TO BE RETAINED AND RELOCATED.

C	26-02-22	AMENDED FOR SAMBING PROPOSALS	
B	27-02-22	AMENDED FOR SAMBING PROPOSALS	
A	02-02-22	ISSUED FOR CONSTRUCTION	
PS	26-02-22	ISSUED FOR COMMENT	
PI	18-01-22	ISSUED FOR COMMENT	
REV	DATE	REVISION DESCRIPTION	
CLIENT			
JAMIESON CONTRACTING			
PROJECT			
TFGM DECARBONISATION PICCADILLY PLACE			
TITLE			
MECHANICAL SERVICES - PROPOSED ROOF PLANT LAYOUT DRAWING 1 OF 2			
 Parker Wilson Consulting			
■ Burnham House, 373 Bury New Road, Manchester, M25 1AW. T: 0161 773 1177 F: 0161 773 9977 manchester@parker-wilson.co.uk □ 2nd Floor, 72, Cannon Street, London EC4N 6AE T: 0207 251 4500 london@parker-wilson.co.uk www.parker-wilson.co.uk			
DRAWN BY	CHECKED	APPROVED BY	
JF	SV	PG	
SCALE	SIZE	DATE	
1:50	A0	JAN 2022	
DRAWING No	REV		
2PP1002-TGM-01-RF-DR-M-0001	C		

DRAWING ARE GENERALLY 1:100
BUT NOT SUITABLE FOR SCALING FROM.

CONSTRUCTION