

GENERAL NOTES

REMOTE DRIVER POSITIONS SHALL BE AGREED ONSITE WITH THE MAIN CONTRACTOR. THE AGREED LOCATIONS ARE TO BE OUT OF DIRECT VIEW BUT ACCESSIBLE FOR POTENTIAL MAINTENANCE REQUIREMENTS.

IF THE REMOTE DRIVER POSITIONS ARE TO BE LOCATED EXTERNALLY, THE MAIN CONTRACTOR SHALL ALLOW FOR THE APPROPRIATE LOCATION OUT OF DIRECT VIEW FROM GROUND AND FIRST FLOOR LEVEL.

CABLING TO THE LUMINAIRES SHALL BE INSTALLED NEATLY AND CONCEALED WHERE POSSIBLE, UTILISING LEDGE DETAILS ETC TO FIX THE CABLEING FROM DIRECT VIEW FROM GROUND AND FIRST FLOOR LEVEL.

ALL ELECTRICAL JUNCTION BOXES SHALL BE INSTALLED NEATLY AND CONCEALED FROM DIRECT VIEW WHERE POSSIBLE, UTILISING LEDGE DETAILS ETC TO FIX THE JUNCTION BOXES FROM DIRECT VIEW FROM GROUND AND FIRST FLOOR LEVEL. JUNCTION BOXES SHALL BE COLOUR MATCHED TO MATCH ADJOINING STRUCTURES.

FIXING DETAILS

FIXING OF ALL LIGHTING EQUIPMENT SHALL BE AGREED ONSITE WITH THE MAIN CONTRACTOR AND PROJECT ARCHITECT / CONSERVATION SPECIALIST.

FIXING DETAILS SHOULD HAVE MINIMAL IMPACT ON THE FABRIC OF BUILDING WHERE POSSIBLE, BUT SHALL ENSURE ALL LIGHTING EQUIPMENT IS PERMANENTLY FIXED AND SAFELY INSTALLED.

FINAL FIXING POSITIONS TO BE REVIEWED AND AGREED ONSITE WITH THE MAIN CONTRACTOR FOLLOWING THE LIGHTING MOCK UP REVIEW.

LIGHTING CONTROL

THE EXTERNAL LIGHTING SHALL BE CONTROLLED VIA THE SPECIFIED ARCHITECTURAL LIGHTING CONTROL SYSTEM, WITH AUTOMATIC SWITCH ONLY VIA AN EXTERNAL MOUNTED PHOTOCELL. PHOTOCELL LOCATION TO BE AGREED ONSITE WITH THE MAIN CONTRACTOR. TIMED SCENE TRANSITIONS SHALL BE PROGRAMMED THROUGH THE LIGHTING CONTROL SYSTEM, WITH AN AGREED AUTOMATIC SWITCH OFF TIME PROGRAMMED IN, MANUAL OVERRIDE OF THE EXTERNAL FACADE LIGHTING SHALL BE PROVIDED VIA THE MASTER SCENE SET CONTROLLER.

ALL EXTERNALLY MOUNTED LUMINAIRES SHALL HAVE DIMMING CONTROL, UNLESS STATED OTHERWISE ON THE LUMINAIRE SCHEDULE.

ARCHITECTURAL LIGHTING MOCK UP

WHERE FEASIBLE, ALL EXTERNAL LIGHTING ELEMENTS SHALL BE MOCKED UP / TESTED WITH THE PROPOSED LIGHTING EQUIPMENT PRIOR TO FINAL INSTALLATION. THE MAIN CONTRACTOR SHALL PROVIDE A VIEWING PLATFORM FOR THE CLIENT AND CONSERVATION SPECIALIST AND LIGHTING DESIGNER PRESENT TO ENSURE ALL PARTIES ARE HAPPY WITH THE PROPOSED EFFECTS.

THE MAIN CONTRACTOR SHALL PROVIDE POWER AND SAFE ACCESS FOR THE MOCK UP WITH THE ELECTRICAL CONTRACTOR UNDERTAKING THE TEMPORARY INSTALLATION WORKS FOR THE TESTS.

THE MOCK UP SHALL BE VIEWED DURING THE HOURS OF DARKNESS TO VIEW THE PROPOSED LIGHTING EFFECTS. THE MAIN CONTRACTOR / ELECTRICAL INSTALLER SHALL MAKE THE APPROPRIATE ALLOWANCES FOR UNDERTAKING THE MOCK UP WORKS AND EVENING (NIGHTTIME) LIGHT TESTS.

EXTERNAL SIGNAGE


SIGNAGE LIGHTING AND EXTERNALLY ILLUMINATED SIGNAGE TO BE CONFORMED



EXTERNAL FEATURE LIGHTING DESIGN INTENT - MAIN FACADE



EXTERNAL FEATURE LIGHTING DESIGN INTENT - MAIN ENTRANCE

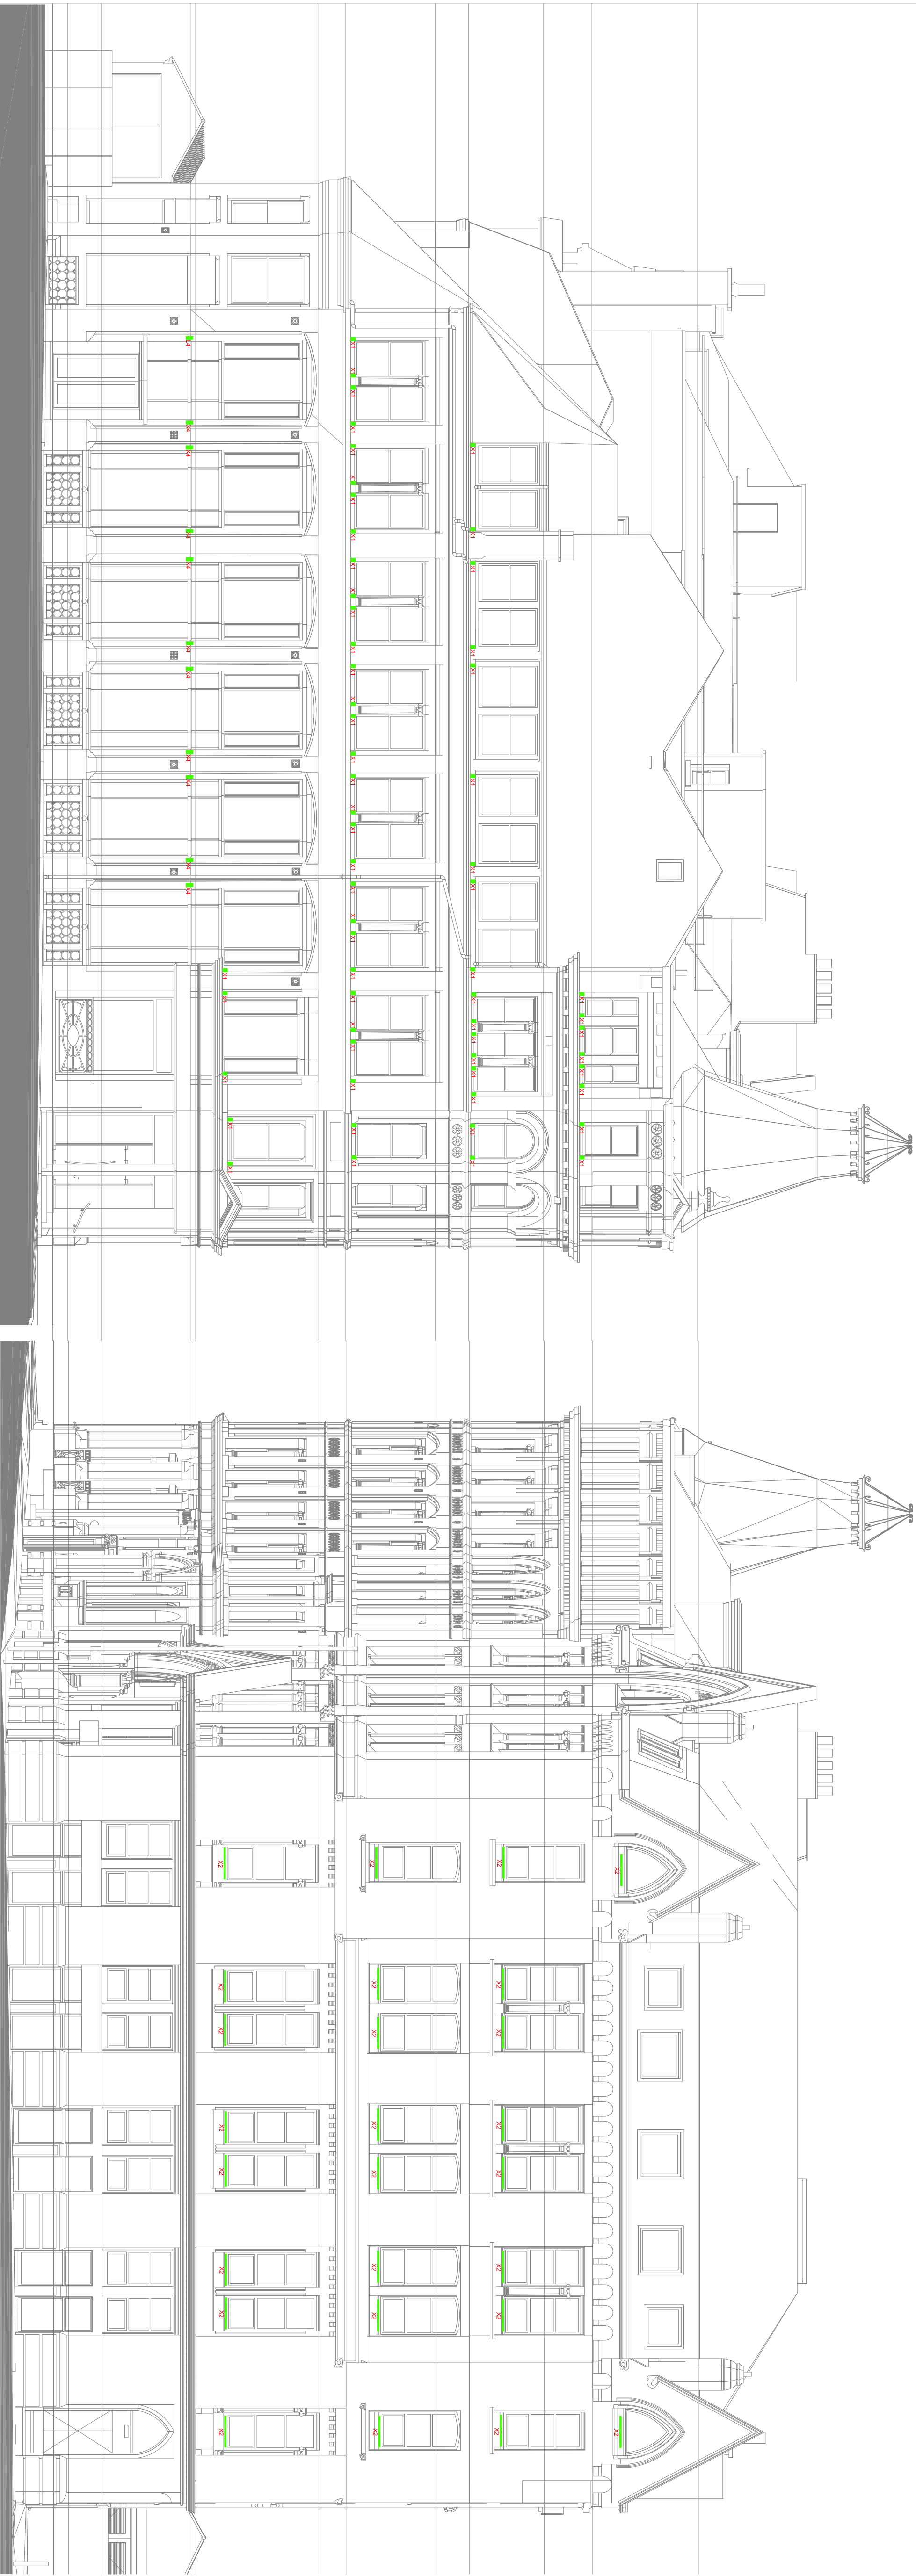

NOTES

1. DO NOT SCALE FROM THIS DRAWING
 2. ALL DIMENSIONS ARE STATED IN MILLIMETERS
 3. THIS DRAWING IS DESIGN INTENT ONLY, AND SHALL NOT BE USED FOR CONSTRUCTION PURPOSES
 4. THIS DRAWING SHALL BE READ IN COORDINATION WITH THE LUMINAIRE SCHEDULE
 5. LIGHTING SPECIFICATION DOCUMENT
 6. CONSTRUCTION DRAWINGS SHALL BE PROVIDED BY OTHERS
 7. COORDINATION OF THE M&E SERVICES ONSITE SHALL BE UNDERTAKEN BY THE MAIN CONTRACTOR
 8. THE MAIN CONTRACTOR SHALL ENSURE THE LIGHTING EQUIPMENT IS INSTALLED IN LINE WITH NATIONAL REGULATORY GUIDANCE
 9. THE MAIN CONTRACTOR SHALL UNDERTAKE A FEASIBILITY STUDY TO ASSESS THE PROPOSED FITTING LOCATIONS, LUMINAIRE SIZES, FIXING DETAILS AND CABLEING ROUTES. THE STUDY RESULTS AND RAISING ANY ISSUES THAT MIGHT ARISE FROM THE STUDY
 10. FINAL LUMINAIRE HEIGHTS FOR WALL MOUNTED FITTINGS AND PENDANTS FITTINGS SHALL BE AGREED BY THE ARCHITECT AND INTERIOR DESIGNER PRIOR TO INSTALLATION
- REMOTE LED DRIVERS
- THE MAIN CONTRACTOR SHALL ENSURE ALL REMOTE LED DRIVERS ARE CONCEALED FROM DIRECT VIEW IN ACCESSIBLE POSITIONS FOR MAINTENANCE PURPOSES.
- LINEAR LED LIGHTING
- LED POSITION WITHIN COFFERS TO BE AGREED ONSITE PRIOR TO FINAL INSTALLATION
- THE MAIN CONTRACTOR SHALL COVER FINAL LED LENGTHS FOR ALL LINEAR LED PRODUCTS WHICH SHALL COORDINATE WITH ARCHITECTURAL DETAILS AND JOINERY ELEMENTS

A	15/02/22	FOR COMMENT	LA
REV	DATE	FOR COMMENT	LA
DATE	ISSUE		

Project	KINGS HOUSE, MANCHESTER
---------	-------------------------

Client	BRUNTWOOD WORKS
--------	-----------------

Architect	EPR ARCHITECTS
-----------	----------------

Drawing	EAST AND WEST ELEVATION EXTERNAL LIGHTING LAYOUT
---------	--

Drawing No.	201869-00-03/002	Scale: 1:100 @ A1
-------------	------------------	-------------------