


This drawing and design are the property of Pye Design Ltd. and should not be reproduced without the consent in writing of Pye Design Ltd.

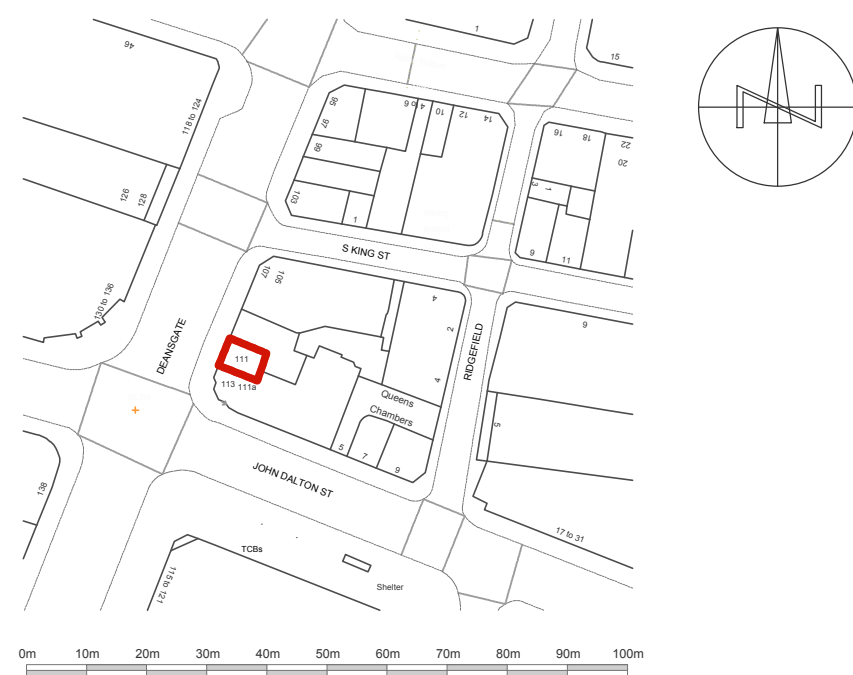

Location Plan

Scale 1:1250 @ A1 / 1:2500 @ A3



Site Plan

Scale 1:500 @ A1 / 1:1000 @ A3

[illegible]

**PYE
DESIGN
ARCHITECTS**

29 Market Street
Hindley
Wigan
WN2 3AE

RIBA Chartered Practice

www.PyeDesign.co.uk 01942 256007
info@PyeDesign.co.uk

LOCATION	111 Deansagte, Manchester. M3 2BQ
----------	---

PROJECT	DUNKIN' - Deansgate
---------	------------------------

CLIENT	SPQ Ltd
--------	---------

DRAWING TITLE

SITE & LOCATION PLAN

PURPOSE OF ISSUE
FOR APPROVAL

DRAWN BY RHS	CHECKED BY ARP	DATE JAN 2022
SCALE (at A1) AS INDICATED	PROJECT NUMBER 3991	
DRAWING NUMBER A111		REV