
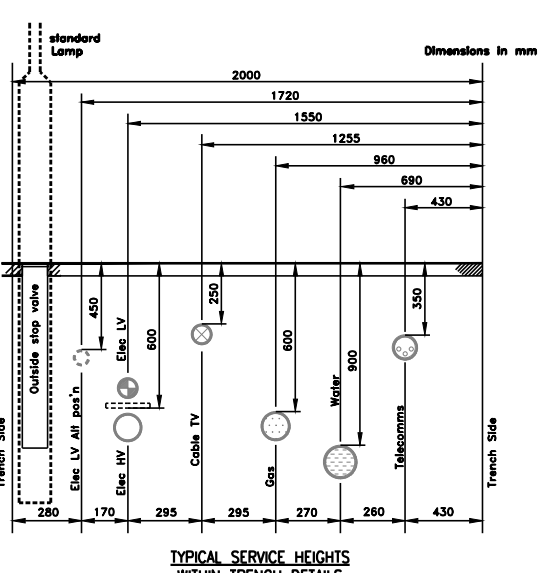


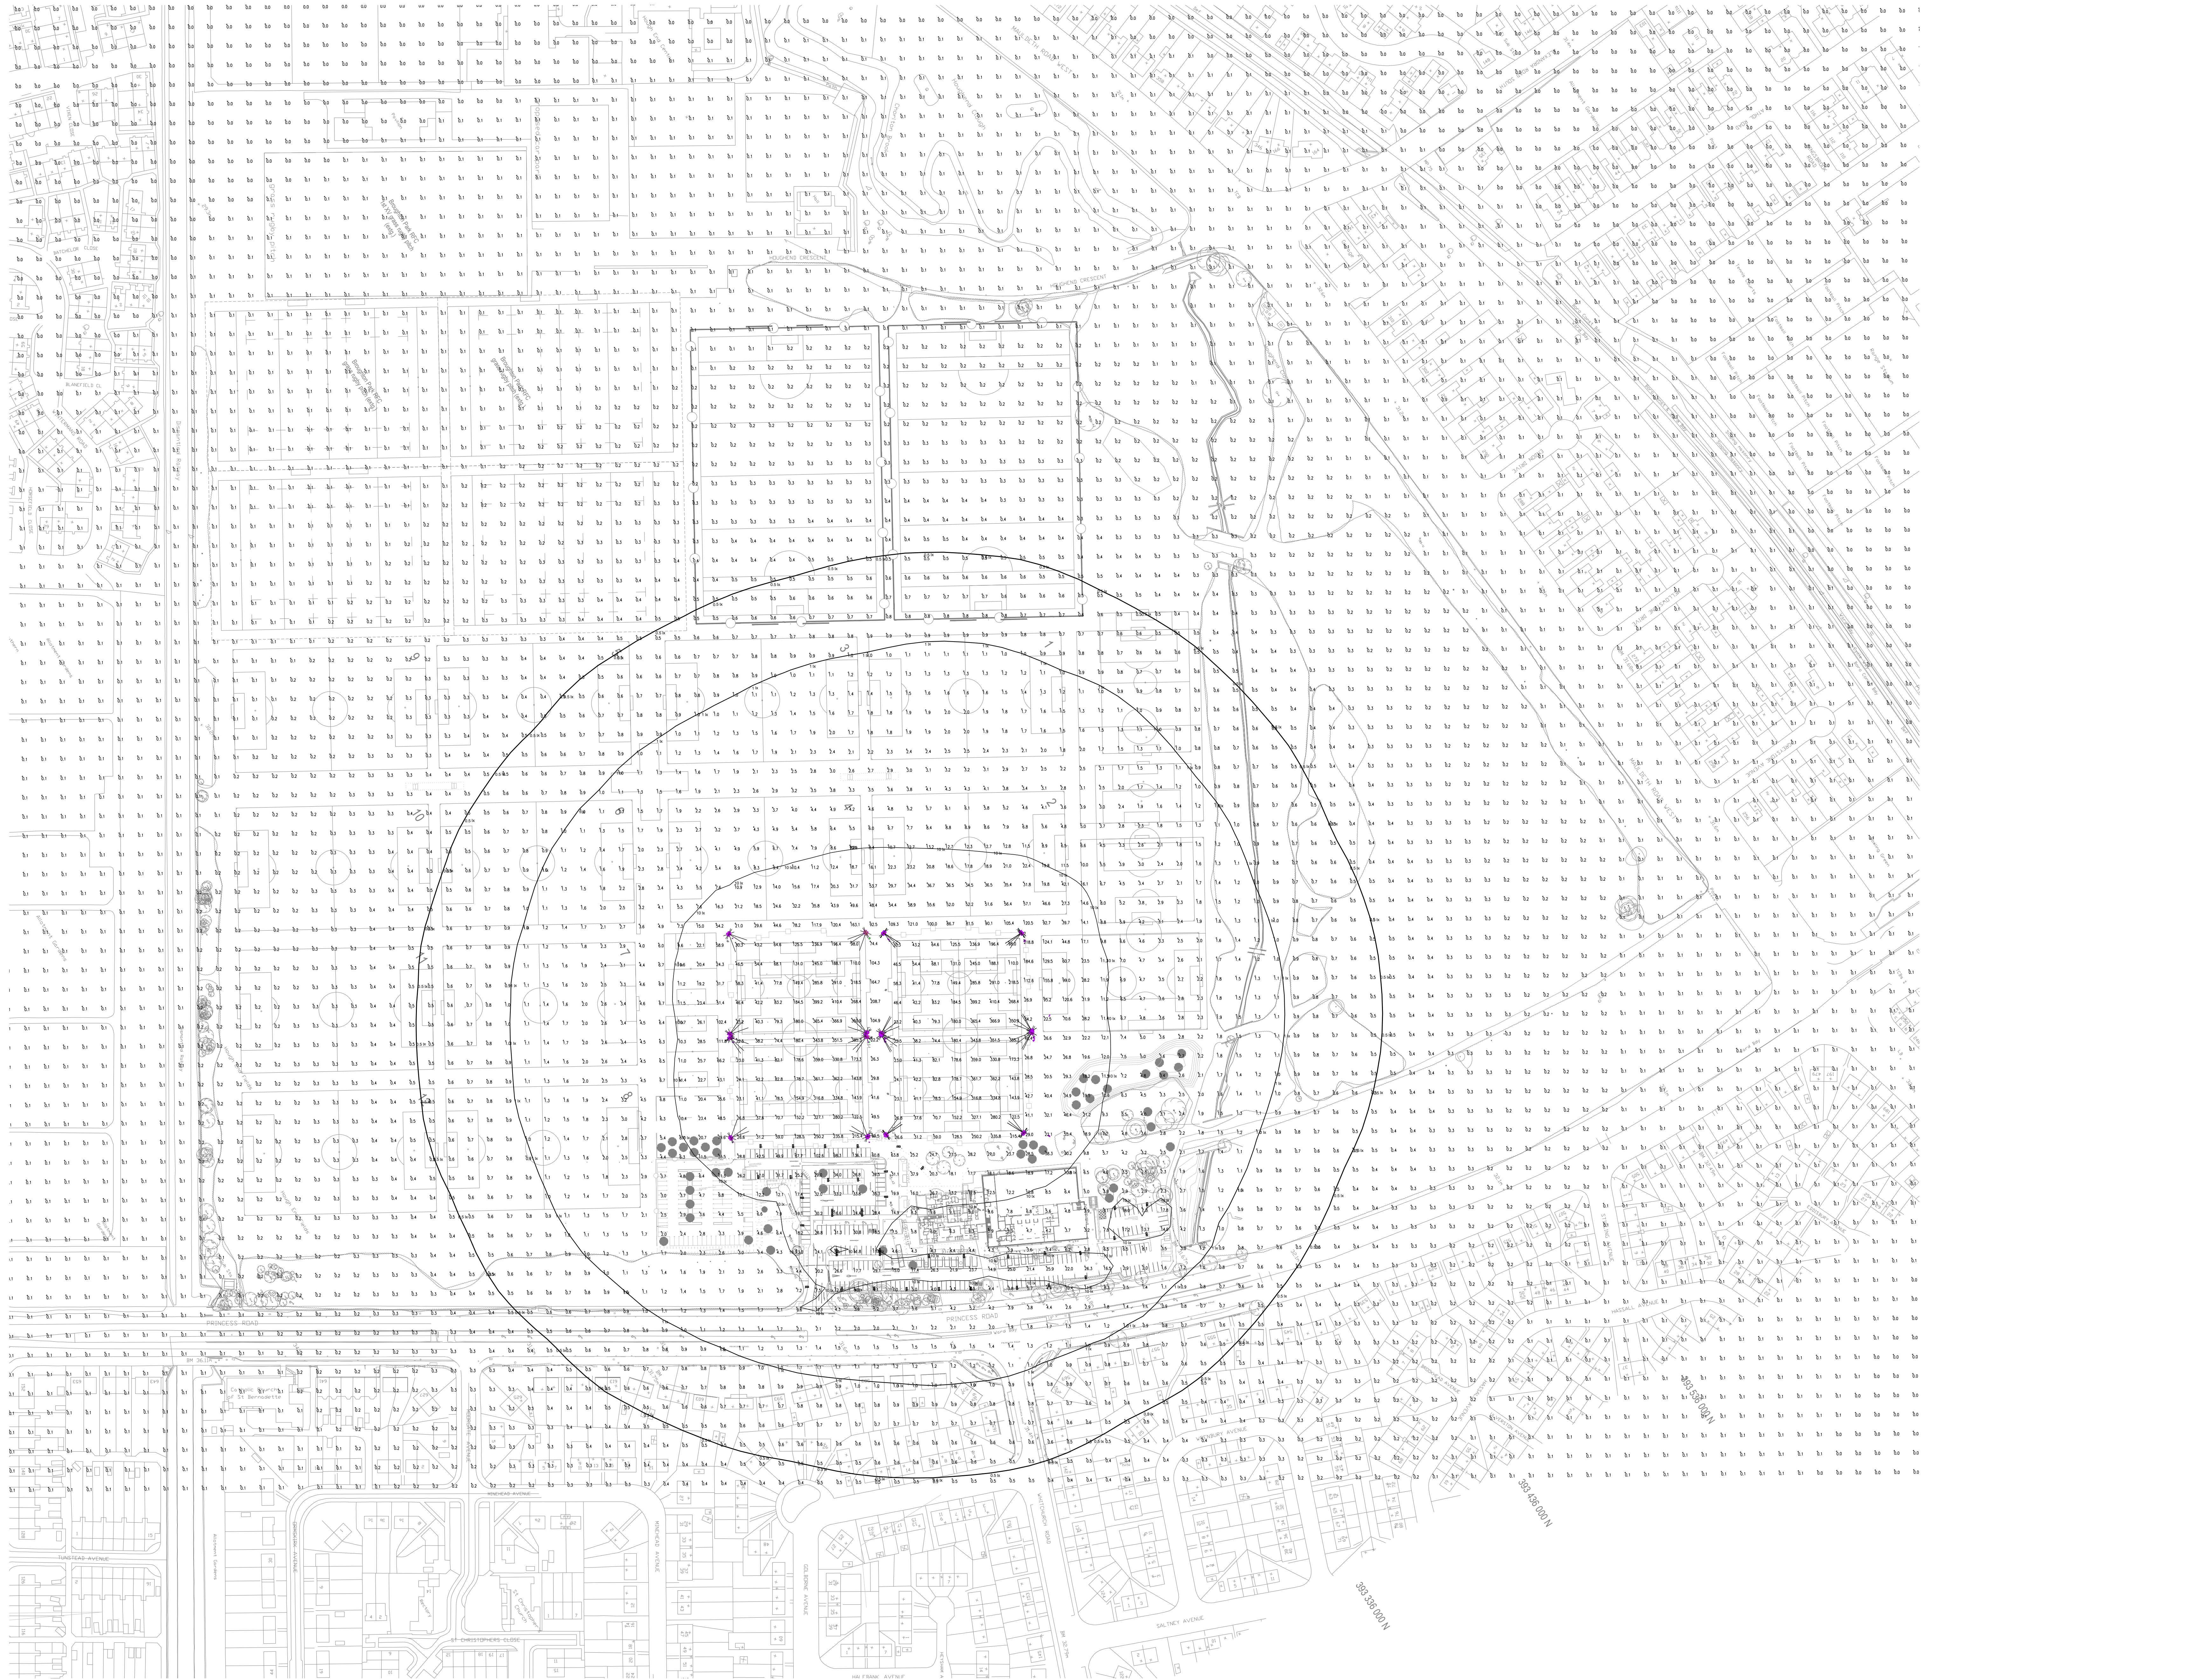

Luminaire Schedule					
Symbol	Qty	LF	Description	Lum. Wbts	UM/LF
40	1,000	IP 24.50-740 EWP	38	0.00	
8	1,000	CHAMPION 264120-740 V3 VSP	539	0.00	
48	1,000	CHAMPION 264120-740 V2 VSP	539	0.00	

Calculation Summary					
Level	CalcType	Units	Avg	Max	Min
Overall Ev	Humance	Lux	2.72	410.4	0.0
				0.00	0.00

This drawing is for engineering services only and is to be read in conjunction with all relevant architectural, structural, Waterman Building Services drawings and the contract specification.

This is NOT AN INSTALLATION DRAWING.

All service routes and equipment locations are indicative, actual location to be determined from site dimensions.

To whom it may concern: The requirements of the Health & Safety at Work etc. Act 1974 & subsequent amendments therein are brought to the attention of all those who design, install or maintain the plant and equipment shown on these drawings or who are required to enter the areas shown on these drawings.

DO NOT SCALE FROM THIS DRAWING

GENERAL NOTES

1. ALL OTHER DISCREPANCIES' SPECIFICATIONS SHALL BE READ IN CONJUNCTION WITH THE WATERMAN BUILDING SERVICES SPECIFICATION AND DRAWINGS AS WELL AS ARCHITECTS, STRUCTURAL ENGINEERS, ACUSTIC ENGINEER'S AND FIRE CONSULTANTS. ANY DISCREPANCIES BETWEEN ANY DOCUMENT, DRAWINGS OR SCHEDULE SHOULD BE CLARIFIED AT TENDER OR THE MOST ONEROUS OPTION SHALL BE DEEMED TO HAVE BEEN ALLOWED FOR.
2. ALL SERVICE ROUTES DETAILED ARE DEEMED APPROXIMATE. THE CONTRACTOR SHALL BE RESPONSIBLE FOR DETERMINING EXACT ROUTES AND POSITIONS OF ALL INSTALLED SERVICES AND EQUIPMENT IN CONJUNCTION WITH THE COLLEGE EDUCATION / DELIVERY TEAM.
3. THE EXACT POSITION OF ALL SERVICES AND EQUIPMENT SHALL BE AGREED BY THE CONTRACTOR.
4. THE CONTRACTOR SHALL BE RESPONSIBLE FOR FULLY COORDINATING ANY SERVICES INSTALLED WITHIN THE BUILDING FABRIC AND SERVICES INSTALLED BY OTHERS.

Rev	Date	Description	By
P05	14.02.22	REVISED ISSUE	TD
P04	15.12.22	REF. UPGRADE TO CURRENT REVISION	TD
P03	16.11.22	PROMOTED TO REVISED SITE PLAN	TD
P02	30.03.22	STAGE 3 ISSUE	TD
P01	18.03.21	STAGE 3 ISSUE	TD

Project	Hough End Sports Village
Title	ELECTRICAL SERVICES EXTERNAL LIGHTING LAYOUT VERTICAL ILLUMINANCE
Client	Manchester City Council

2nd Floor, South Central, 11 Peter Street, Manchester, M2 5DR
0161 638 6362 / 0161 638 6364
mail@watermangroup.com / www.watermangroup.com

Designing Studio	STAGE 4	Project No	BSD13812
Designed by	TD	Checked by	TD
Drawn by	TD	Date	MAR 2021
Scale (if A2)	1:1250	Computer File No	
Drawing No	HEV-WBS-01-XX-DR-E-63101	Revision	P05