


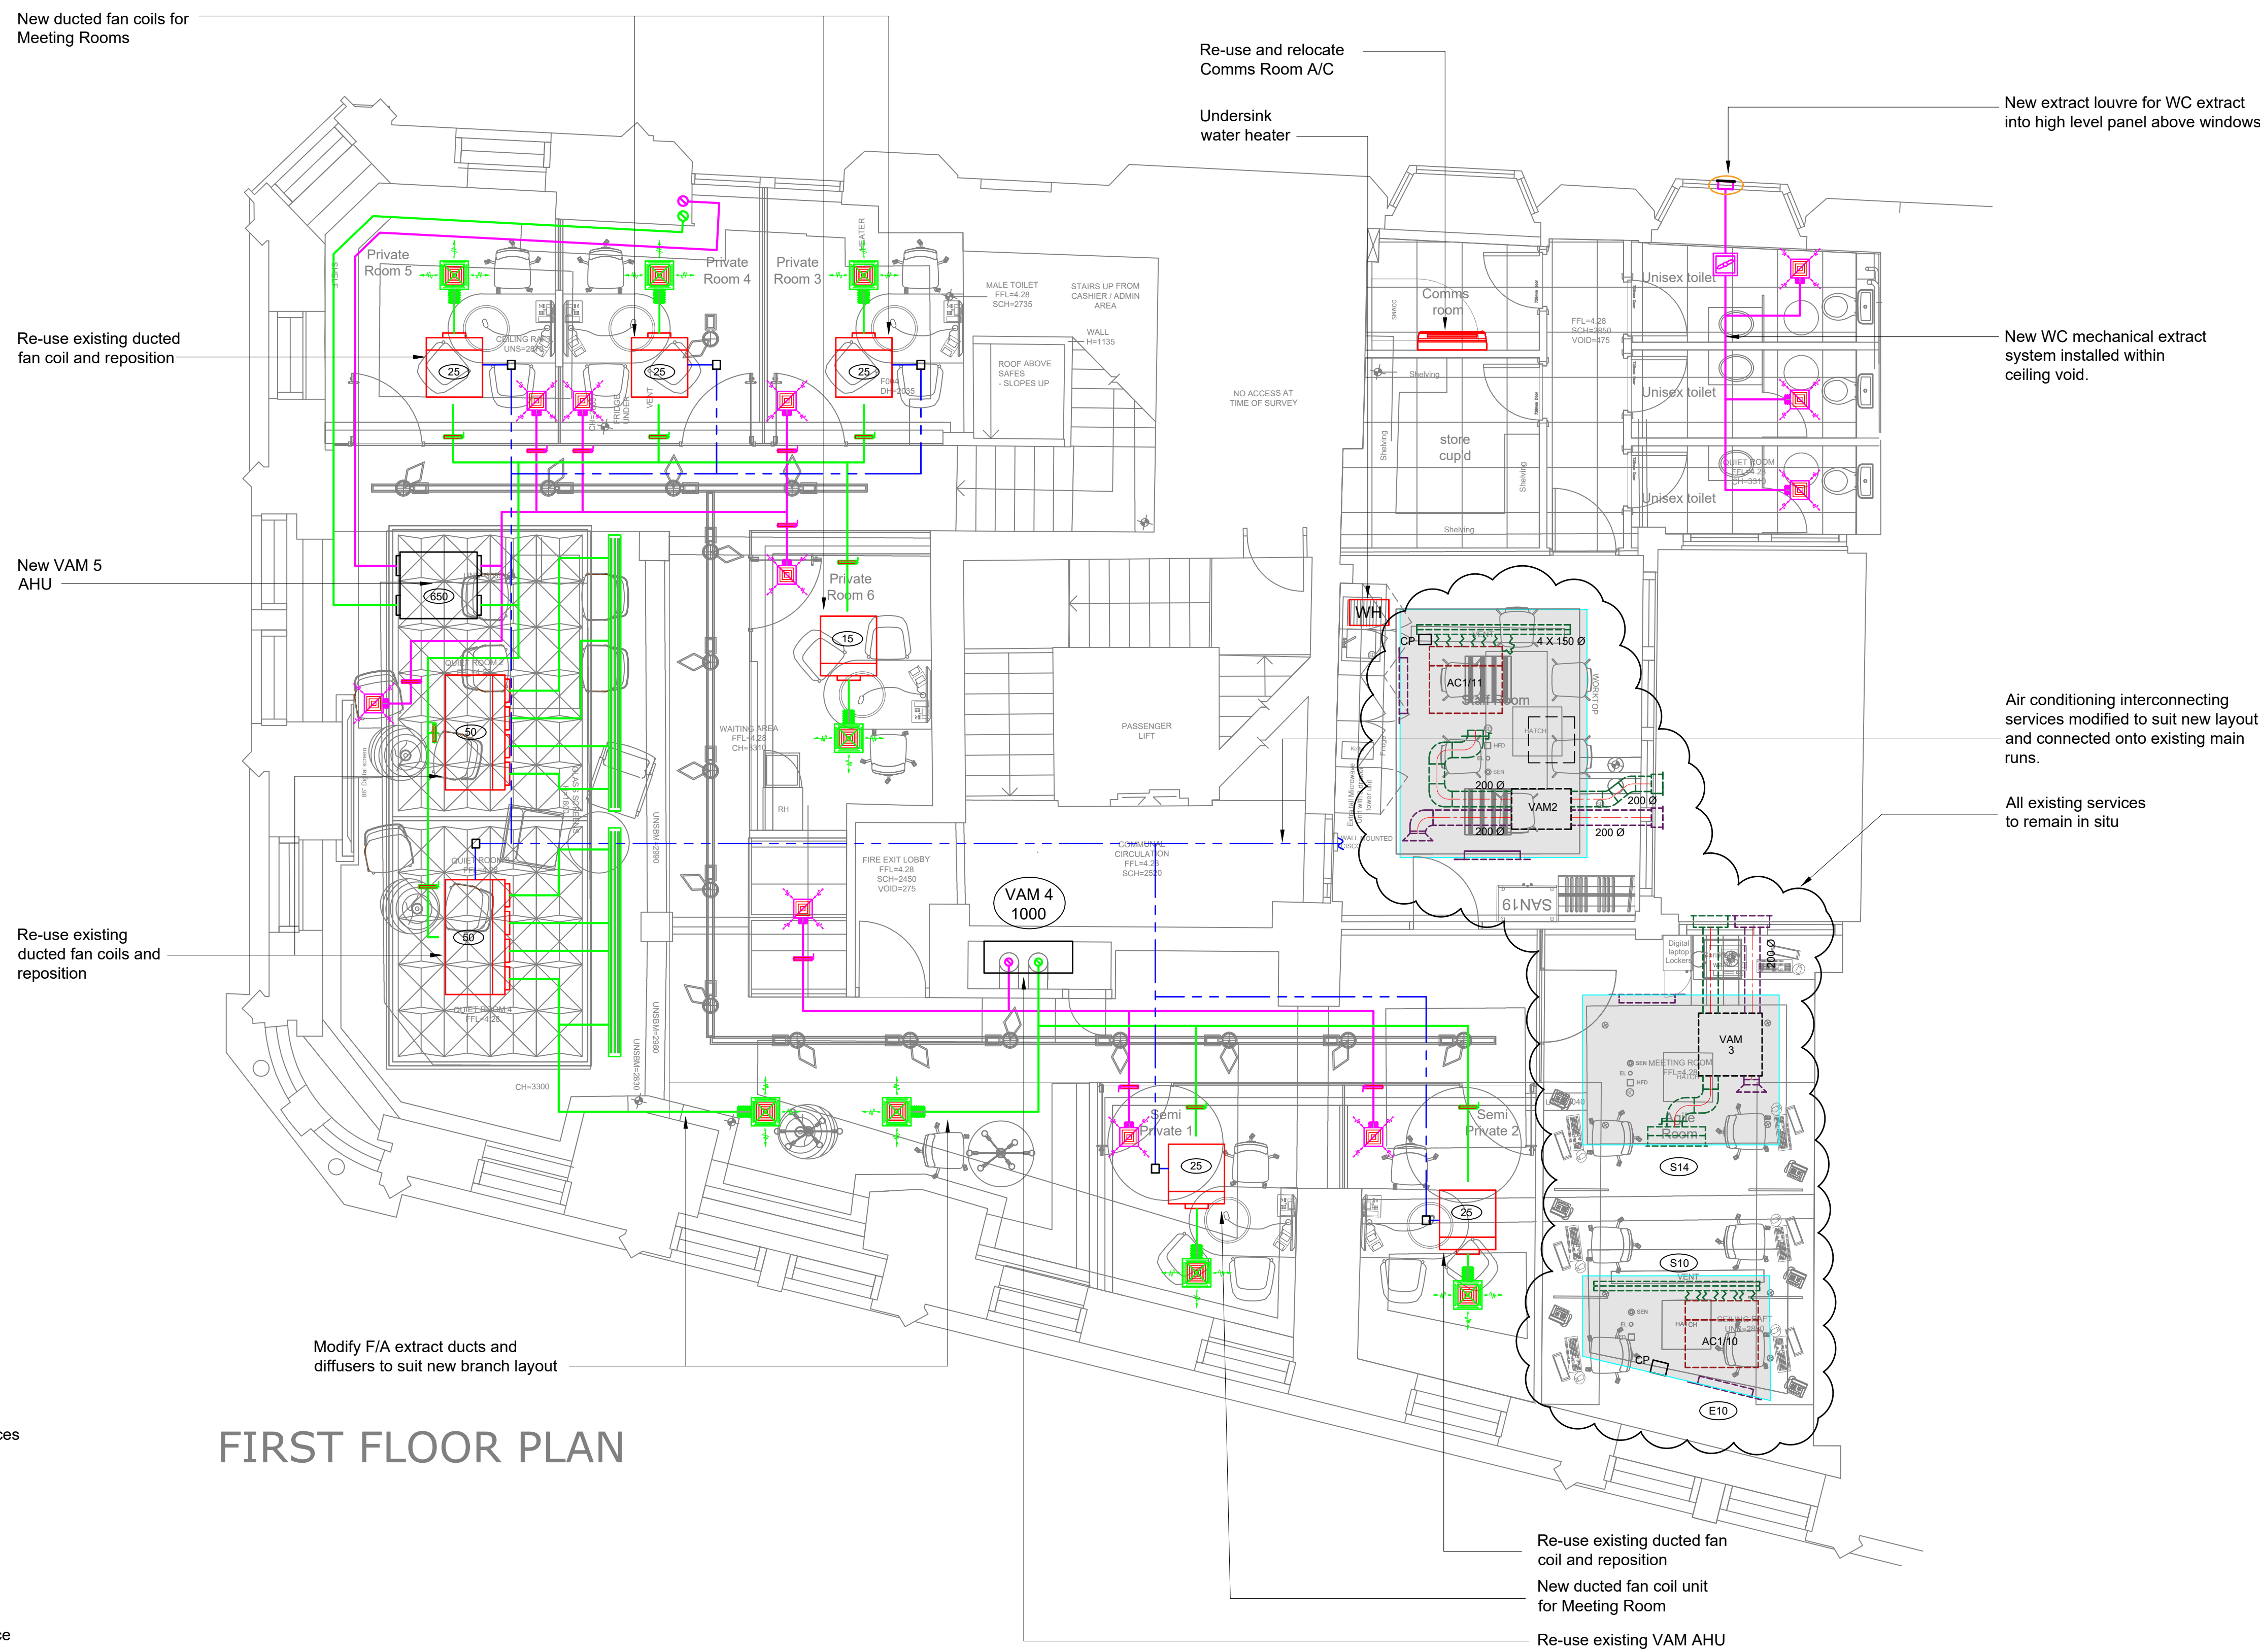

- Legend**
- Extract Attenuator
 - Supply Attenuator
 - New ductwork
 - Existing ductwork
 - Open up and make good penetration for services
 - New penetration and make good services
 - RC - Remote controller
 - ODHC - Overdoor heater controller
 - FD - Fire damper
 - PIR - Passive infra red detector
 - Remove old radiators and decorate
 - Remove old radiators and decorate and replace with new 7 day panel heater
 - Condensate
 - A/C pipework
 - AC - Air conditioning fan coils
 - H - Heater
 - S - Supply Diffusers
 - E - Extract diffusers

FIRST FLOOR PLAN

21 Degrees Limited, Business & Innovation Centre, Wearfield, Sunderland Enterprise Park(East), Sunderland. SR5 2TA Tel:0191-5166679 Fax:0191-5166689 e-mail: Admin@21-degrees.co.uk	
PROJECT Santander 28/34 Cross Street, Manchester, M2 7AQ	PROJECT No. -
CLIENT Santander	
DRAWING TITLE Proposed First Floor HVAC Services Upgrade (option 1)	
DRAWN RSR	CHECKED VN
DATE 10.03.22	Scale A1/A3 1:50/1:100
DRAWING No. Cross-HVAC-FF-02	REVISION -
DRAWING STATUS ○ PRELIMINARY ○ CONSTRUCTION ○ AS BUILT	
APPROVAL ●	