


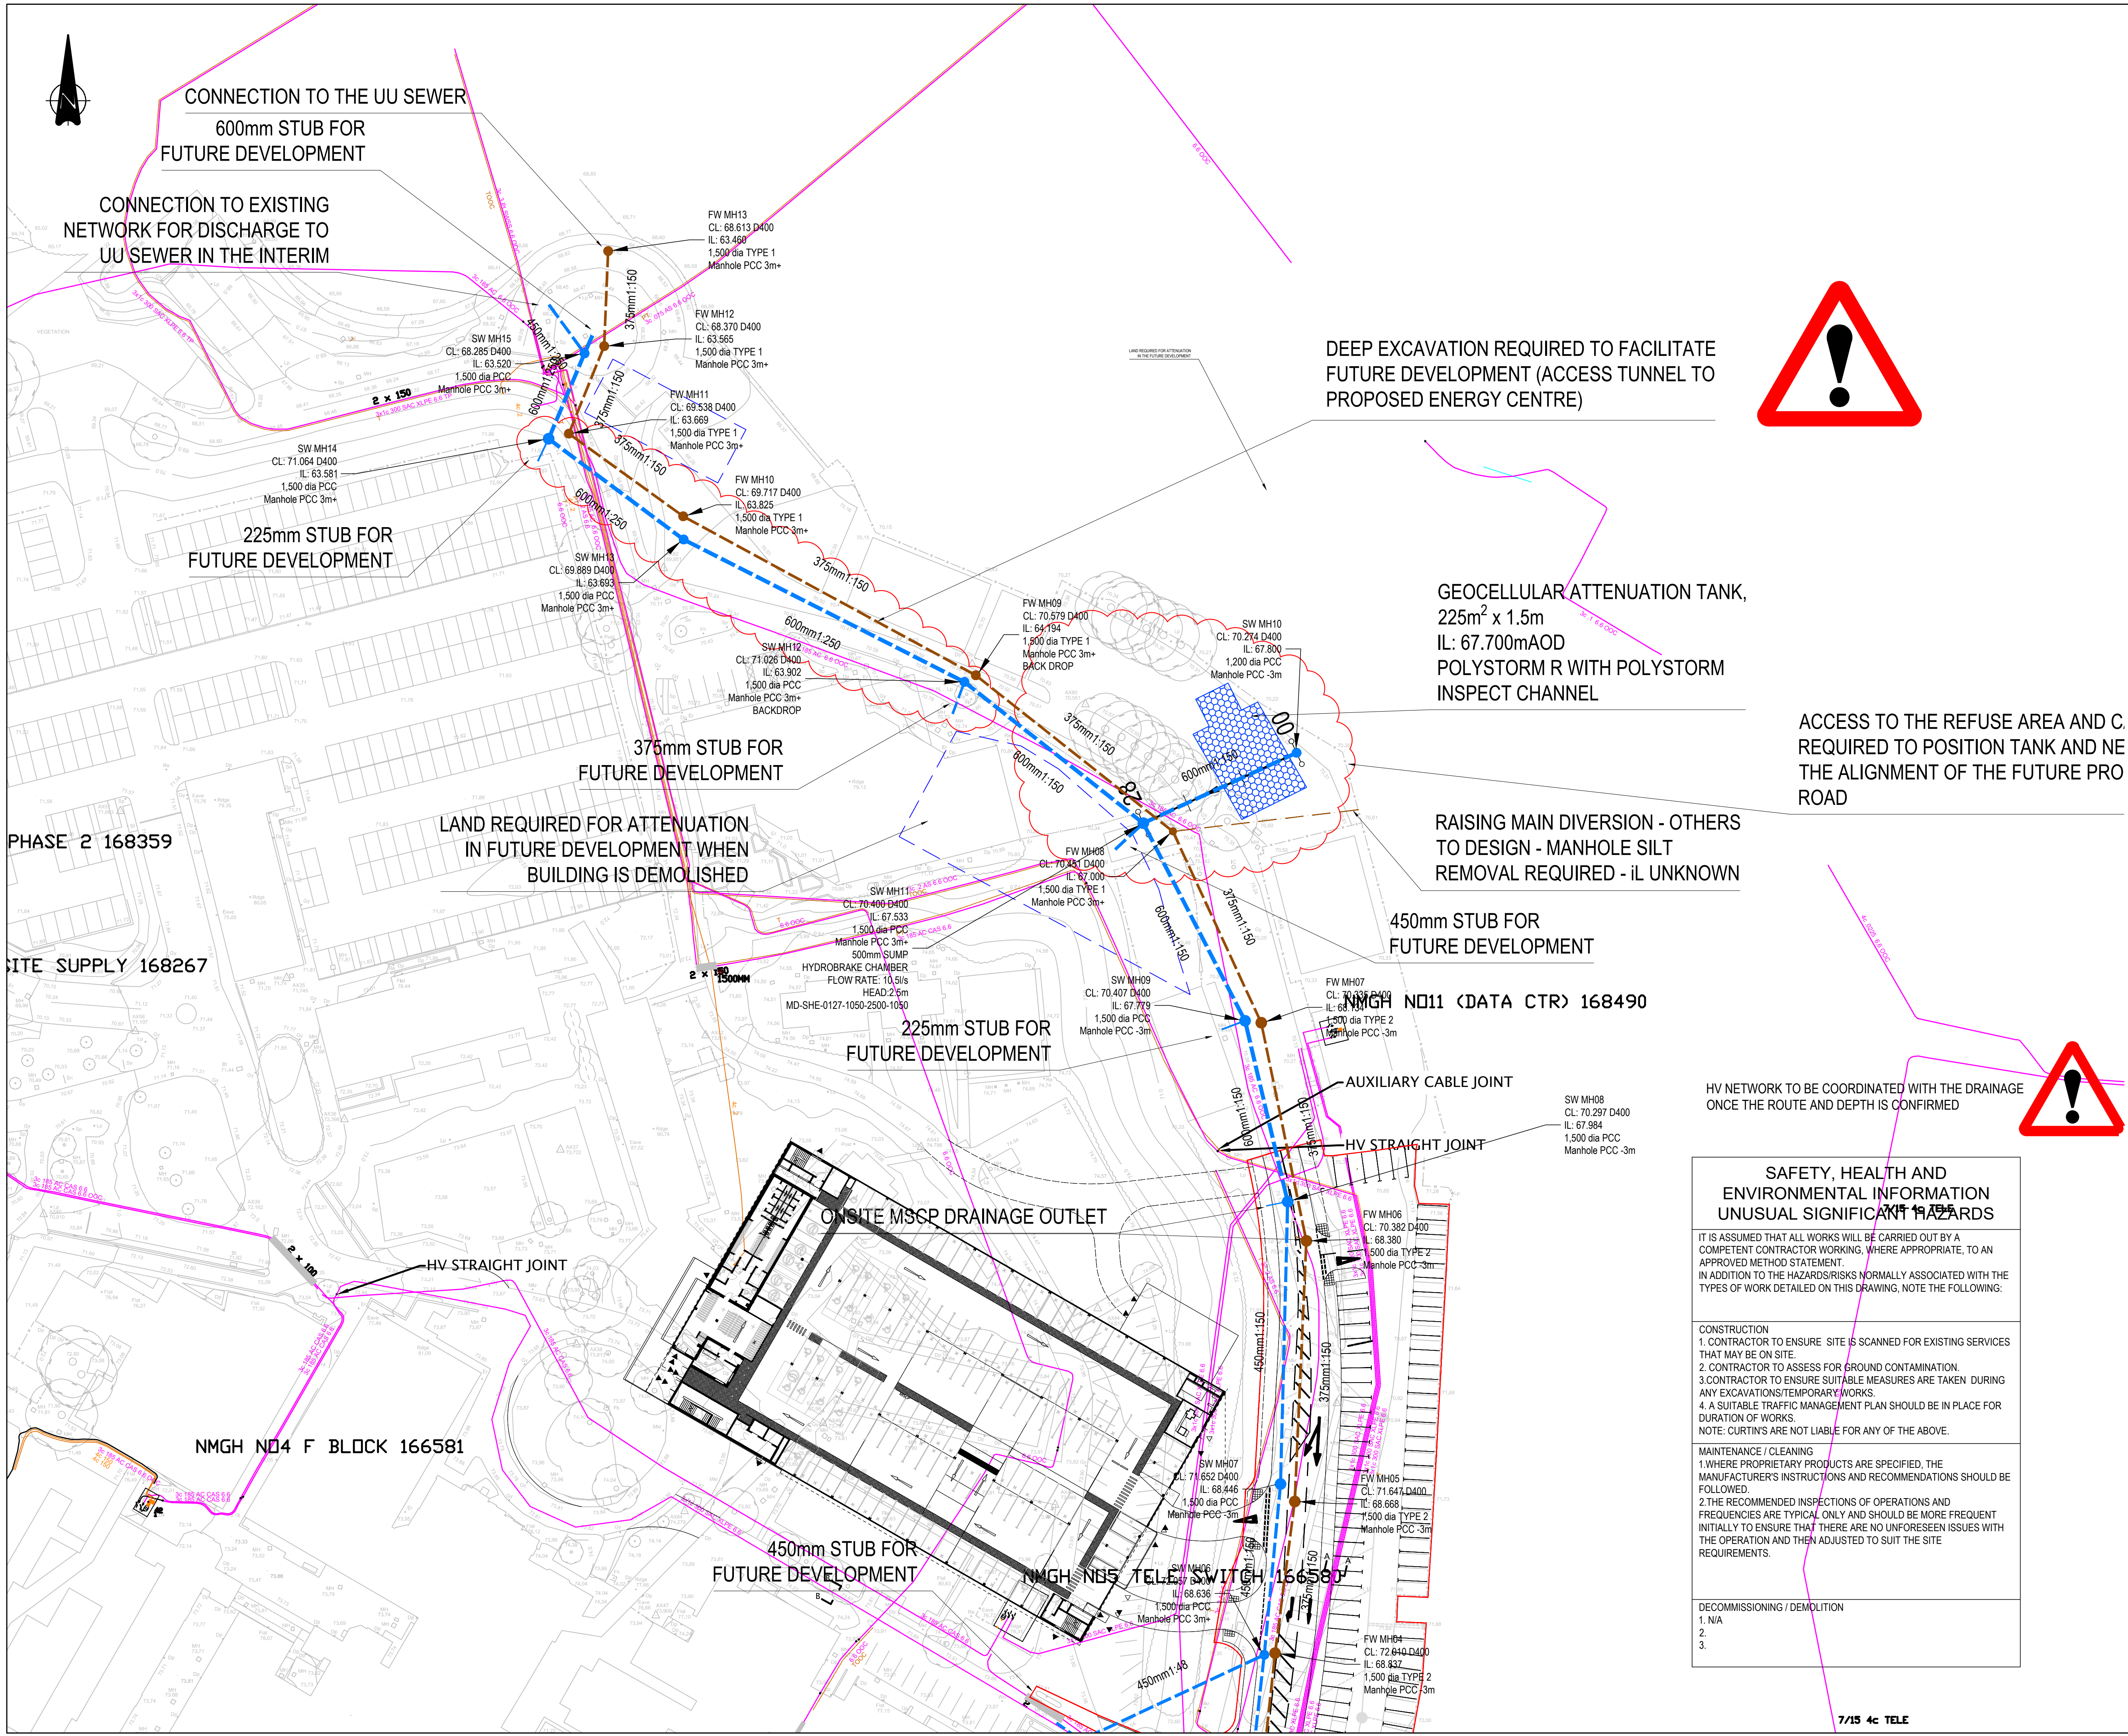

- Notes:
1. THIS DRAWING IS TO BE READ IN CONJUNCTION WITH ALL RELEVANT ARCHITECTS AND ENGINEERS DRAWINGS AND SPECIFICATIONS.
 2. DO NOT SCALE THIS DRAWING. ANY AMBIGUITIES, OMISSIONS AND ERRORS ON DRAWINGS SHALL BE BROUGHT TO THE ENGINEERS ATTENTION IMMEDIATELY. ALL DIMENSIONS MUST BE CHECKED / VERIFIED ON SITE.
 3. ALL DIMENSIONS ARE IN METRES UNLESS NOTED OTHERWISE.
 4. FOR GENERAL NOTES REFER TO DRAWING.

KEY

PROPOSED WORKS BOUNDARY

PROPOSED SURFACE WATER SEWER

PROPOSED FOUL WATER SEWER

HV NETWORK

REV.	DESCRIPTION	DATE	DRW.	CHK.
P06	DETECTION CHECK UPDATE (FOUL/SURFACE)	23.02.22	DE	HS
P05	DRAINAGE LAYOUT UPDATED	21.12.21	TH	DE
P04	DRAINAGE LAYOUT UPDATED	06.12.21	TH	HS
P03	TITLE BOX UPDATED	30.07.21	TH	HS
P02	UPDATED IL ON FW08 AND FW09	01.07.21	DE	HS
P01	FIRST ISSUE	28.05.21	DE	HS

Manchester University
NHS Foundation Trust

Merchant Exchange, 17-19 Whitworth Street West, Manchester M1 5WG
0161 236 2306
manchester@curtins.com
www.curtins.com

PROJECT

MSCP ENABLING WORKS

TITLE

CARRIER DRAINAGE
SHEET 2 OF 2

STATUS	PURPOSE OF ISSUE
S3	FOR REVIEW/COMMENT

DRAWN BY	CHECKED BY	DATE
DE	HS	28/05/2021

SCALE (@A1)	PROJECT NUMBER
1:500	077416

FILE DRAWING NUMBER	REV.
20200-CUR-MSCP-EX-DR-D-7502	P06