





©2020 Cellnex
All rights reserved. No part of this publication may be reproduced, stored in a retrieval system or transmitted in any form or by any means (Electronic, Mechanical, Photocopying, Recording or otherwise), without the prior written consent of the Company.

NOTES

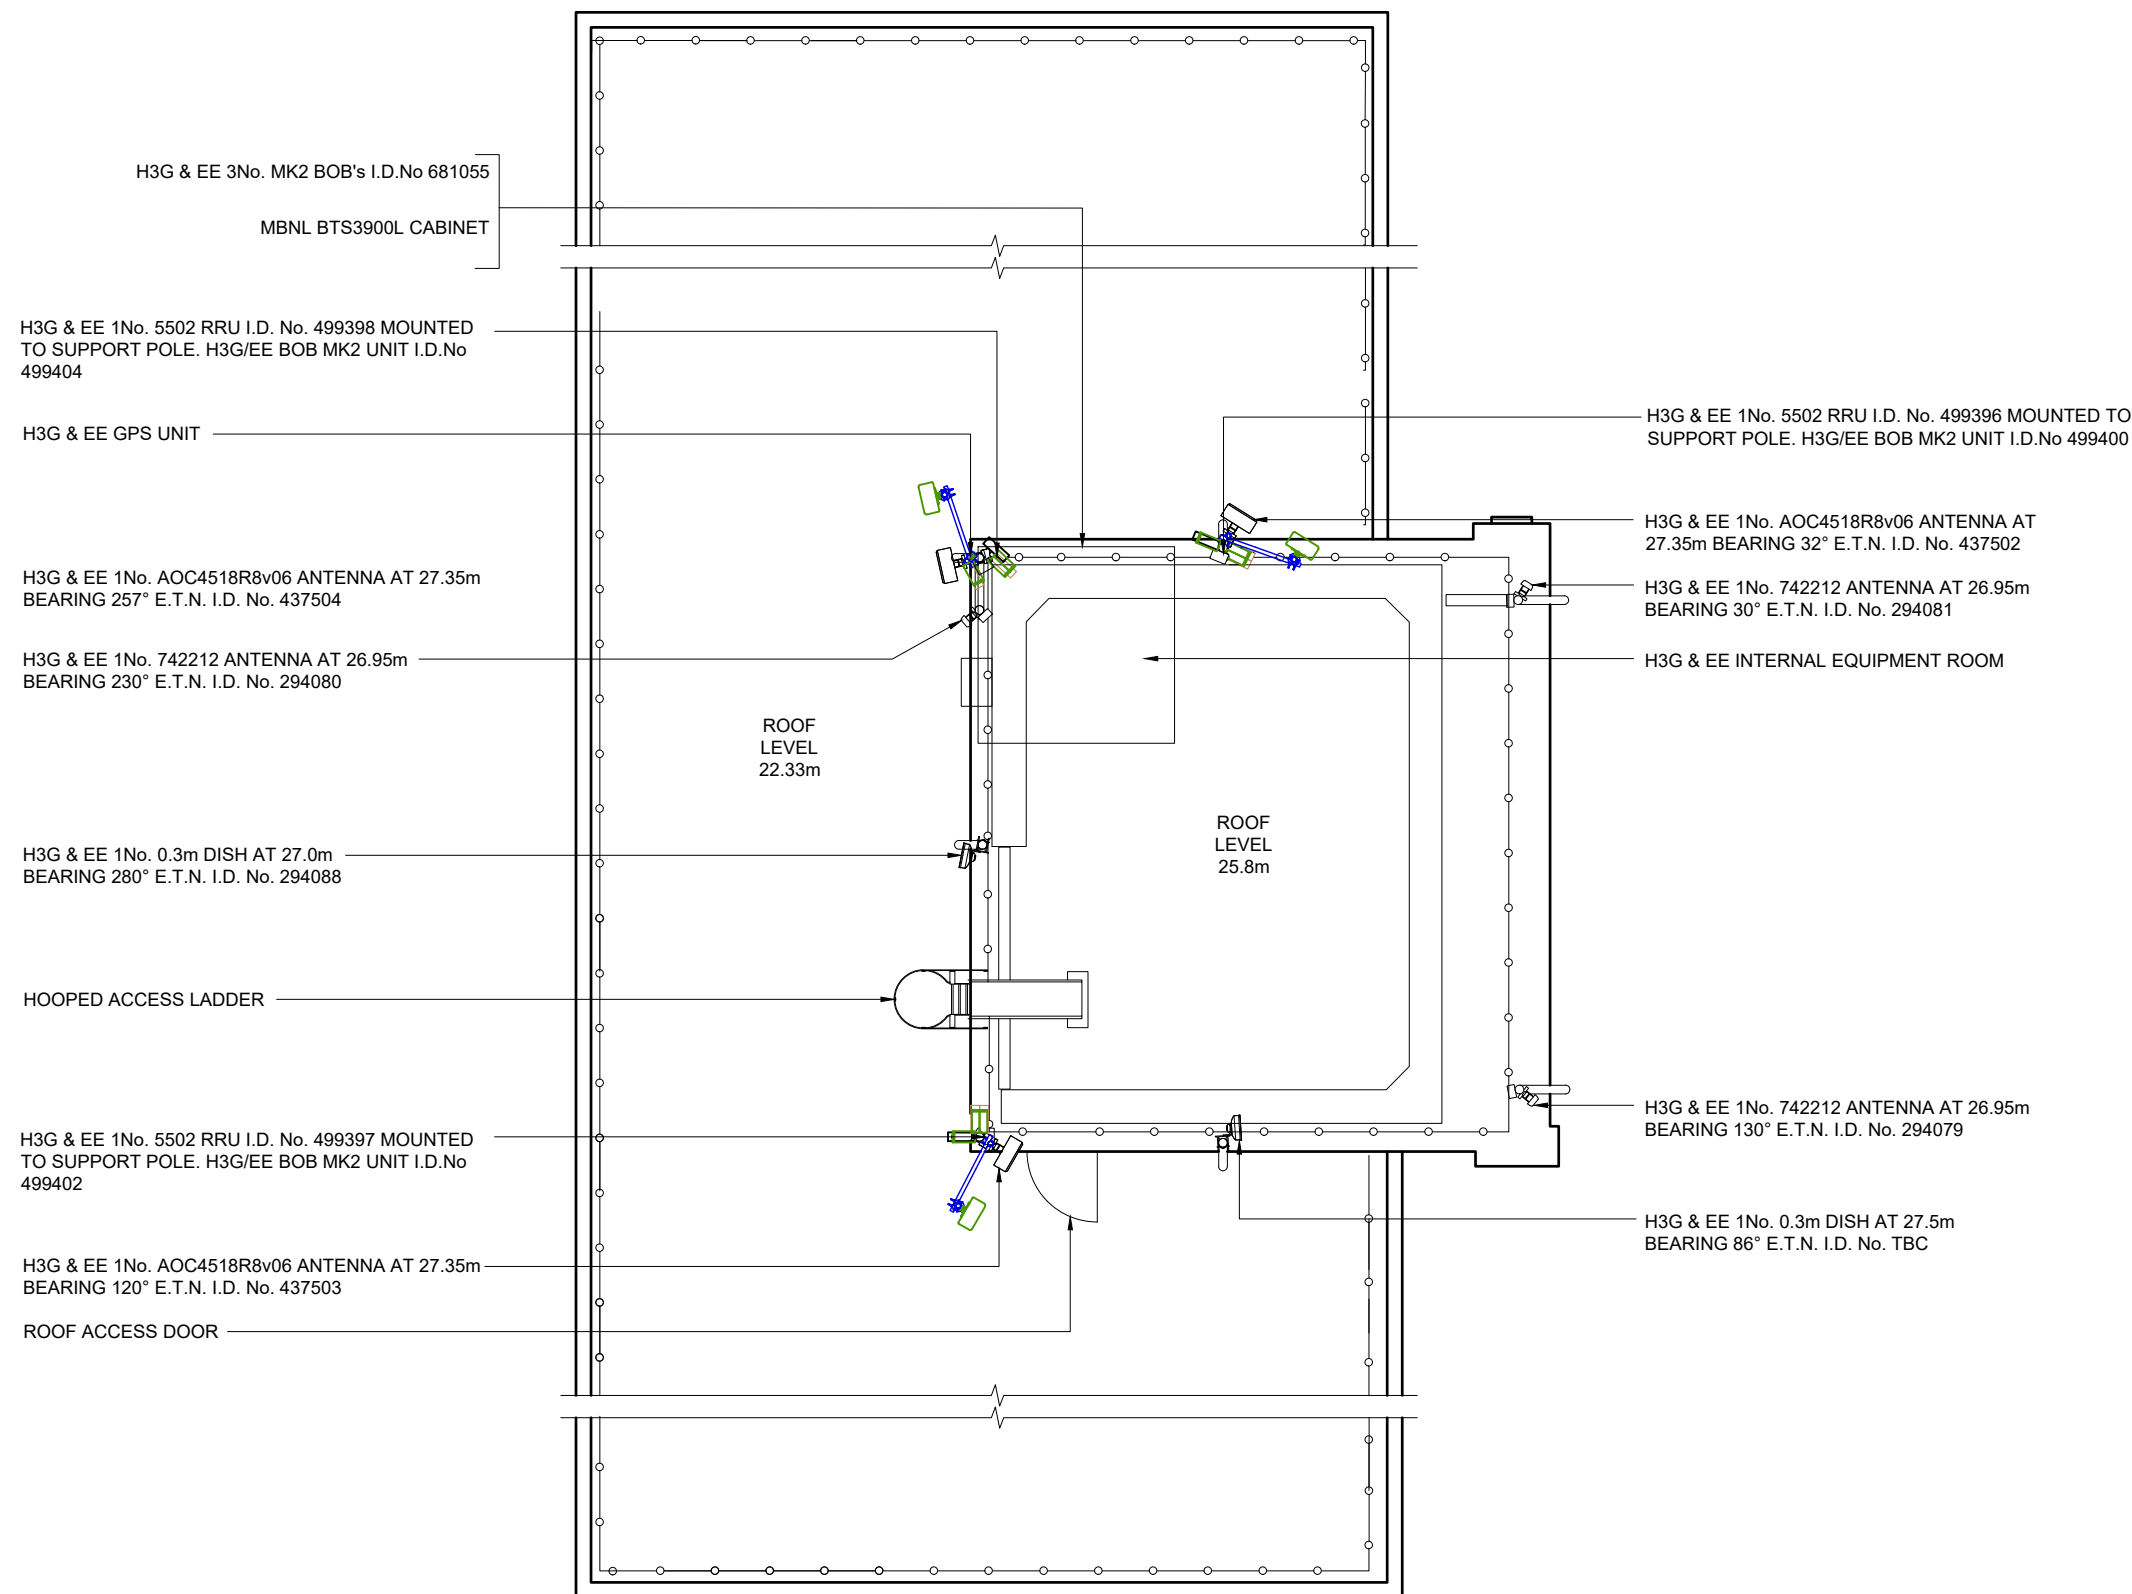

 SITE PLAN



FEINT DETAILS INDICATE LOCATIONS
RESERVED FOR OTHER PROPOSALS
WHICH MAY BE THE SUBJECT OF
SEPARATE APPLICATIONS

PROJECT No.		230330			
CELL No.		MAN076			
	PROJ No				
4	PROJ No 238736 PLANNING		10/11/21	WHP	WHP
3	PROJ No 230330 AS BUILT		01/02/21	WHP	MF
2	PROJ No 230330 PLANNING		29/10/20	WHP	WHP
1	PROJ No 9BMOBL MD CREATION		02/12/19	KG	FC
ISS	REVISION	DATE	DRN	APP	



CELLNEX UK
R+, 4TH FLOOR, 2 BLA GRAVE STREET, READING, RG1 1AZ
Tel. 020 4526 8553

SITE No 87249
MANCHESTER DEVONSHIRE STRE
APEX HOUSE
2 DEVONSHIRE STREET NORTH, A
MANCHESTER
GREATER MANCHESTER
M12 6JQ

NGR SJ 85796 97015

OS GRID 385796 397015

TITLE
SITE PLAN
AS BUILT
H3G & EE LTD

SCALE 1:100

DRAWN KG 27/11/19

APPROVED WHP 10/11/21

DRG No. 87249-02-100-MD004
Sheet 1 of 1
Rev 4



©2020 Cellnex
All rights reserved. No part of this publication may be reproduced, stored in a retrieval system or transmitted in any form or by any means (Electronic, Mechanical, Photocopying, Recording or otherwise), without the prior written consent of the Company.

NOTES

H3G & EE 3No. MK2 BOB's I.D.No 681055

MBNL BTS3900L CABINET

AC UNIT

RRUKINE +24v PSU

MBNL IMB05

ROXTEC GLAND

MBNL 3-PHASE ELTEK EF2S PSU

MBNL 2No. VENTS

MBNL 300 WIDE O/H CABLE LADDER

AC UNIT

MBNL SUPREME RACK (REDUNDANT)

 
MBNL O/H CABLE LADDER

MBNL 8No. FLOOR MOUNTED NOKIA 2100 FLEXI
MODULES WITH 3No. MK2 UCU's ON TOP

MBNL APM 5930

MBNL 42U TRANSMISSION RACK TX1 C/W
TRANSMISSION EQUIPMENT

CRABTREE POLESTAR 3-PHASE DIST.BOARD



EE EQUIPMENT LAYOUT

FEINT DETAILS INDICATE LOCATIONS
RESERVED FOR OTHER PROPOSALS
WHICH MAY BE THE SUBJECT OF
SEPARATE APPLICATIONS

PROJECT No. 230330

CELL No. MAN076

	PROJ No			
	PROJ No	238736		
4	PLANNING		10/11/21	WHP
	PROJ No	230330		
3	AS BUILT		01/02/21	WHP
	PROJ No	230330		
2	PLANNING		29/10/20	WHP
	PROJ No	9BMOBL		
1	MD CREATION		02/12/19	KG
ISS	REVISION	DATE	DRN	APP



CELLNEX UK
R+, 4TH FLOOR, 2 BLAGRAVE STREET, READING, RG1 1AZ
Tel. 020 4526 8553

SITE No 87249
MANCHESTER DEVONSHIRE STRE
APEX HOUSE
2 DEVONSHIRE STREET NORTH, A
MANCHESTER
GREATER MANCHESTER
M12 6JQ

NGR SJ 85796 97015

OS GRID 385796 397015

TITLE
EQUIPMENT PLAN
AS BUILT
H3G & EE LTD


SCALE 1:25

DRAWN KG 27/11/19

APPROVED WHP 10/11/21

DRG No. 87249-02-101-MD004
Sheet 1 of 1
Rev 4

NOTES

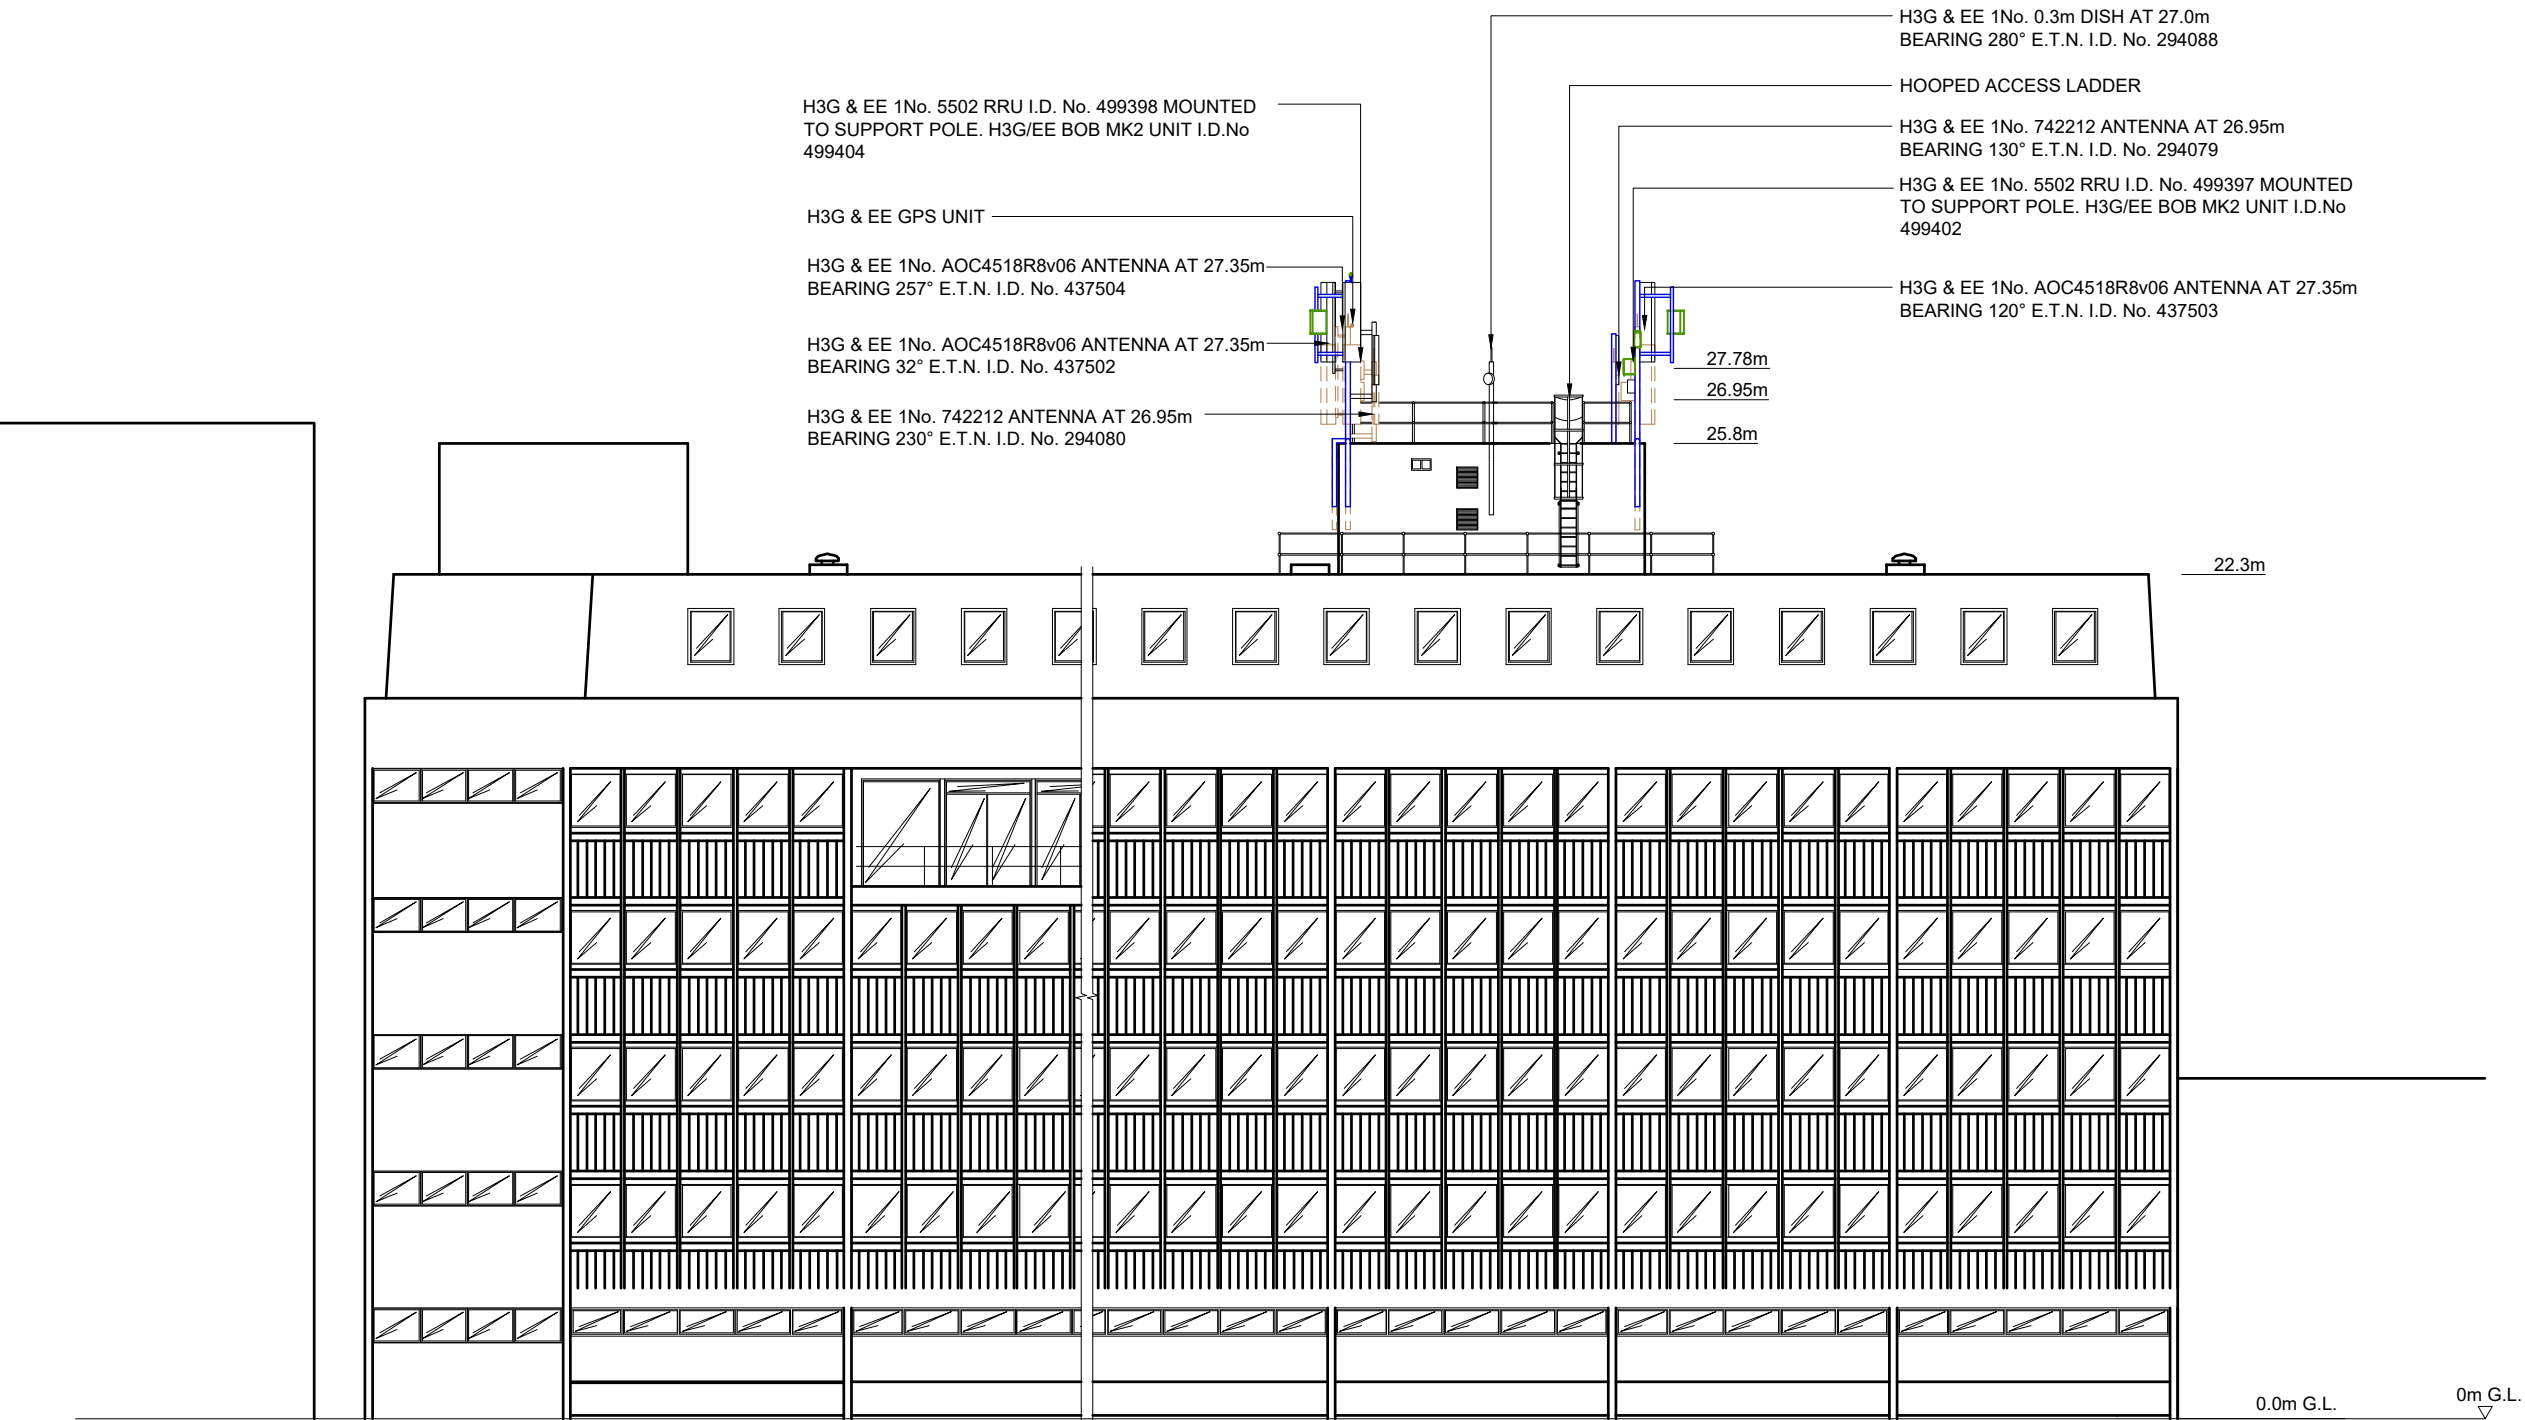

0 1m 5m 10m

WEST ELEVATION

FEINT DETAILS INDICATE LOCATIONS
RESERVED FOR OTHER PROPOSALS
WHICH MAY BE THE SUBJECT OF
SEPARATE APPLICATIONS

PROJECT No.	230330
CELL No.	MAN076

	PROJ No			
4	PROJ No 238736 PLANNING	10/11/21	WHP	WHP
3	PROJ No 230330 AS BUILT	01/02/21	WHP	PMF
2	PROJ No 230330 PLANNING	29/10/20	WHP	WHP
1	PROJ No 9BMOBL MD CREATION	02/12/19	KG	FC
ISS	REVISION	DATE	DRN	APP



CELLNEX UK
R+, 4TH FLOOR, 2 BLAGRAVE STREET, READING, RG1 1AZ
Tel. 020 4526 8553

SITE No 87249
MANCHESTER DEVONSHIRE STRE
APEX HOUSE
2 DEVONSHIRE STREET NORTH, A
MANCHESTER
GREATER MANCHESTER
M12 6JQ

NGR SJ 85796 97015
OS GRID 385796 397015

TITLE
ELEVATION
AS BUILT
H3G & EE LTD

SCALE 1:200

DRAWN	KG	27/11/19
APPROVED	WHP	10/11/21

DRG No.	Sheet 1 of 1	Rev
87249-02-150-MD004		4



EE BTS 3900L CABINET I.D. No. 411979
INSIDE CABIN TO BE REMOVED
PROPOSED EE 1No. AIRI CABINET I.D. No. 724752
TO BE INSTALLED IN CABIN
EE IMB05 CABINET I.D. No. 724749
INSIDE CABIN TO BE REMOVED
EE 3No. MK2 BOB's I.D. No. 681055 INSTALLED
ON BOB LADDER

H3G & EE 1No. GPS MODULE AT 28.0m MEAN, I.D. No. 551238
INSTALLED ON SUPPORT POLE TO BE REMOVED
PROPOSED EE 1No. UHF GPS MODULE AT 30.25m MEAN,
I.D. No. 551239 TO BE INSTALLED ON SUPPORT POLE
PROPOSED EE 1No. AIR 3278 ANTENNA AT 29.0m
MEAN, BEARING 257° E.T.N. I.D. No. 551242 TO BE
INSTALLED ON PROPOSED SUPPORT POLE
H3G & EE 1No. AOC4518R8v06 ANTENNA AT 27.35m MEAN,
BEARING 257° E.T.N. I.D. No. 437504 TO BE RAISED TO
29.0m MEAN ON PROPOSED STEELWORK
H3G & EE 1No. 3262 RRU I.D. No. 499398 & 1No. 5258
RRU I.D. No. 437907 MOUNTED TO SUPPORT POLE
TO BE REMOVED
PROPOSED EE 1No. 2460 RRU I.D. No. 551245, 1No.
4480 RRU I.D. No. 551246 & 1No. 4419 RRU I.D. No.
551251 TO BE INSTALLED ON SUPPORT POLE
EE 1No. BOB MK2 I.D. No. 499404 MOUNTED TO
SUPPORT POLE

H3G & EE 1No. 742212 ANTENNA AT 26.95m BEARING 230°
E.T.N. I.D. No. 294080 TO BE RAISED TO 28.0m MEAN

H3G & EE 1No. 0.3m DISH AT 27.0m
BEARING 280° E.T.N. I.D. No. 294088

HOOPED ACCESS LADDER

PROPOSED EE 1No. AIR 3278 ANTENNA AT 29.0m
MEAN, BEARING 120° E.T.N. I.D. No. 551241 TO BE
INSTALLED ON PROPOSED SUPPORT POLE
H3G & EE 1No. AOC4518R8v06 ANTENNA AT 27.35m
BEARING 120° E.T.N. I.D. No. 437503 TO BE RAISED
TO 29.0m MEAN ON PROPOSED STEELWORK
H3G & EE 1No. 3262 RRU I.D. No. 499397 & 1No. 5258
RRU I.D. No. 437906 MOUNTED TO SUPPORT POLE
TO BE REMOVED
PROPOSED EE 1No. 2460 RRU I.D. No. 551244, 1No.
4480 RRU I.D. No. 551247 & 1No. 4419 RRU I.D. No.
551250 TO BE INSTALLED ON SUPPORT POLE
EE 1No. BOB MK2 I.D. No. 499402 MOUNTED TO
SUPPORT POLE

ROOF ACCESS DOOR

PROPOSED EE 1No. AIR 3278 ANTENNA AT 29.0m
MEAN, BEARING 32° E.T.N. I.D. No. 551240 TO BE
INSTALLED ON PROPOSED SUPPORT POLE
H3G & EE 1No. AOC4518R8v06 ANTENNA AT 27.35m MEAN,
BEARING 32° E.T.N. I.D. No. 437502 TO BE RAISED TO
29.0m MEAN ON PROPOSED STEELWORK
H3G & EE 1No. 3262 RRU I.D. No. 499396 & 1No. 5258
RRU I.D. No. 437905 MOUNTED TO SUPPORT POLE
TO BE REMOVED
PROPOSED EE 1No. 2460 RRU I.D. No. 551243, 1No.
4480 RRU I.D. No. 551248 & 1No. 4419 RRU I.D. No.
551249 TO BE INSTALLED ON SUPPORT POLE
EE 1No. BOB MK2 I.D. No. 499400 MOUNTED TO
SUPPORT POLE

 
H3G & EE 1No. 742212 ANTENNA AT 26.95m BEARING 32°
E.T.N. I.D. No. 294081 TO BE RAISED TO 28.0m MEAN

H3G & EE INTERNAL EQUIPMENT ROOM

H3G & EE 1No. 742212 ANTENNA AT 26.95m BEARING 130°
E.T.N. I.D. No. 294079 TO BE RAISED TO 28.0m MEAN

H3G & EE 1No. 0.3m DISH AT 27.5m
BEARING 86° E.T.N.

ROOF LEVEL
25.8m



FEINT DETAILS INDICATE LOCATIONS
RESERVED FOR OTHER PROPOSALS
WHICH MAY BE THE SUBJECT OF
SEPARATE APPLICATIONS

©2020 Cellnex
All rights reserved. No part of this publication may be reproduced, stored in
a retrieval system or transmitted in any form or by any means (Electronic,
Mechanical, Photocopying, Recording or otherwise), without the prior
written consent of the Company.

NOTES

PROJECT No. 238736

CELL No. 66222

	PROJ No			
4	PROJ No 238736 PLANNING	10/11/21	WHP	WHP
3	PROJ No 230330 AS BUILT	01/02/21	WHP	MF
2	PROJ No 230330 PLANNING	29/10/20	WHP	WHP
1	PROJ No 9BMOBL MD CREATION	02/12/19	KG	FC
ISS	REVISION	DATE	DRN	APP



CELLNEX UK
R+, 4TH FLOOR, 2 BLA GRAVE STREET, READING, RG1 1AZ
Tel. 020 4526 8553

SITE No 87249

MANCHESTER DEVONSHIRE STRE
APEX HOUSE
2 DEVONSHIRE STREET NORTH, A
MANCHESTER
GREATER MANCHESTER
M12 6JQ

NGR SJ 85796 97015

OS GRID 385796 397015

TITLE
SITE PLAN
PROPOSED
H3G & EE LTD

SCALE 1:100

DRAWN	KG	27/11/19
APPROVED	WHP	10/11/21

DRG No.	Sheet 1 of 1	Rev
87249-02-110-MD004		4



©2020 Cellnex
All rights reserved. No part of this publication may be reproduced, stored in a retrieval system or transmitted in any form or by any means (Electronic, Mechanical, Photocopying, Recording or otherwise), without the prior written consent of the Company.

NOTES

EE BTS 3900L CABINET I.D. No. 411979
INSIDE CABIN TO BE REMOVED

PROPOSED EE 1No. AIRI CABINET I.D. No. 724752
TO BE INSTALLED IN CABIN

EE 3No. MK2 BOB's I.D. No. 681055

AC UNIT

EE 1No.SUPREME RACK (REDUNDANT)

RRUKINE +24v PSU

EE O/H CABLE LADDER

EE IMB05 CABINET I.D. No. 724749
INSIDE CABIN TO BE REMOVED

H3G & EE 8No. FLOOR MOUNTED NOKIA 2100 FLEXI
MODULES WITH 3No. MK2 UCU's ON TOP

ROXTEC GLAND

EE 3-PHASE ELTEK EF2S PSU

H3G & EE 1No. APM 5930

2No. VENTS

 
EE 42U TRANSMISSION RACK TX1 C/W TRANSMISSION EQUIPMENT

300 WIDE O/H CABLE LADDER

AC UNIT

CRABTREE POLESTAR 3-PHASE DISTRIBUTION BOARD

H3G & EE INTERNAL EQUIPMENT ROOM



FEINT DETAILS INDICATE LOCATIONS
RESERVED FOR OTHER PROPOSALS
WHICH MAY BE THE SUBJECT OF
SEPARATE APPLICATIONS

PROJECT No. 238736

CELL No. 66222

	PROJ No			
4	PROJ No 238736 PLANNING	10/11/21	WHP	WHP
3	PROJ No 230330 AS BUILT	01/02/21	WHP	MF
2	PROJ No 230330 PLANNING	29/10/20	WHP	WHP
1	PROJ No 9BMOBL MD CREATION	02/12/19	KG	FC
ISS	REVISION	DATE	DRN	APP



CELLNEX UK
R+, 4TH FLOOR, 2 BLAGRAVE STREET, READING, RG1 1AZ
Tel. 020 4526 8553

SITE No 87249

MANCHESTER DEVONSHIRE STRE
APEX HOUSE
2 DEVONSHIRE STREET NORTH, A
MANCHESTER
GREATER MANCHESTER
M12 6JQ

NGR SJ 85796 97015

OS GRID 385796 397015

TITLE
EQUIPMENT PLAN
PROPOSED
H3G & EE LTD

SCALE 1:25

DRAWN KG 27/11/19

APPROVED WHP 10/11/21

DRG No.	Sheet 1 of 1	Rev
87249-02-111-MD004		4







©2020 Cellnex
All rights reserved. No part of this publication may be reproduced, stored in a retrieval system or transmitted in any form or by any means (Electronic, Mechanical, Photocopying, Recording or otherwise), without the prior written consent of the Company.

NOTES


PROJECT No.		238736			
CELL No.		66222			
	PROJ No				
4	PROJ No	238736		10/11/21	WHP
	PLANNING				
3	PROJ No	230330		01/02/21	WHP
	AS BUILT				
2	PROJ No	230330		29/10/20	WHP
	PLANNING				
1	PROJ No	9BMOBL		02/12/19	KG
	MD CREATION				
ISS	REVISION		DATE	DRN	APP
cellnex driving telecom connectivity CELLNEX UK R+, 4TH FLOOR, 2 BLAGRAVE STREET, READING, RG1 1AZ Tel. 020 4526 8553					
SITE No		87249			
MANCHESTER DEVONSHIRE STREET					
APEX HOUSE					
2 DEVONSHIRE STREET NORTH, A					
MANCHESTER					
GREATER MANCHESTER					
M12 6JQ					
NGR		SJ 85796 97015			
OS GRID		385796 397015			
TITLE					
ANTENNA LAYOUT					
PROPOSED					
H3G & EE LTD					
SCALE		1:25			
DRAWN		KG		27/11/19	
APPROVED		WHP		10/11/21	
DRG No.		Sheet 1 of 1			Rev
87249-02-161-MD004					4

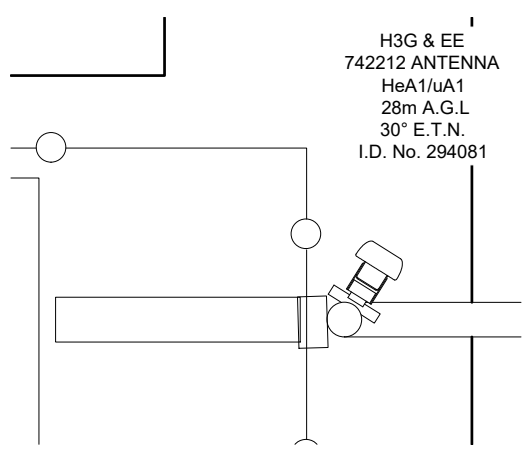


SECTOR 1 ANTENNA LAYOUT AT 28m

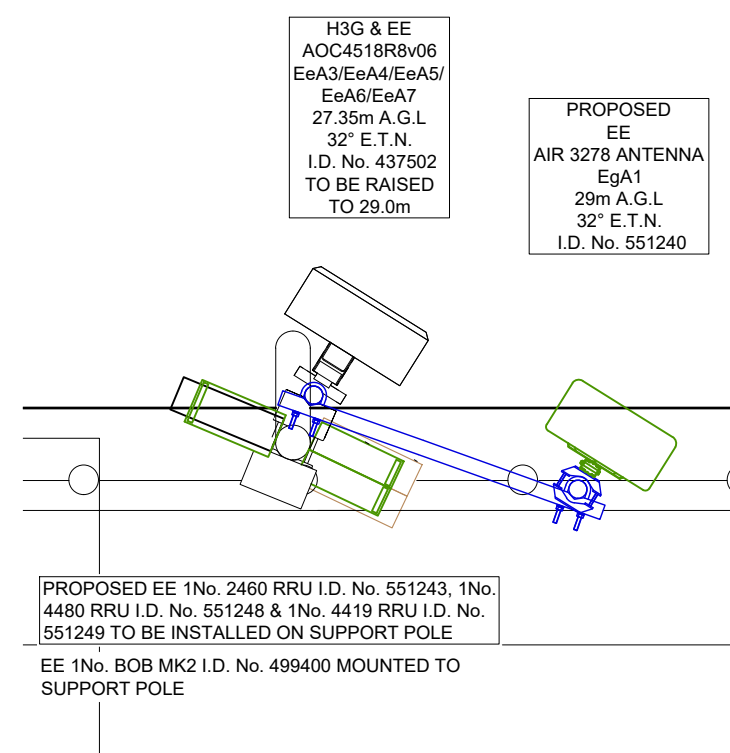


SECTOR 1 ANTENNA LAYOUT AT 29m

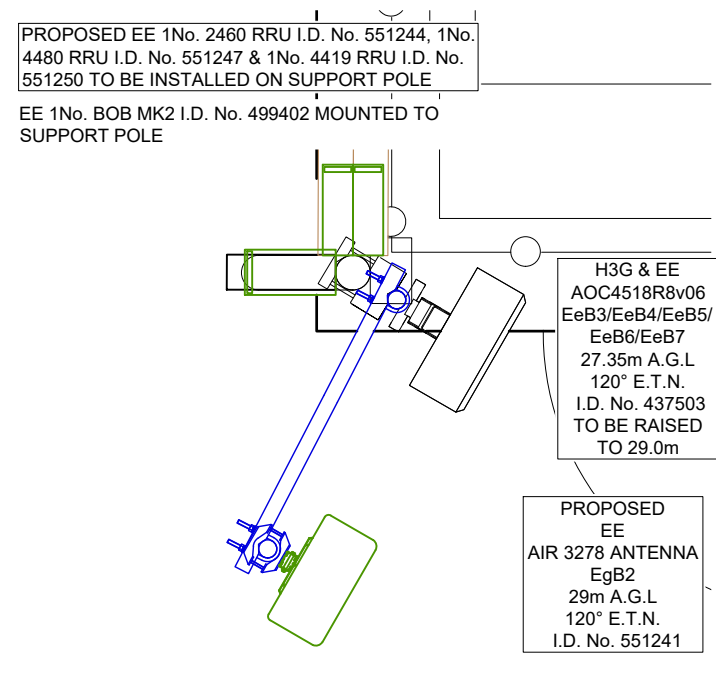


SECTOR 2 ANTENNA LAYOUT AT 29m

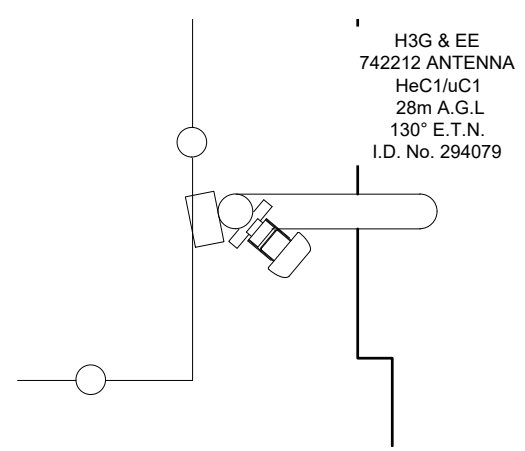

SECTOR 2 ANTENNA LAYOUT AT 28m

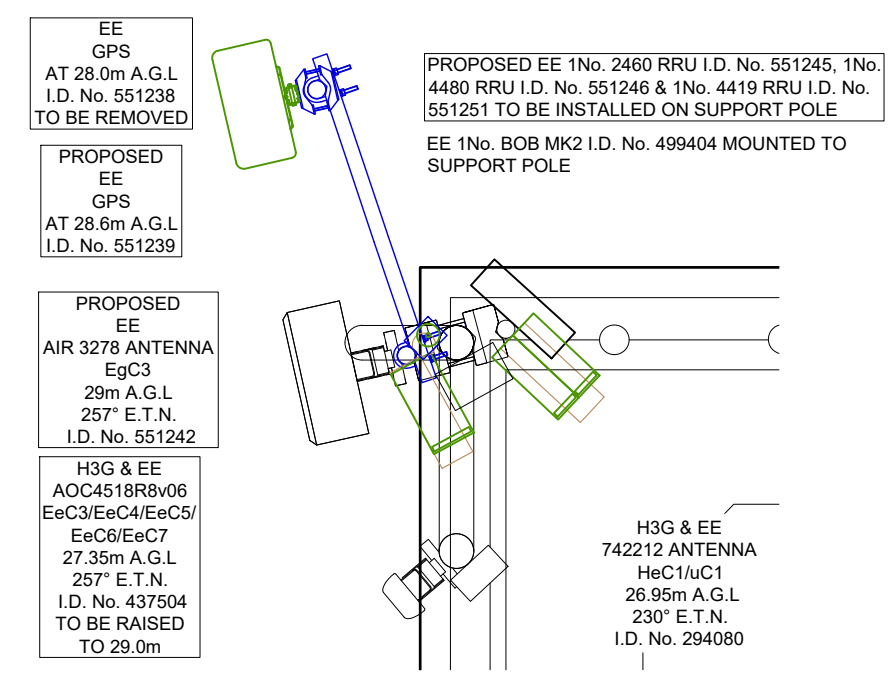

SECTOR 3 ANTENNA LAYOUT AT 29m

 

FEINT DETAILS INDICATE LOCATIONS RESERVED FOR OTHER PROPOSALS WHICH MAY BE THE SUBJECT OF SEPARATE APPLICATIONS