


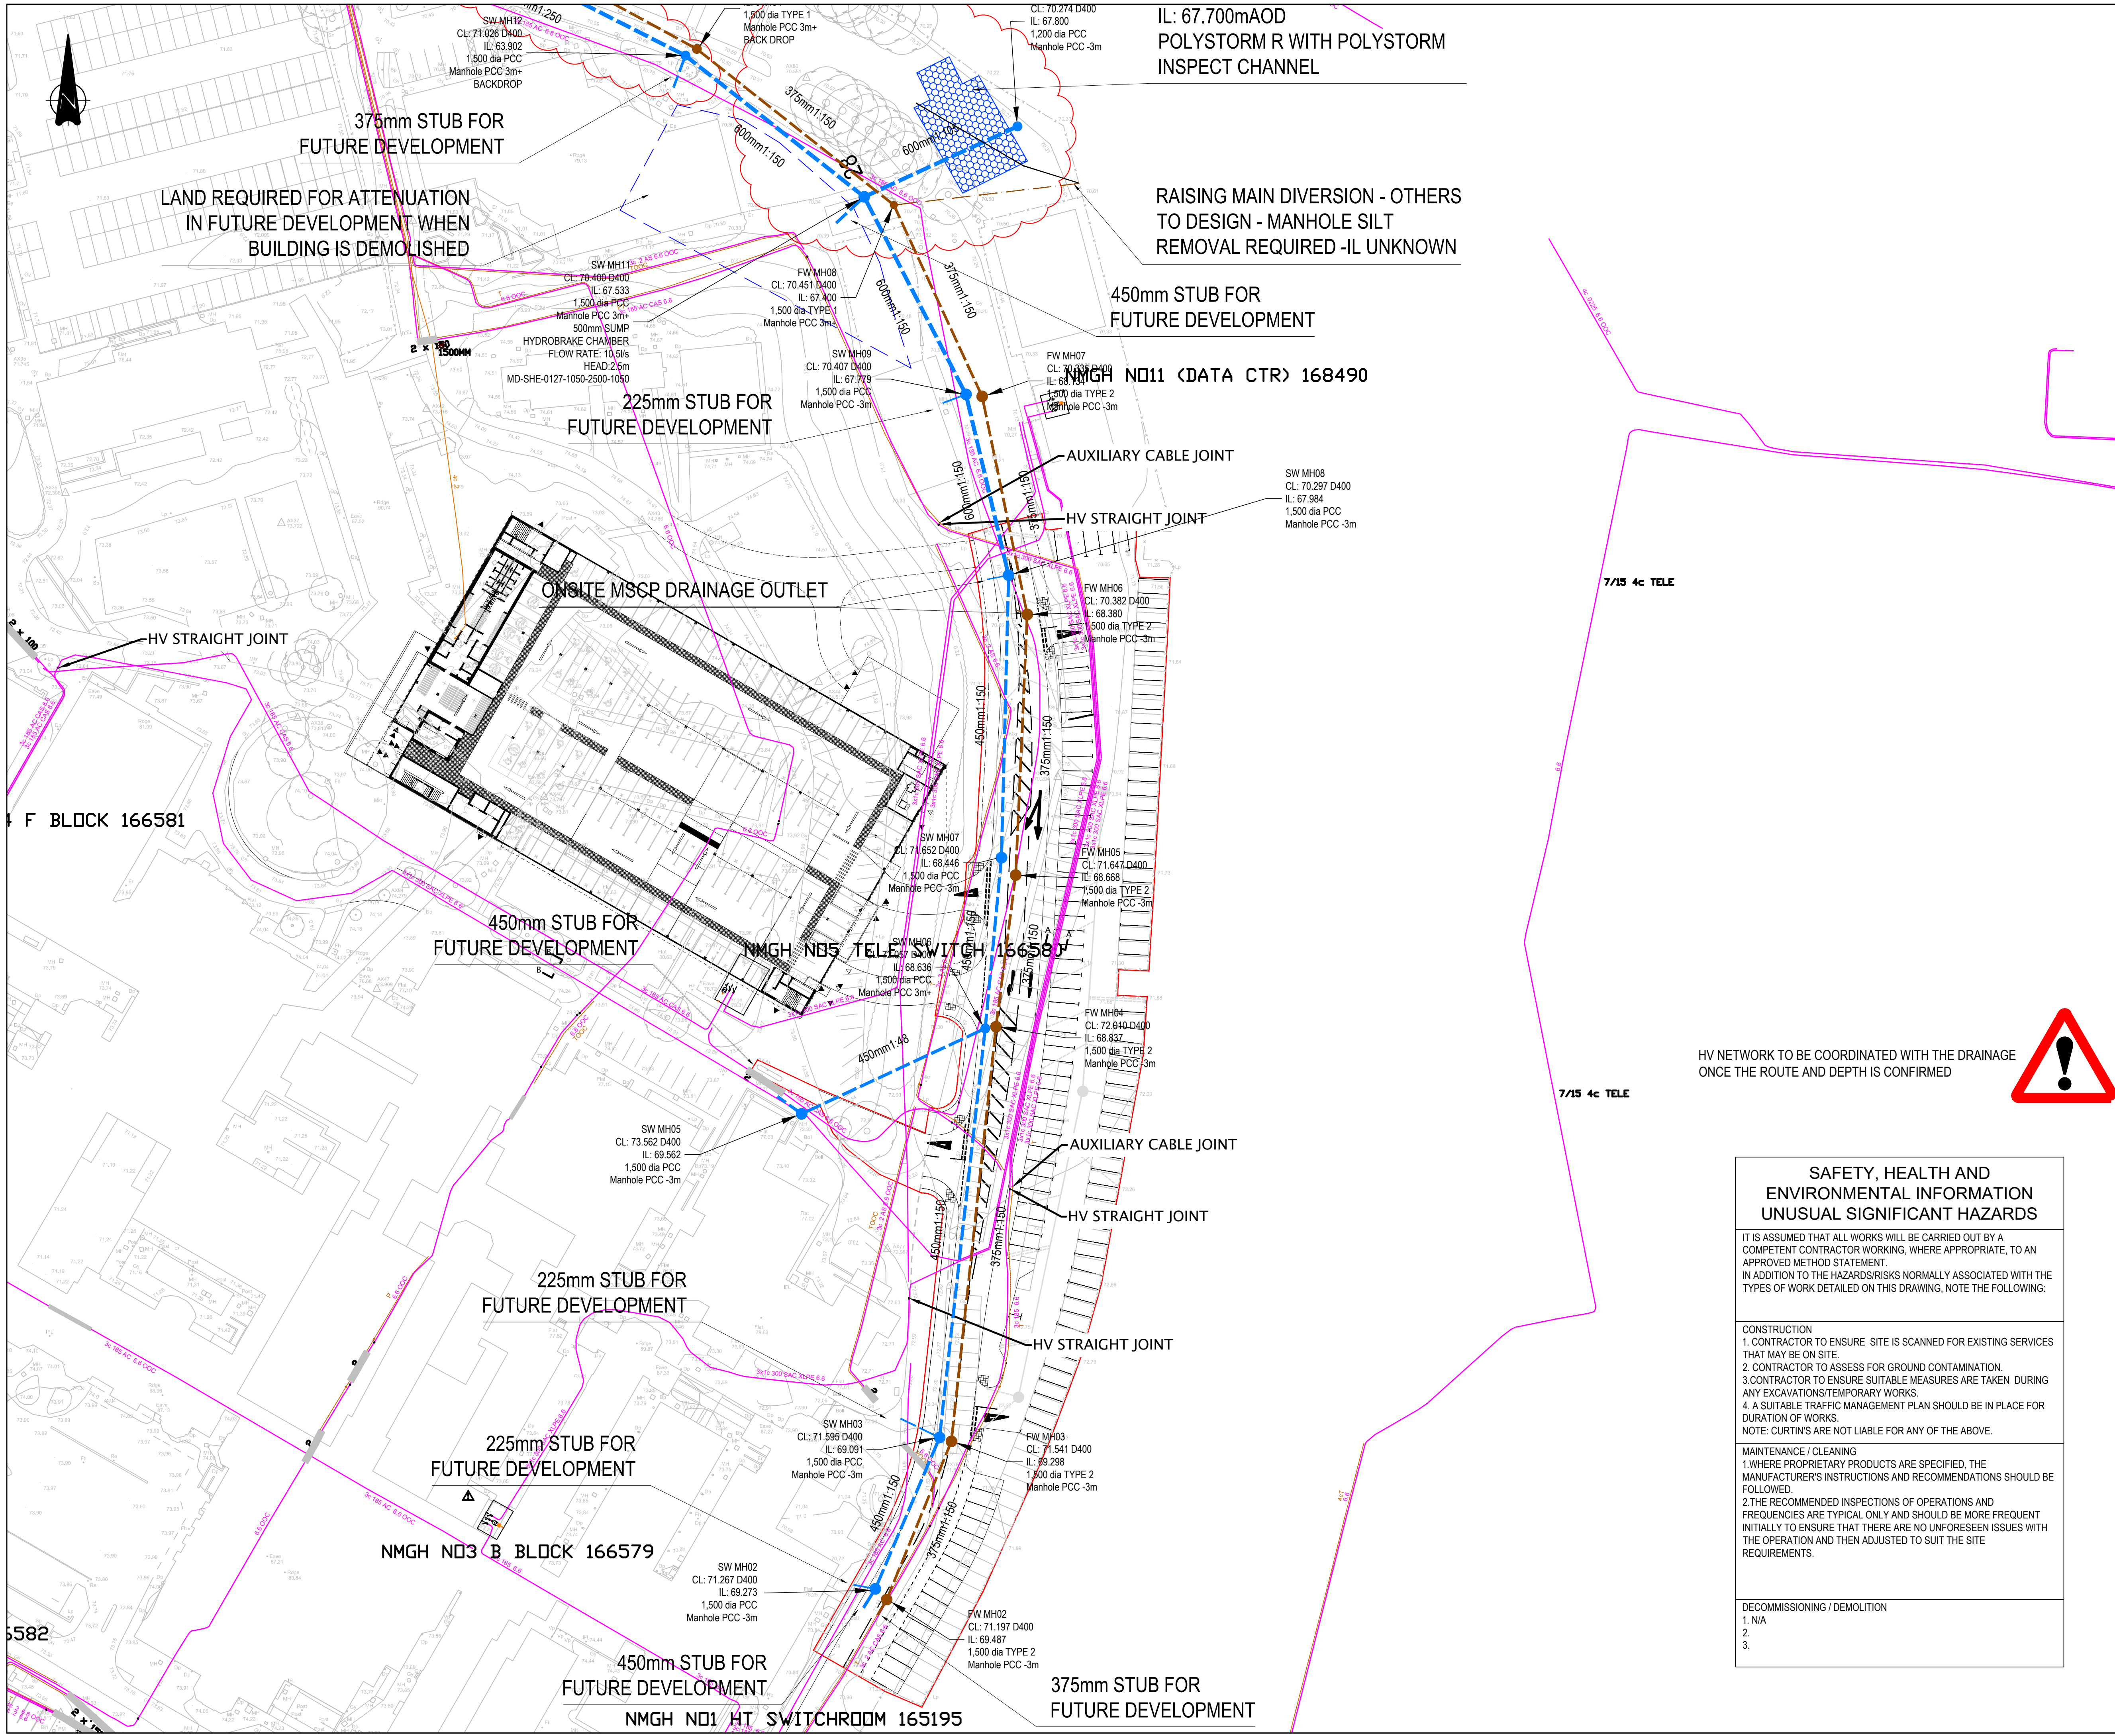

- Notes:**
1. THIS DRAWING IS TO BE READ IN CONJUNCTION WITH ALL RELEVANT ARCHITECTS AND ENGINEERS DRAWINGS AND SPECIFICATIONS.
 2. DO NOT SCALE THIS DRAWING. ANY AMBIGUITIES, OMISSIONS AND ERRORS ON DRAWINGS SHALL BE BROUGHT TO THE ENGINEERS ATTENTION IMMEDIATELY. ALL DIMENSIONS MUST BE CHECKED / VERIFIED ON SITE.
 3. ALL DIMENSIONS ARE IN METRES UNLESS NOTED OTHERWISE.
 4. FOR GENERAL NOTES REFER TO DRAWING.

KEY

	PROPOSED WORKS BOUNDARY
	PROPOSED SURFACE WATER SEWER
	PROPOSED FOUL WATER SEWER
	HV NETWORK
	FOUL DIVERSION
	FOUL RAISING MAIN DVERISION

REV.	DESCRIPTION	DATE	DRW.	CHK.
P04	DRAINAGE LAYOUT UPDATED	21.12.21	TH	DE
P03	DRAINAGE LAYOUT UPDATED	08.12.21	TH	HS
P02	TITLE BOX UPDATED	30.07.21	TH	HS
P01	FIRST ISSUE	28.05.21	HS	AR



HV NETWORK TO BE COORDINATED WITH THE DRAINAGE ONCE THE ROUTE AND DEPTH IS CONFIRMED

SAFETY, HEALTH AND ENVIRONMENTAL INFORMATION UNUSUAL SIGNIFICANT HAZARDS

IT IS ASSUMED THAT ALL WORKS WILL BE CARRIED OUT BY A COMPETENT CONTRACTOR WORKING, WHERE APPROPRIATE, TO AN APPROVED METHOD STATEMENT. IN ADDITION TO THE HAZARDS/RISKS NORMALLY ASSOCIATED WITH THE TYPES OF WORK DETAILED ON THIS DRAWING, NOTE THE FOLLOWING:

CONSTRUCTION

1. CONTRACTOR TO ENSURE SITE IS SCANNED FOR EXISTING SERVICES THAT MAY BE ON SITE.
2. CONTRACTOR TO ASSESS FOR GROUND CONTAMINATION.
3. CONTRACTOR TO ENSURE SUITABLE MEASURES ARE TAKEN DURING ANY EXCAVATIONS/TEMPORARY WORKS.
4. A SUITABLE TRAFFIC MANAGEMENT PLAN SHOULD BE IN PLACE FOR DURATION OF WORKS.

NOTE: CURTINS ARE NOT LIABLE FOR ANY OF THE ABOVE.

MAINTENANCE / CLEANING

1. WHERE PROPRIETARY PRODUCTS ARE SPECIFIED, THE MANUFACTURER'S INSTRUCTIONS AND RECOMMENDATIONS SHOULD BE FOLLOWED.
2. THE RECOMMENDED INSPECTIONS OF OPERATIONS AND FREQUENCIES ARE TYPICAL ONLY AND SHOULD BE MORE FREQUENT INITIALLY TO ENSURE THAT THERE ARE NO UNFORESEEN ISSUES WITH THE OPERATION AND THEN ADJUSTED TO SUIT THE SITE REQUIREMENTS.

DECOMMISSIONING / DEMOLITION

1. N/A
- 2.
- 3.

Manchester University
NHS Foundation Trust

Merchant Exchange, 17-19 Whitworth Street West, Manchester M1 5WG
0161 236 2304
manchester@curtins.com
www.curtins.com

PROJECT MSCP ENABLING WORKS

TITLE CARRIER DRAINAGE SHEET 1 OF 2

STATUS S3	PURPOSE OF ISSUE FOR REVIEW/COMMENT	
DRAWN BY DE	CHECKED BY HS	DATE 28/05/2021
SCALE (@A1) 1:250		PROJECT NUMBER 077416
FILE DRAWING NUMBER 20200-CUR-MSCP-EX-DR-D-7501		REV. P04