


THIS DRAWING IS THE PROPERTY OF FG MECHANICAL SERVICES LTD. AND MAY ONLY BE USED WITH THEIR WRITTEN APPROVAL.
DO NOT SCALE FROM THIS DRAWING.
GENERAL NOTES:
THIS DRAWING TO BE READ IN CONJUNCTION WITH ALL OTHER RELEVANT DRAWINGS AND SPECIFICATIONS.
ALL DIMENSIONS ARE IN MILLIMETRES UNLESS OTHERWISE STATED.
THE CONTRACTOR SHALL BE RESPONSIBLE FOR THE PRODUCTION OF FABRICATION AND INSTALLATION DRAWINGS. DRAWINGS SHALL BE FAMILIAR WITH OTHER WORKS PACKAGES WHICH DIRECTLY INTERFACE WITH HIS PACKAGE AND COORDINATE WITH THE FABRICATION AND INSTALLATION DRAWINGS ACCORDINGLY.
THE CONTRACTOR SHALL BE RESPONSIBLE FOR THE DESIGN, SUPPLY AND INSTALLATION OF SUPPORTS, BRACKETING SYSTEMS, AND SECONDARY STEELWORK SUPPORTS REQUIRED FOR THIS WORKS PACKAGE, UNLESS OTHERWISE STATED.
SHOULD ANY DISCREPANCIES BE APPARENT IN THIS DRAWING, THE ENGINEER SHALL BE MADE AWARE OF THIS FOR FURTHER ACTION.

NOTE:
VCD HANDLES TO BE POSITIONED
TO SUIT ACCESS PANEL LOCATIONS

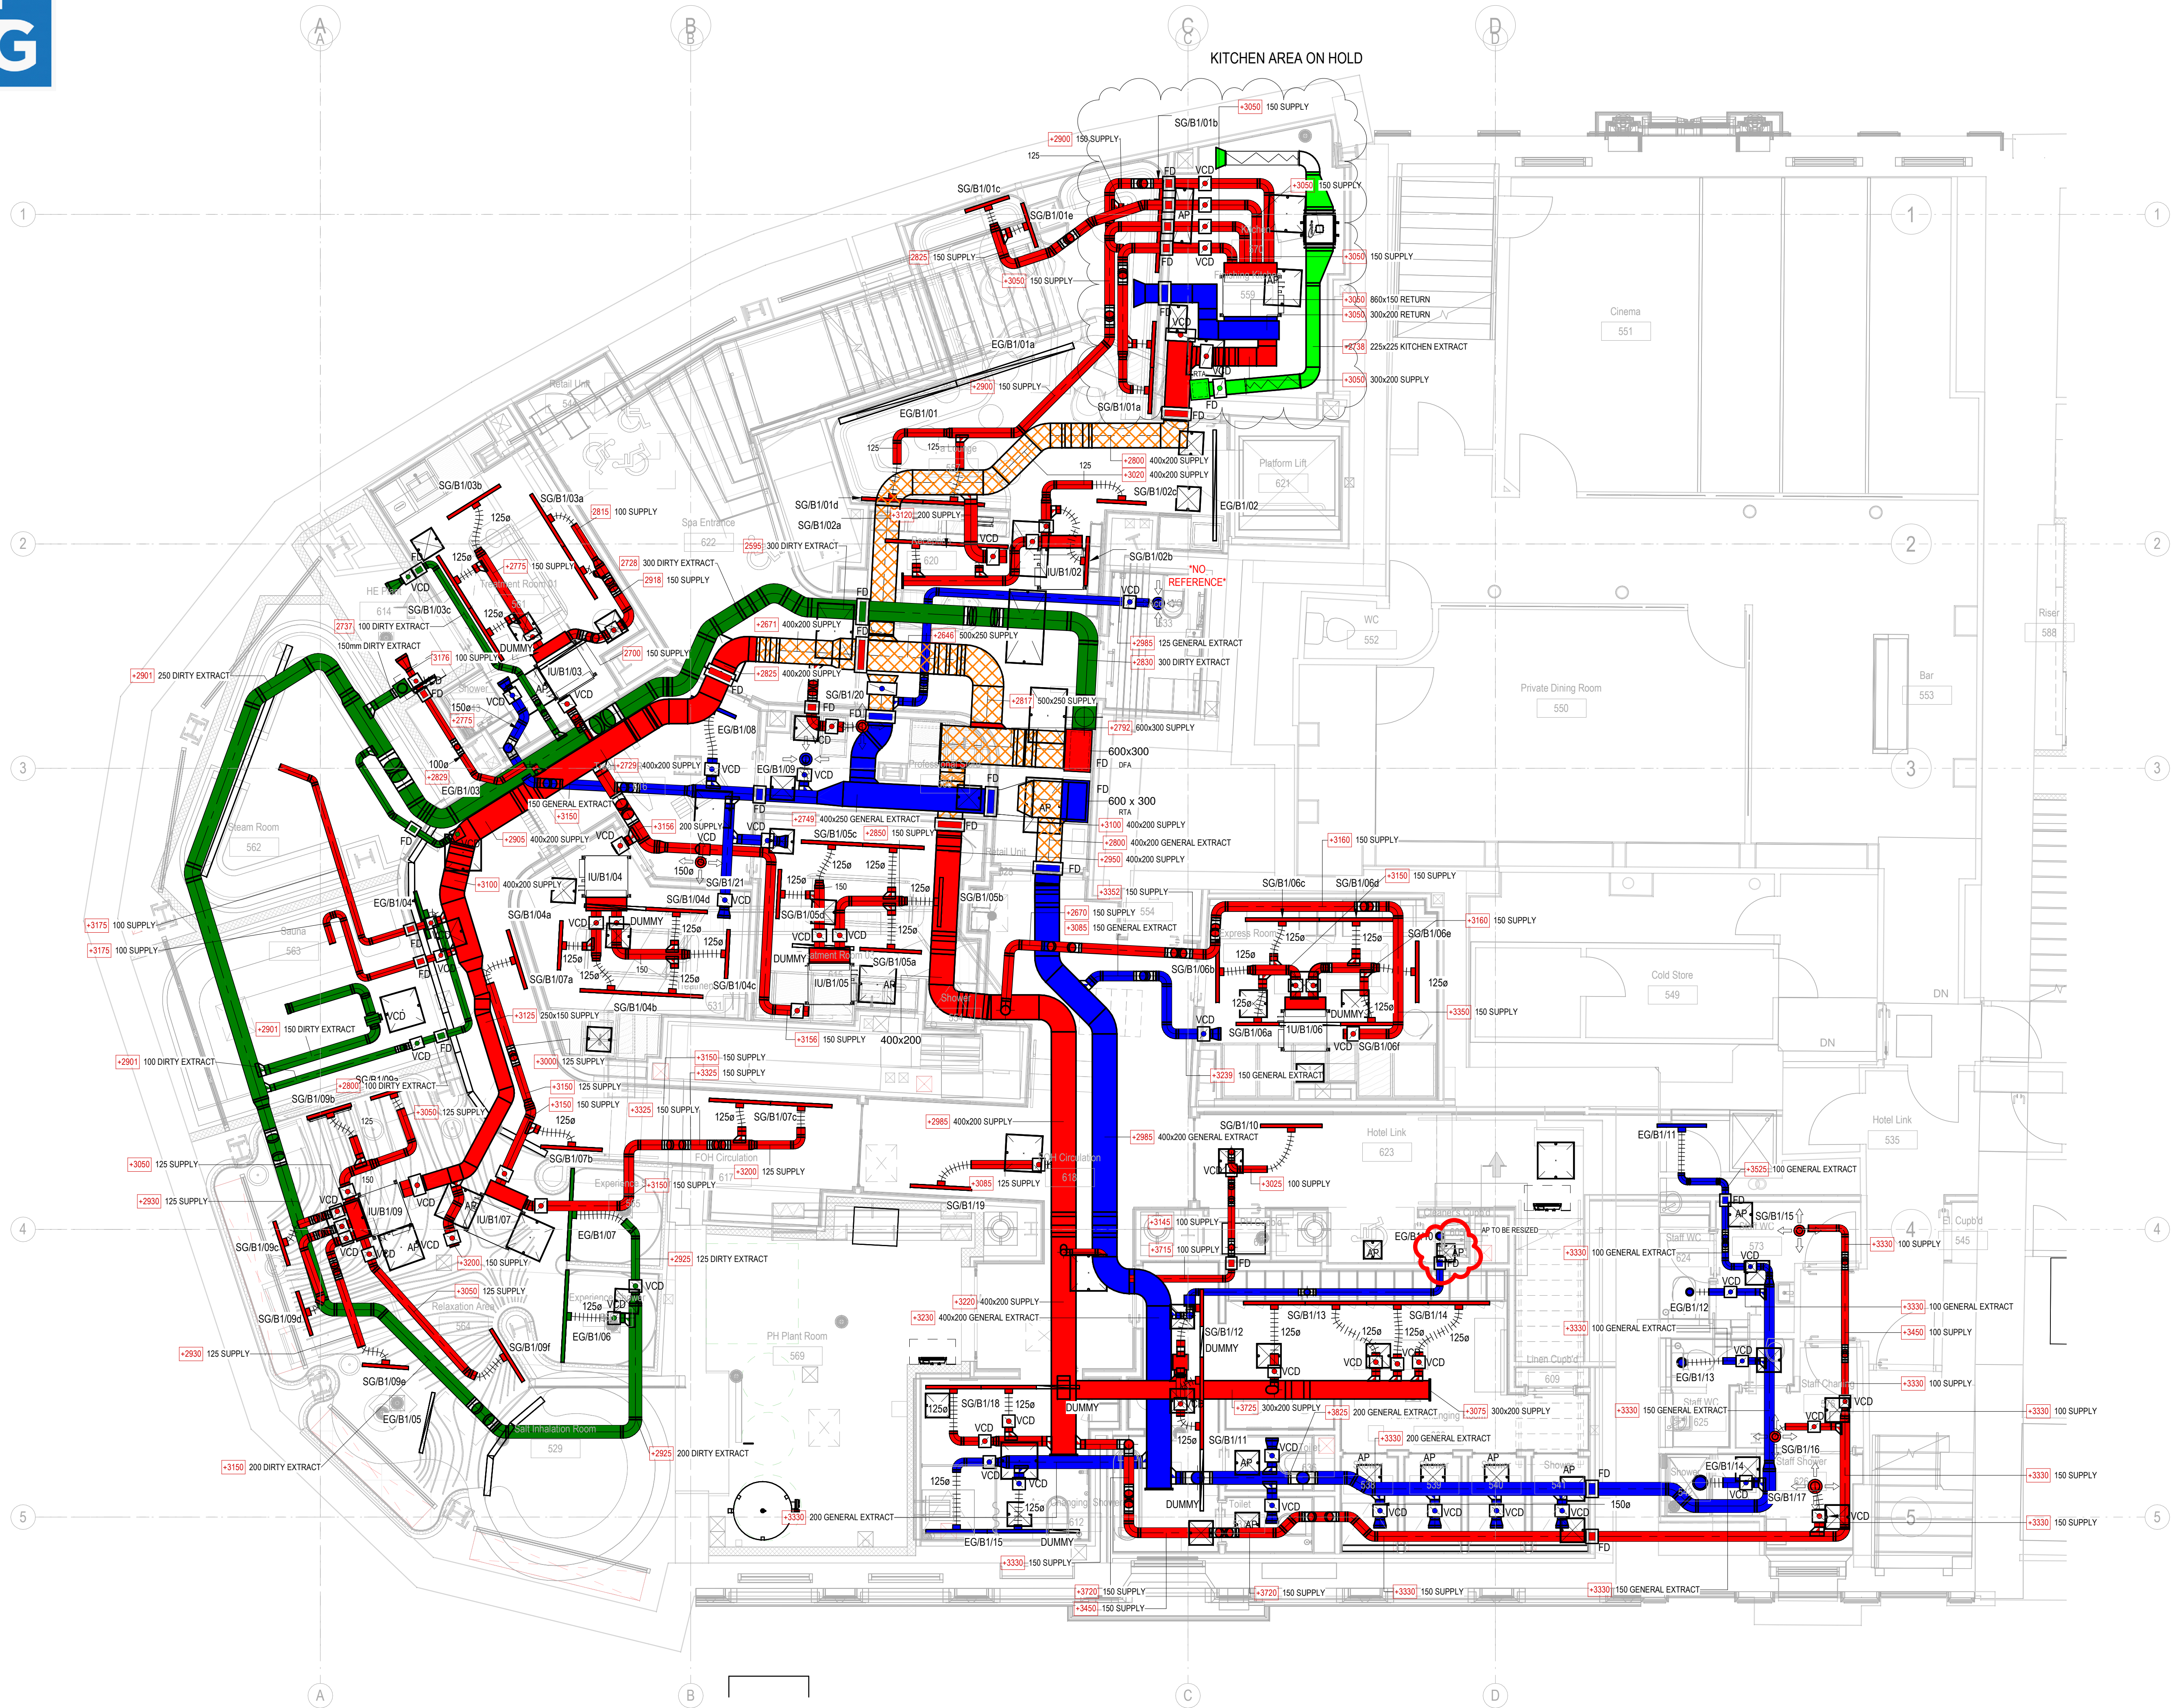

P01	ISSUED FOR APPROVAL	23.06.2021	KEM	FGM	OKD
REV	DESCRIPTION	DATE	BY	CHKD	
REVISION SCHEDULE					
STATUS					
FOR APPROVAL					
PROJECT TITLE					
SPA@KSTH					
DRAWING TITLE					
BASEMENT LEVEL VENTILATION LAYOUT					
DRAWING NUMBER		REV	SIZE	SCALE	
THG-FGM-BS-B1-DR-M-570101		P01	A1	1 : 50	
DRAWN BY	DATE	CHECKED BY	DATE		
CM	23.06.2021	KEM	23.06.2021		