
 


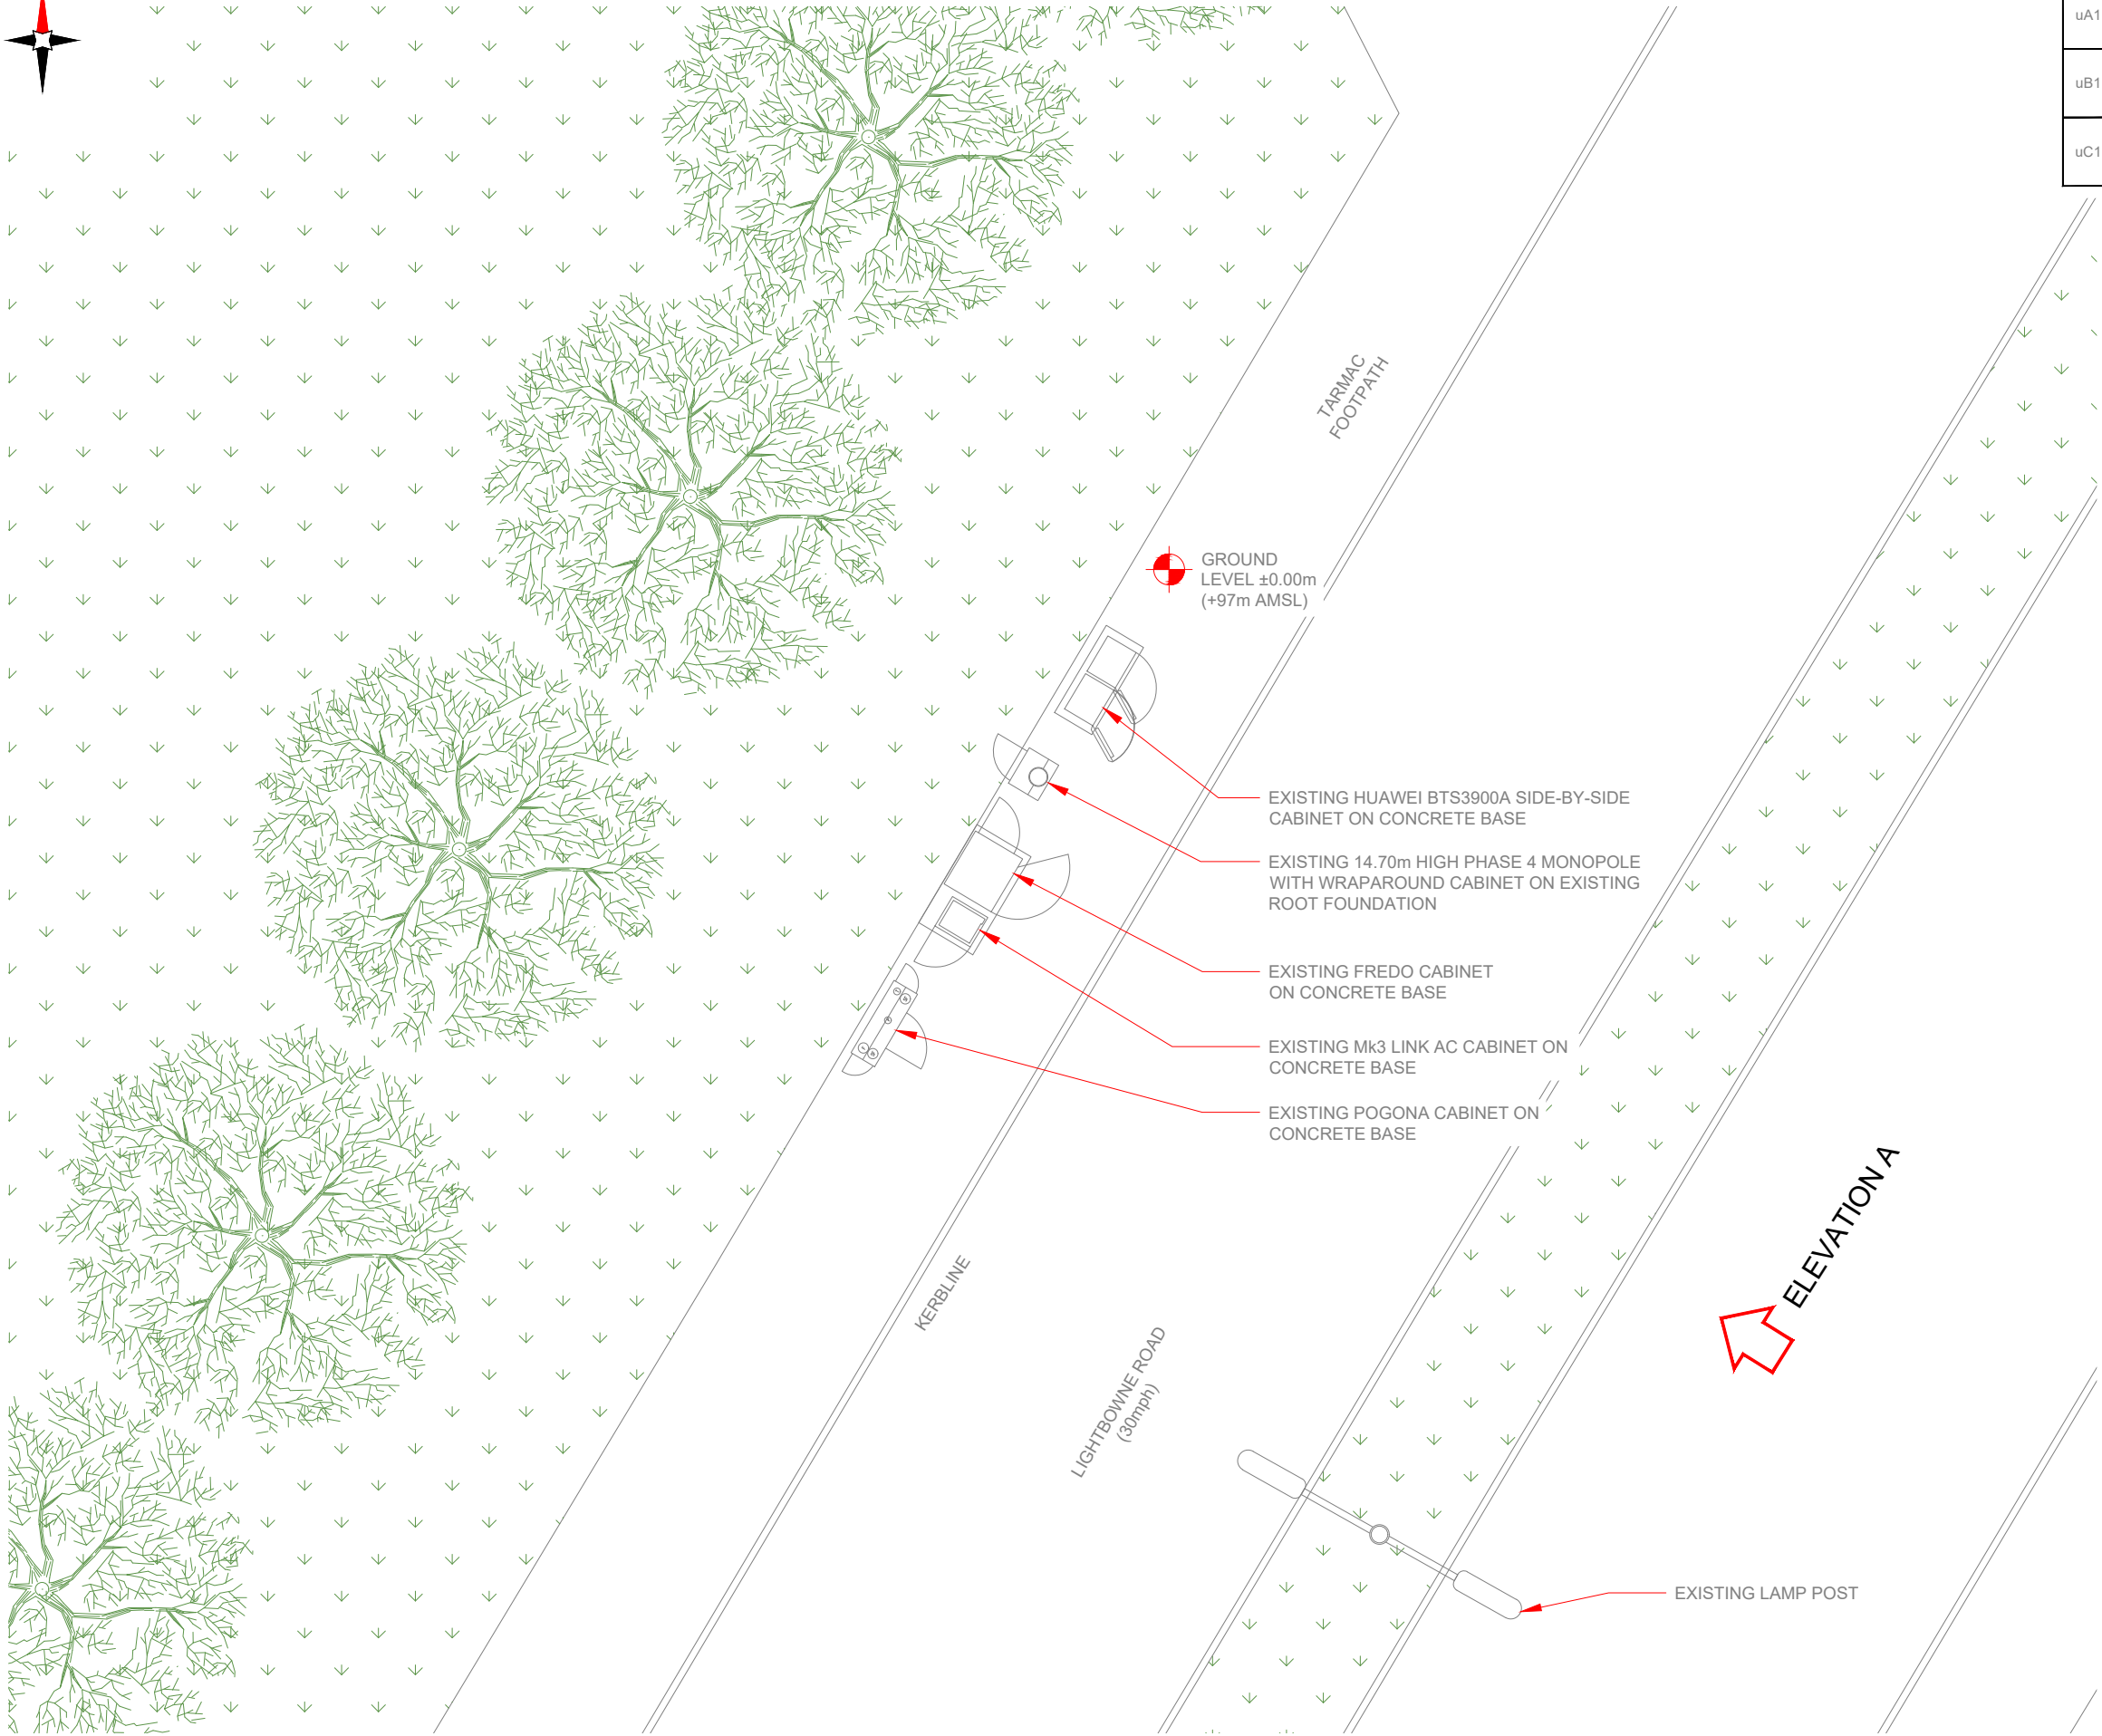

EXISTING SITE PLAN



3G Antenna ID	Existing 3G Bearing
uA1	330°
uB1	90°
uC1	210°

NOTES:	
1. ALL DIMENSIONS IN MM UNLESS OTHERWISE NOTED.	

Master:	MBNL / EE / H3G:	Project:	Purpose of Issue:	Issue:
M001	H3G	UNILATERAL	Planning	A
Date:	26/11/2021	Revision / Upgrade Description:		
Drawn:	K. Soper	First Issue		
Checked:	T. Clifford	ACQ		
Approved:	M. Venner			



Hutchison 3G UK Limited
Star House, 20 Grenfell Road
Maidenhead, SL6 1EH
Tel: 01628 765 000
Fax: 01628 765 001

H3G Base Station Information line:
0845 6043000
Available 8am-8pm Monday to Friday


**BEACONCOMMS**

UNIT E3 PITTS CLEAVE INDUSTRIAL ESTATE, TAVISTOCK, DEVON, PL19 0PW
sales@beaconcomms.co.uk Tel: +44 (0)1822 610610

Site Name:	LIGHTBOWNE ROAD DNS		
Site ID:	981164		
Address:	MOSTON LIGHTBOWNE ROAD MOSTON MANCHESTER GREATER MANCHESTER M40 0FJ		
Title:	100 EXISTING SITE PLAN		
Project:	H3G UNILATERAL		
Purpose of Issue:	GENERAL ARRANGEMENT		
EE Cell ID:	MBNL Cell ID:	3UK Cell ID:	
51946	MAN010	M0234	
Master Drawing No:			Issue:
981164_MAN010_51946_M0234_M001			A

3G Antenna ID	Existing 3G Bearing
uA1	330°
uB1	90°
uC1	210°

NOTES:	
1. ALL DIMENSIONS IN MM UNLESS OTHERWISE NOTED.	

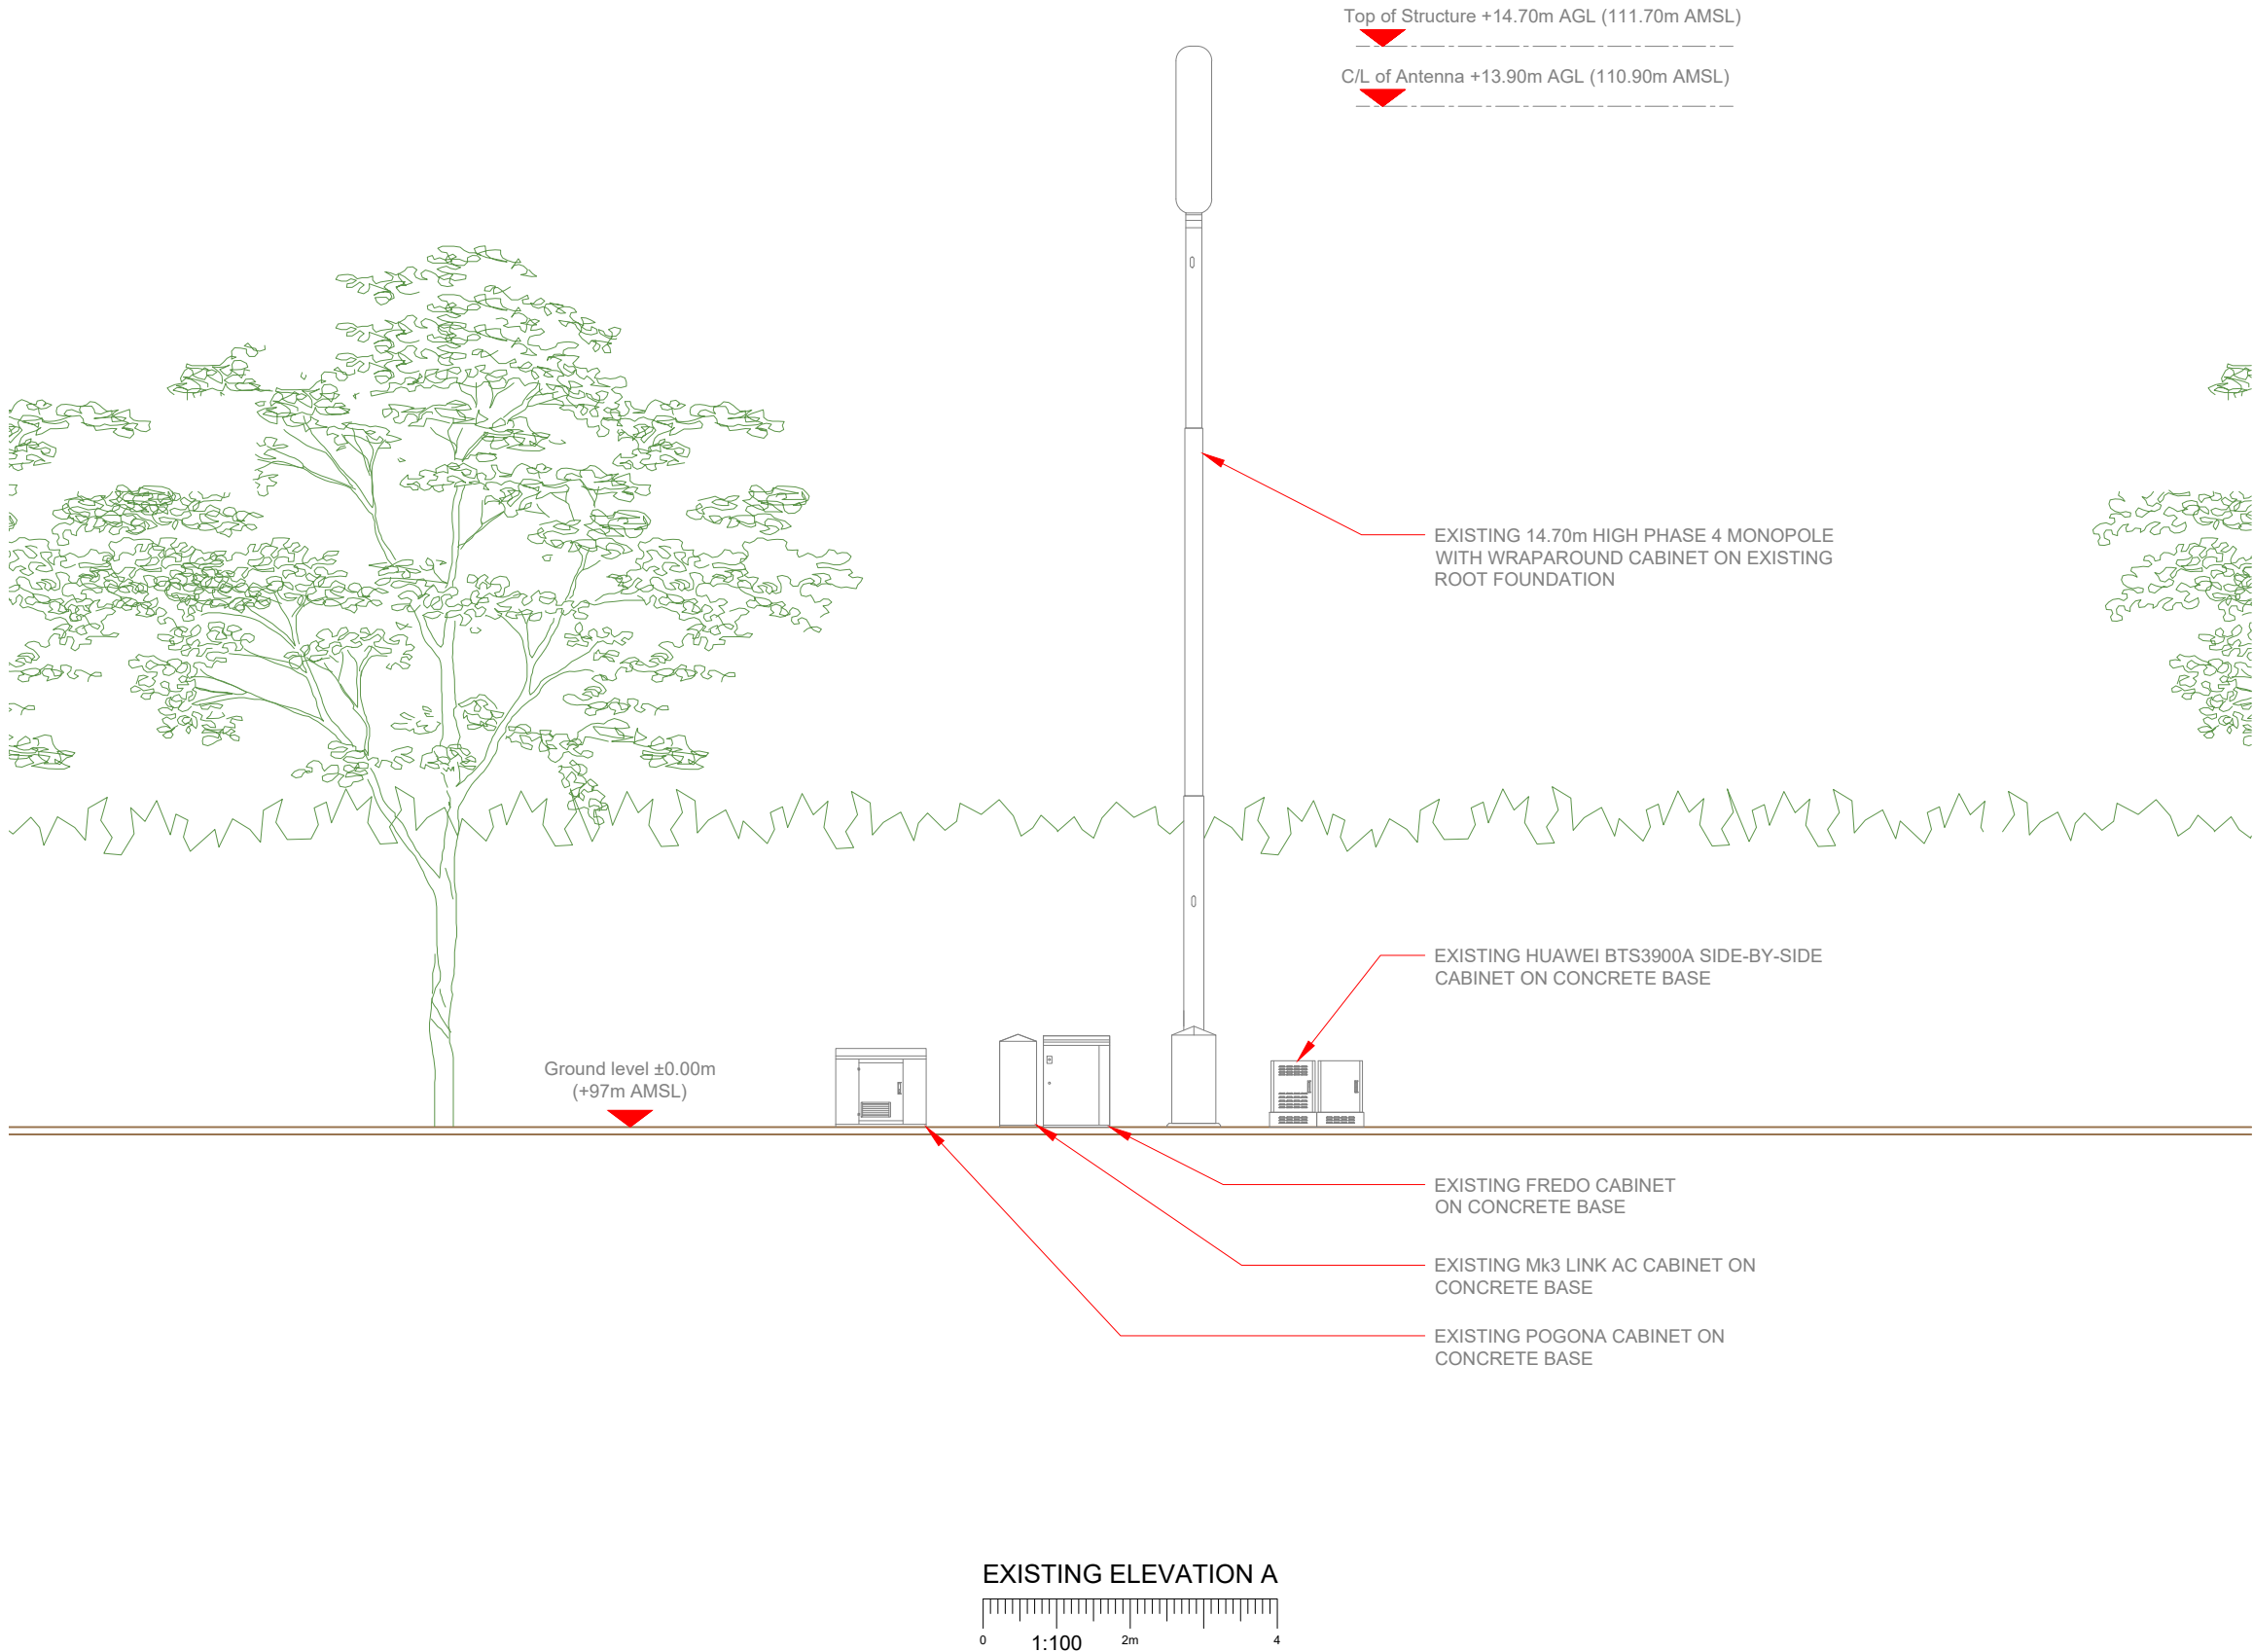

Hutchison 3G UK Limited
Star House, 20 Grenfell Road
Maidenhead, SL6 1EH
Tel: 01628 765 000
Fax: 01628 765 001

H3G Base Station Information line:
0845 6043000
Available 8am-8pm Monday to Friday

**BEACONCOMMS**

UNIT E3 PITTS CLEAVE INDUSTRIAL ESTATE, TAVISTOCK, DEVON, PL19 0PW
sales@beaconcomms.co.uk


Tel: +44 (0)1822 610610

Site Name:		LIGHTBOWNE ROAD DNS	
Site ID:		981164	
Address:		MOSTON LIGHTBOWNE ROAD MOSTON MANCHESTER GREATER MANCHESTER M40 0FJ	
Title:		150 EXISTING ELEVATION A	
Project:		H3G UNILATERAL	
Purpose of Issue:		GENERAL ARRANGEMENT	
EE Cell ID:	MBNL Cell ID:	3UK Cell ID:	
51946	MAN010	M0234	
Master Drawing No:			Issue:
981164_MAN010_51946_M0234_M001			A




Antenna Aperture ID	Proposed 4G/5G Bearing	Operator: Shared/ EE/H3G
A1	330°	H3G
A2	330°	EE/H3G
B1	90°	H3G
B2	90°	EE/H3G
C1	210°	H3G
C2	210°	EE/H3G

NOTES:
1. ALL DIMENSIONS IN MM UNLESS OTHERWISE NOTED.

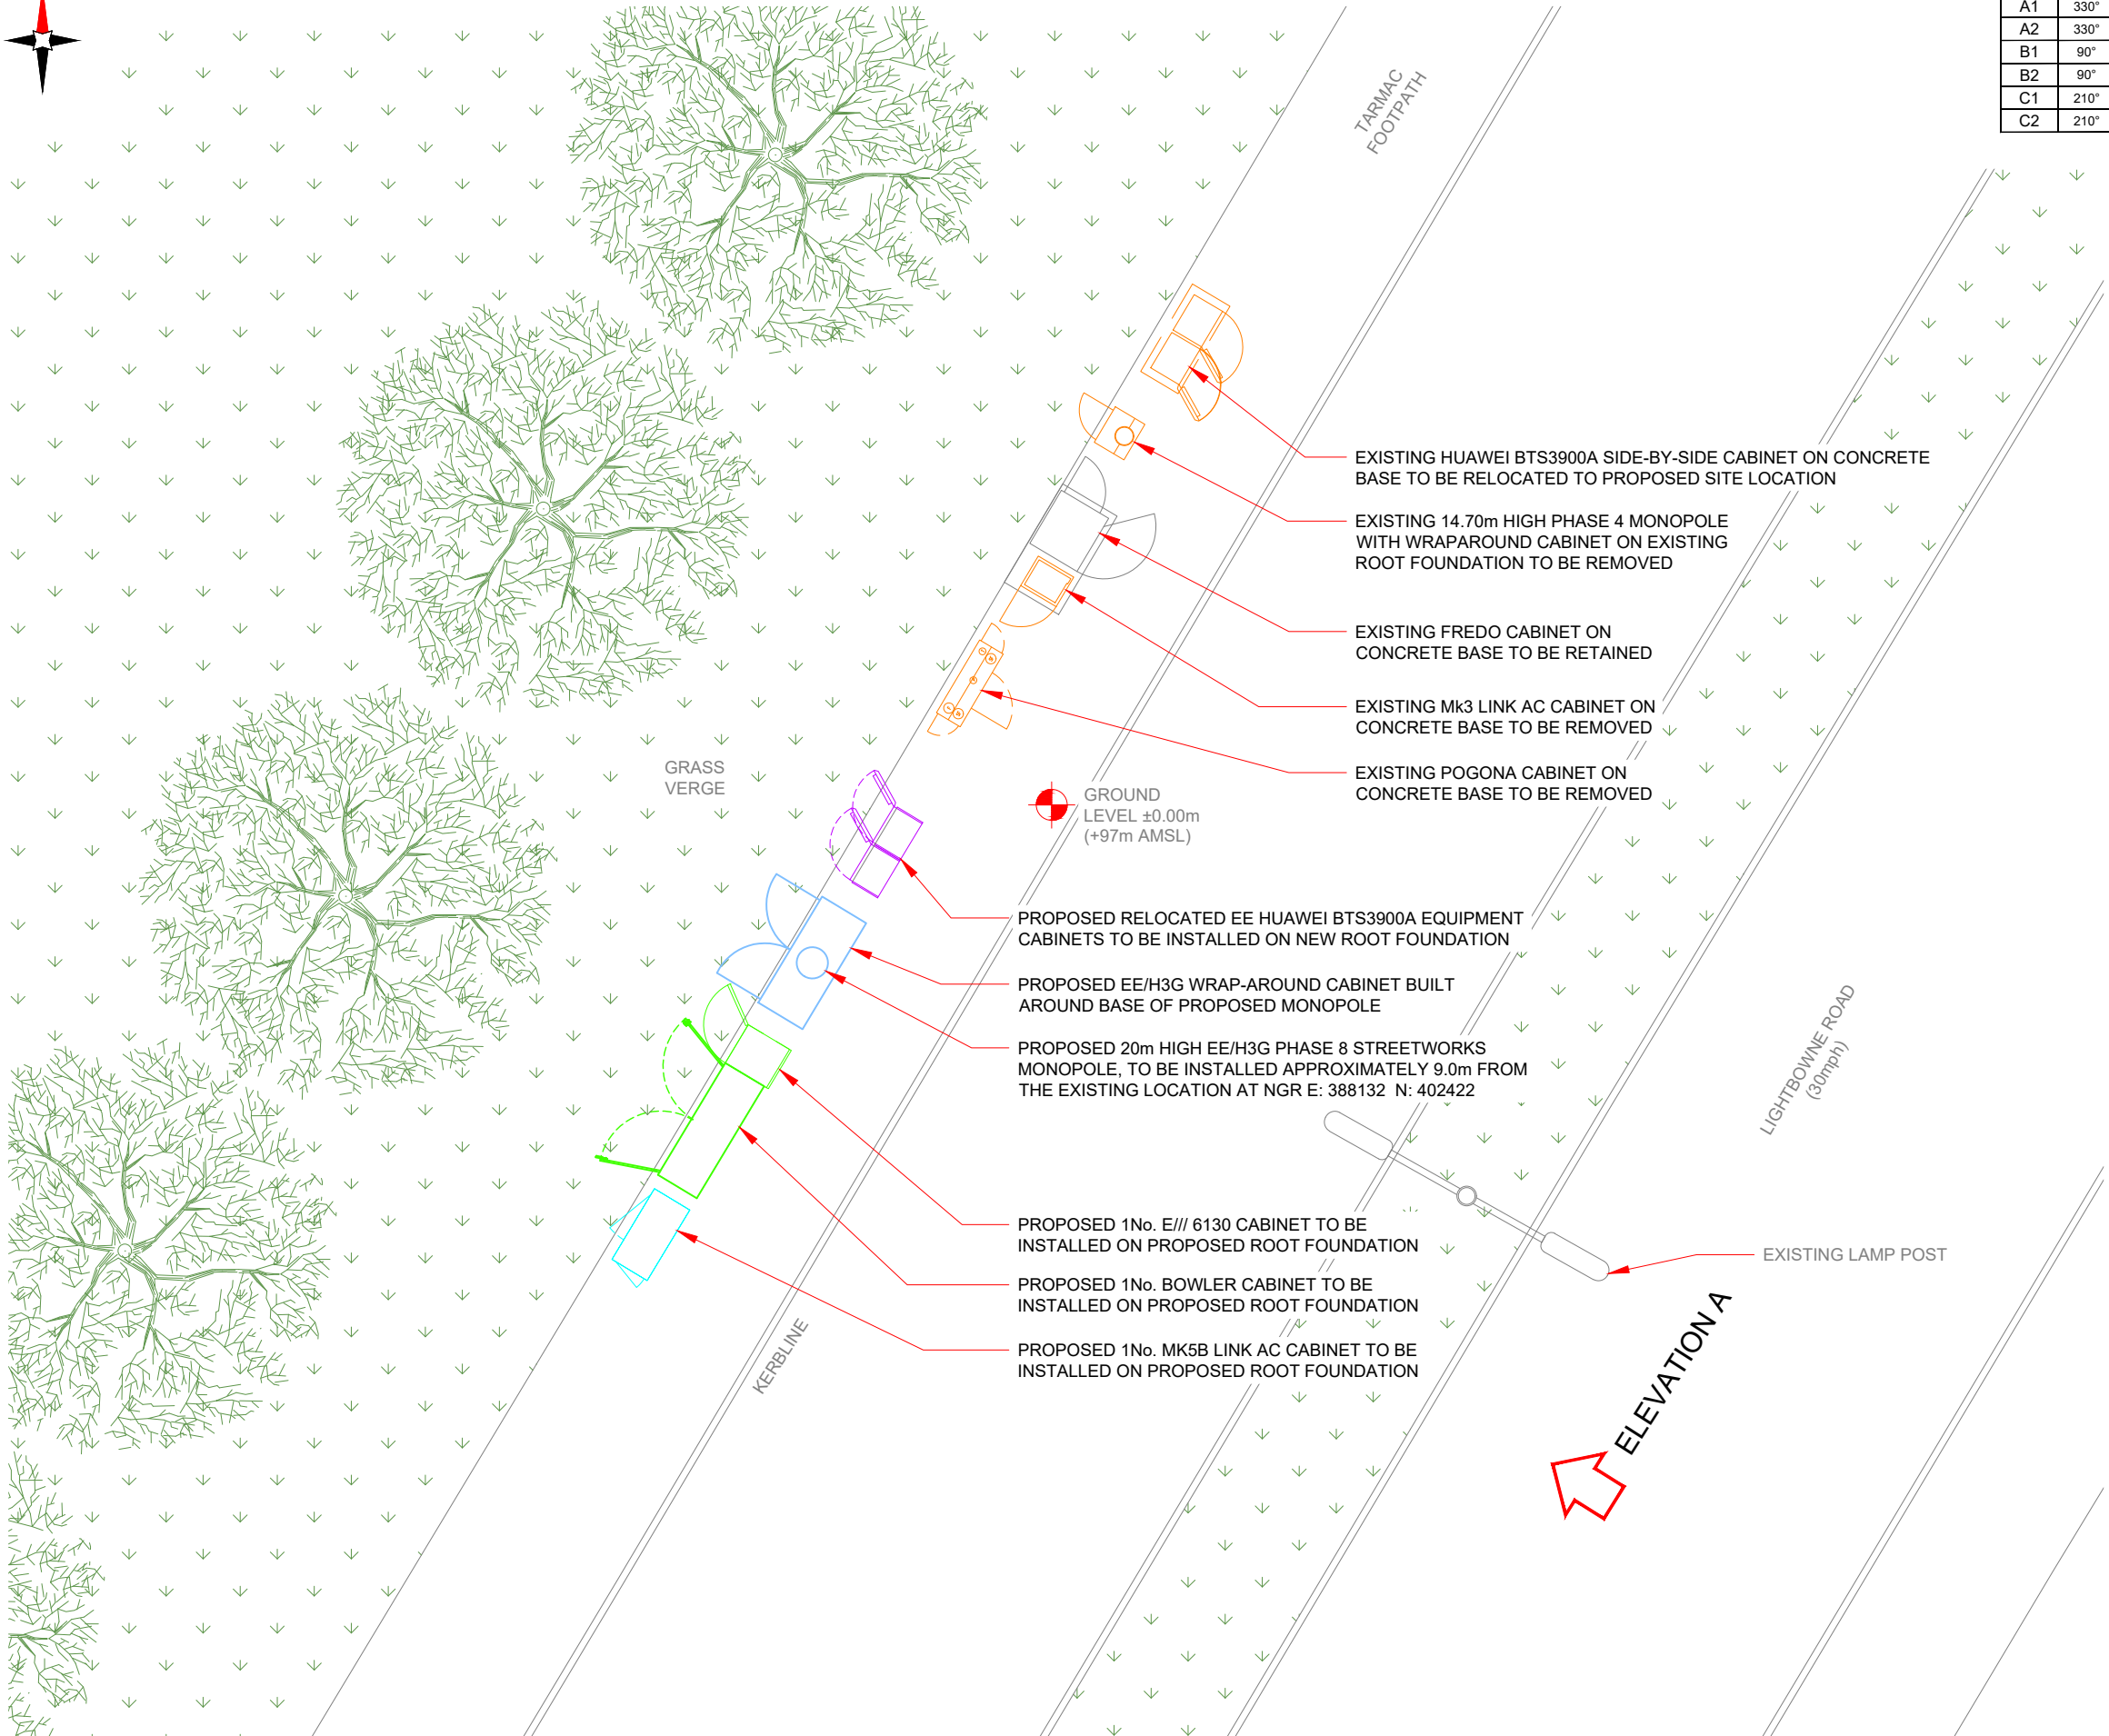

PROPOSED MAX CONFIGURATION SITE PLAN

 

Master:	MBNL / EE / H3G:	Project:	Purpose of Issue:	Issue:
M001	H3G	UNILATERAL	Planning	A
Date:	26/11/2021	Revision / Upgrade Description:		
Drawn:	K. Soper	First Issue		
Checked:	T. Clifford	ACQ		
Approved:	M. Venner			

Hutchison 3G UK Limited
Star House, 20 Grenfell Road
Maidenhead, SL6 1EH
Tel: 01628 765 000
Fax: 01628 765 001

H3G Base Station Information line:
0845 6043000
Available 8am-8pm Monday to Friday

UNIT E3 PITTS CLEAVE INDUSTRIAL ESTATE, TAVISTOCK, DEVON, PL19 0PW
sales@beaconcomms.co.uk

Tel: +44 (0)1822 610610

Site Name:		LIGHTBOWNE ROAD DNS	
Site ID:		981164	
Address:		MOSTON LIGHTBOWNE ROAD MOSTON MANCHESTER GREATER MANCHESTER M40 0FJ	
Title:		215 PROPOSED MAX CONFIGURATION SITE PLAN	
Project:		H3G UNILATERAL	
Purpose of Issue:		GENERAL ARRANGEMENT	
EE Cell ID:	51946	MBNL Cell ID:	MAN010
3UK Cell ID:	M0234		
Master Drawing No:			981164_MAN010_51946_M0234_M001
			Issue: A

TOP OF PROPOSED EE/H3G STREET POLE +20.00m AGL (+117.00m AMSL)

TOP OF PROPOSED H3G ANTENNAS +19.95m AGL (+116.95m AMSL)

C/L OF PROPOSED H3G ANTENNAS +19.55m AGL (+116.55m AMSL)

U/S OF PROPOSED H3G ANTENNAS +19.15m AGL (+116.15m AMSL)

TOP OF PROPOSED EE/H3G ANTENNAS +18.65m AGL (+115.65m AMSL)

C/L OF PROPOSED EE/H3G ANTENNAS +17.65m AGL (+114.65m AMSL)

U/S OF PROPOSED EE/H3G ANTENNAS +16.65m AGL (+113.65m AMSL)

Top of Structure +14.70m AGL (111.70m AMSL)

C/L of Antenna +13.90m AGL (110.90m AMSL)

PROPOSED 20m HIGH EE/H3G PHASE 8 STREETWORKS MONOPOLE,
TO BE INSTALLED APPROXIMATELY 9.0m FROM THE EXISTING
LOCATION AT NGR E: 388132 N: 402422

EXISTING 14.70m HIGH PHASE 4 MONOPOLE
WITH WRAPAROUND CABINET ON EXISTING
ROOT FOUNDATION TO BE REMOVED

PROPOSED 1No. BOWLER CABINET TO BE INSTALLED
ON PROPOSED ROOT FOUNDATION

PROPOSED 1No. MK5B LINK AC CABINET
TO BE INSTALLED ON PROPOSED ROOT
FOUNDATION

Ground level ±0.00m
(+97m AMSL)

PROPOSED 1No. E/// 6130 CABINET TO BE INSTALLED
ON PROPOSED ROOT FOUNDATION

PROPOSED EE/H3G WRAP-AROUND CABINET BUILT
AROUND BASE OF PROPOSED MONOPOLE

PROPOSED RELOCATED EE HUAWEI BTS3900A EQUIPMENT
CABINETS TO BE INSTALLED ON NEW ROOT FOUNDATION

 
EXISTING HUAWEI BTS3900A SIDE-BY-SIDE
CABINET ON CONCRETE BASE TO BE
RELOCATED TO PROPOSED SITE
LOCATION

EXISTING FREDO CABINET ON
CONCRETE BASE TO BE RETAINED

EXISTING Mk3 LINK AC CABINET ON
CONCRETE BASE TO BE REMOVED

EXISTING POGONA CABINET ON
CONCRETE BASE TO BE REMOVED

PROPOSED MAX CONFIGURATION ELEVATION



Antenna Aperture ID	Proposed 4G/5G Bearing	Operator: Shared/ EE/H3G
A1	330°	H3G
A2	330°	EE/H3G
B1	90°	H3G
B2	90°	EE/H3G
C1	210°	H3G
C2	210°	EE/H3G

NOTES:
1. ALL DIMENSIONS IN MM UNLESS OTHERWISE NOTED.

Master:	MBNL / EE / H3G:	Project:	Purpose of Issue:	Issue:
M001	H3G	UNILATERAL	Planning	A
Date:	26/11/2021	Revision / Upgrade Description:		
Drawn:	K. Soper	First Issue		
Checked:	T. Clifford			
Approved:	M. Venner	ACQ		



Hutchison 3G UK Limited
Star House, 20 Grenfell Road
Maidenhead, SL6 1EH
Tel: 01628 765 000
Fax: 01628 765 001

H3G Base Station Information line:
0845 6043000
Available 8am-8pm Monday to Friday

BEACONCOMMS

UNIT E3 PITTS CLEAVE INDUSTRIAL ESTATE, TAVISTOCK, DEVON, PL19 0PW
sales@beaconcomms.co.uk

Tel: +44 (0)1822 610610

Site Name:	LIGHTBOWNE ROAD DNS		
Site ID:	981164		
Address:	MOSTON LIGHTBOWNE ROAD MOSTON MANCHESTER GREATER MANCHESTER M40 0FJ		
Title:	265 PROPOSED MAX CONFIGURATION ELEVATION		
Project:	H3G UNILATERAL		
Purpose of Issue:	GENERAL ARRANGEMENT		
EE Cell ID:	MBNL Cell ID:	3UK Cell ID:	
51946	MAN010	M0234	
Master Drawing No:			Issue:
981164_MAN010_51946_M0234_M001			A