


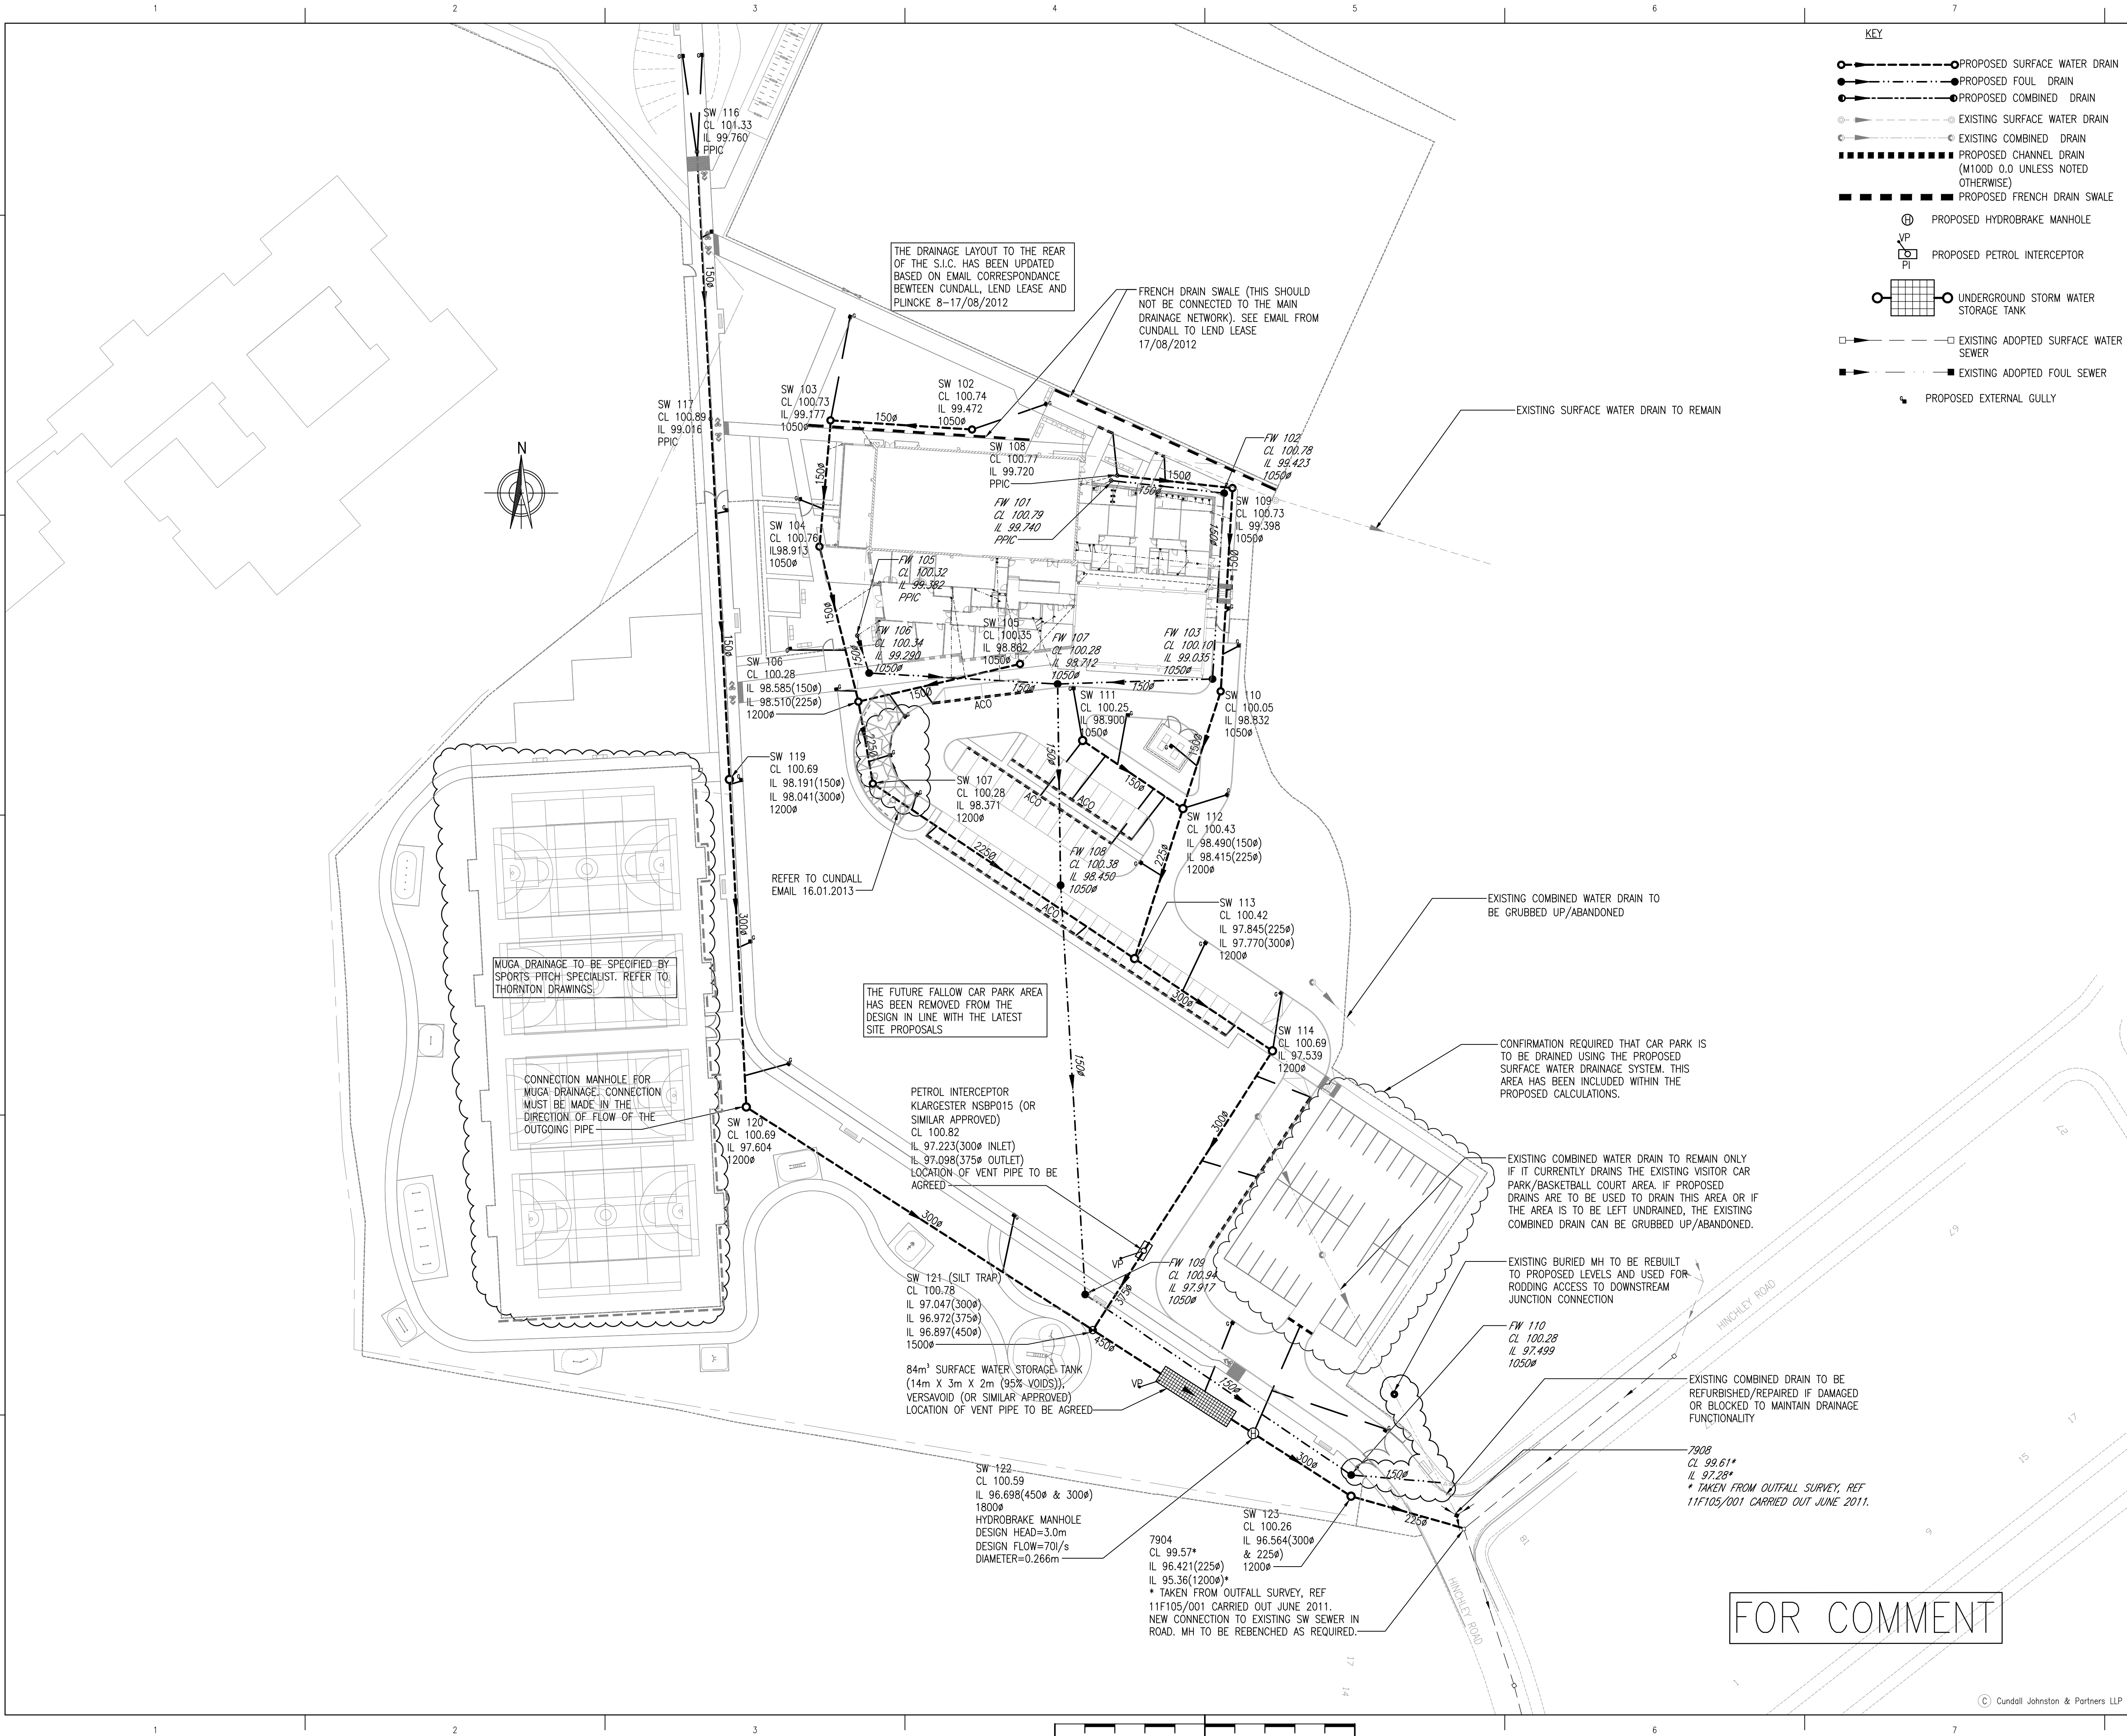

1001579

A1

Based on Architects Drg No.
Structural Drg No.
Survey Drg No.
Other Drg No.
Other Drg No.

Rev
Rev
Rev
Rev
Rev

DO NOT SCALE FROM THIS DRAWING

Notes

1. EXISTING DRAINAGE LOCATIONS, SIZES AND LEVELS ARE TAKEN FROM UNITED UTILITIES RECORDS AND SITE SURVEYS AND SHOULD BE CONFIRMED BY THE CONTRACTOR BEFORE DRAINAGE CONSTRUCTION COMMENCES ON SITE.

2. DRAWING TO BE READ IN CONJUNCTION WITH CIVIL ENGINEERING SPECIFICATION.

3. EXTERNAL GULLY LOCATIONS AND CHANNEL DRAINS ARE BASED ON SOUTHERN MASTERPLAN LEVELS ISSUED BY PLINCKE 20/11/2012 AND ARE SUBJECT TO CHANGE UPON RECEIPT OF FORMAL CONSTRUCTION ISSUE LEVELS.

4. ALL CHANNEL DRAINS REQUIRE A SUMP UNIT AT THE OUTLET.

5. GREASE TRAP(S) NOT SHOWN.

6. DRAINAGE LOCATIONS AND SIZES SUBJECT TO CHANGE FOLLOWING CONFIRMATION OF FINAL LEVELS, RWP LOCATIONS AND POP-UP LOCATIONS.

7. THIS DRAWING WAS CREATED USING THE PLINCKE SITE LAYOUT ISSUED 20-11-2012 BY EMAIL.

8. THIS DRAWING SHOULD BE READ IN CONJUNCTION WITH DRAWING 1045-PROPOSED SPORTS & INCLUSION UNDERSLAB DRAINAGE LAYOUT.

9. MANHOLE DIMENSIONS FOR ACCESS AND MAINTENANCE REQUIREMENTS IN ACCORDANCE WITH BS EN 752:2008 AND BS EN 476:2011.

D	05.03.13	REMOVED SW118, ACO CHANNELS TO MUGA PITCH & ASSOCIATED CONNECTIONS. REPLACED ACO ADJACENT DISABLED BAYS WITH 3 GULLIES (LEND LEASE EMAIL 15.02.13). UPDATED FOUL OUTFALL LAYOUT (CUNDALL EMAIL 14.01.13).	JDH	DE	GC
C	23.11.12	REVISED FOUL & SURFACE WATER LAYOUT FOR HAUL ROAD TRAFFIC. UPDATED DRAINAGE LEVELS & GULLY/CHANNEL LOCATIONS BASED ON PLINCKE LAYOUT 20/11/2012. EXTERNAL SIC DRAINAGE UPDATED BASED ON LEND LEASE CORRESPONDANCE 8-17/08/2012	JDH	RK	GC
B	22.07.11	REVISED ALL FOUL AND SURFACE WATER INFORMATION TO LATEST SITE LAYOUT AND DESIGN. ATTENUATION VOLUME SIGNIFICANTLY REDUCED.	JDH	DE	GC
A	20.07.11	SKETCH INTERIM ISSUE	JDH	CR	GC
-	24.12.10	SKETCH ISSUE	JDH	GC	GC

Issue	Date	Description	By	Chkd	Verid

Project

CREATIVE AND MEDIA ACADEMY
VICTORIA ROAD EAST
MANCHESTER

Client

MANCHESTER
CITY COUNCIL

Architect

Aedas
Aedas Architects

Title

PROPOSED DRAINAGE LAYOUT
SOUTHERN SITE

Drawing No.

CU-DRG-52-1026

Issue.

D

Job No.

1001579

Scale

1:500

Drawing Status

FOR COMMENT

CUNDALL

Consulting Engineers

10th Floor, Portland Tower,
Portland Street,
Manchester. M1 3AH
Telephone: 0161 244 5660
Fax: 0161 200 1210
Website: www.cundall.com