


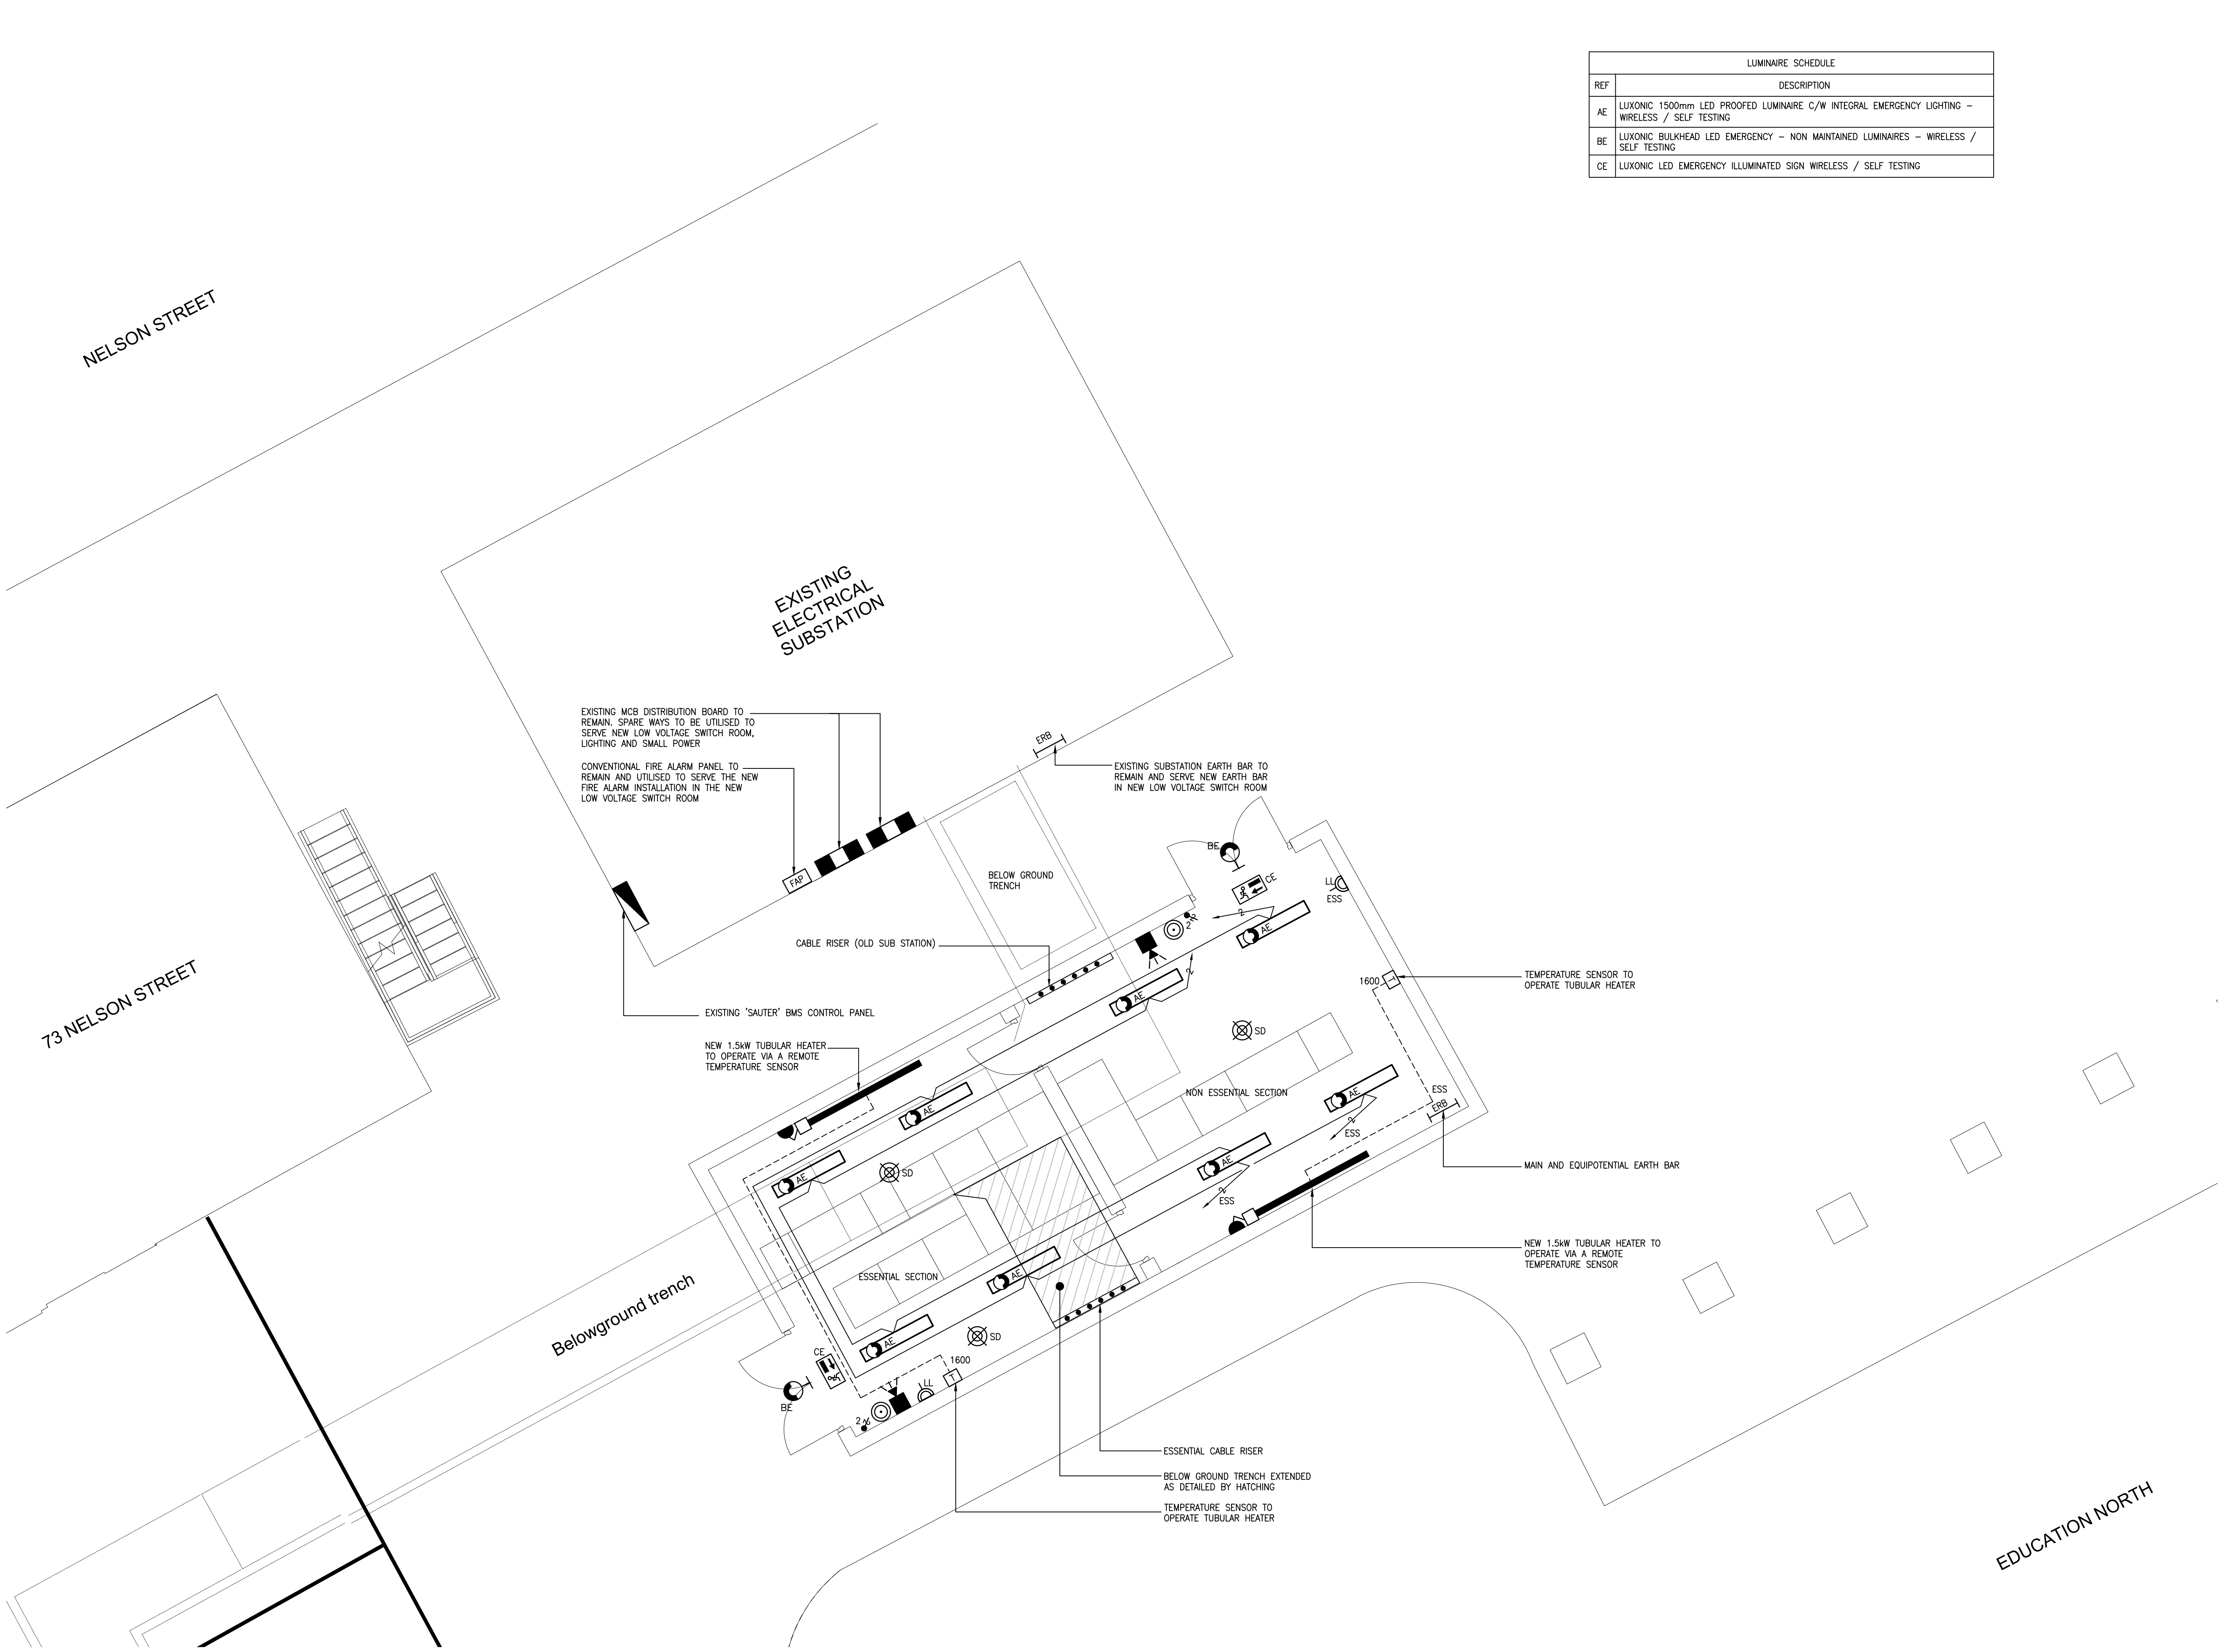

LUMINAIRE SCHEDULE	
REF	DESCRIPTION
AE	LUXONIC 1500mm LED PROOFED LUMINAIRE C/W INTEGRAL EMERGENCY LIGHTING – WIRELESS / SELF TESTING
BE	LUXONIC BULKHEAD LED EMERGENCY – NON MAINTAINED LUMINAIRES – WIRELESS / SELF TESTING
CE	LUXONIC LED EMERGENCY ILLUMINATED SIGN WIRELESS / SELF TESTING

- LEGEND
- A: LOAD BANK
B: MOBILE GENERATOR
C: GENERATOR INCOMER
D: LINKS TO BUSTIE 2
E: CABLEWAY
F: OUTGOING ESSENTIAL
G: CABLEWAY
H: CABLEWAY
I: OUTGOING NON-ESSENTIAL
J: CABLEWAY
K: BUSTIE 2
L: TX INCOMER
M: CABLEWAY
N: OUTGOING NON-ESSENTIAL
Z: BUSBAR LINK

- LEGEND
- FAP FIRE ALARM PANEL
SD SMOKE DETECTOR
SOUNDER C/W XENON
BREAKGLASS UNIT
2 GANG 2 WAY SWITCH
LUMINAIRE REF AE
LUMINAIRE REF BE
ILLUMINATED EXIT SIGN
TWIN SWITCHED SOCKET OUTLET
LOW LEVEL – 400mm AFFL
DISTRIBUTION BOARD
CONTROL PANEL
ERB EARTH REFERENCE BAR

P3	11.10.21	AMENDED IN ACCORDANCE WITH DESIGN TEAM MEETING	MPR
P2	08.09.21	AMENDED IN ACCORDANCE WITH DESIGN TEAM MEETING 05.08.21	MPR
P1	25.06.21	STAGE 3 ISSUE	MPR
REV	DATE	NOTE	ENG

ISSUE STAGE: STAGE 3

REDWORTH ASSOCIATES CONSULTING ENGINEERS

Ryefield House, 180 Highgate Road, Queensbury, Bradford, West Yorkshire, BD13 1DS
Tel: 01274 577171
E-Mail: admin@redworthassociates.co.uk
Web: www.redworthassociates.co.uk

The Incubator Building, 48 Grafton Street, Manchester, M13 9XX
Tel: 0161 606 7379

CLIENT:

PROJECT:
MANCHESTER ROYAL INFIRMARY
NELSON STREET SUBSTATION
LIFE CYCLE UPGRADE
LC1839

DRAWING TITLE:
ELECTRICAL SERVICES
AS PROPOSED

DESIGNED / DRAWN BY: MPR	SUITABILITY: S0	CHECKED: NB	APPROVED: CNA
REDWORTH PROJECT NUMBER: 3341	SCALE: 1:50 A1		REVISION DATE: 11.10.21
DRAWING NUMBER: 3341-RWA-XX-XX-DR-E-6006	REVISION: P3		