



THE COPYRIGHT OF THIS DRAWING IS HELD BY TeDS
(ELECTRICAL) LTD, AND NO REPRODUCTION IS ALLOWED
WITHOUT PRIOR WRITTEN AND SIGNED PERMISSION.

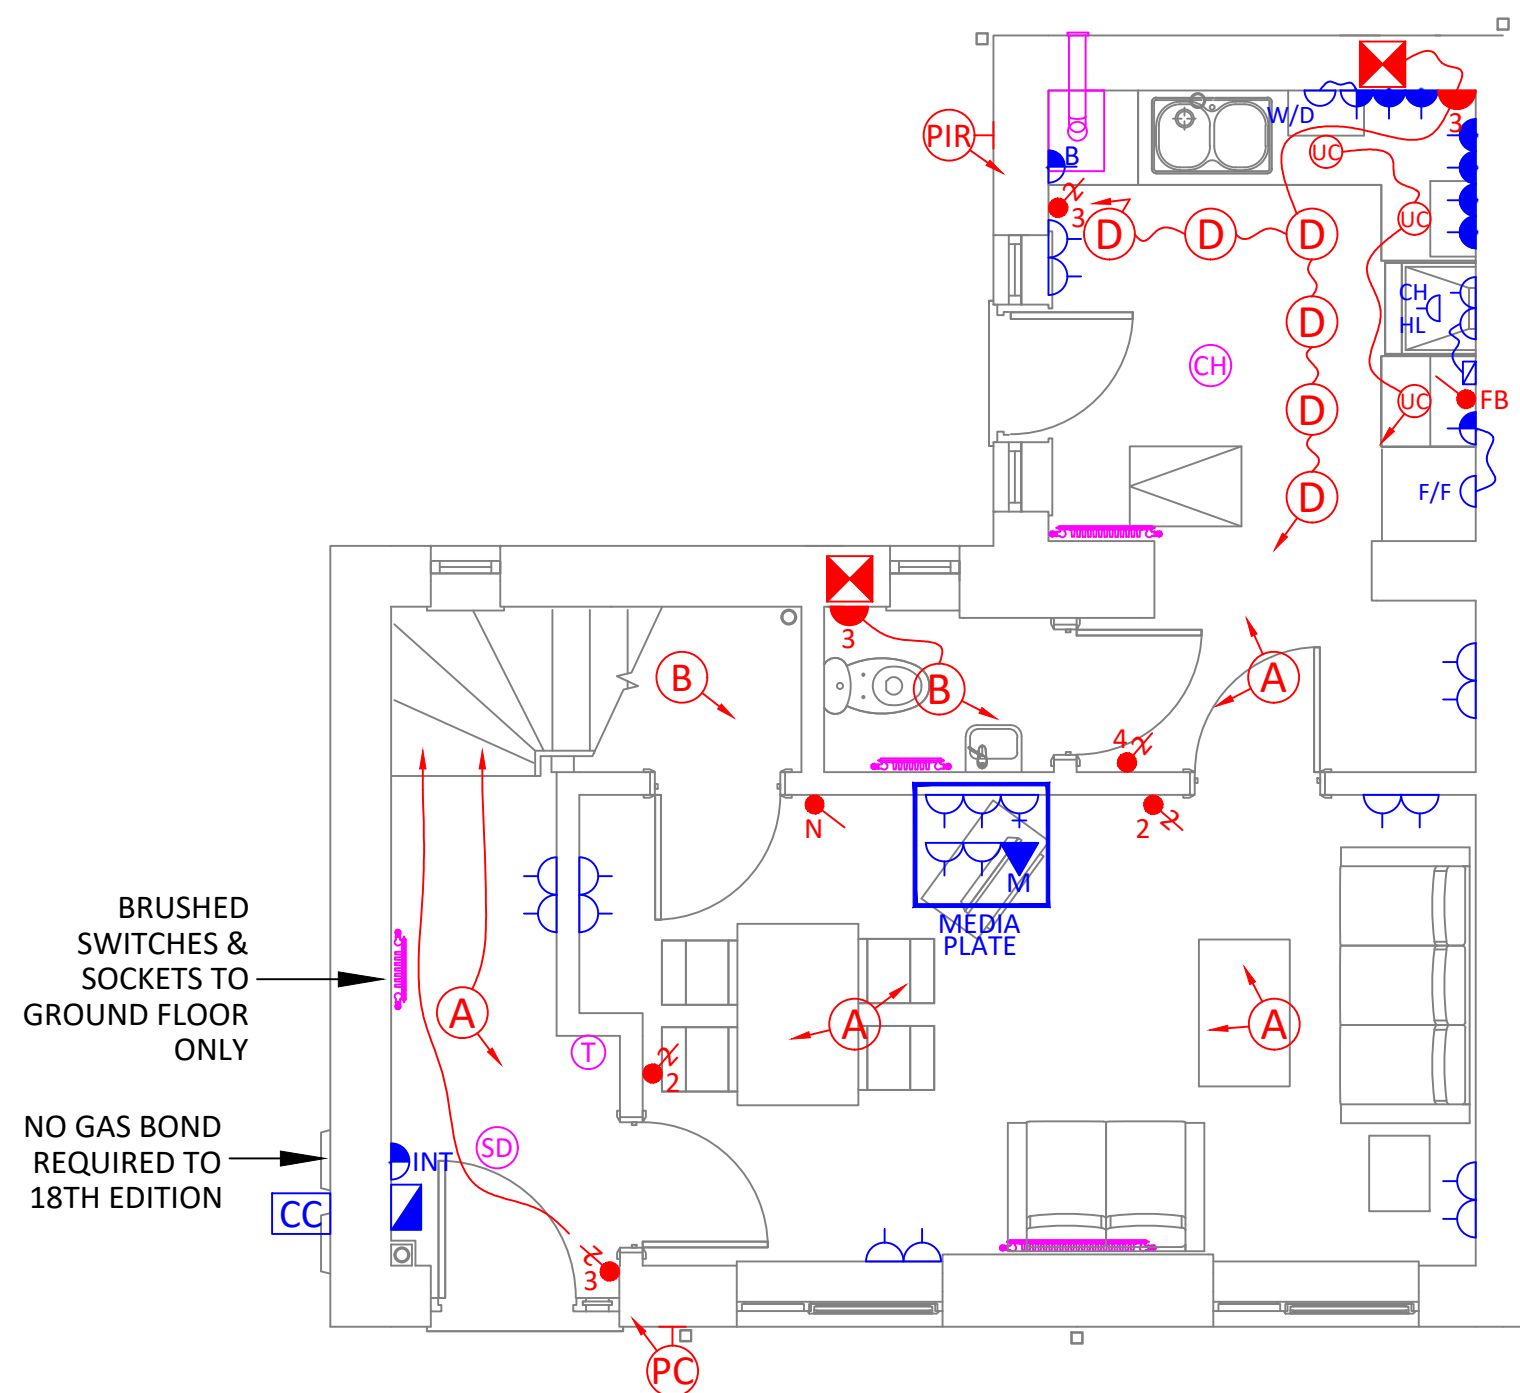


TYPE B GROUND FLOOR

PLOT 2,4,7,9


PLOT 1,3,8,10 (HANDED)

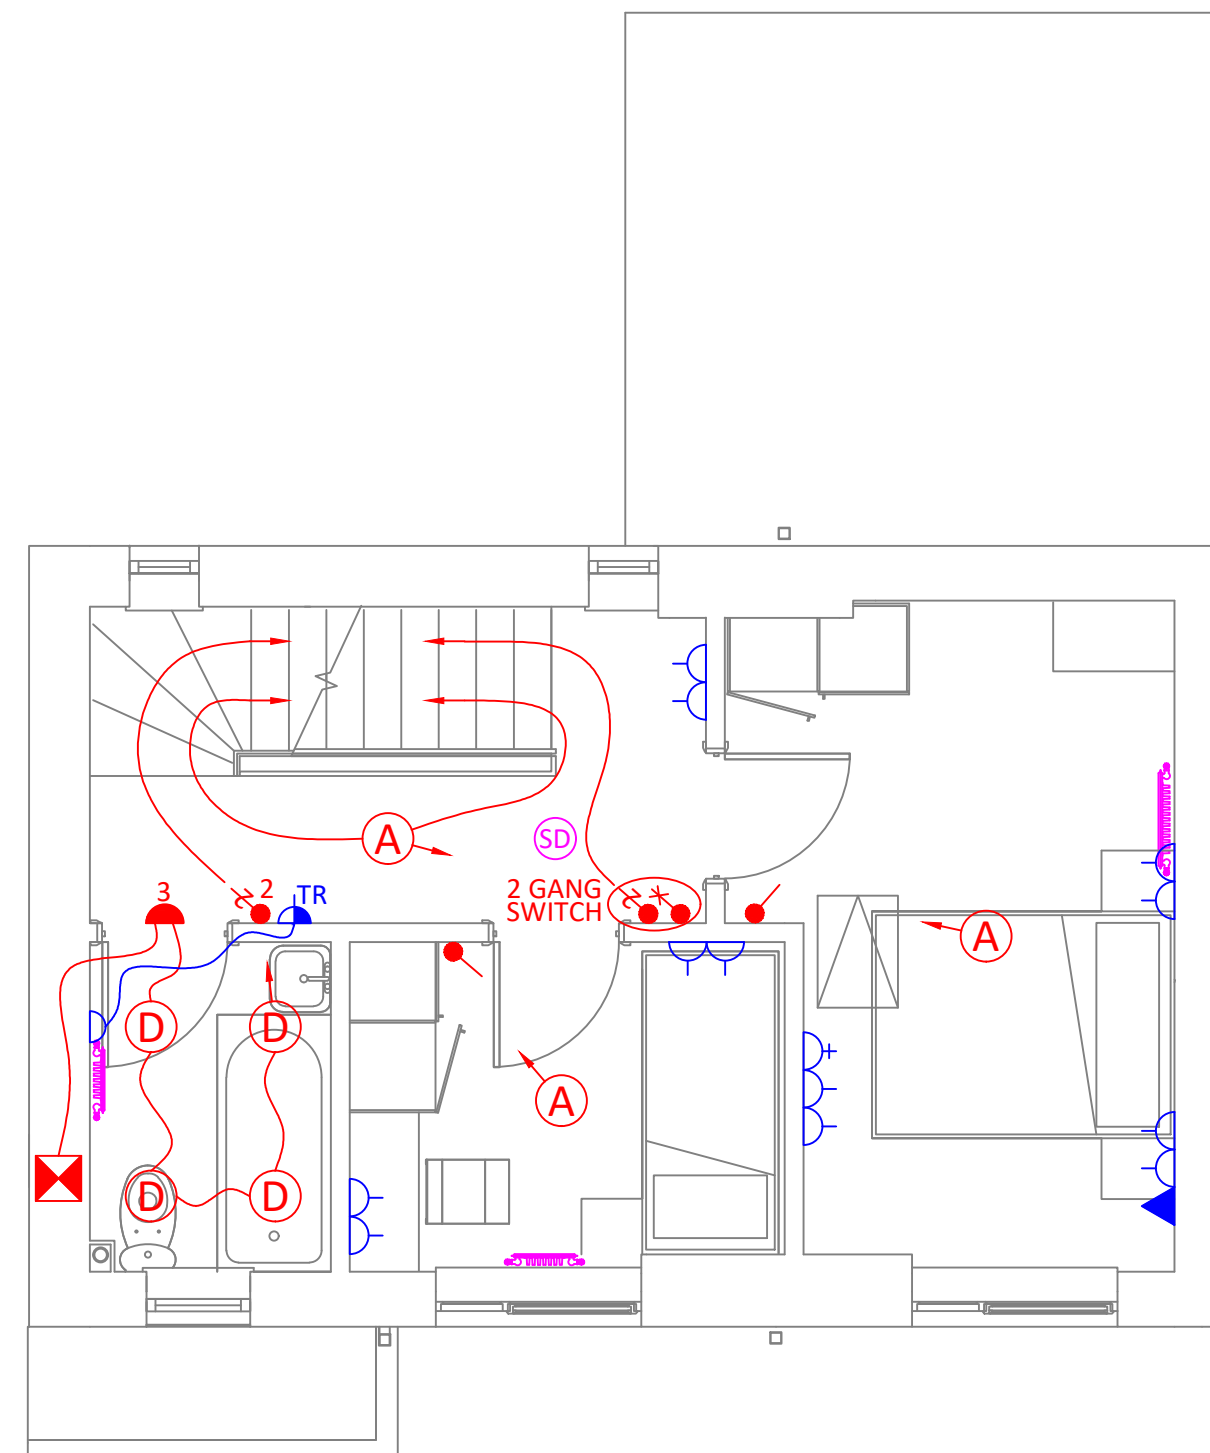

TYPE B FIRST FLOOR

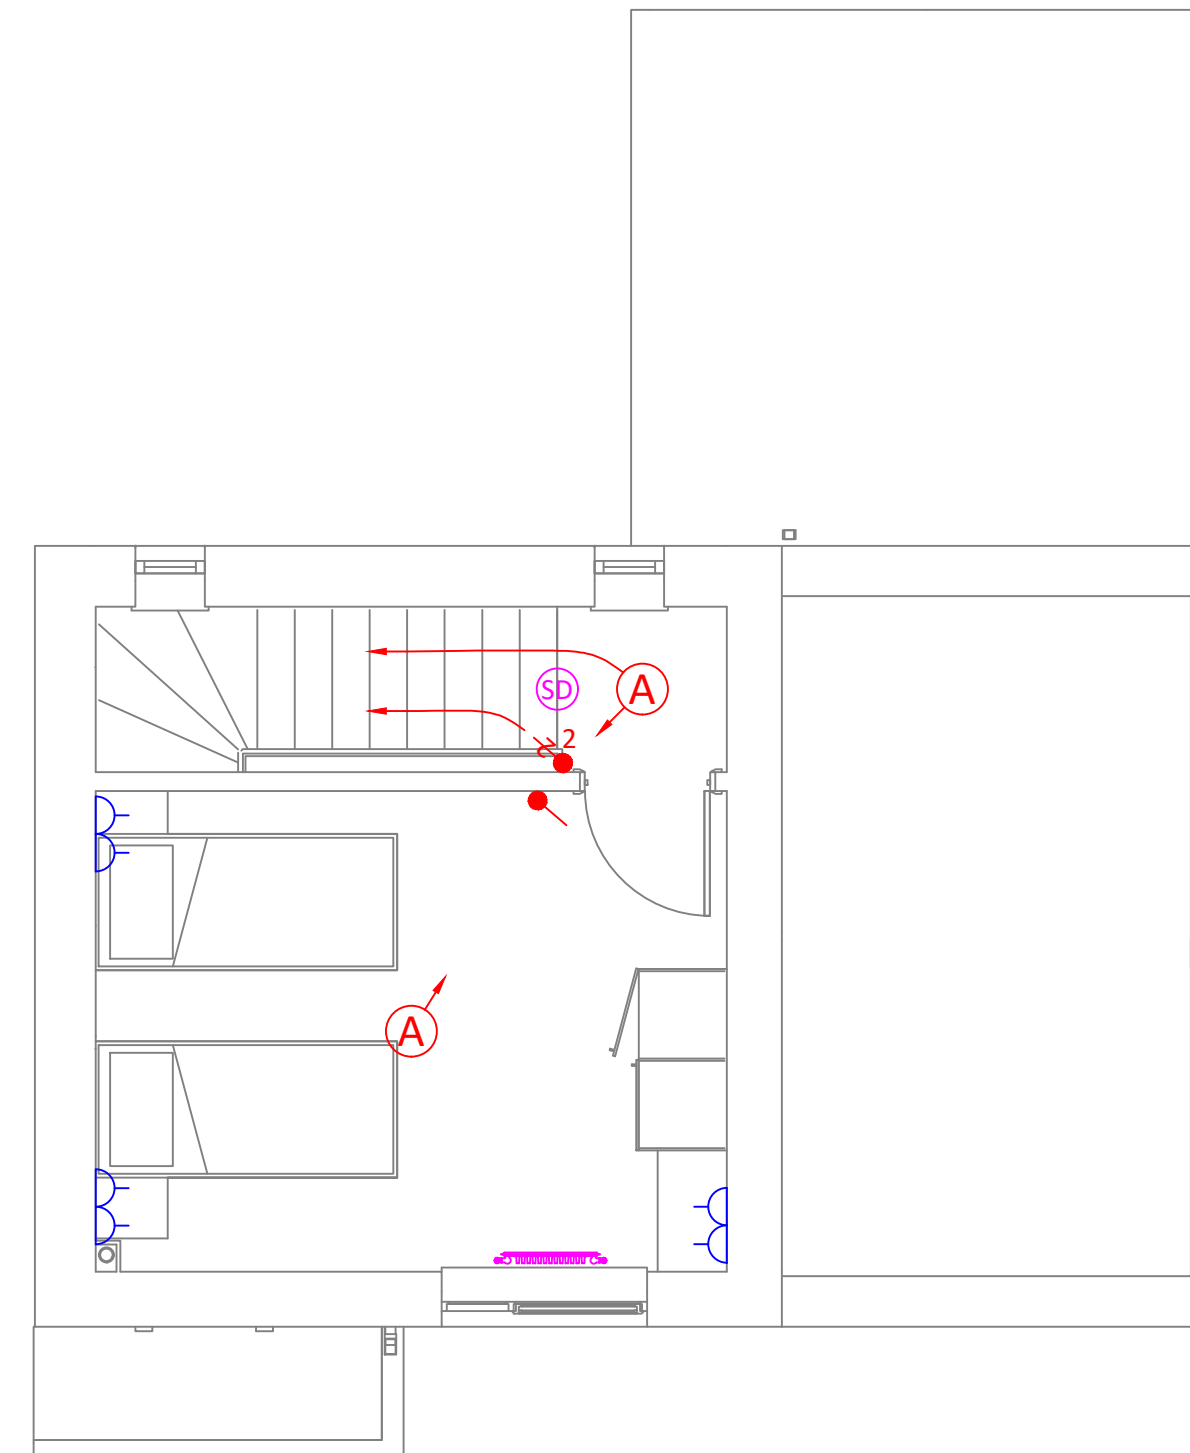

TYPE B SECOND FLOOR

 SYMBOL KEY & PROPOSED MATERIALS			
SYMBOL	DESCRIPTION	MANUFACTURER / CODE	PICTURE
	CONSUMER UNIT	WYLEX WNM1770	
	PENDANT LAMPHOLDER	CLICK PRC033	
	BATTEN LAMPHOLDER	CLICK PRC016	
	DOWNLIGHT (IP RATED IN WET AREAS)	ANSELL AEFRD/SC	
	UNDER CUPBOARD LIGHT	ANSELL ARLEDTL/CW LED LUMINAIRE 2W	
	WALL MOUNTED LUMINAIRE C/W PHOTO-CELL	ANSELL ALHL/PC/BL HALF LANTERN	
	WALL MOUNTED LUMINAIRE C/W PIR	ANSELL ALHL/PIR/BL HALF LANTERN	
	1 WAY LIGHT SWITCH (NUMBER DENOTES GANG)	CLICK VPSC011BK (GROUND FLOOR) CLICK POLAR PRW011-PRW013	
	2 WAY LIGHT SWITCH (NUMBER DENOTES GANG)	CLICK VPSC011BK (GROUND FLOOR) CLICK POLAR PRW011-PRW013	
	DENOTES NEON SWITCH	CLICK VPSC623BK (GROUND FLOOR) CLICK POLAR PRW023	
	INTERMEDIATE LIGHT SWITCH	CLICK VPSC025BK (GROUND FLOOR) CLICK POLAR PRW025	
	1G SWITCHED SOCKET	CLICK VPSC535BK (GROUND FLOOR) CLICK POLAR PRW035	
	2G SWITCHED SOCKET	CLICK VPSC036BK (GROUND FLOOR) CLICK POLAR PRW036	
	AS ABOVE BUT ABOVE WORKTOP	CLICK VPSC036BK (GROUND FLOOR) CLICK POLAR PRW036	
	2G SWITCHED USB SOCKET		
	1G UNSWITCHED SOCKET	CLICK POLAR PRW030	
	SWITCHED FUSED SPUR	CLICK VPSC651BK (GROUND FLOOR) CLICK POLAR PRW051	
	UNSWITCHED FUSED SPUR	CLICK VPSC750BK (GROUND FLOOR) CLICK POLAR PRW050	
	COOKER CONTROL UNIT (2G) CONTROLLING LOW LEVEL OUTLET & 1G SOCKET	CLICK VPSC204BK CCU & 13A SOCKET 45A SC	
	TV OUTLET	CLICK VPSC065BK (GROUND FLOOR) CLICK POLAR PRW065	
	BT OUTLET ('M' DENOTES MASTER)	CLICK VPSC125BK (GROUND FLOOR) CLICK POLAR PRW120 & PRW125	
	CAR CHARGING POINT	ROLEC WALLPOD - EVWP0020	
	SMOKE DETECTOR	AICO EI3016	
	COMBINED HEAT & CO DETECTOR	AICO EI3028	
	EXTRACT FAN	GREENWOOD AIRVAC CV2GIP	
	3 POLE FAN ISOLATOR	CLICK VPSC020BK (GROUND FLOOR) CLICK POLAR PRW020	

SITE PLAN, PLOTS & TYPES




MOUNTING HEIGHTS

<u>ITEM</u>	<u>HEIGHT</u>	<u>REFERENCE POINT</u>
CONSUMER UNIT	1350mm - 1450mm	TO CENTRE LINE OF MCB
LIGHT SWITCHES	1100mm	TO UNDERSIDE
GENERAL SOCKETS	450mm	TO UNDERSIDE
KITCHEN ACCESSORIES	1100mm	TO UNDERSIDE
BT OUTLET	450mm	TO UNDERSIDE
TV OUTLET	450mm	TO UNDERSIDE

ANNOTATIONS

CH	COOKER HOOD
DRY	DRYER
FB	FAN BOOST SWITCH
F/F	FRIDGE FREEZER
INT	INTRUDER ALARM
W/D	WASHER/DRYER
WM	WASHING MACHINE

TYPICAL ARRANGEMENTS

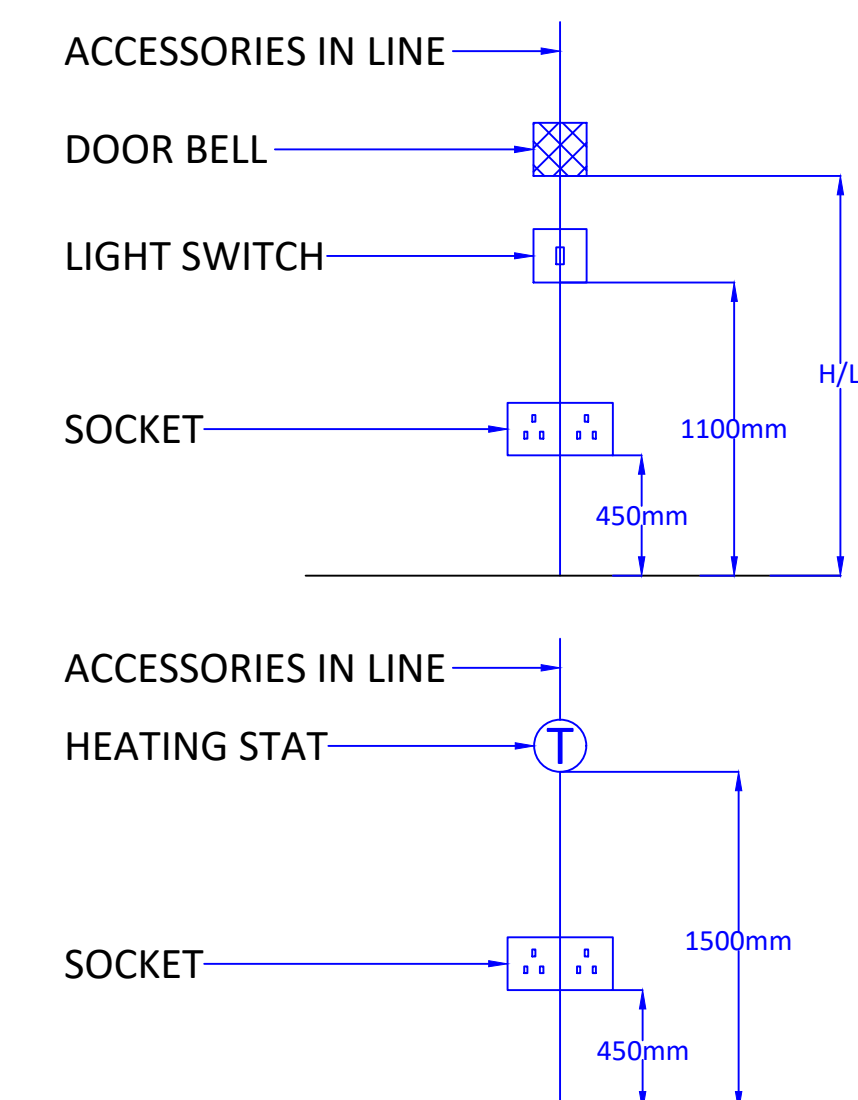

REV	DESCRIPTION	DATE
-	-	-
ISSUE		
PRELIMINARY		
CLIENT		
		
PROJECT		
GATE STREET		
TITLE		
HOUSE TYPE B ELECTRICAL INSTALLATION		
SCALE:	1:50@A1	DRAWN: SG
DATE:	MAR 2021	CHECKED: MM
DRAWING No. P0154/B		REV: -
		
TeDs (ELECTRICAL) LTD ST MARK'S HOUSE, 29 WEST STREET, DUKINFIELD, CHESHIRE, SK16 4PL TEL: 0161 330 7506 EMAIL : design@tedsltd.co.uk		