


Last saved by: OWNER(2020-12-21) Last Plotted: 2021-01-04
Filename: C:\USERS\OWNER\HURSTWOOD\FILESTORE - BOLTON PROJECTS\PROJECTS\C3435 - GRANADA STUDIOS OFFICES\02 MECHANICAL\04 DRAWINGS\003-FIRST-NINTH FLOOR - VENT DWG

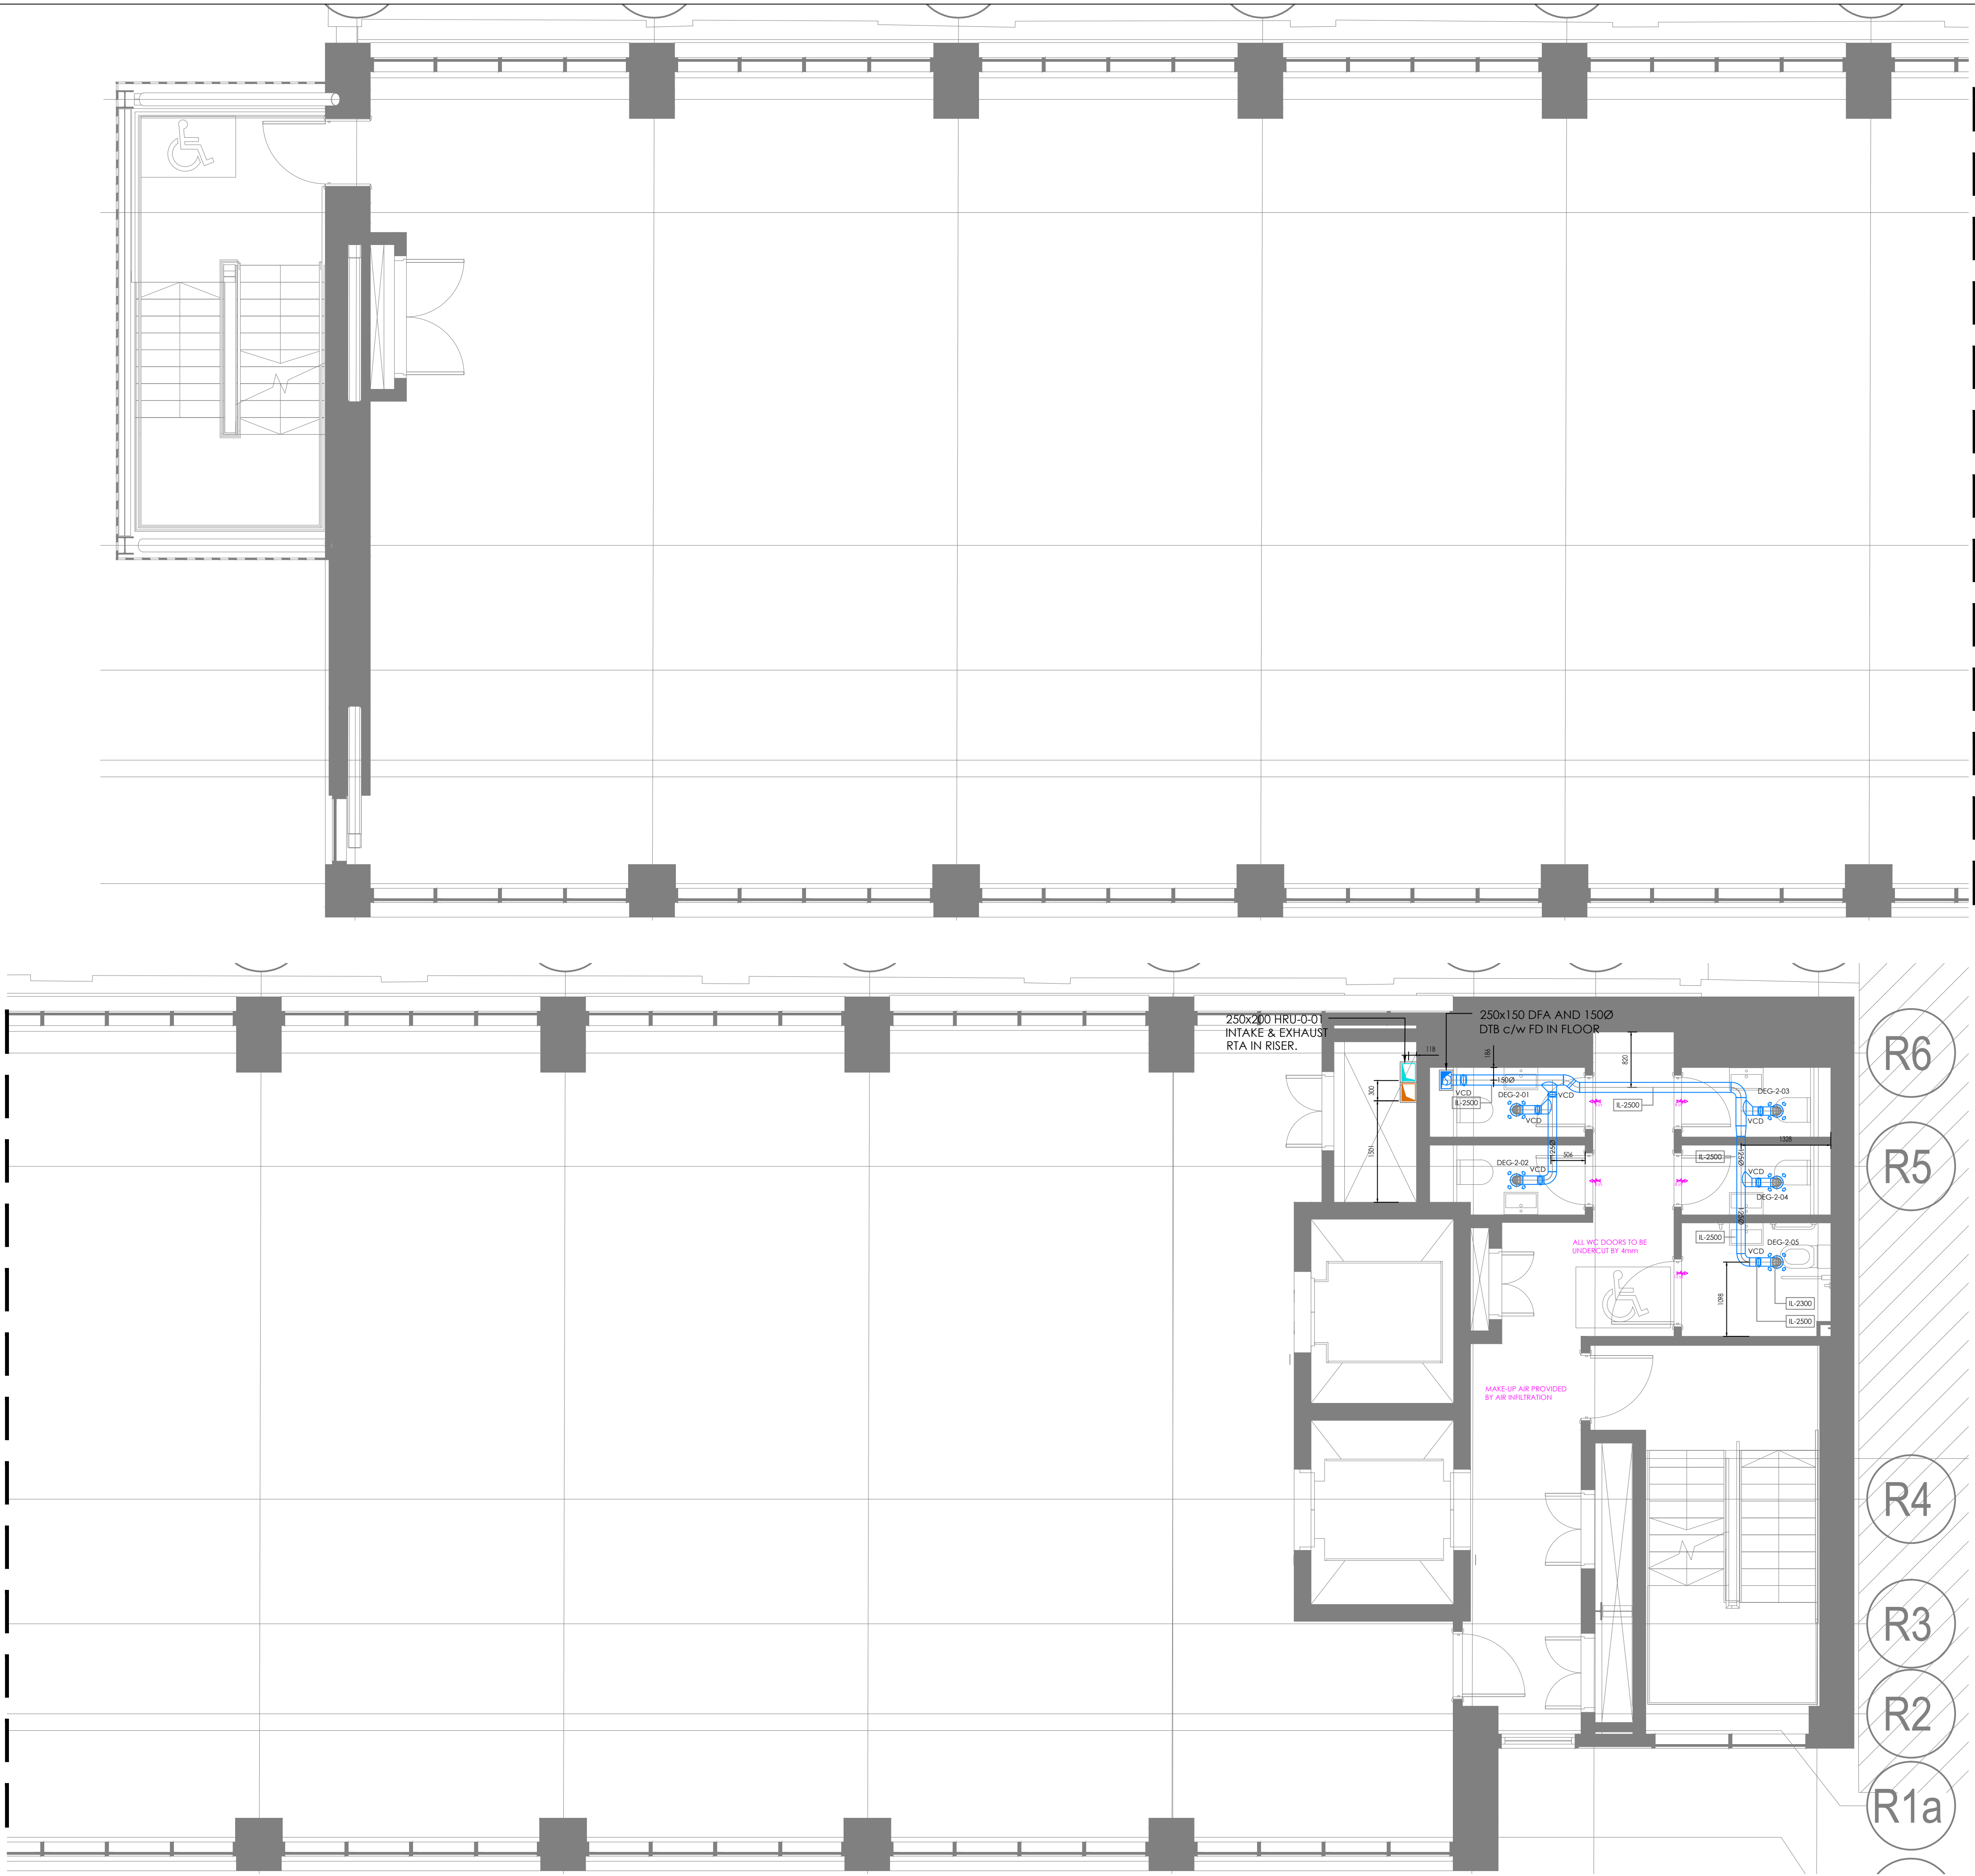

© This drawing is copyright protected, and remains the property of hurstwood environmental consulting, it must not be reproduced, used, disclosed or transmitted to third parties in any form without prior written permission.

VENTILATION NOTES

1. ALL GENERAL SUPPLY AND EXTRACT DUCTWORK SHALL BE MANUFACTURED AND INSTALLED IN ACCORDANCE WITH THE HVCA SPECIFICATION DW144 LOW PRESSURE CLASS A
2. ALL EXTERNAL SUPPLY AND RETURN AIR DUCTWORK SHALL BE INSULATED, FINISHED ALUMINIUM CLAD AND IDENTIFIED
3. ALL INVERT LEVELS TAKEN TO CENTERLINE OF SERVICES

C2	PC	21.12.20	CONSTRUCTION ISSUE
C1	PC	04.10.20	CONSTRUCTION ISSUE
P2	PC	03.08.20	STAGE 4 - PRELIMINARY - COMMENTS INCORPORATED
P1	PC	12.04.20	STAGE 4 - PRELIMINARY ISSUE
REV	CHK	DATE	Description

Architectural X-Ref Drawings:
FF&E X-Ref Drawings:

Drawing Status: **CONSTRUCTION**

Design & Construction By: **Bowmer & Kirkland** MEP Contractor: **VAUGHAN**

HE **hurstwood environmental**
Consulting Engineers
www.hurstwood-eng.co.uk

Bolton Office
Altra
Spa Road
Bolton
BL1 4AG
T: 01204 770 041
E: bolton@hurstwood-eng.co.uk

Liverpool Office
23 Goodlass Road
Speke
Liverpool
L24 9HJ
T: 0151 728 3360
E: liverpool@hurstwood-eng.co.uk

London Office
344 Gray's Inn Road
Bloomsbury
London
WC1X 8BP
T: 0203 755 3711
E: london@hurstwood-eng.co.uk

Drawn: R Jordan	Chkd: P Chambers	App: M Jordan	A1
Date: APR 2020	Scale: 1:50	Client:	

BOWMER AND KIRKLAND

Project: OLD GRANADA STUDIOS - ZONE 6

Drawing Title: VENTILATION LAYOUT
SECOND FLOOR

Project No: 63050-VAU-Z6-02-DR-N-5703	Rev: C2
---------------------------------------	---------