


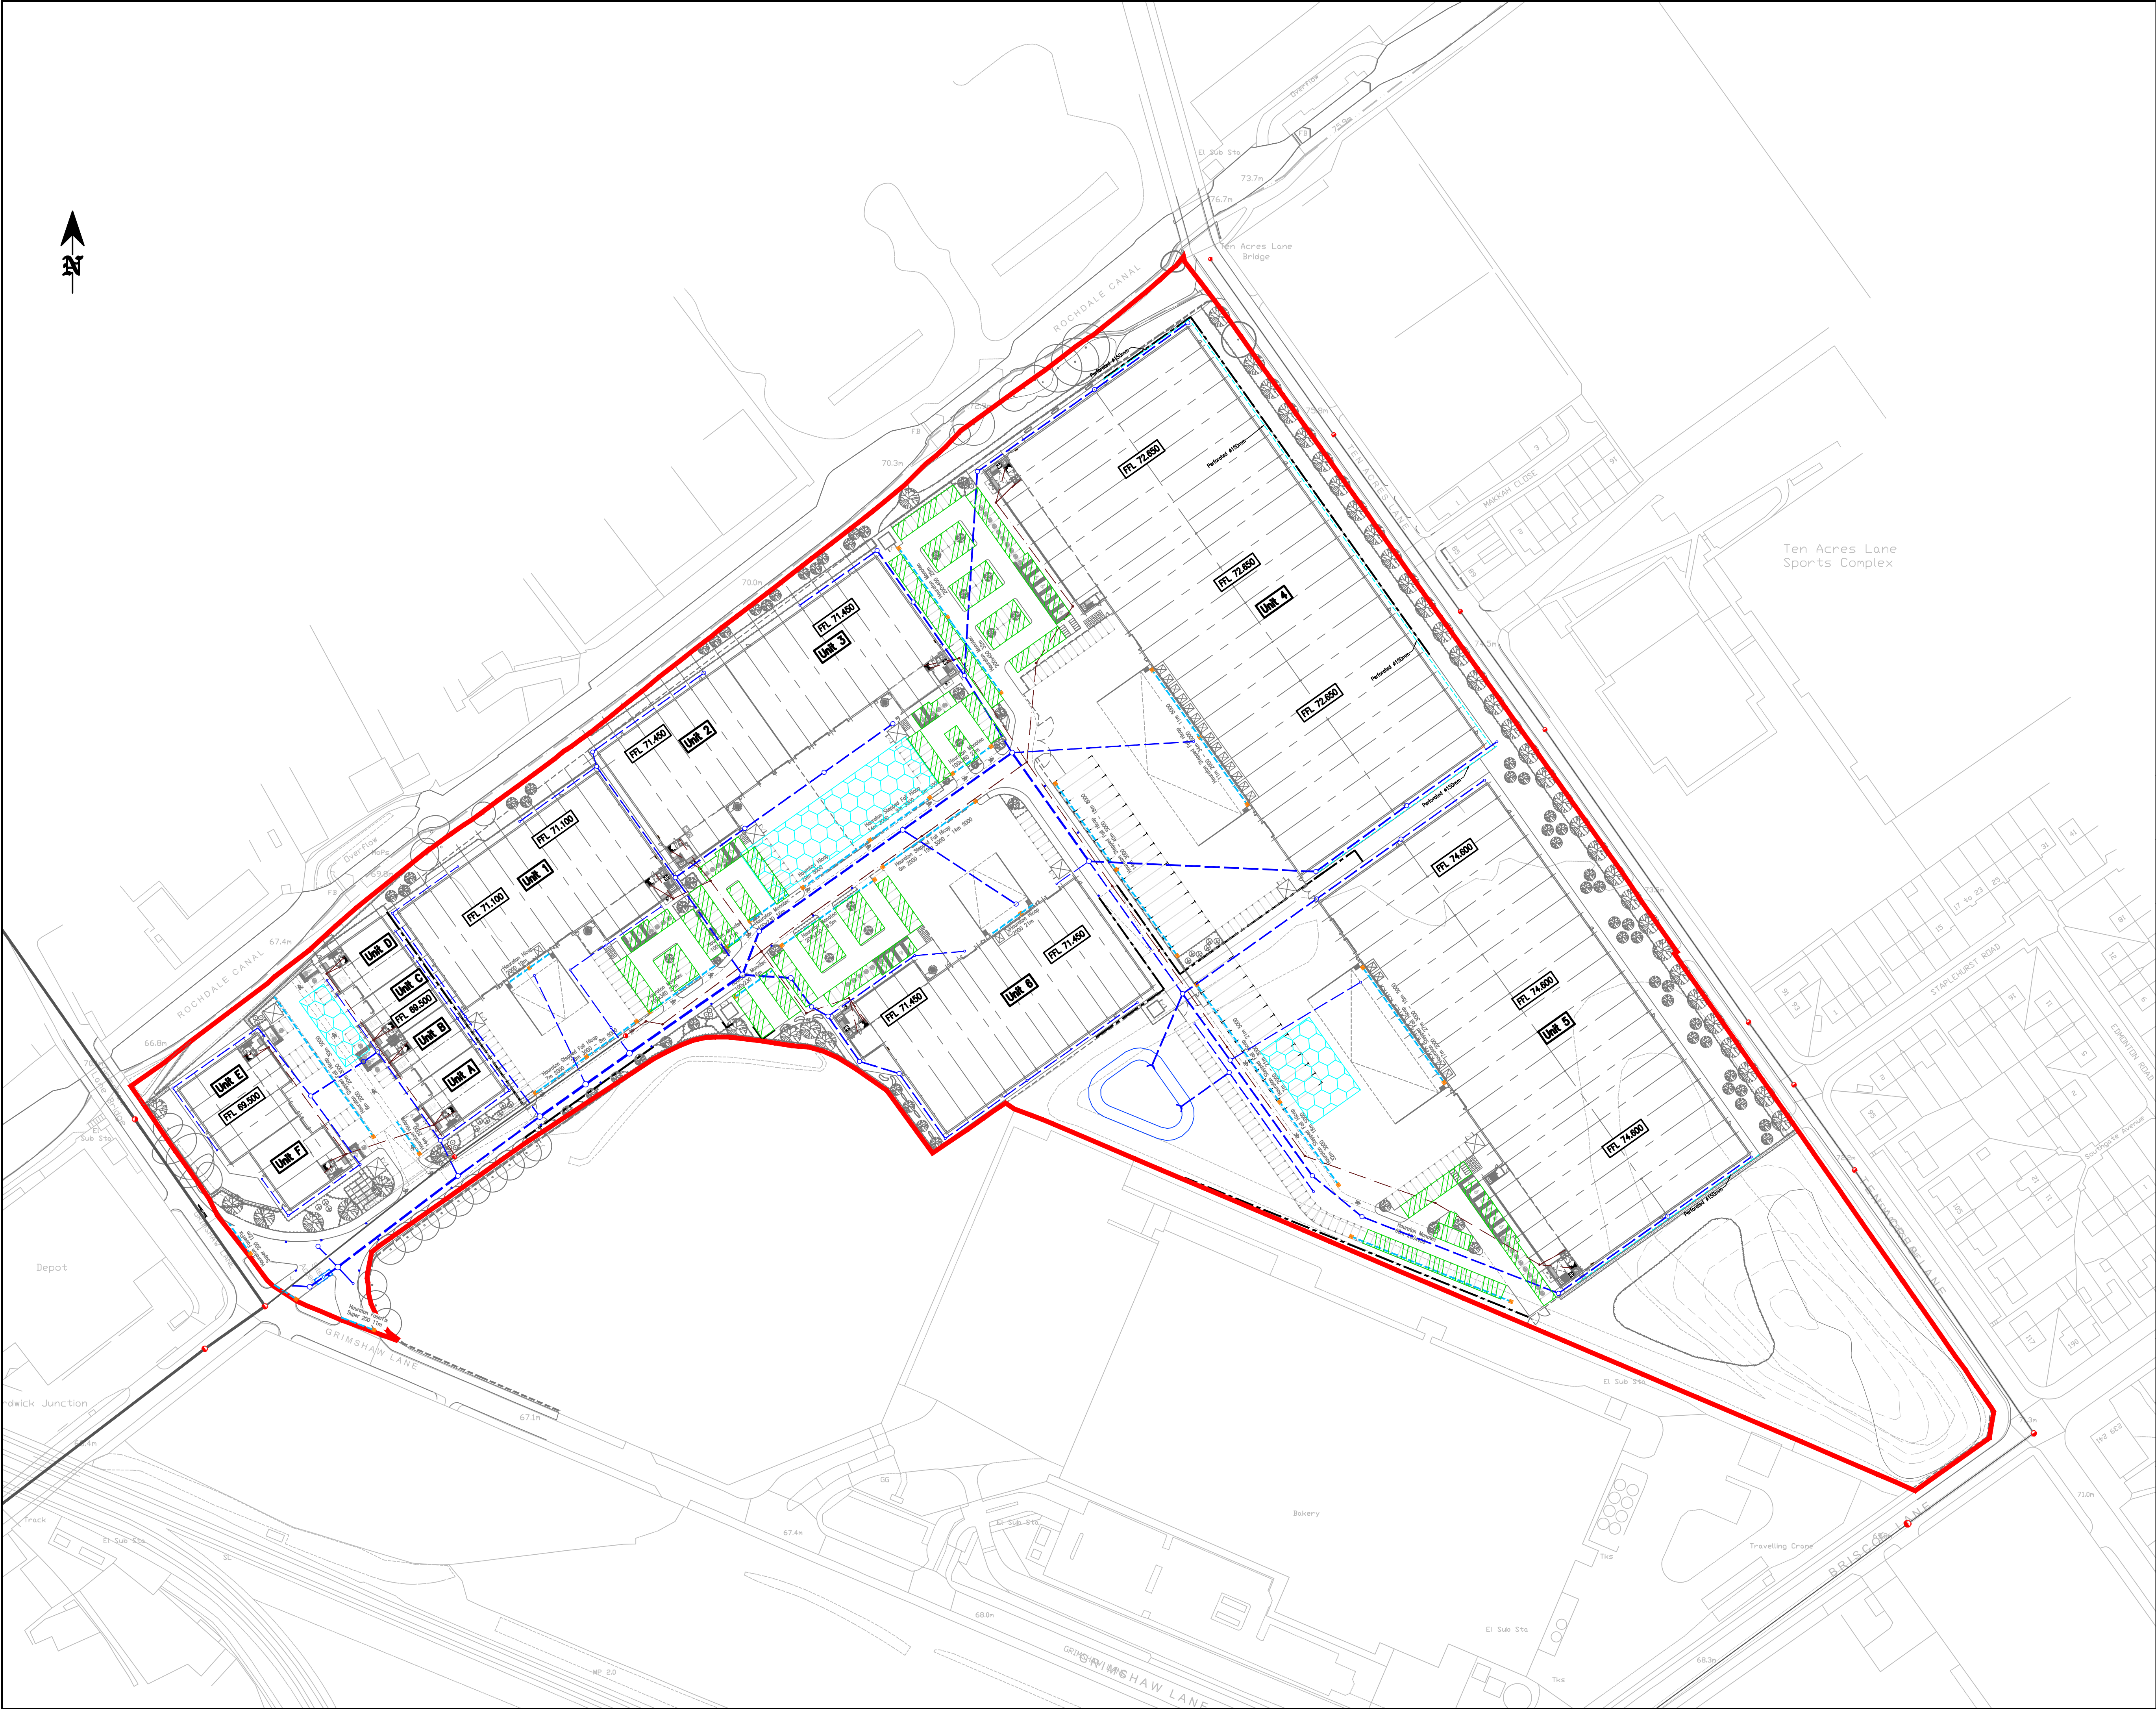

- Notes:**
1. Do not scale from this drawing.
 2. In case of any discrepancies in drawings, details or bills, refer to engineers for clarification; unilateral decisions by the Contractor will not be accepted.
 3. This drawing is to be read in conjunction with all related Architects, Consultants & Sub-Contractors drawings and specifications.
 4. The Contractor is advised that all design drawings and information are to be read concurrently and any discrepancies or omissions reported directly to PTA's Civil Engineering Department.

Key:

- Site Boundary
- Attenuation Tank
- Proposed Surface Water Drainage
- Proposed Foul Water Drainage
- Existing Combined Sewer

© Powell Tolner & Associates Ltd.
The contents of this drawing may not be reproduced in whole or in part without the prior written permission of Powell Tolner & Associates.

COMMENT/COSTING/APPROVAL
NOT FOR CONSTRUCTION

REV	DESCRIPTION	BY	DATE	CHK'D
P06	Site Layout Updated; SW Network Adjusted; Pond Added.	LB	13.08.21	
P05	Site Layout Updated; SW Network Redesigned.	LB	07.06.21	
P04	Site Layout Updated.	LB	19.03.21	
P03	Site Layout Updated.	LB	12.02.21	
P02	Tank 1 Label Amended.	LB	03.11.20	
P01	First Issue.	LB	27.10.20	

PROJECT TITLE
Grimshaw Lane, Manchester

DRAWING TITLE
Proposed Sitewide Drainage Layout

DATE	October 2020	This drawing is issued only for the purposes described in the drawing status box.	PTA PROJ No
DRAWN	LB		9762
SCALE	1:1000		REVISION
DWG SIZE	A1		P06

DRAWING No 9762-PTA-XX-XX-DR-C- 8100

Consulting Civil & Structural Engineers

pta

29 Red Lion Street
Chesham
Bucks.
HP5 1EJ
Tel. 01494 772721