


Notes

1. This layout shall be read in conjunction with all other services, architectural and structural information, project specifications and contract documentation.

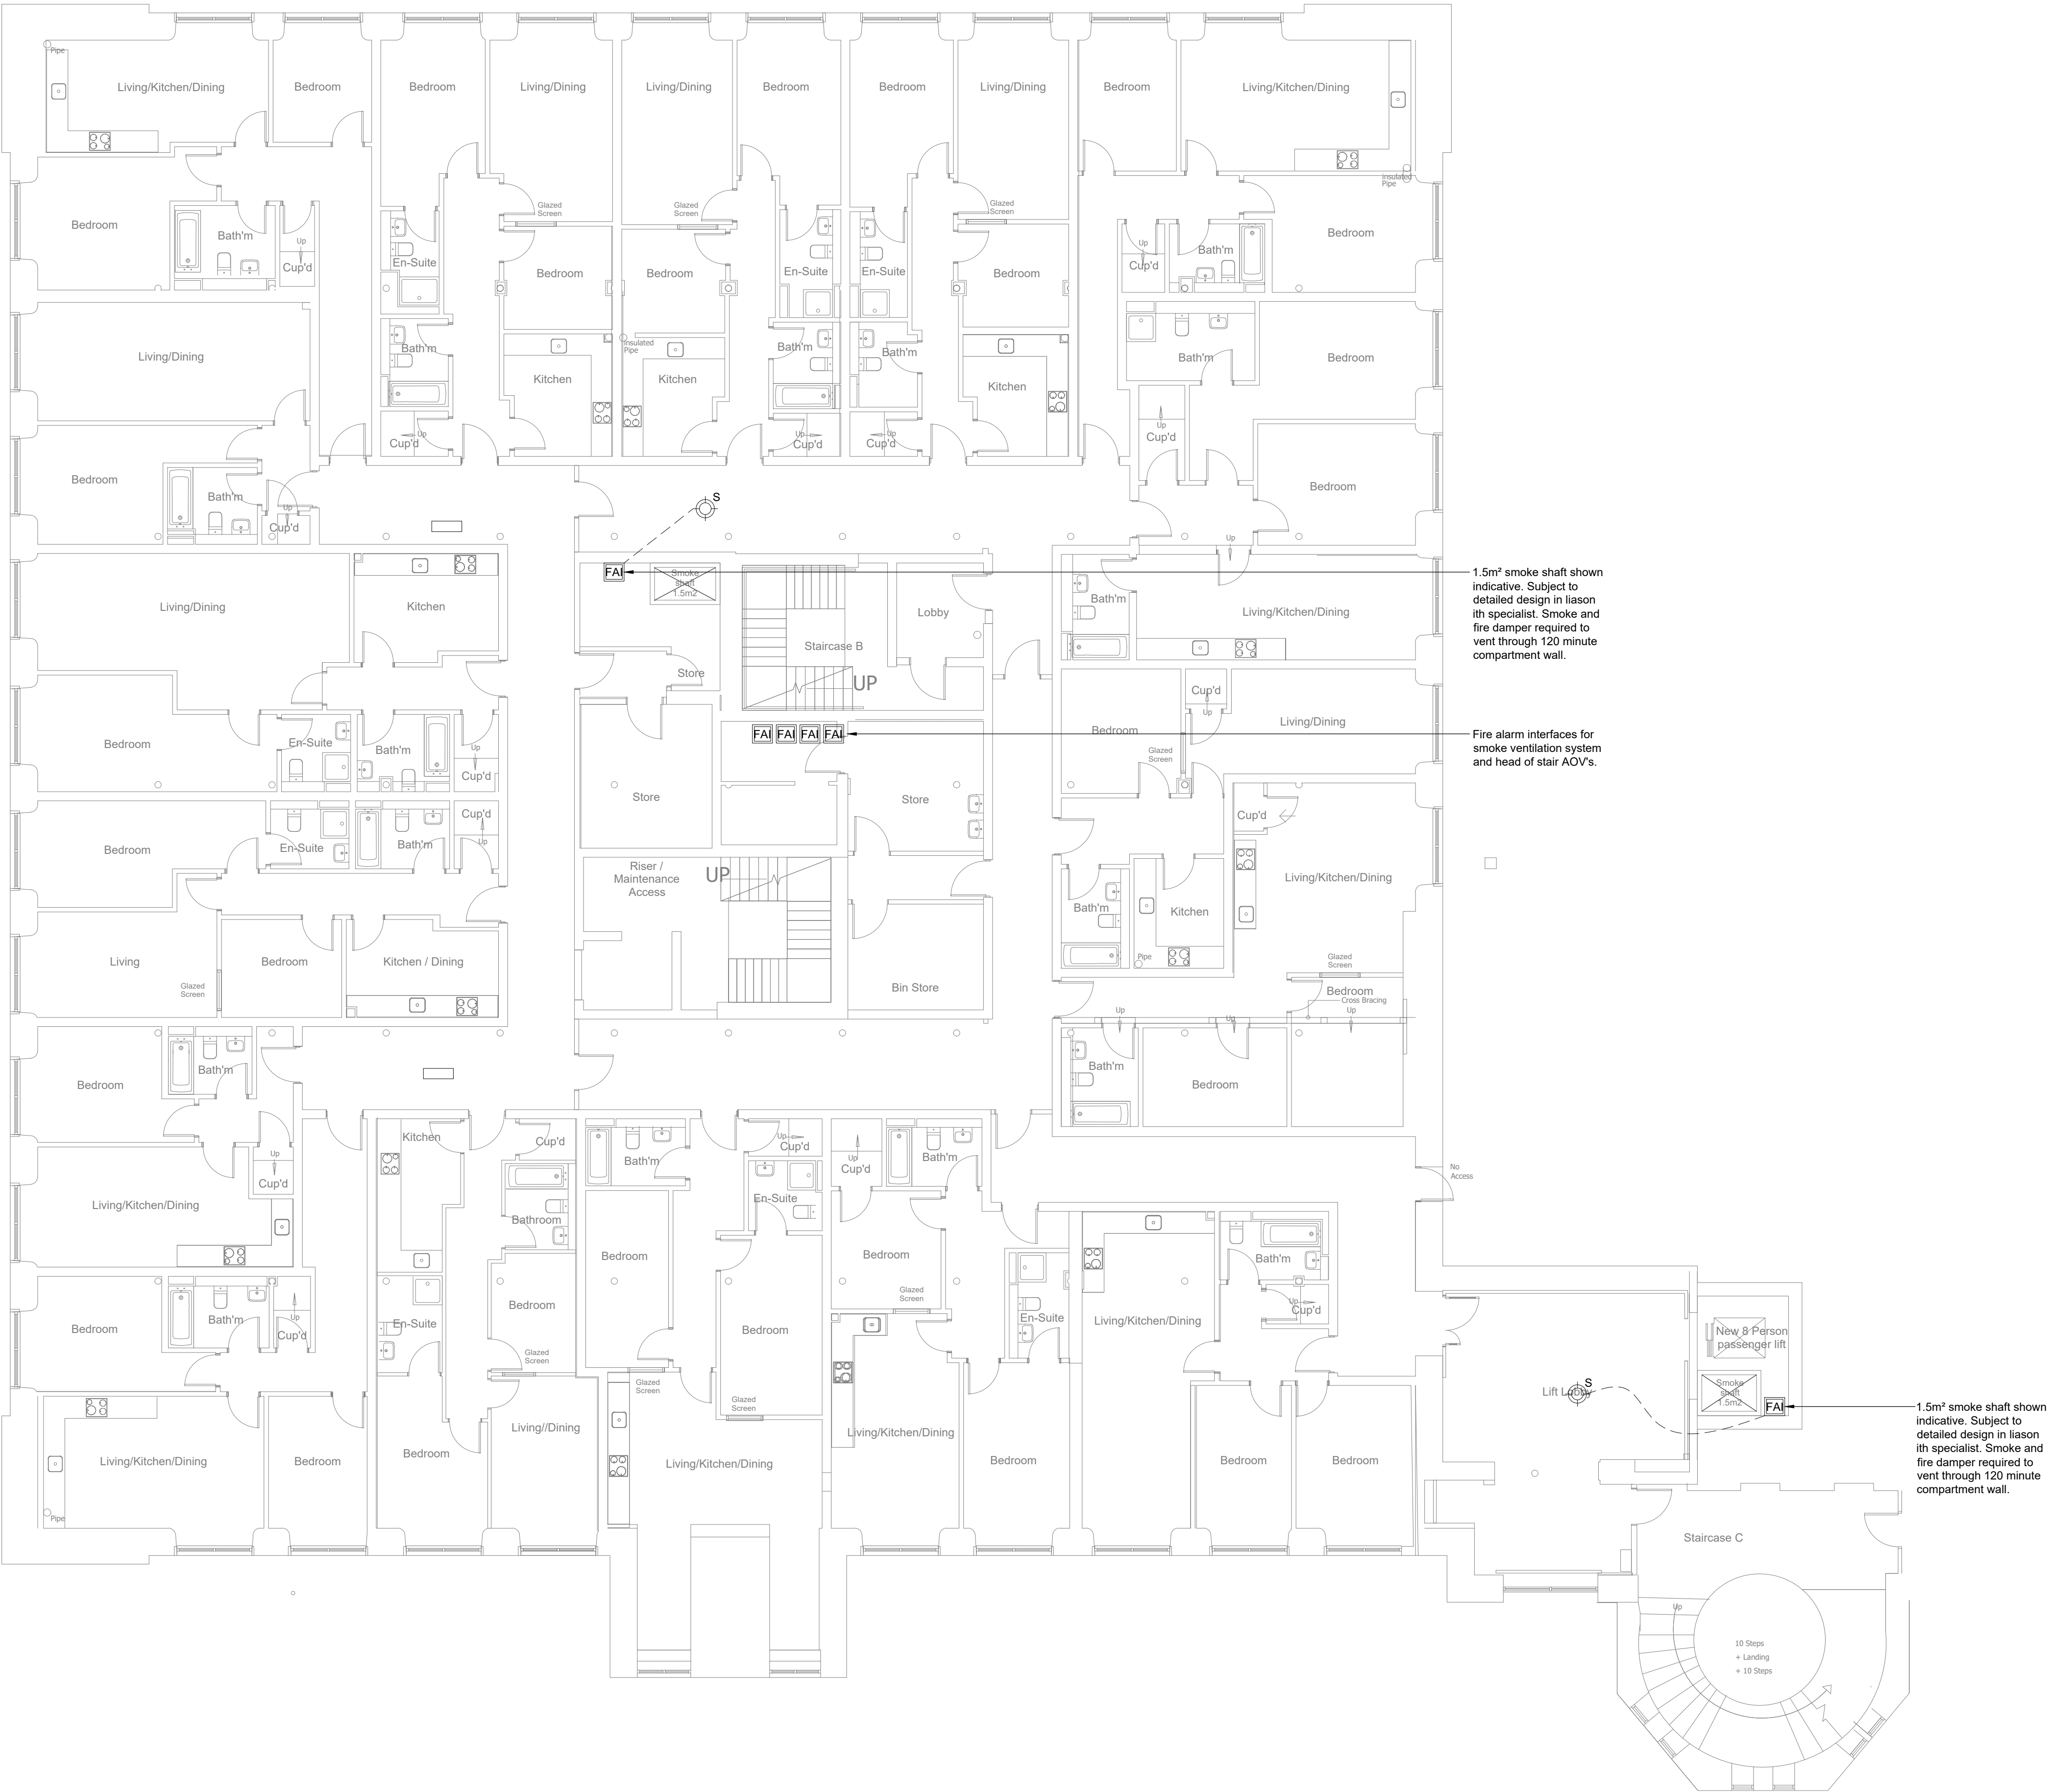

C1	NG	19.03.21	Contract Issue.
P1	NG	26.02.21	Preliminary Issue.
Rev	By	Date	Description



TACE

THE ASSOCIATES CONSULTING ENGINEERS
Portland House
Stanley Green Business Park
Oak Green
Cheshire M16 9JL
T: 0161 486 5429
F: 0161 486 0488
E: info@tace.co.uk
W: www.tace.co.uk

Client

RFP Advisory Group

Project

Victoria Mill, Manchester

Drawing Title

Proposed
Smoke Ventilation Layout
Level 01

Drawn	EI	Date	26.02.21	Cad File	VMM-TCE-XX-01-DR-M-57002 Rev C1.dwg
Checked	NG	Date	26.02.21	External Ref.	-
Approved	NG	Date	26.02.21	Scale	1:100 at A1
				Issue Status	--
Job No.	PA1484	Drawing No.	VMM-TCE-XX-01-DR-M-57002	Rev	C1