

NOTE:


FOR ALL ILLUMINATED SIGNAGE
AN INDEPENDANT 5A / 230V / 60
Hz SINGLE-PHASE SUPPLY
SHALL BE TAKEN THROUGH A
DUCT TO THE SIGNAGE AND
CONNECTED.

THE PYLON / FLAGPOLE SIGN IS
SUPPLIED FREE ISSUE BY LIDL.
THE BOLT CAGE / ANCHOR
BASKET IS TO BE PROVIDED IN
ADVANCE (BY LIDL) SO THAT
THE FOUNDATION CAN BE
INSTALLED IN ADVANCE OF THE
SIGN ARRIVING ON SITE. THE
LIDL SENIOR CONSULTANT
CONSTRUCTION (SCC) WILL
ORDER THE EXTERNAL
SIGNAGE TO ACCEPT DELIVERY
AND STORE THE SIGNAGE
SAFELY UNTIL IT IS INSTALLED.
THE LOCATION OF THE PYLON
AND BUILDING SIGNS MUST BE
AGREED IN WRITING WITH LIDL
SENIOR CONSULTANT
CONSTRUCTION (SCC)


INSTALLATION METHODOLOGY
OF THE SIGNAGE INCLUDING
ELECTRICAL CONNECTION TO
SAME MUST BE AS PER THE
STANDARD LIDL DETAIL
DRAWINGS. ALL CABLING FOR
GABLE SIGNS MUST BE HIDDEN
IN MULLIONS / TRANSOMS OF
THE SHOP FRONT. ONCE
INSTALLED, SIGNAGE MUST BE
PROTECTED AS NECESSARY
UNTIL IT IS HANDED OVER AT
PRACTICAL COMPLETION.

THE DIRECTION ARROWS ARE
TO BE POSITIONED AS PER
ADVICE FROM THE LIDL SENIOR
CONSULTANT CONSTRUCTION
(SCC), AND TO BE SET IN
CONCRETE TO A HEIGHT OF
1200mm (UPPER EDGE PIPE)
ABOVE GROUND LEVEL.
SPECIAL ATTENTION IS TO BE
GIVEN TO THE FACT THAT ALL
SIGNAGE DOES NOT POSE A
LINE-OF-SIGHT OBSTRUCTION
WHEN EXITING THE PARKING
AREA.


FOUNDATIONS AND POWER
SUPPLY FOR THE NON - FOOD
POSTER DISPLAY UNIT (PDU),
AND TWO FOUNDATIONS FOR
THE TUBE FRAMES FOR LIDL
ENTRANCE ARROW ARE ALSO
TO BE INCLUDED IN THE MC's
SCOPE OF WORK.

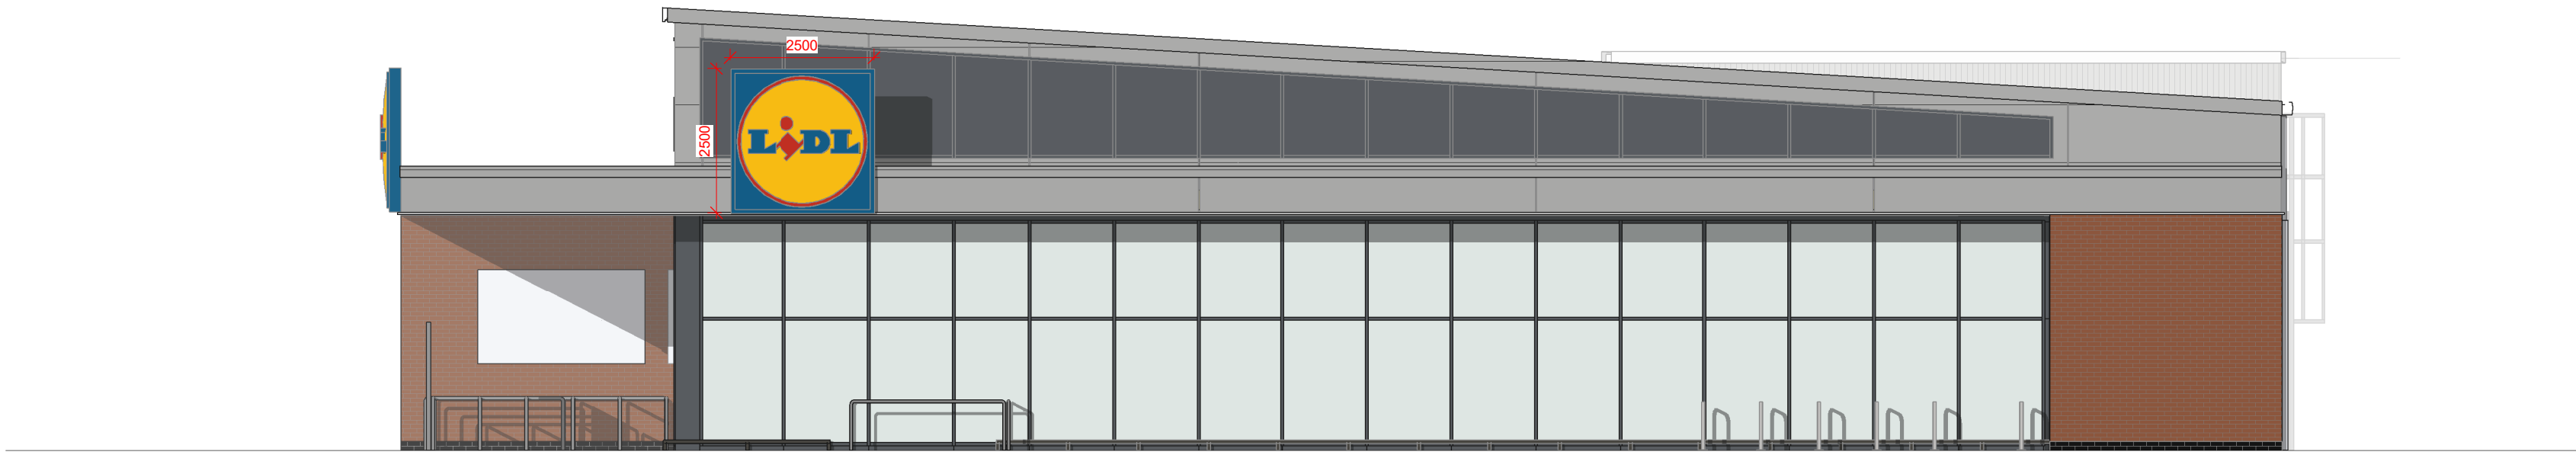


E03 GLAZED ELEVATION
1 : 100

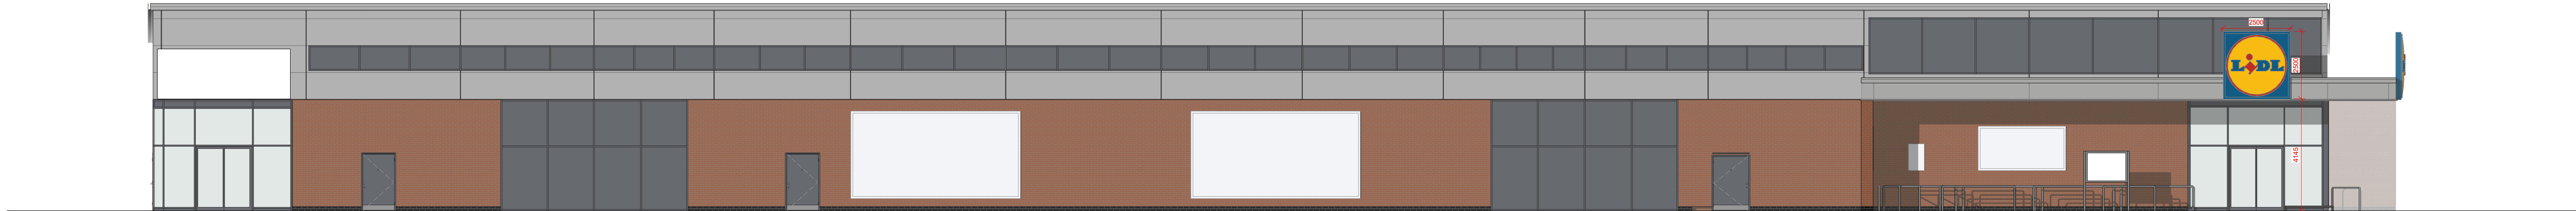


E01 FRONT ELEVATION
1 : 100

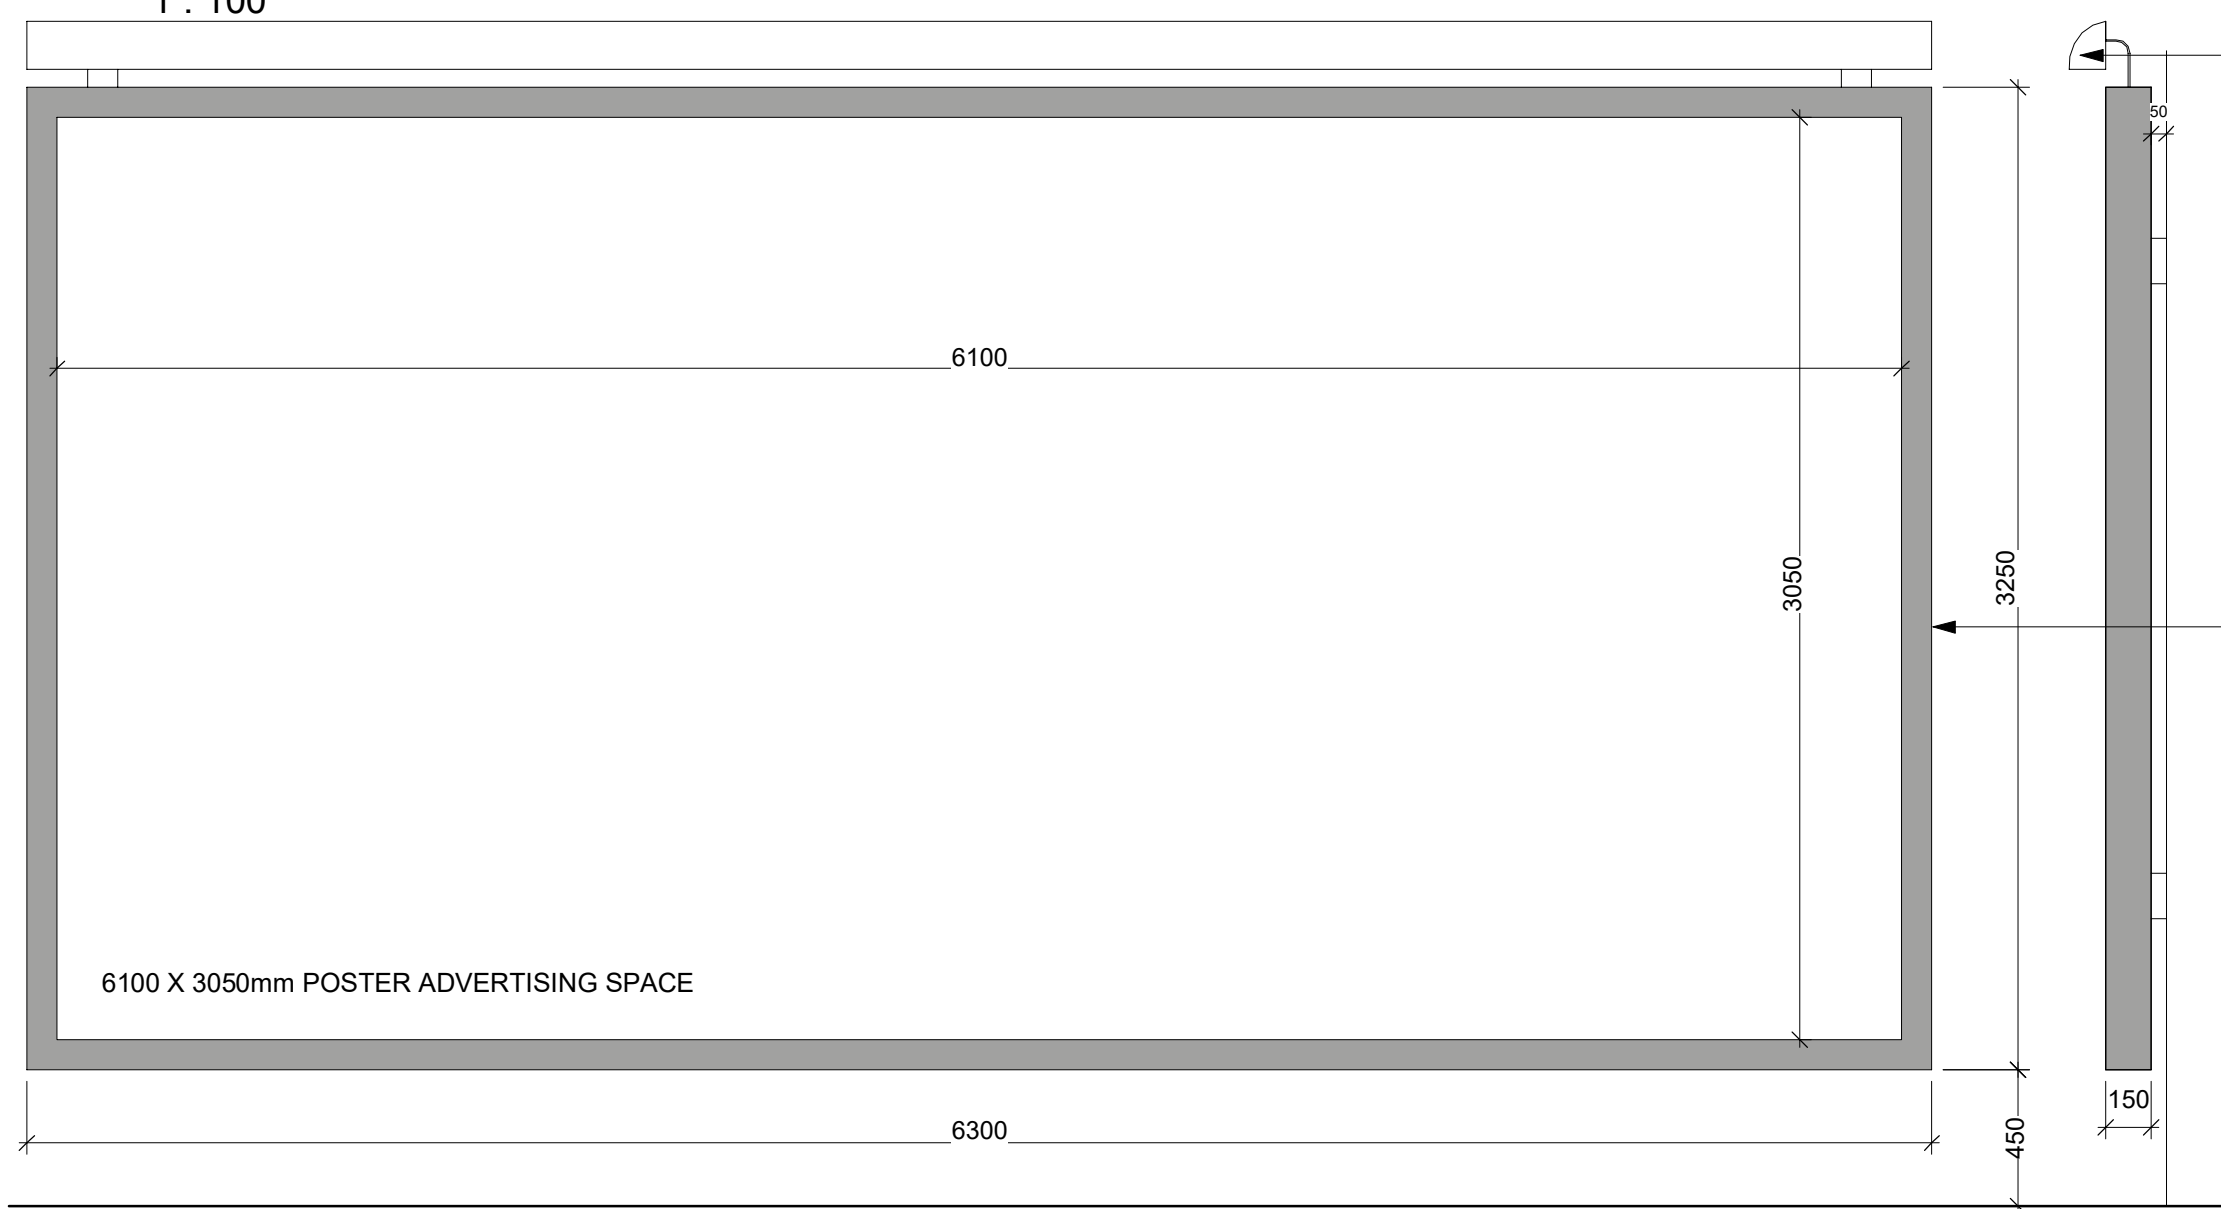

1 LARGE WALL MOUNTED BILLBOARD WITH REBATE (2 No TOTAL)
1:25

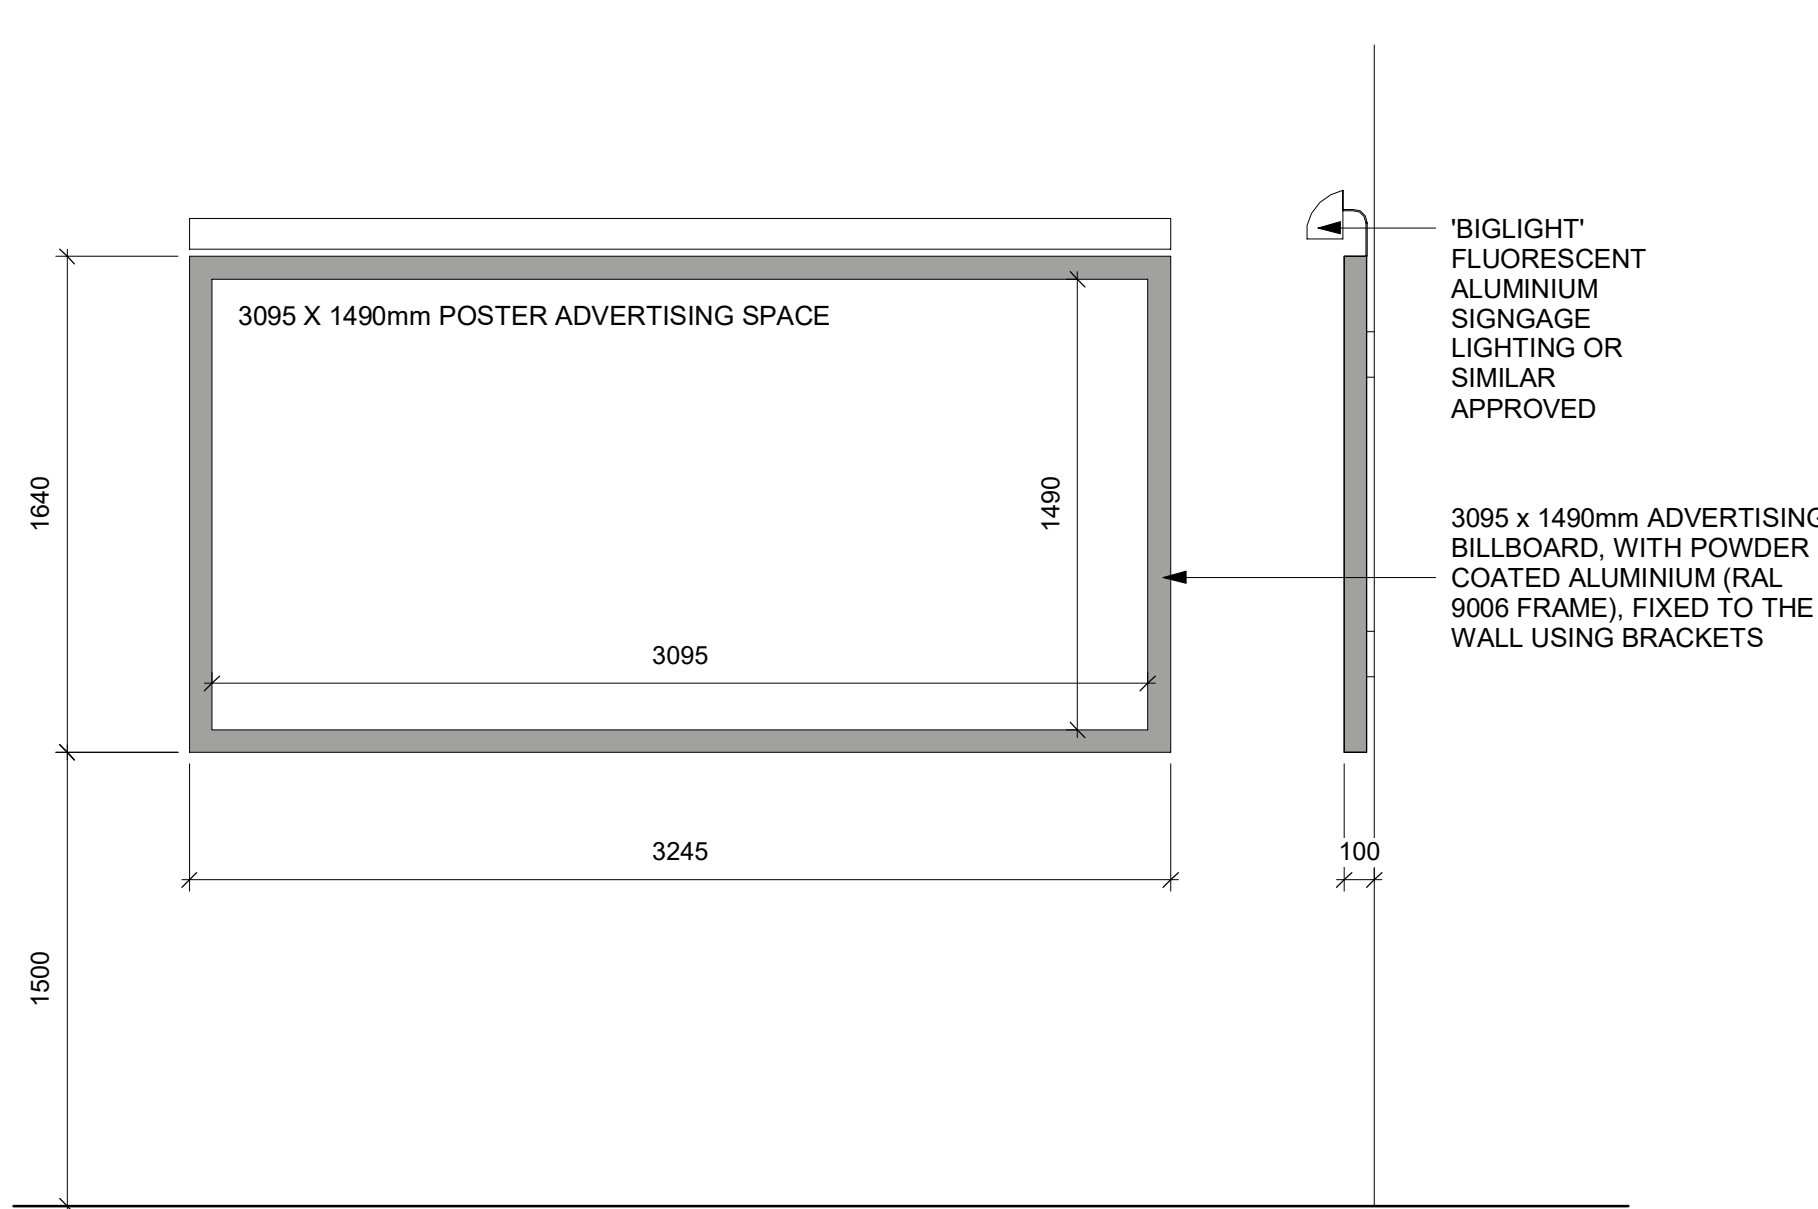


2 SMALL WALL MOUNTED BILLBOARD (2 No TOTAL)
1:25

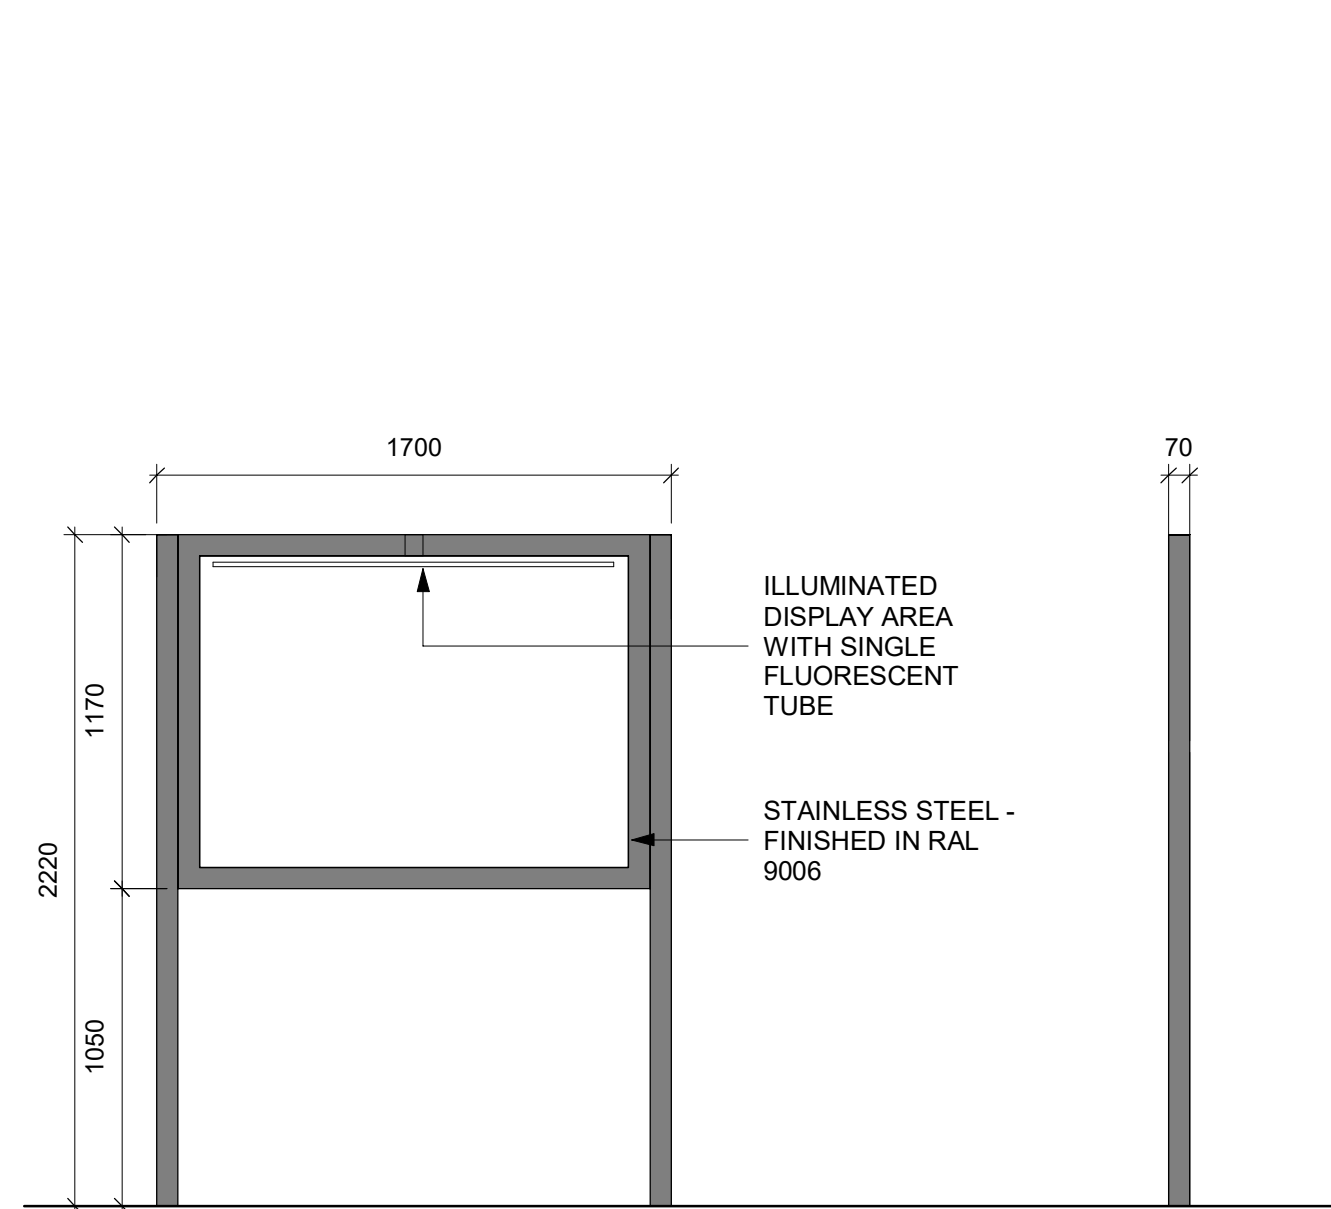

3 POSTER DISPLAY UNIT (1 No TOTAL)
1:25

NOTE: BILLBOARD TO BE FIXED TO EXISTING STEEL COLUMNS

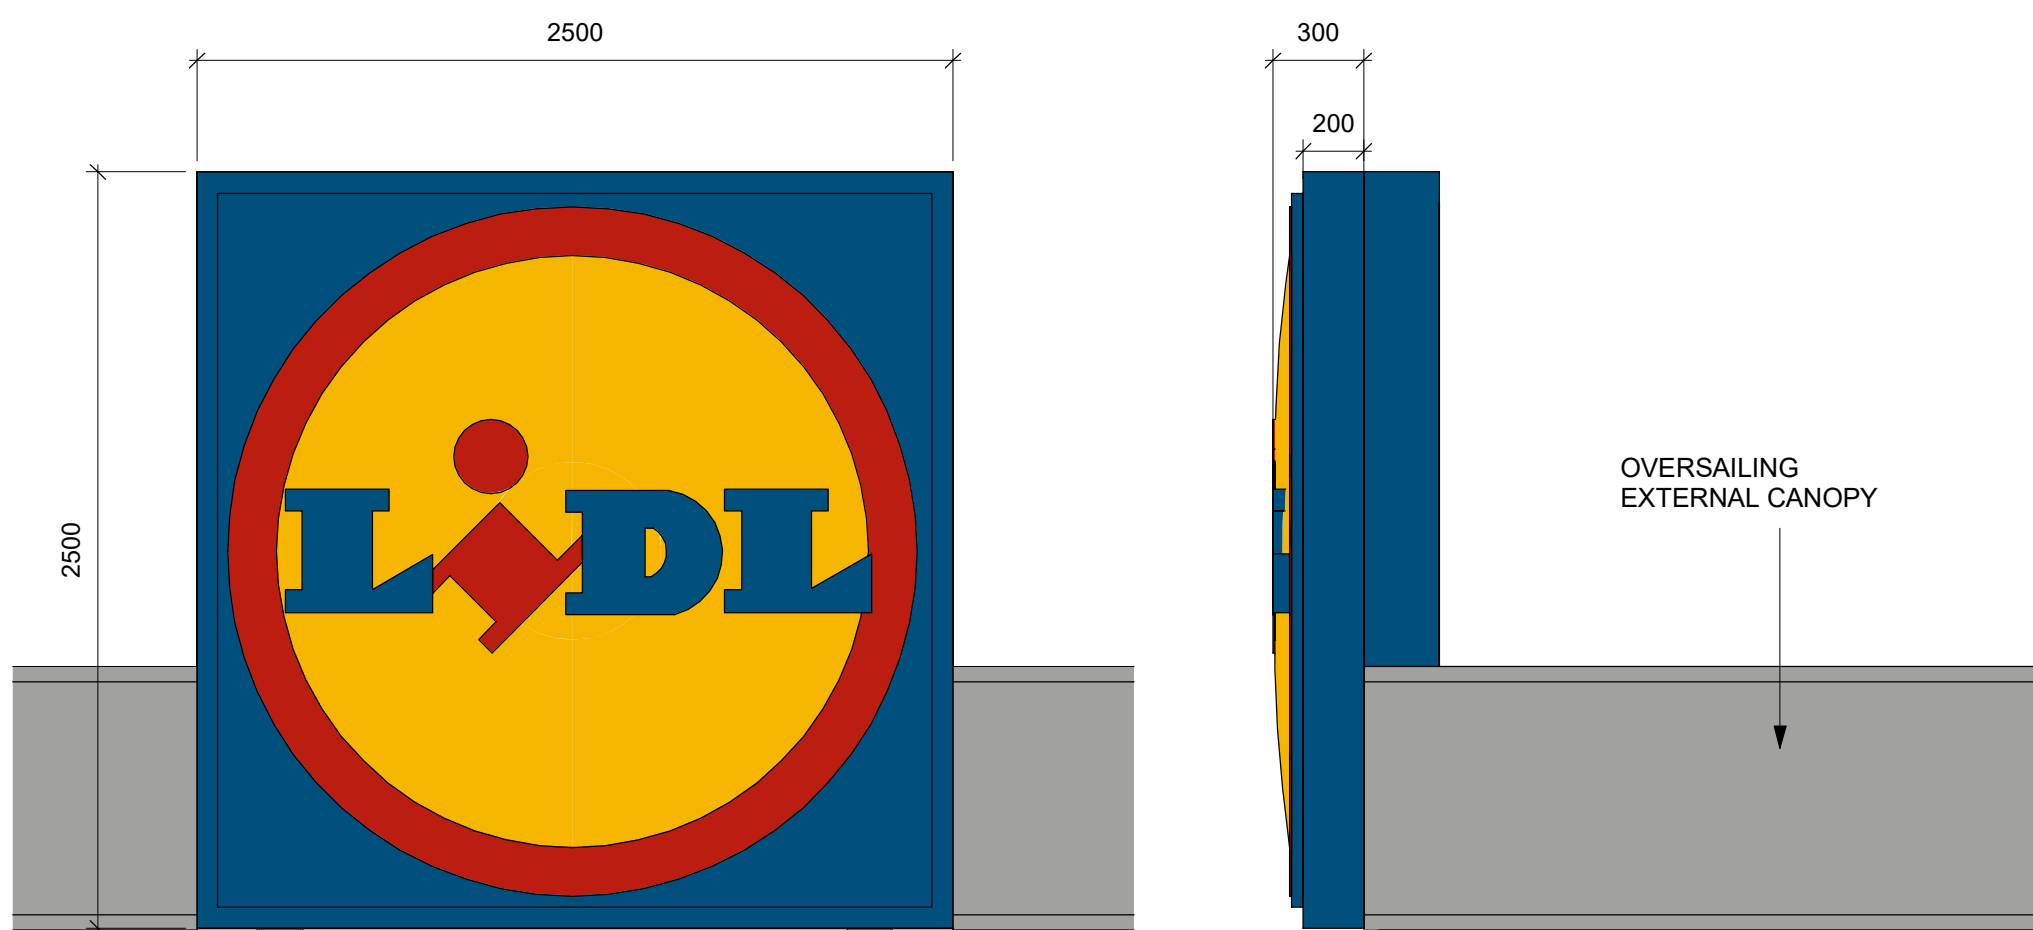

CANOPY SIGN

2500mm SQUARE, ALUMINIUM SINGLE SIDED
LIGHTBOX, ALUMINIUM DUAL CASE TYPE
EXTRUSION, COMPRISING 4 MITRED SECTIONS
WITH WELDED INNER STEEL FRAME.

FACING
FACE PANEL - 5mm OPAL ACRYLIC 40% LIGHT
TRANSMISSION DECORATED WITH LIDL LOGO
GRAPHIC.

COLOURS:
BLUE RAL 5010
RED RAL 3020
YELLOW RAL 1021

ILLUMINATION WITH SAPS-LEDs:


FUSE 16A, FI 30mA.

UNDERGROUND CABLE NYY-J, WIRE CROSS
SECTION FOR CABLE LENGTH MAX. 90 m3 x
2.5mm²

POWER CONSUMPTION: 1020W, POWER
INPUT: 4.66A, COS φ > 0.98

LUMINANCE YELLOW UNDIMMED: APPROX
580cd/m²

UPTO 6 ILLUMINATED ACRYLIC BANNERS

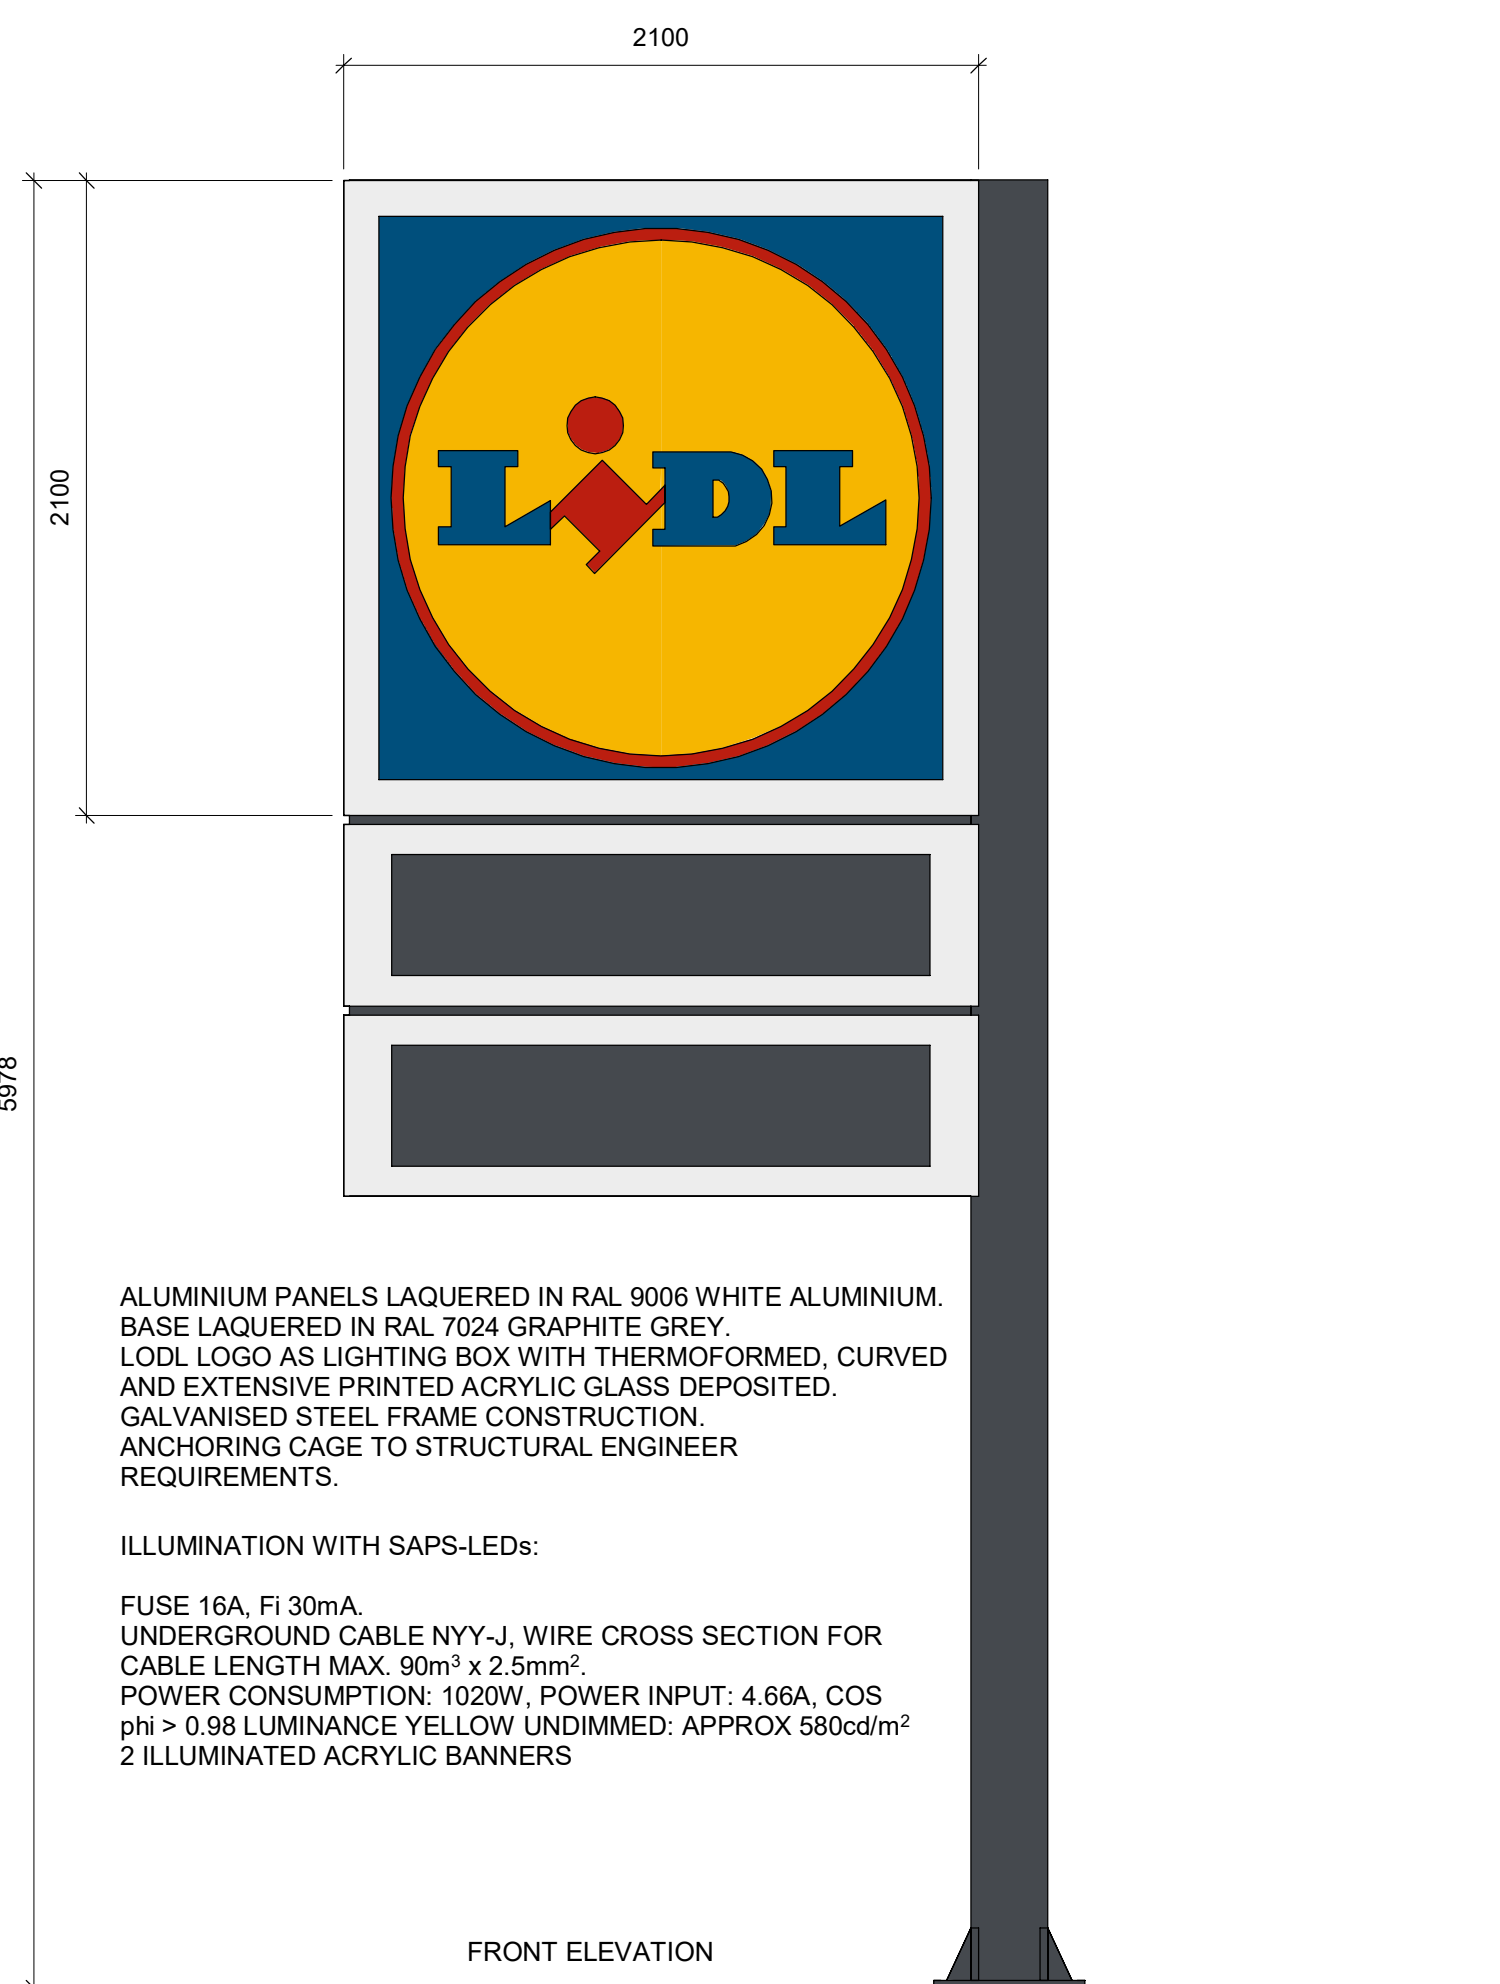

5 LIDL FLAGPOLE
1:25

ALUMINIUM PANELS LAQUERED IN RAL 9006 WHITE ALUMINIUM
BASE LAQUERED IN RAL 7024 GRAPHITE GREY.
LIDL LOGO AS LIGHTING BOX WITH THERMOFORMED, CURVED
AND EXTENSIVE PRINTED ACRYLIC GLASS DEPOSITED.
GALVANISED STEEL FRAME CONSTRUCTION.
ANCHORING CAGE TO STRUCTURAL ENGINEER
REQUIREMENTS.



ILLUMINATION WITH SAPS-LEDs:

FUSE 16A, FI 30mA

UNDERGROUND CABLE NYY-J, WIRE CROSS SECTION FOR
CABLE LENGTH MAX. 50m³ x 2.5mm²

POWER CONSUMPTION: 1020W, POWER INPUT: 4.66A, COS
φ > 0.98 LUMINANCE YELLOW UNDIMMED: APPROX 580cd/m²

2 ILLUMINATED ACRYLIC BANNERS

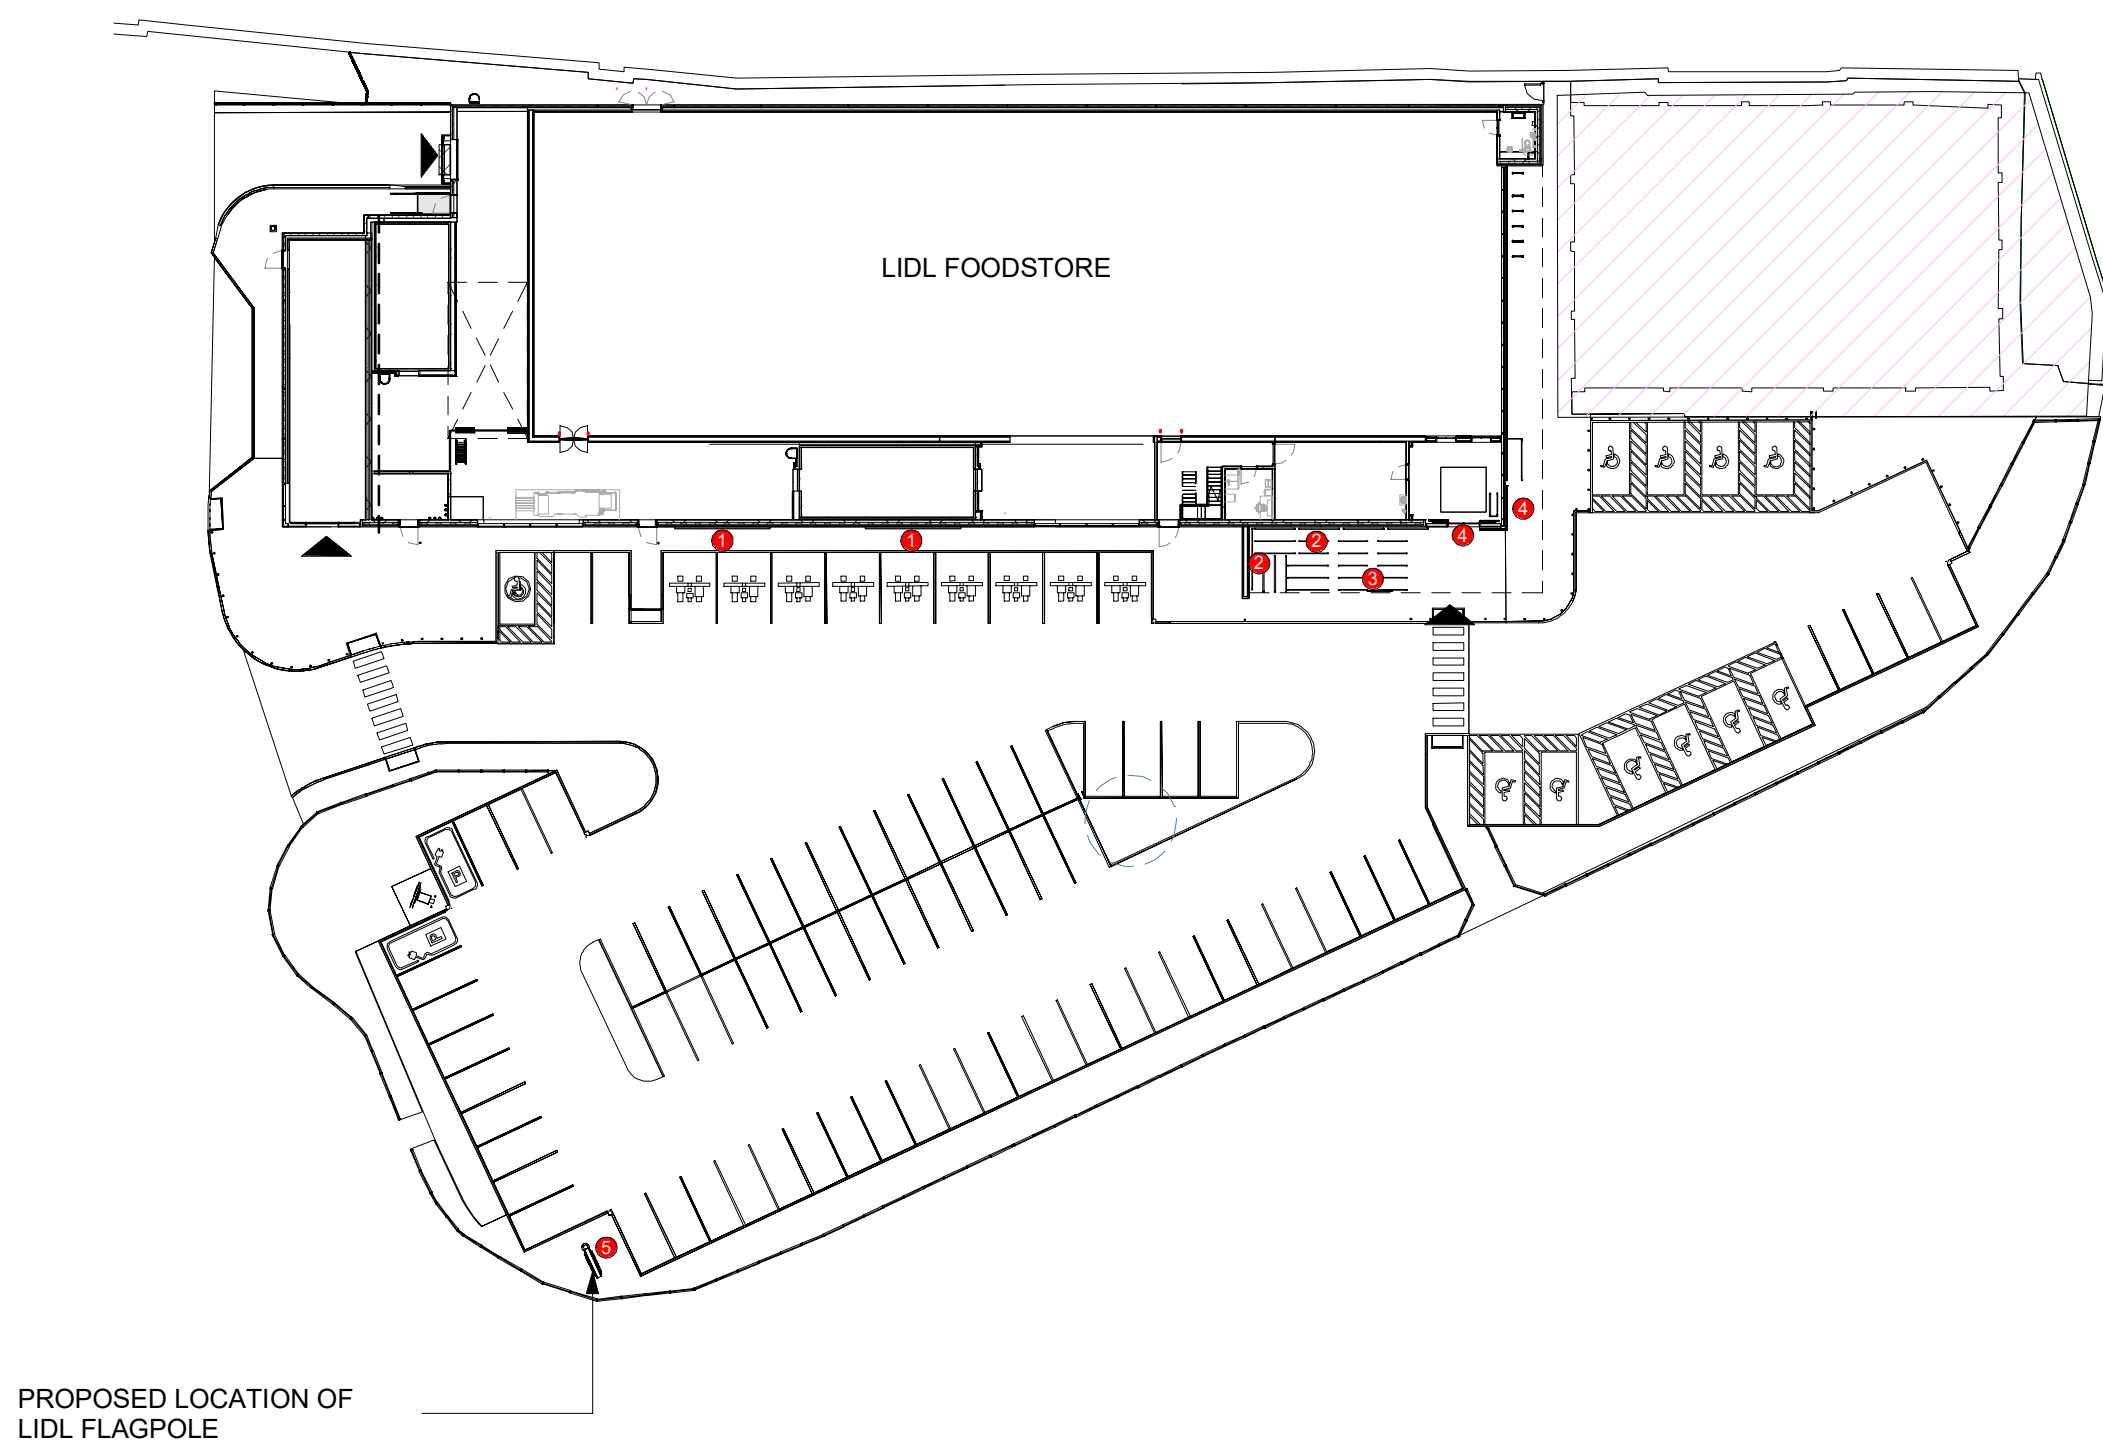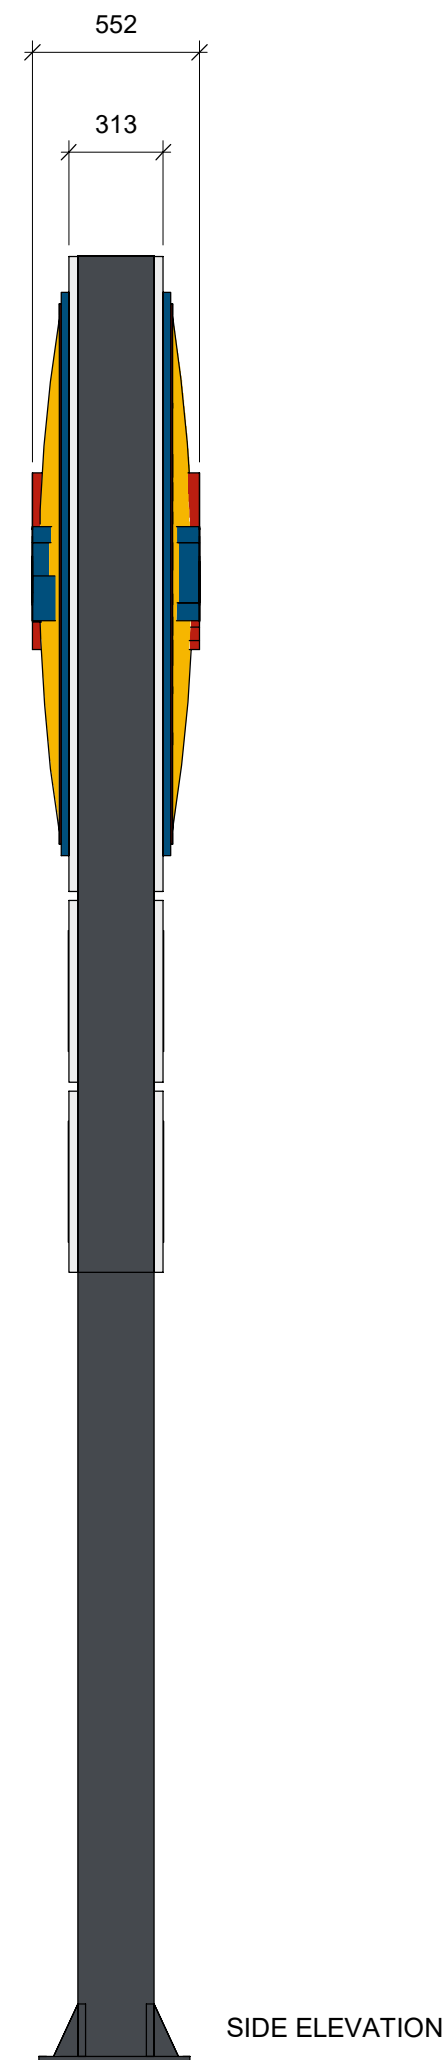

KEY PLAN
1 : 500

4 LARGE EXTERNAL LOGO (2 No TOTAL)
1:25

P4	DRAWING UPDATED TO REFLECT THE LATEST DESIGN	01.02.22	MN	JM
P3	SIGNAGE PLAN UPDATED	06.10.21	MN	JM
P2	Minor updates to the drawing	10.06.21	MN	JM
P1	FIRST ISSUE	30.03.21	MN	JM
Rev	Description	Date	Dim	Chk

Status

PLANNING

SMR
SMALLEY MARSEY RISPIN
ARCHITECTS

Floor 2 - The Exchange - Station Parade - Harrogate - HG1 1TS
01423 707 757 admin@smrarchitects.co.uk

Project

Fallowfield Retail Park, Birchfield Rd

Client



Drawing Title

PROPOSED SIGNAGE PLAN

Proj Ref	Origin	Zone	Level	Type	Role	Num	Status	Rev									
---	7397	-	SMR	-	00	-	ZZ	-	DR	-	A	-	2107	-	S3	-	P4
SMR Job Ref		Sheet		Scale		Drawn											
7397-00-2107		A0		As indicated		MN											