




GENERAL NOTES:

- FOR DRAWING REFERENCES REFER TO DRAWING
NMGNPH-CUR-VV-XX-DR-C-9250
- FOR FULL DRAINAGE NOTES REFER TO DRAWING
NMGNPH-CUR-VV-XX-DR-C-9260
- KEY:
- SITE BOUNDARY BASED ON LANDSCAPE ARCHITECT'S LAYOUT
 - EXISTING PUBLIC COMBINED SEWER
 - EXISTING PRIVATE COMBINED DRAINAGE
 - EXISTING PRIVATE SURFACE WATER DRAINAGE
 - EXISTING PRIVATE FOUL DRAINAGE
 - PROPOSED COMBINED MANHOLE
 - PROPOSED FOUL DRAINAGE
 - PROPOSED FOUL DRAINAGE MANHOLE/ INSPECTION CHAMBER
 - PROPOSED SURFACE WATER DRAINAGE
 - PROPOSED SURFACE WATER ROUTED THROUGH PETROL INTERCEPTOR
 - PROPOSED SURFACE WATER MANHOLE/ INSPECTION CHAMBER
 - PROPOSED FLOW CONTROL MANHOLE
 - PROPOSED CELLULAR ATTENUATION TANK
 - PROPOSED BACKDROP
 - PROPOSED ROAD GULLY
 - PROPOSED GULLY TO SEATING AREA
 - PROPOSED FOUL CONNECTION
 - SVP - SOIL VENT PIPE
 - SS - STUB STACK
 - SG - SHOWER GULLY
 - FG - FOUL GULLY
 - PROPOSED RAINWATER PIPE
 - DRAINAGE CAST PASSES THROUGH STRIP FOOTING*
 - DRAINAGE PASSES UNDER STRIP FOOTING**
 - LINEAR DRAINAGE CHANNEL
 - GATIC CASTSLOT TREADSAFE (150 UNLESS NOTED OTHERWISE)
 - LINEAR DRAINAGE ACCESS BOX
 - LINEAR DRAINAGE OUTLET UNIT
 - PERFORATED PIPE IN LAND DRAIN/ PERMEABLE PAVING
 - RODDING EYE FOR LAND DRAIN
 - 3000 INSPECTION CHAMBER ON LAND DRAIN
 - RETAINING WALL DRAIN
 - TREE PIT DRAINAGE - PERFORATED PIPE AND INFILTRATION TANK

P04	ISSUED FOR PLANNING UPDATE	17/12/21	ATL	MW
P03	ISSUED FOR PLANNING CONDITION DISCHARGE	22/11/21	ATL	MW
P02	STAGE 4 ISSUE	29/10/21	ATL	MW
P01	STAGE 3 ISSUE	18/01/21	ATL	MW
Rev:	Description:	Date:	By:	Chkd:

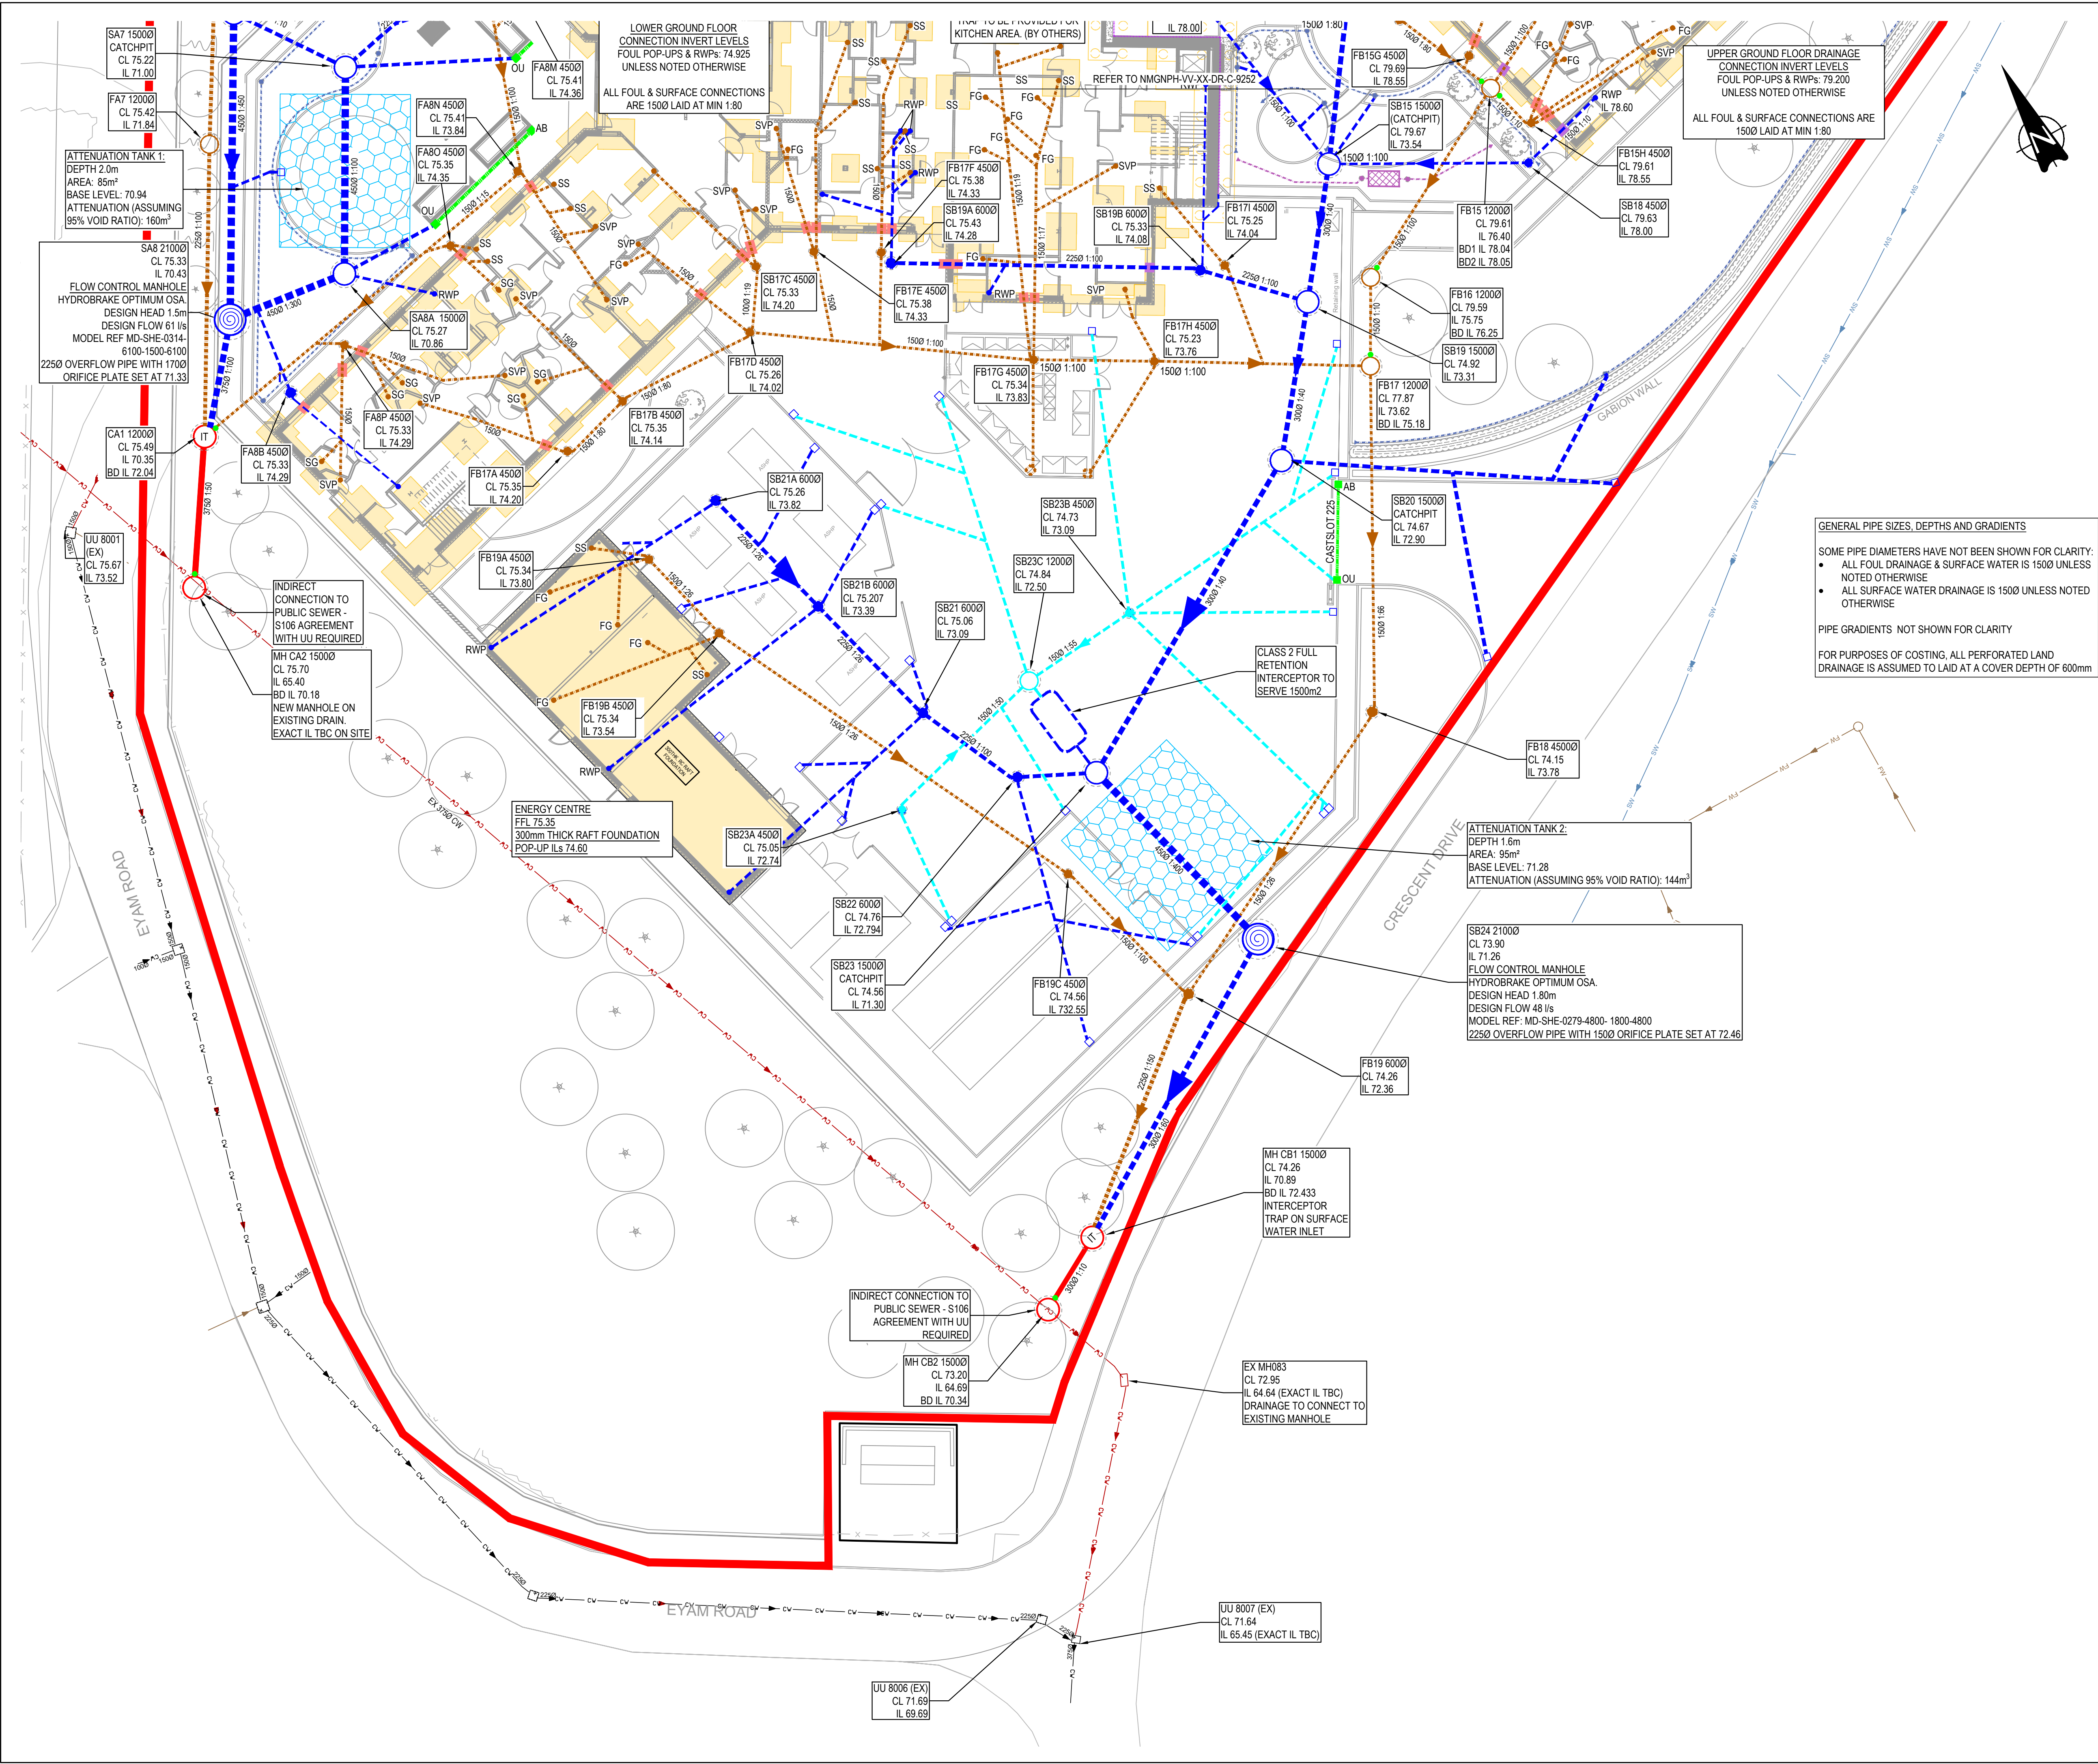

Merchant Exchange, 17-19 Whitworth Street West, Manchester, M1 5WG
0161 235 2394
manchester@curtins.com
www.curtins.com

Civils & Structures • Transport Planning • Environmental • Infrastructure • Geotechnical • Conservation & Heritage • Principal Designer
Birmingham • Bristol • Cambridge • Cardiff • Douglas • Dublin • Edinburgh • Glasgow • Kentish • Leeds • Liverpool • London • Manchester • Nottingham

STAGE 4

Project:

NEW PARK HOUSE

Dwg Title:

PROPOSED 1:200
DRAINAGE LAYOUT
SHEET 3

Size:	Date:	Drawn By:	Designed By:	Checked By:
A1	15/04/21	ATL	ATL	MW

Scale: 1:500

Project No:	Originator:	Volume:	Level:	Type:	Role:	Category / Number:	Rev:
NMGNPH - CUR - VV - XX - DR - C -						9253 - P04	