



SITE LOCATION
(Scale 1:50000)

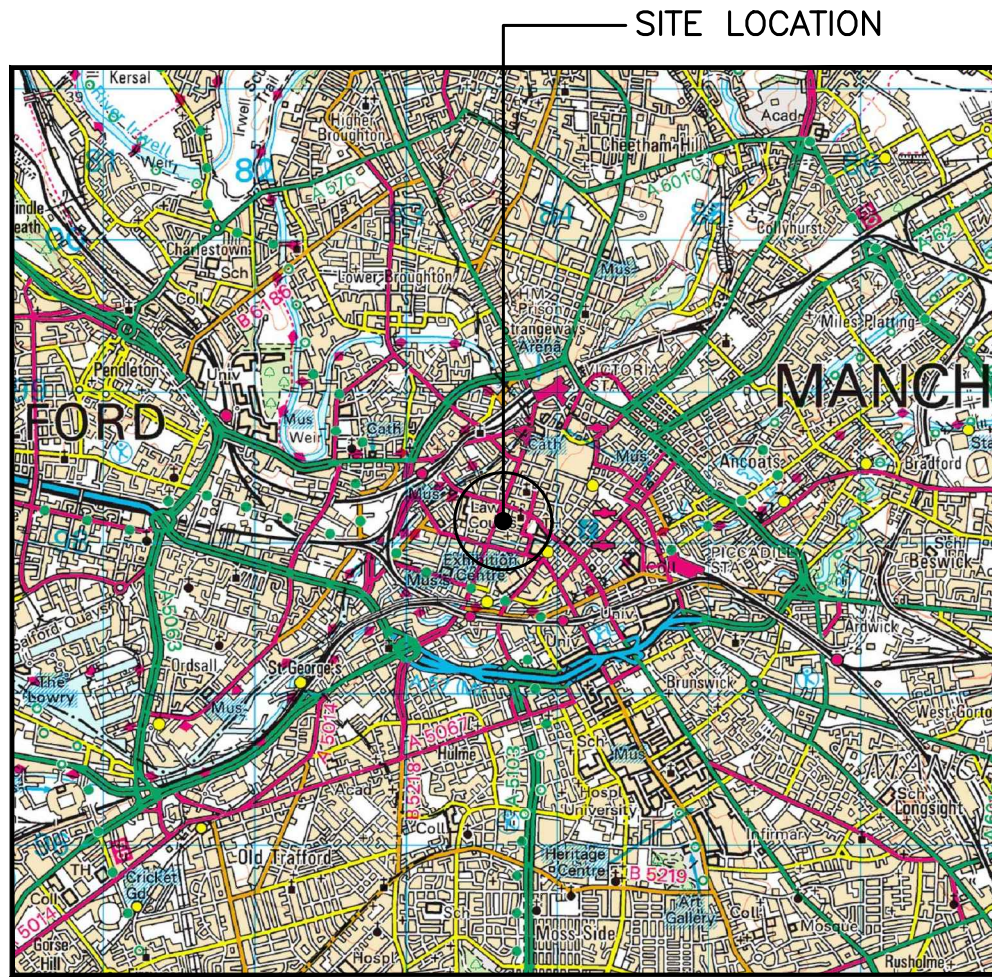


SITE PHOTOGRAPH

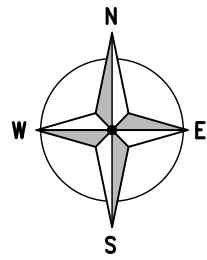

3982 00


3981 00

3836 00

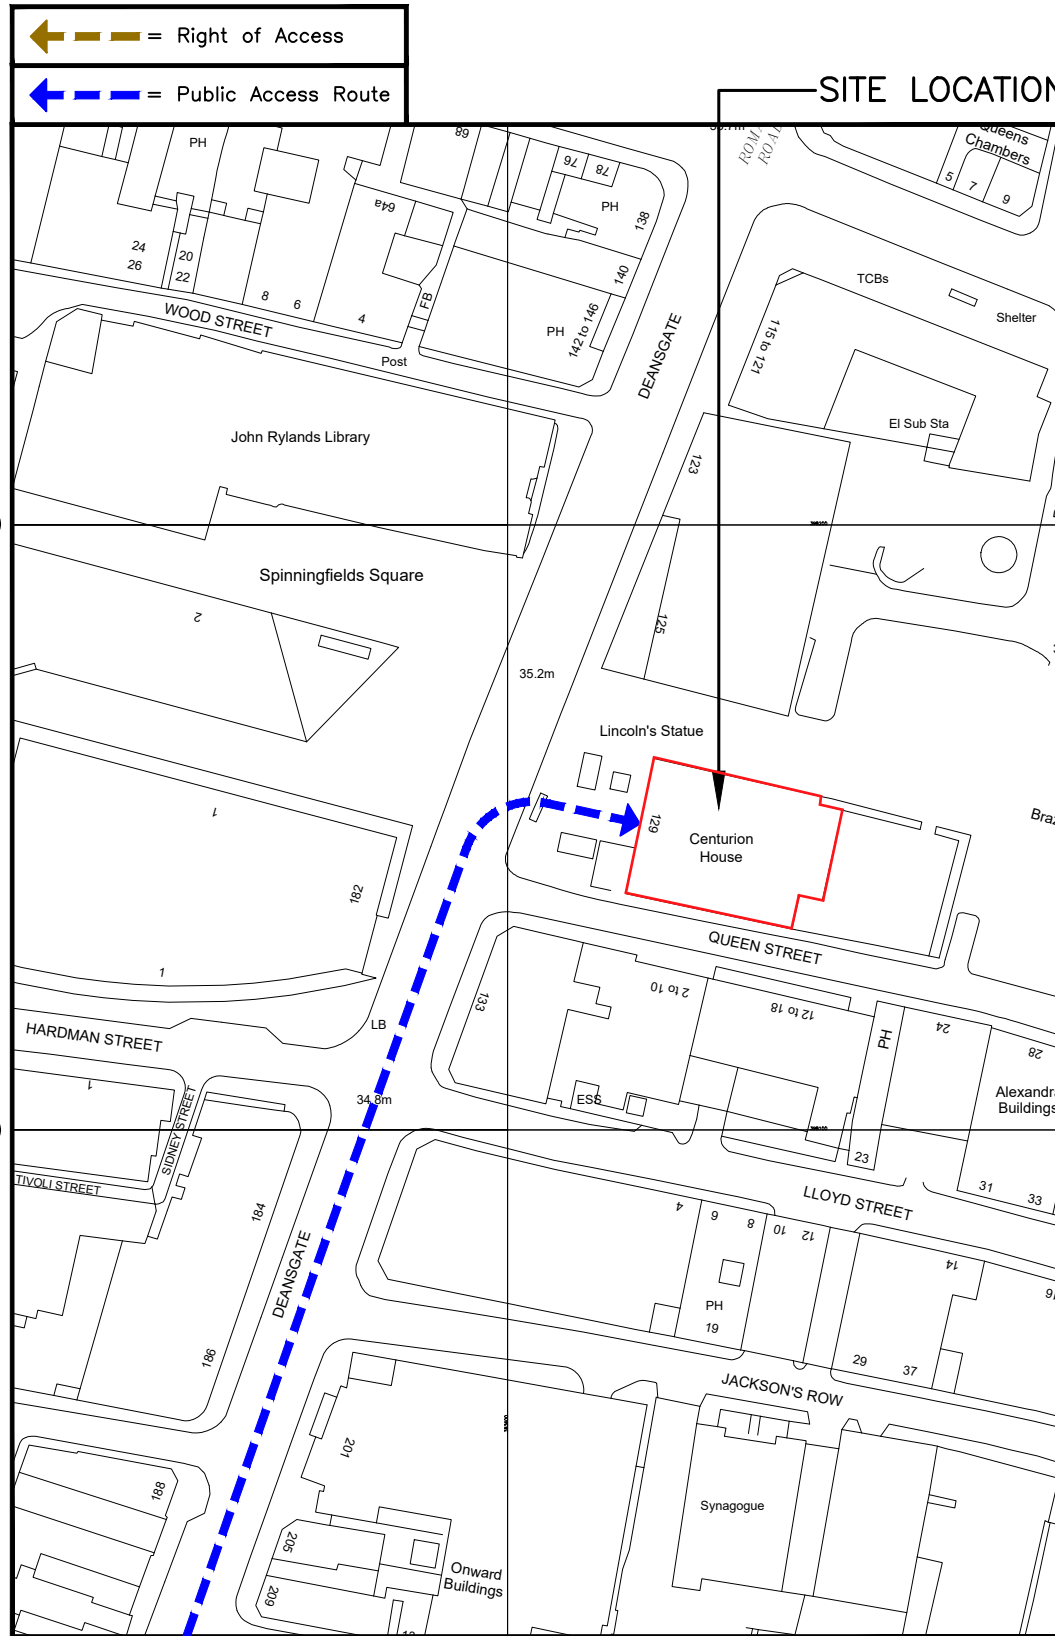

DETAILED SITE LOCATION
(Scale 1:1250)

 Based upon Ordnance Survey map extract
with the permission of the Controller of
Her Majesty's Stationery Office.
Crown copyright.
Licence No. 100022432



SCALE 1:1250

ALL DIMENSIONS ARE IN mm UNLESS NOTED OTHERWISE

N.G.R | E: 383637 N: 398148

DIRECTIONS TO SITE:
FROM THE END OF THE M602, CONTINUE
ALONG REGENT ROAD/A57 TOWARDS
MANCHESTER. AFTER 1.2km, VEER LEFT
TOWARDS RING ROAD/A6042. AFTER 50m,
TURN LEFT ONTO RING ROAD/A6042. AFTER
110m, TURN RIGHT ONTO WATER
STREET/A6143. AFTER 200m, TURN RIGHT
ONTO LIVERPOOL ROAD/A6143. AFTER 550m,
TURN LEFT ONTO DEANSGATE/A56. CENTURION
HOUSE IS ON THE RIGHT AFTER 500m.

NOTES:

A	Issued for Approval	CS	MC	05.08.21
REV	MODIFICATION	BY	CH	DATE

CLARKE
telecom
Unit E, Madison Place, Northampton Road,
Manchester, M40 5AG
Tel: 0161 785 4500
Fax: 0161 785 4501
Web: www.clarke-telecom.com

O₂

CORNERSTONE - BEACON 3

Cell Name		Opt.
CENTURION HOUSE		A
Cell ID No		
CORNERSTONE	TEF	VF
129400_26 E307802	092661	79290


Site Address / Contact Details

DEANSGATE
MANCHESTER
GREATER MANCHESTER
M3 3WR

Drawing Title:
SITE LOCATION MAPS

Purpose of issue:		Dwg Rev:
PLANNING		
Drawing Number:		A
100		
Surveyed By:	Original Sheet Size:	Pack Issue:
DW	A3	
Drawn:	Date:	Checked:
CS	05.08.21	MC
		Date:
		05.08.21
		B

The drawings comply with TEF & Vodafone Standard ICNIRP guidelines.
Designed in accordance with CORNERSTONE document: SDN0008

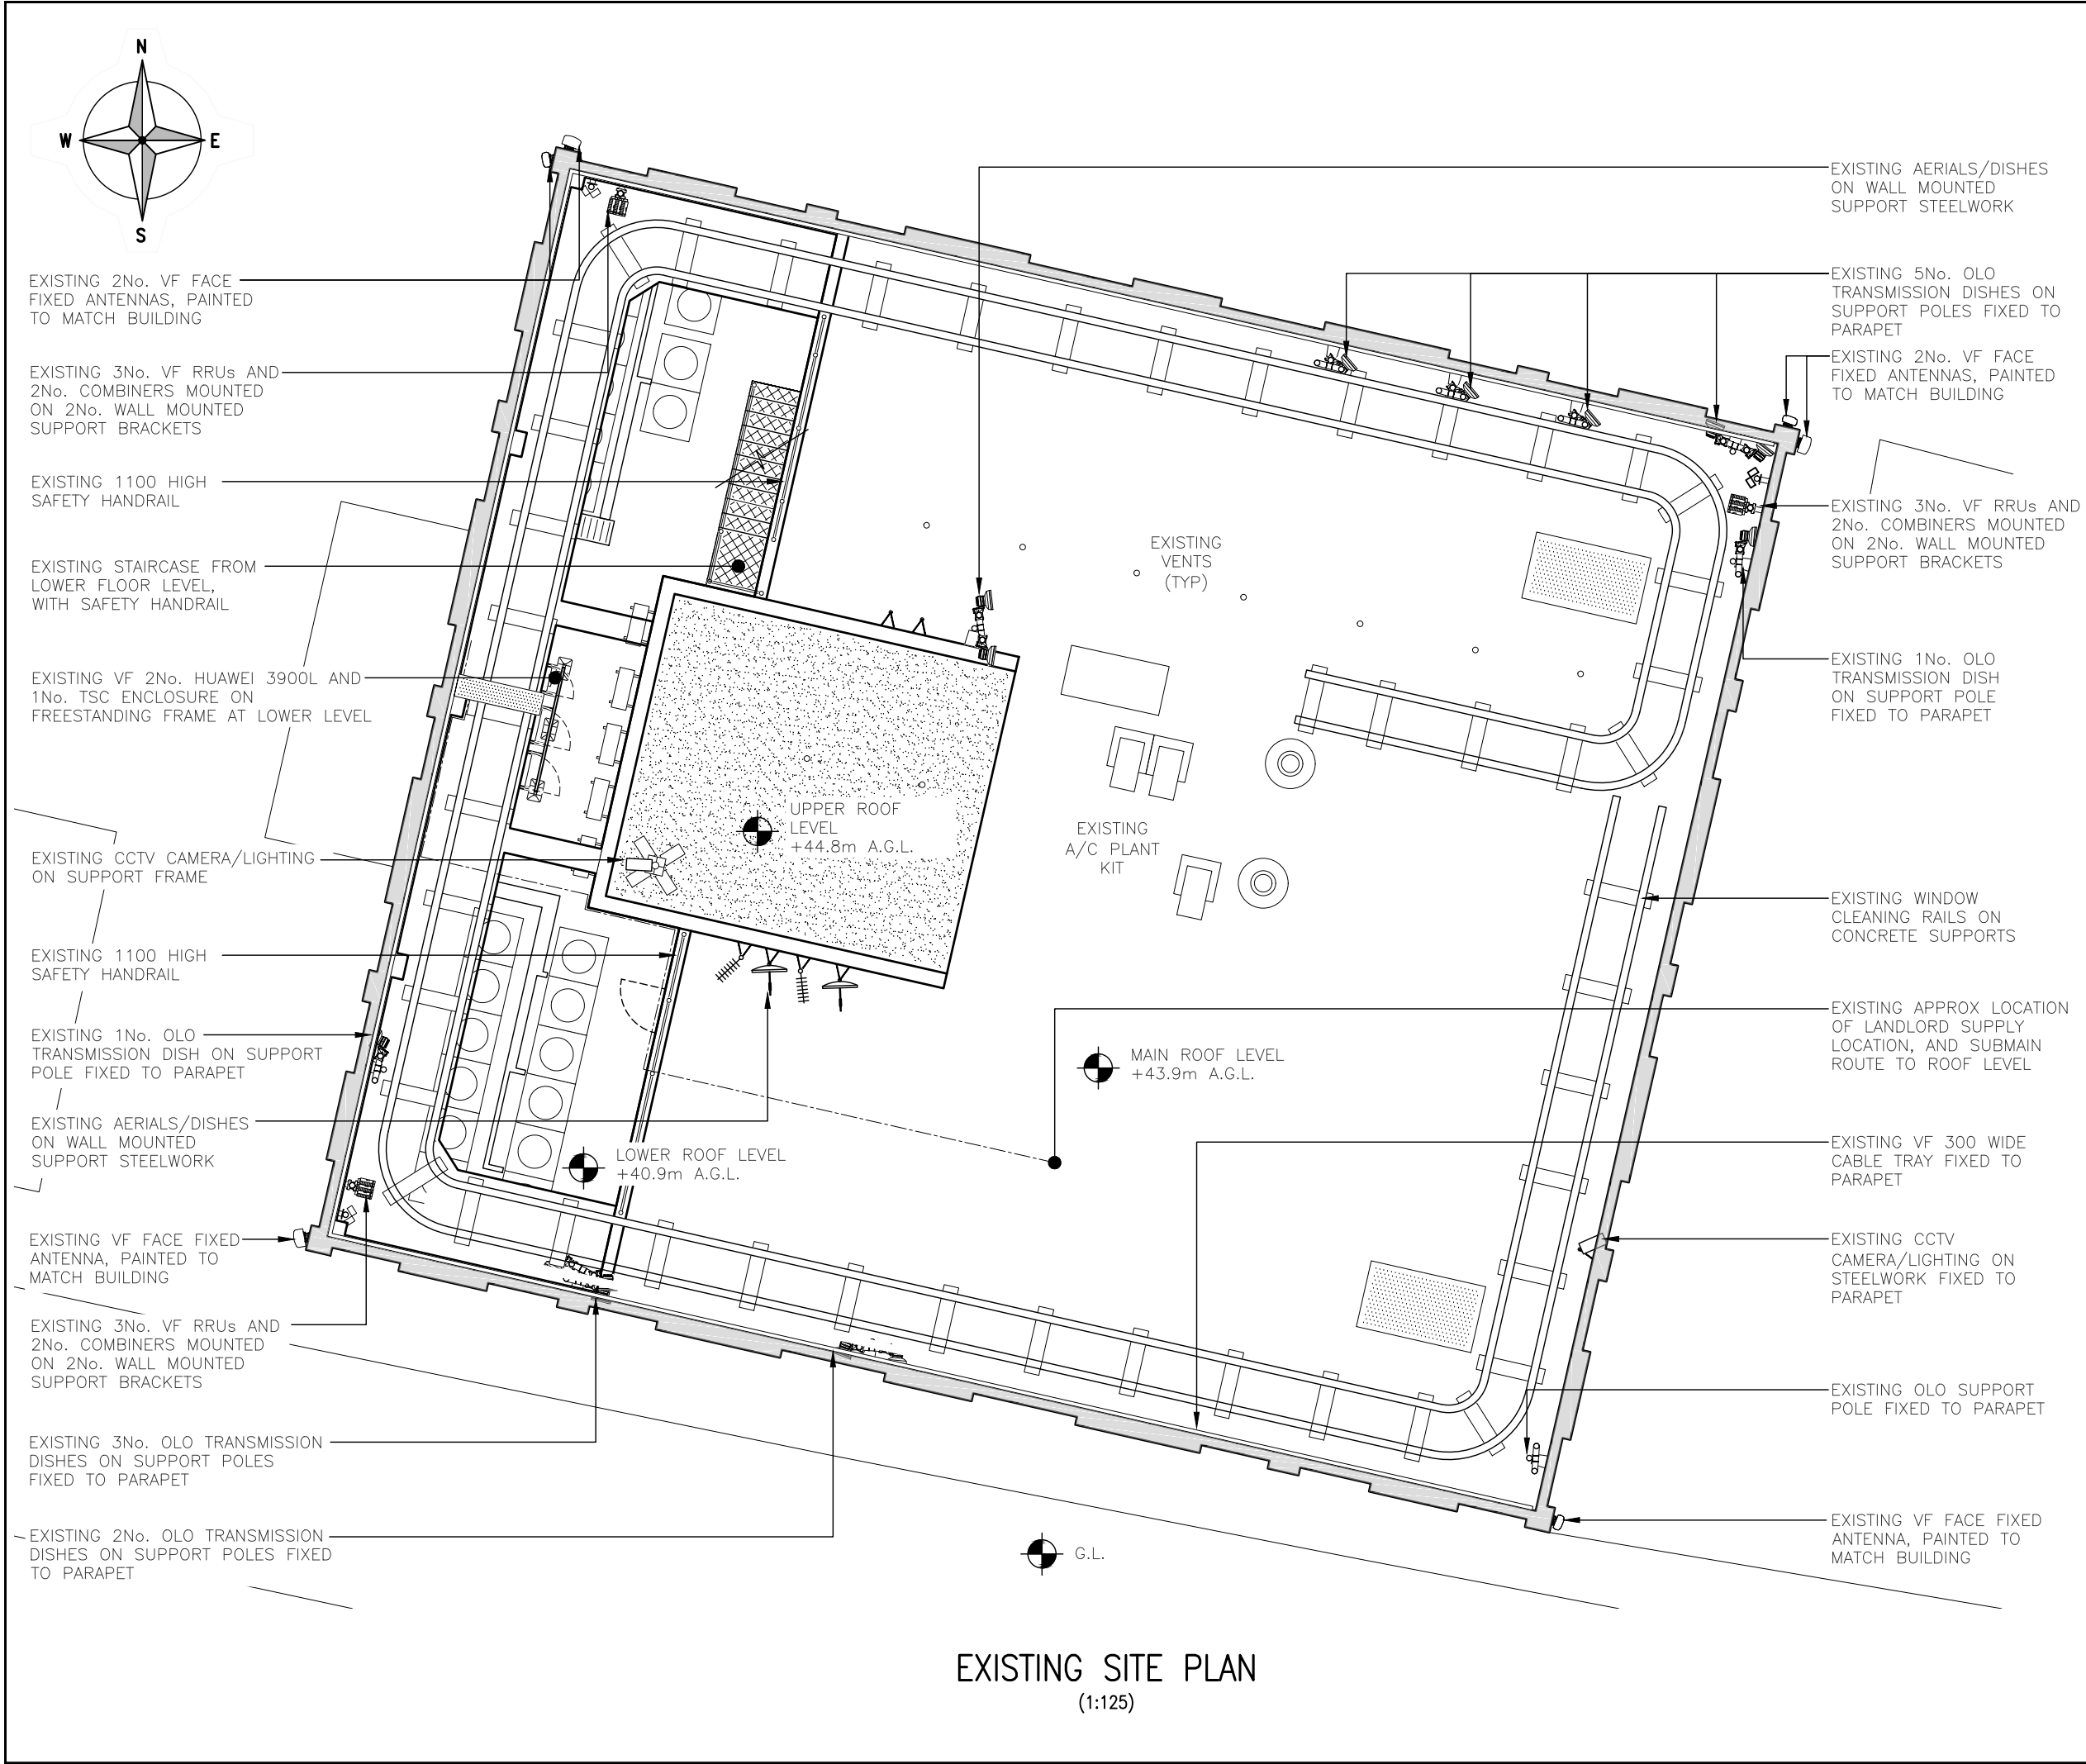

EXISTING SITE PLAN
(1:125)

ALL DIMENSIONS ARE IN mm UNLESS NOTED OTHERWISE

N.G.R | E: 383637 | N: 398148

NOTES:

A	Issued for Approval	CS	MC	05.08.21
REV	MODIFICATION	BY	CH	DATE



Unit E, Madison Place, Northampton Road,
Manchester, M40 5AG
Tel: 0161 785 4500
Fax: 0161 785 4501
Web: www.clarke-telecom.com




CORNERSTONE - BEACON 3

Cell Name	Opt.
CENTURION HOUSE	A

Cell ID No		
CORNERSTONE	TEF	VF
129400_26 E307802	092661	79290

Site Address / Contact Details		
DEANSGATE MANCHESTER GREATER MANCHESTER M3 3WR		

Drawing Title: EXISTING SITE PLAN			
Purpose of issue: PLANNING			Dwg Rev:
Drawing Number: 200			A
Surveyed By: DW		Original Sheet Size: A3	Pack Issue:
Drawn: CS	Date: 05.08.21	Checked: MC	Date: 05.08.21
			B

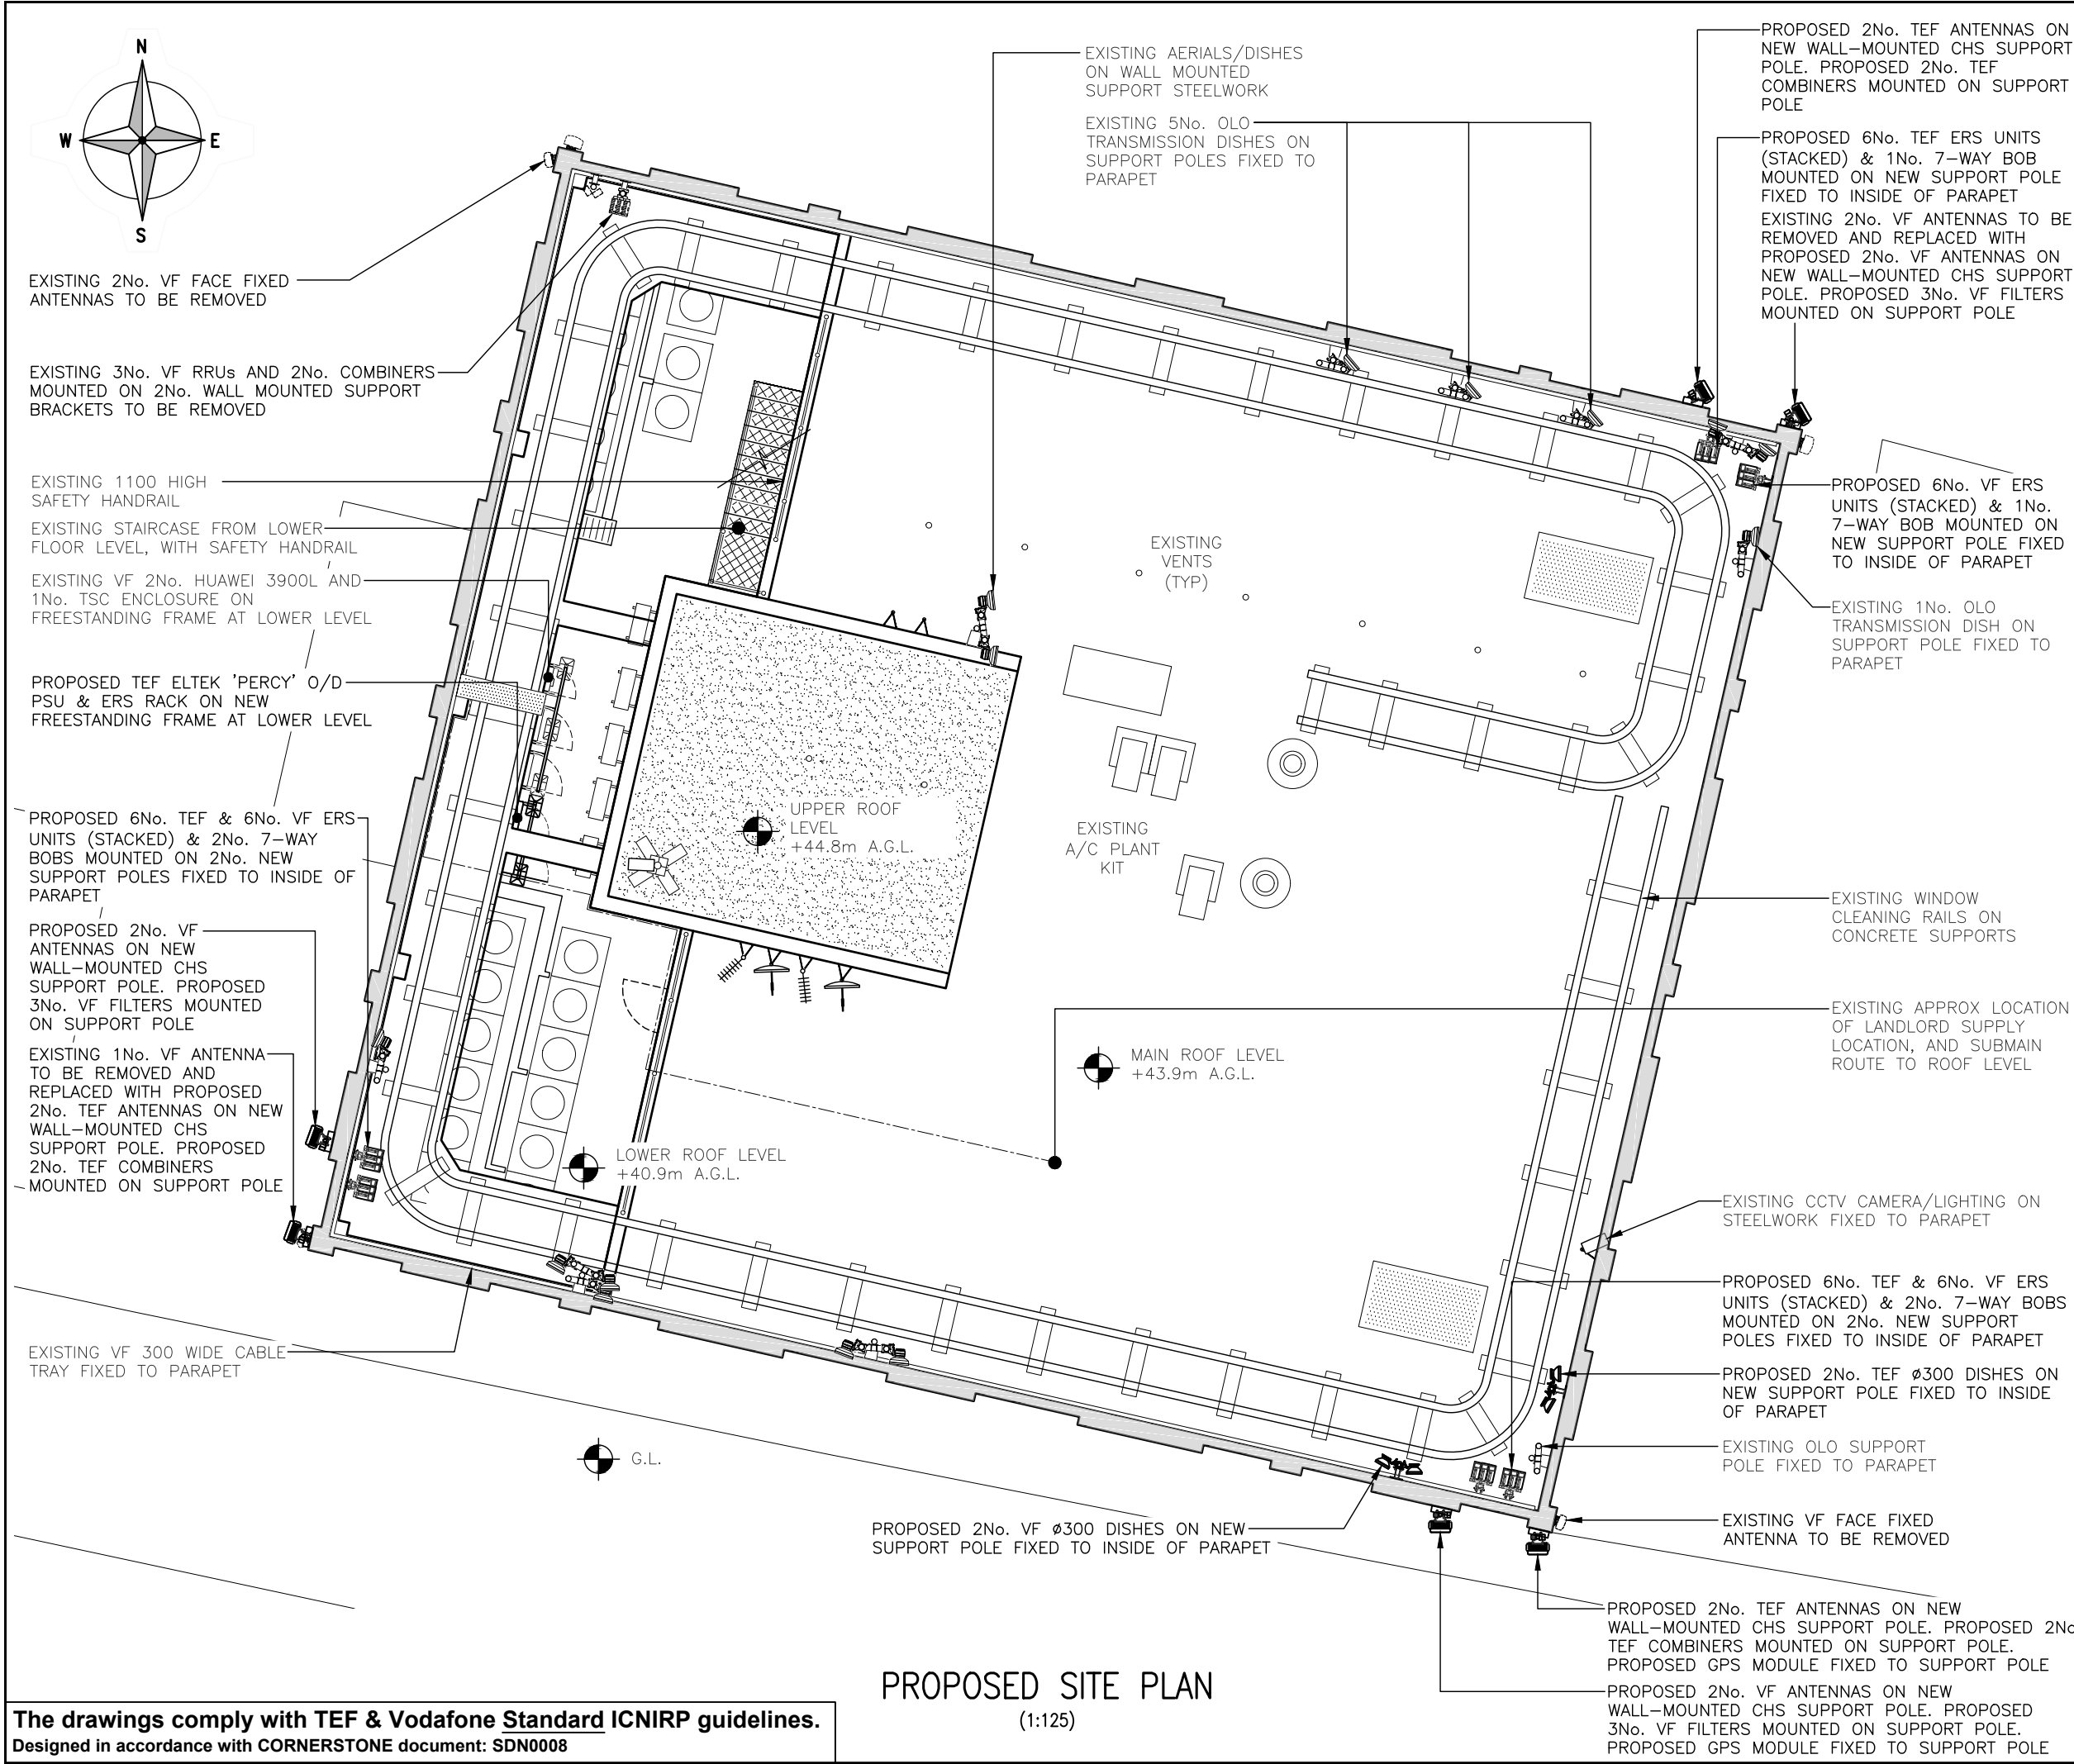

ALL DIMENSIONS ARE IN mm UNLESS NOTED OTHERWISE

N.G.R

E: 383637

N: 398148

NOTES:

B	S2 Relocated / Dishes Added	CS	MC	28.10.21
A	Issued for Approval	CS	MC	05.08.21
REV	MODIFICATION	BY	CH	DATE

CLARKEtelecom

Unit E, Madison Place, Northampton Road,
Manchester, M40 5AG
Tel: 0161 785 4500
Fax: 0161 785 4501
Web: www.clarke-telecom.com

O₂

CORNERSTONE - BEACON 3

Cell Name		Opt.
CENTURION HOUSE		A
Cell ID No		
CORNERSTONE	TEF	VF
129400_26 E307802	092661	79290

Site Address / Contact Details

DEANSGATE
MANCHESTER
GREATER MANCHESTER
M3 3WR

Drawing Title:
PROPOSED SITE PLAN

Purpose of issue:		Dwg Rev:		
PLANNING				
Drawing Number:				
201		B		
Surveyed By:		Pack Issue:		
DW				
Original Sheet Size:				
A3				
Drawn:	Date:	Checked:	Date:	
CS	05.08.21	MC	05.08.21	B

The drawings comply with TEF & Vodafone Standard ICNIRP guidelines.
Designed in accordance with CORNERSTONE document: SDN0008

PROPOSED SITE PLAN
(1:125)

EXISTING 2No. VF FACE
FIXED ANTENNAS, PAINTED
TO MATCH BUILDING

TOP OF EXISTING VF ANTENNAS
+44.30m A.G.L.

U/S OF EXISTING VF ANTENNAS
+42.30m A.G.L.

EXISTING 3No. VF RRUs AND 2No.
COMBINERS MOUNTED ON 2No. WALL
MOUNTED SUPPORT BRACKETS (BEHIND)

EXISTING 3No. VF RRUs AND 2No.
COMBINERS MOUNTED ON 2No. WALL
MOUNTED SUPPORT BRACKETS (BEHIND)


EXISTING VF FACE FIXED ANTENNA,
PAINTED TO MATCH BUILDING

PARAPET LEVEL
+44.60m A.G.L.

MAIN ROOF LEVEL
+43.90m A.G.L.

LOWER ROOF LEVEL
+40.90m A.G.L.

EXISTING VF 2No. HUAWEI 3900L
CABINETS AND 1No. TSC ENCLOSURE ON
FREESTANDING FRAME AT LOWER LEVEL
(BEHIND)

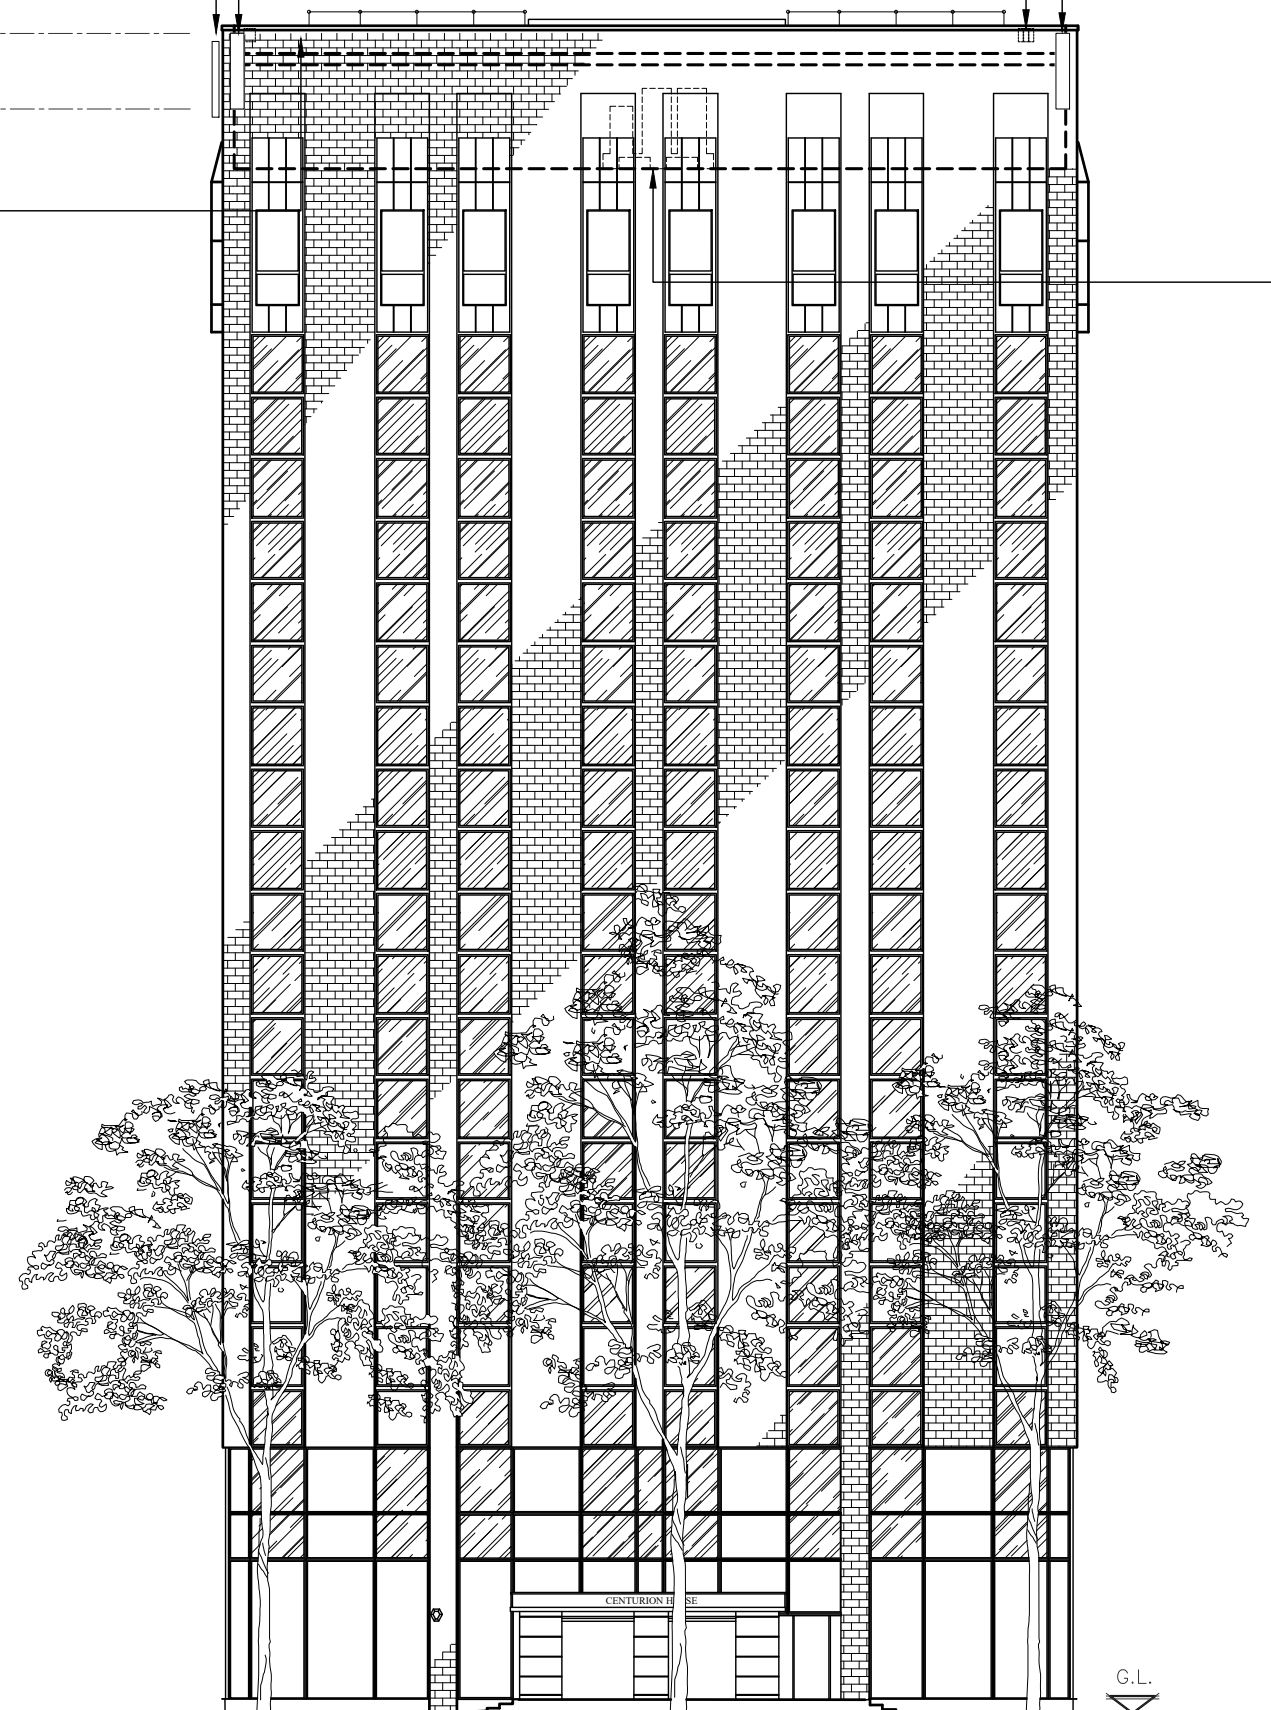

EXISTING NORTH WEST ELEVATION
(1:200)

ALL DIMENSIONS ARE IN mm UNLESS NOTED OTHERWISE

N.G.R | E: 383637 | N: 398148

NOTES:

A	Issued for Approval	CS	MC	05.08.21
REV	MODIFICATION	BY	CH	DATE

CLARKE
telecom
Unit E, Madison Place, Northampton Road,
Manchester, M40 5AG
Tel: 0161 785 4500
Fax: 0161 785 4501
Web: www.clarke-telecom.com

O₂


CORNERSTONE - BEACON 3

Cell Name	Opt.
CENTURION HOUSE	A

Cell ID No		
CORNERSTONE	TEF	VF
129400_26 E307802	092661	79290

Site Address / Contact Details		
DEANS_GATE MANCHESTER GREATER MANCHESTER M3 3WR		

Drawing Title: EXISTING NW SITE ELEVATION				
Purpose of issue: PLANNING				Dwg Rev:
Drawing Number: 300				A
Surveyed By: DW		Original Sheet Size: A3		Pack Issue:
Drawn: CS	Date: 05.08.21	Checked: MC	Date: 05.08.21	B

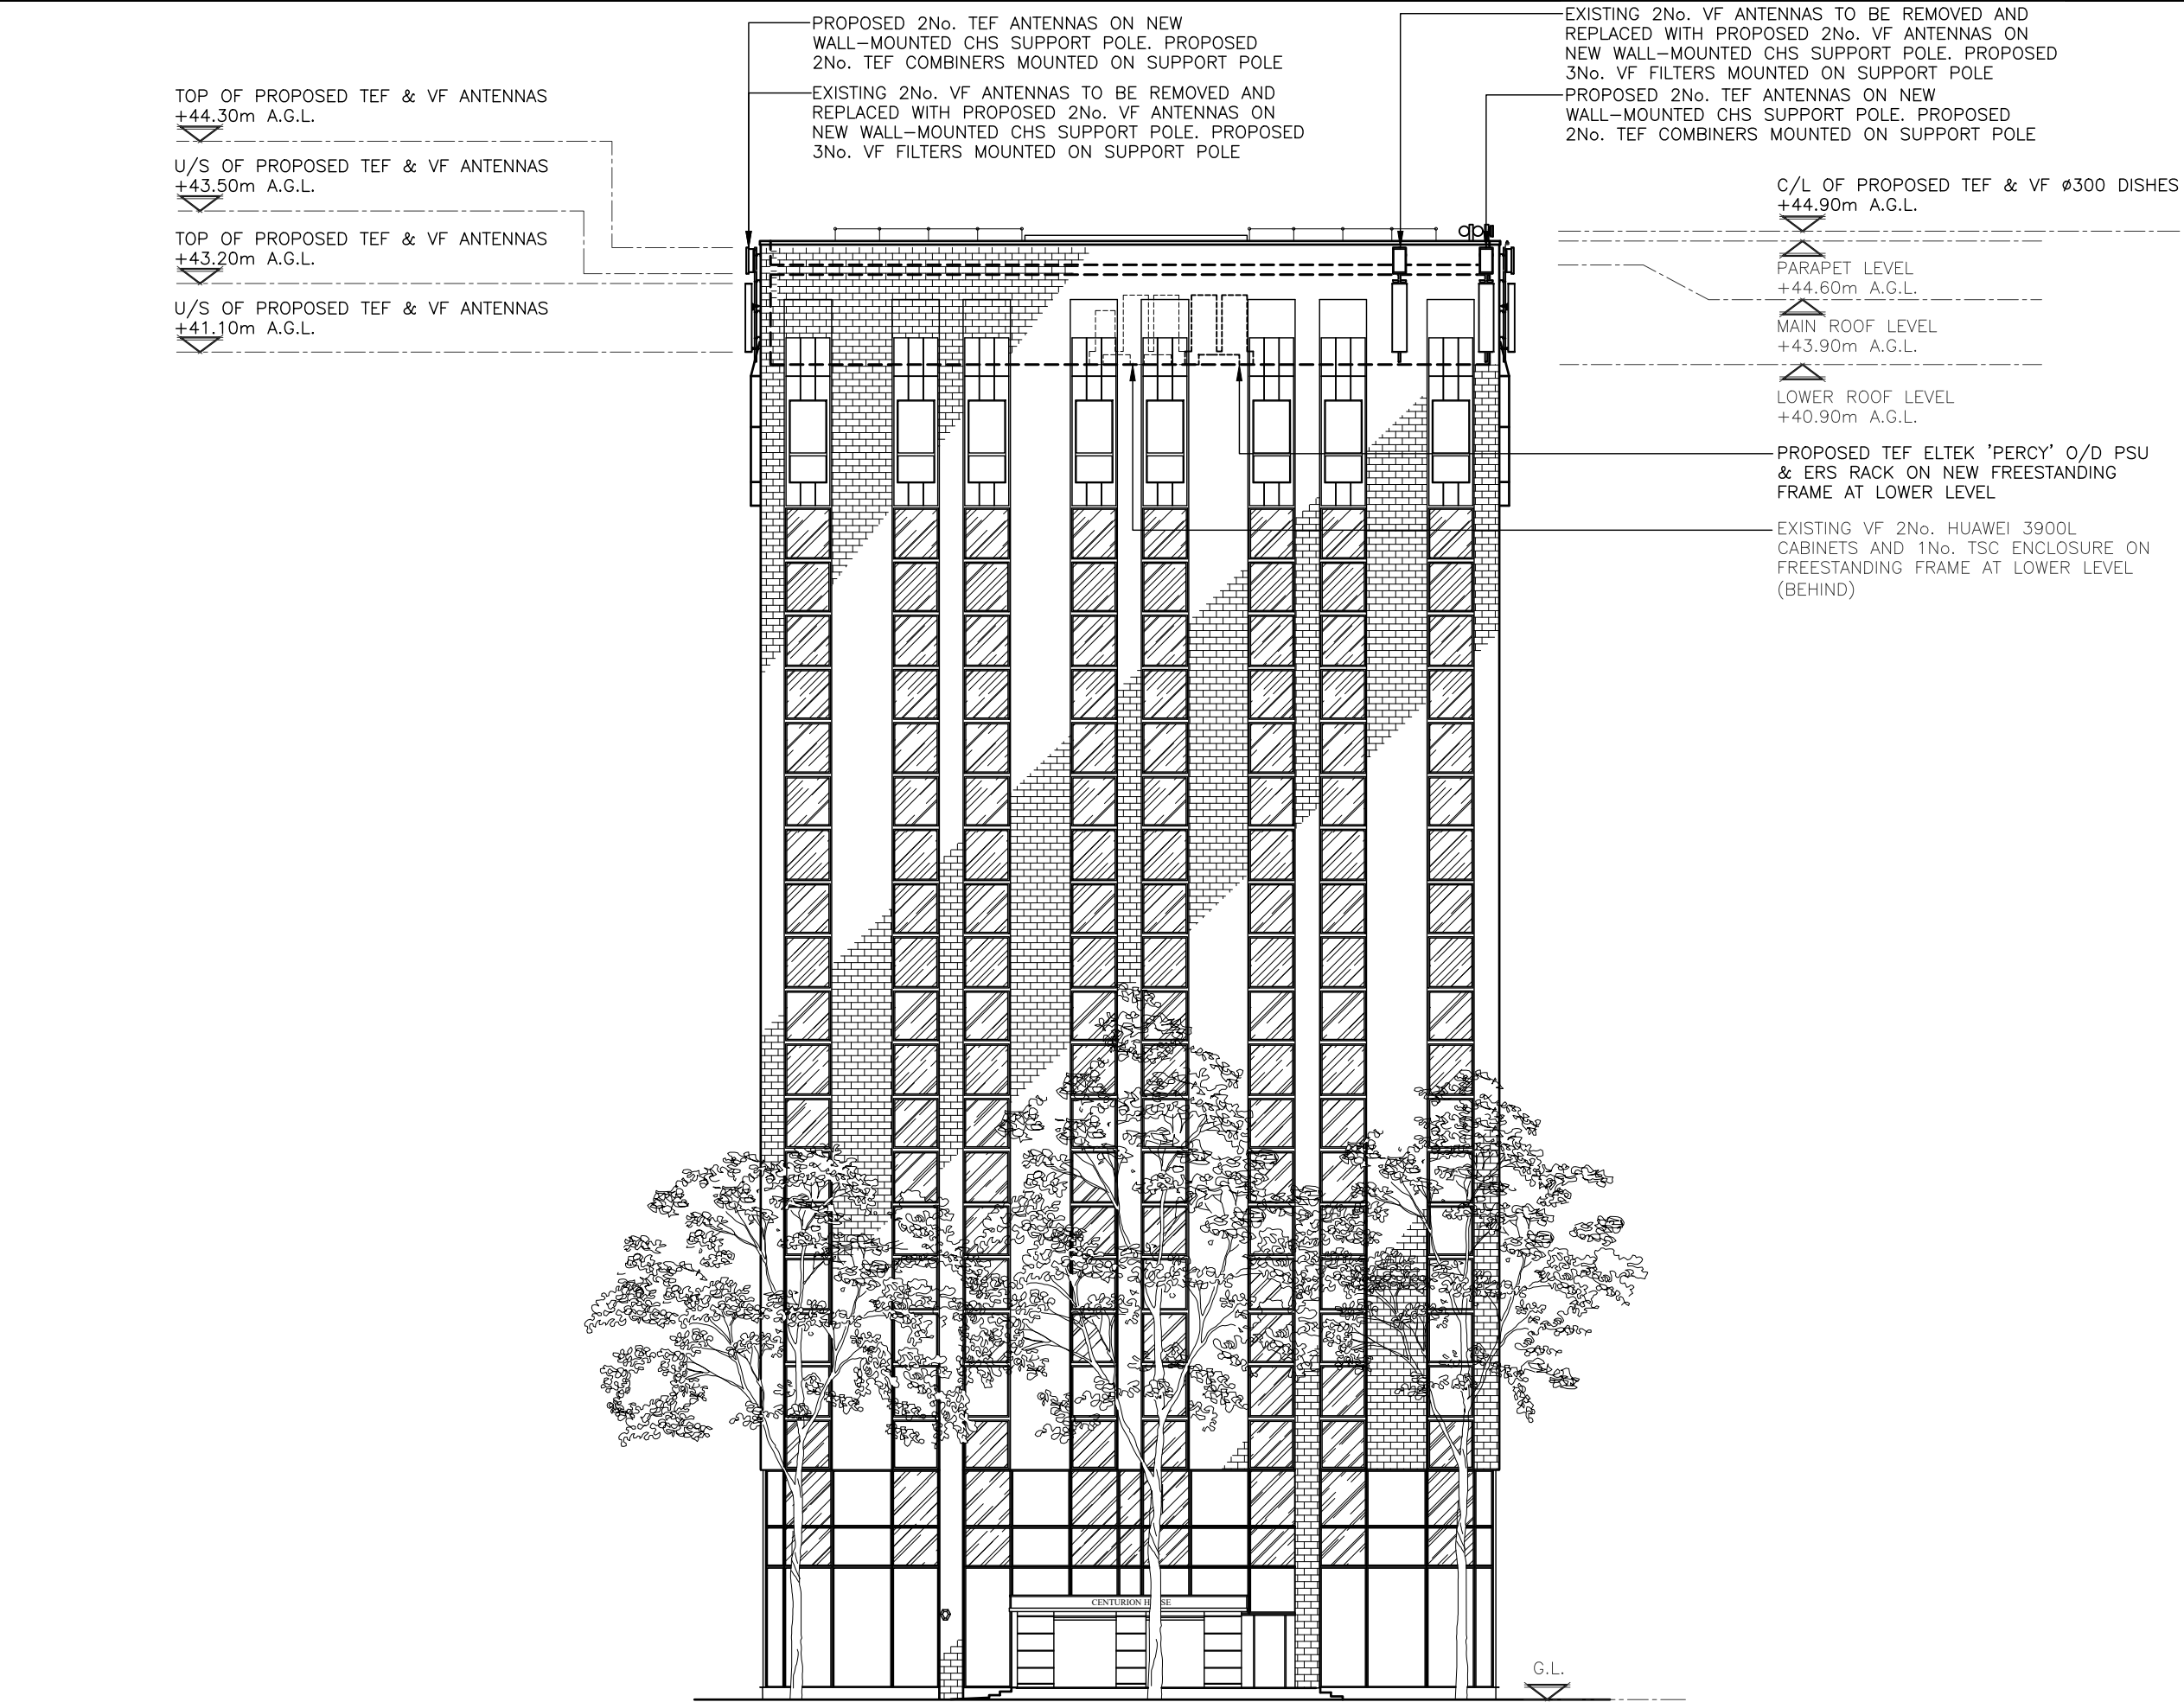

PROPOSED NORTH WEST ELEVATION
(1:200)

The drawings comply with TEF & Vodafone Standard ICNIRP guidelines.
Designed in accordance with CORNERSTONE document: SDN0008

ALL DIMENSIONS ARE IN mm UNLESS NOTED OTHERWISE

N.G.R

E: 383637

N: 398148

NOTES:

B	S2 Relocated / Dishes Added	CS	MC	28.10.21
A	Issued for Approval	CS	MC	05.08.21
REV	MODIFICATION	BY	CH	DATE

CLARKE
telecom

Unit E, Madison Place, Northampton Road,
Manchester, M40 5AG
Tel: 0161 785 4500
Fax: 0161 785 4501
Web: www.clarke-telecom.com

O₂

CORNERSTONE - BEACON 3

Cell Name		Opt.
CENTURION HOUSE		A
Cell ID No		
CORNERSTONE	TEF	VF
129400_26 E307802	092661	79290
Site Address / Contact Details		
DEANSGATE MANCHESTER GREATER MANCHESTER M3 3WR		
Drawing Title: PROPOSED NW SITE ELEVATION		
Purpose of issue: PLANNING		Dwg Rev:
Drawing Number: 301		B
Surveyed By: DW	Original Sheet Size: A3	Pack Issue:
Drawn: CS	Date: 05.08.21	Checked: MC
	Date: 05.08.21	B

EXISTING 2No. VF FACE
FIXED ANTENNAS, PAINTED
TO MATCH BUILDING

TOP OF EXISTING VF ANTENNAS
+44.30m A.G.L.

U/S OF EXISTING VF ANTENNAS
+42.30m A.G.L.

EXISTING 3No. VF RRUs AND
2No. COMBINERS MOUNTED ON
2No. WALL MOUNTED SUPPORT
BRACKETS (BEHIND)

EXISTING 2No. VF FACE FIXED ANTENNAS,
PAINTED TO MATCH BUILDING

PARAPET LEVEL
+44.60m A.G.L.

MAIN ROOF LEVEL
+43.90m A.G.L.

LOWER ROOF LEVEL
+40.90m A.G.L.

EXISTING 3No. VF RRUs AND
2No. COMBINERS MOUNTED ON
2No. WALL MOUNTED SUPPORT
BRACKETS (BEHIND)

EXISTING VF 2No. HUAWEI 3900L AND 1No.
TSC ENCLOSURE ON FREESTANDING FRAME
AT LOWER LEVEL (BEHIND)

G.L.

EXISTING NORTH EAST ELEVATION
(1:200)

ALL DIMENSIONS ARE IN mm UNLESS NOTED OTHERWISE

N.G.R | E: 383637 N: 398148

NOTES:

A	Issued for Approval	CS	MC	05.08.21
REV	MODIFICATION	BY	CH	DATE

CLARKE
telecom

Unit E, Madison Place, Northampton Road,
Manchester, M40 5AG
Tel: 0161 785 4500
Fax: 0161 785 4501
Web: www.clarke-telecom.com

O₂

CORNERSTONE - BEACON 3

Cell Name	Opt.
CENTURION HOUSE	A

Cell ID No		
CORNERSTONE	TEF	VF
129400_26 E307802	092661	79290

Site Address / Contact Details	
DEANS GATE MANCHESTER GREATER MANCHESTER M3 3WR	

Drawing Title: EXISTING NE SITE ELEVATION			
Purpose of issue: PLANNING			Dwg Rev: A
Drawing Number: 302			A
Surveyed By: DW		Original Sheet Size: A3	
Drawn: CS		Date: 05.08.21	Pack Issue: B
		Checked: MC	Date: 05.08.21

U/S OF PROPOSED TEF & VF ANTENNAS
+41.10m A.G.L.

—PROPOSED 2No. TEF ANTENNAS ON NEW
WALL-MOUNTED CHS SUPPORT POLE. PROPOSED
2No. TEF COMBINERS MOUNTED ON SUPPORT POLE

—PROPOSED 2No. TEF ANTENNAS ON NEW
WALL-MOUNTED CHS SUPPORT POLE. PROPOSED
2No. TEF COMBINERS MOUNTED ON SUPPORT POLE

— EXISTING VF 2No. HUAWEI 3900L
CABINETS AND 1No. TSC ENCLOSURE ON
FREESTANDING FRAME AT LOWER LEVEL
(BEHIND)

NOTES:

B	S2 Relocated / Dishes Added	CS	MC	28.10.21
A	Issued for Approval	CS	MC	05.08.21

REV	MODIFICATION	BY	CH	DATE
-----	--------------	----	----	------



CENTURION HOUSE

CORNERSTONE	TEF	VF
-------------	-----	----

129400_26 E307802	092661	79290
----------------------	--------	-------

DEANS
MANCHESTER
GREATER MANCHESTER
M3 3WR


Purpose of issue:	PLANNING	Dwg Rev:
-------------------	----------	-------------

Drawing Number:	303	B
-----------------	-----	---

Surveyed By: DW	Original Sheet Size: A3	Pack Issue:
--------------------	----------------------------	----------------

Drawn: CS	Date: 05.08.21	Checked: MC	Date: 05.08.21	B
--------------	-------------------	----------------	-------------------	---

The drawings comply with TEF & Vodafone Standard ICNIRP guidelines.
Designed in accordance with CORNERSTONE document: SDN0008

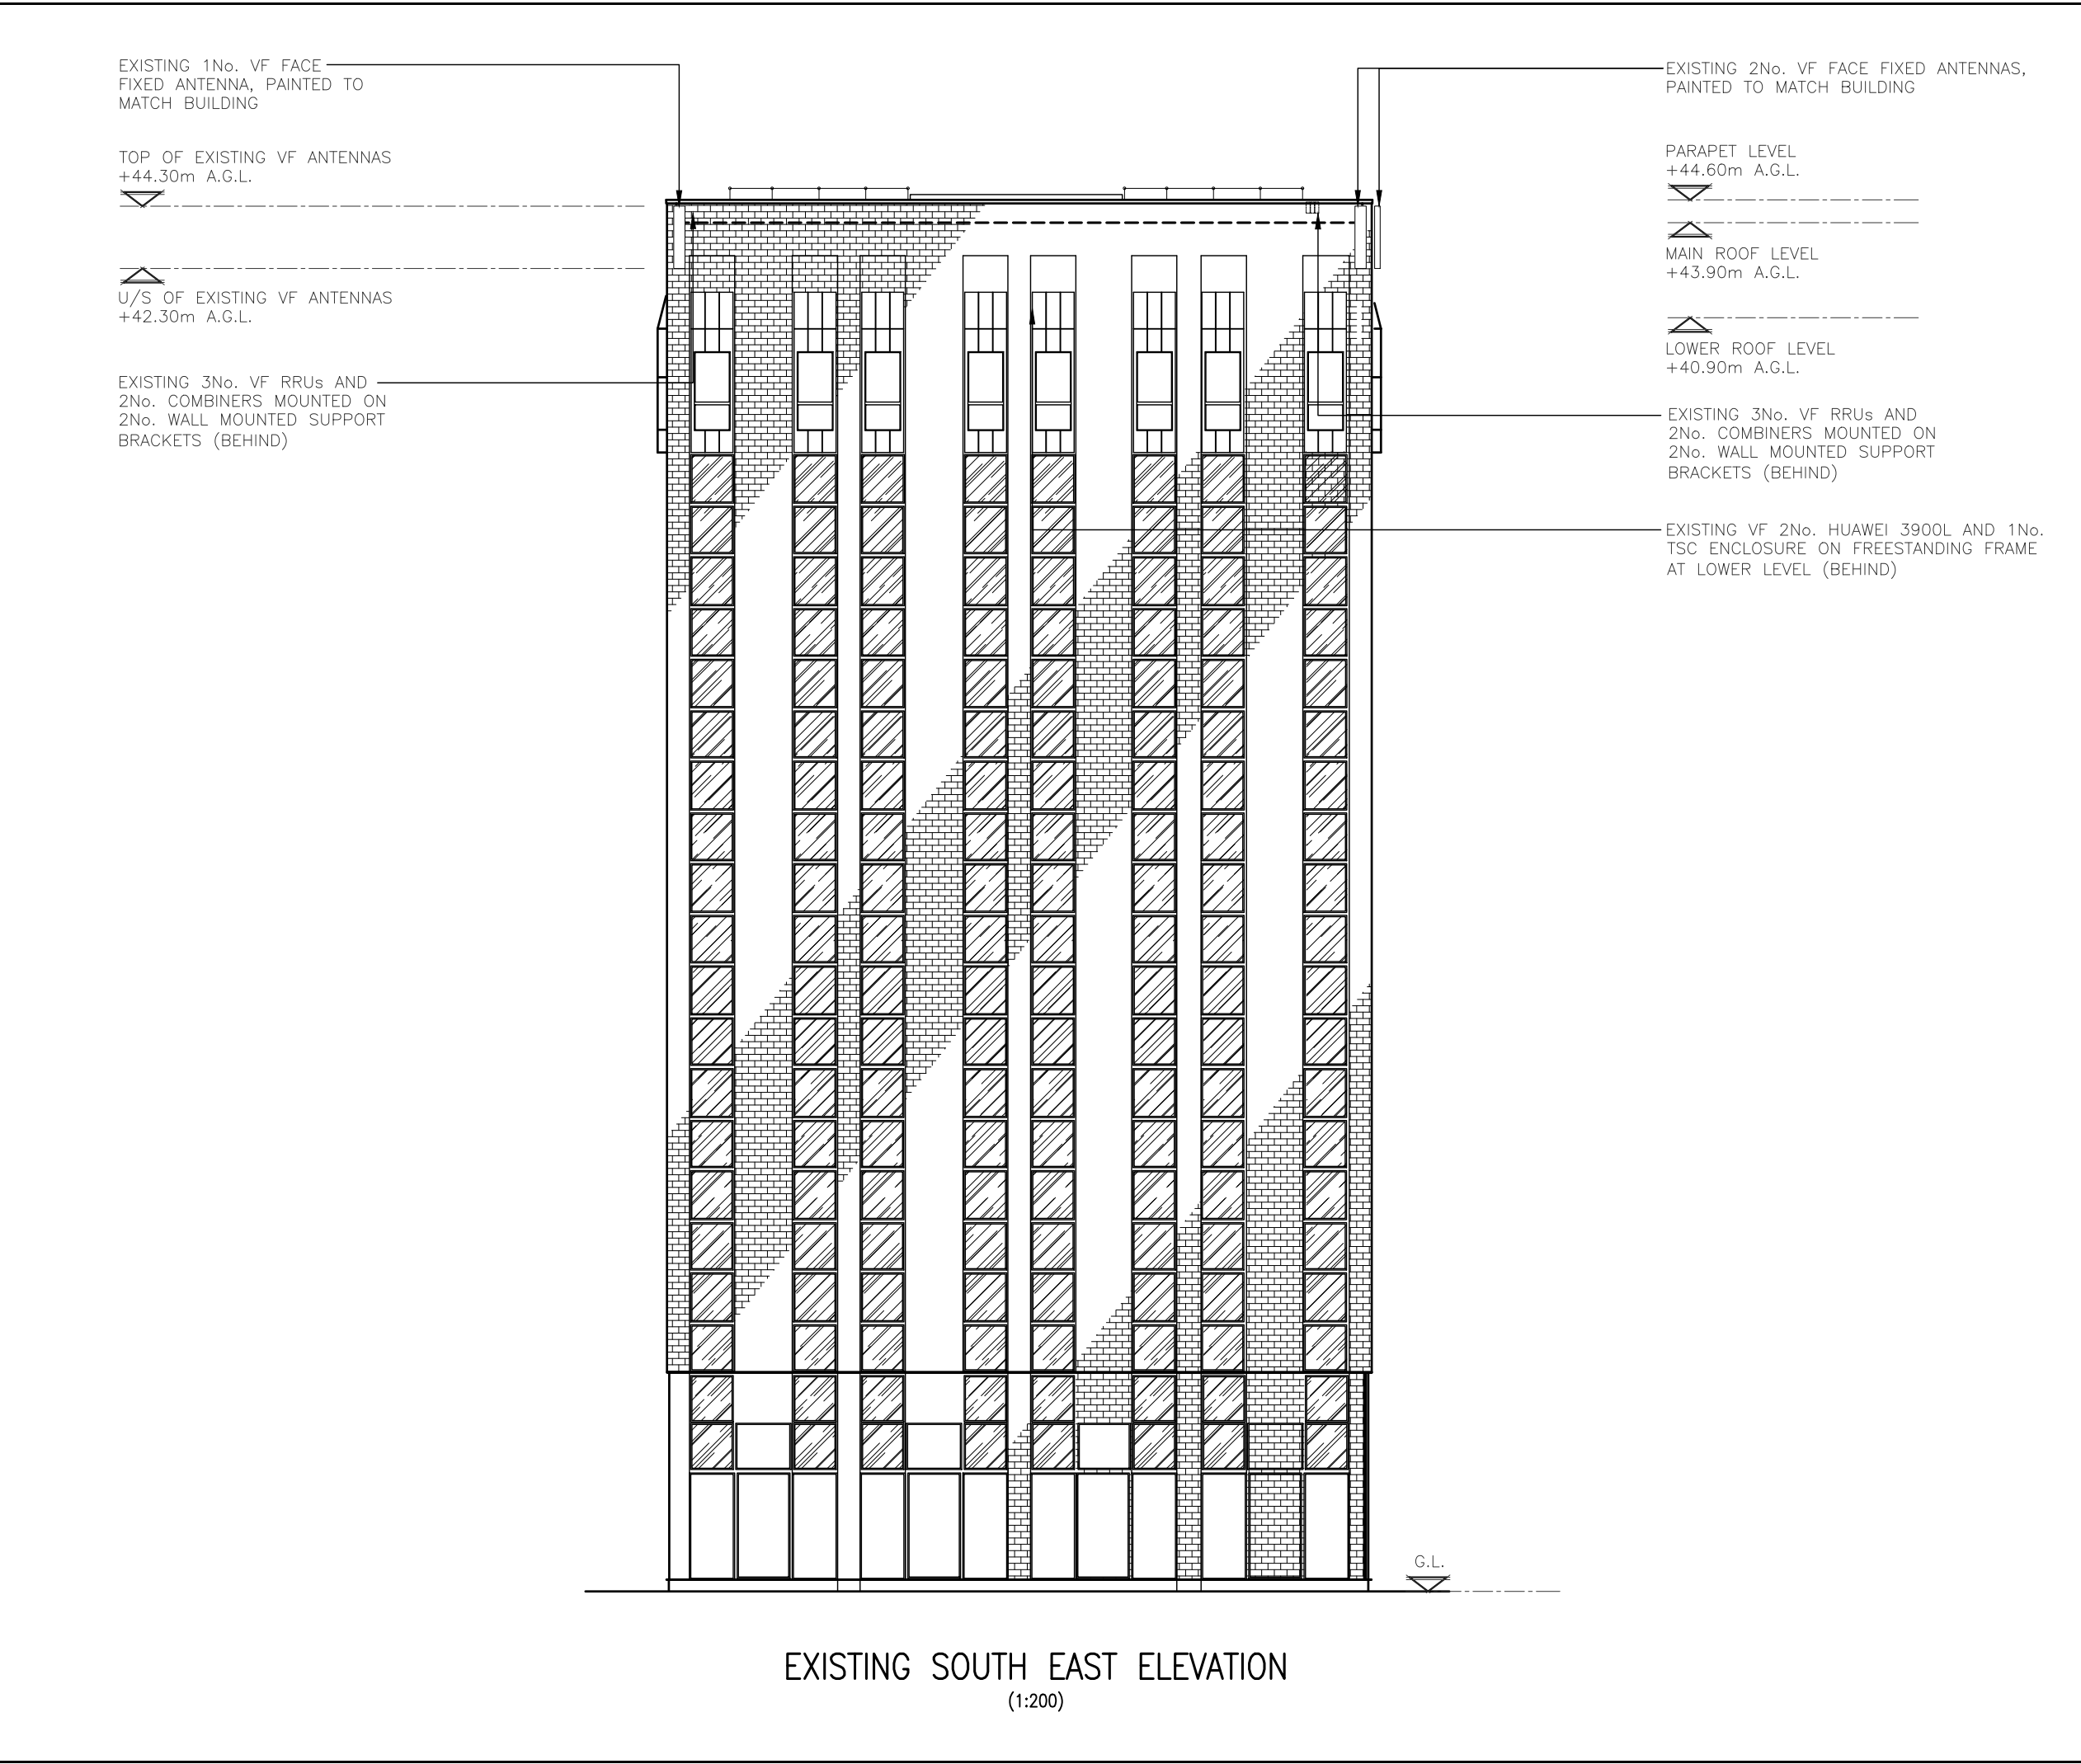

ALL DIMENSIONS ARE IN mm UNLESS NOTED OTHERWISE

N.G.R

E: 383637

N: 398148

NOTES:

A	Issued for Approval	CS	MC	05.08.21
REV	MODIFICATION	BY	CH	DATE

CLARKE

telecom

Unit E, Madison Place, Northampton Road,
Manchester, M40 5AG
Tel: 0161 785 4500
Fax: 0161 785 4501
Web: www.clarke-telecom.com

O₂

CORNERSTONE - BEACON 3

Cell Name			Opt.
CENTURION HOUSE			A
Cell ID No			
CORNERSTONE	TEF	VF	
129400_26 E307802	092661	79290	
Site Address / Contact Details			
DEANS_GATE MANCHESTER GREATER MANCHESTER M3 3WR			

Drawing Title:
EXISTING SE SITE ELEVATION

Purpose of issue:			Dwg Rev:
PLANNING			
Drawing Number:			A
304			
Surveyed By:		Original Sheet Size:	Pack Issue:
DW		A3	
Drawn:	Date:	Checked:	Date:
CS	05.08.21	MC	05.08.21
			B

C/L OF PROPOSED TEF & VF Ø300 DISHES
+44.90m A.G.L.

TOP OF PROPOSED TEF & VF ANTENNAS
+44.30m A.G.L.

U/S OF PROPOSED TEF & VF ANTENNAS
+43.50m A.G.L.

TOP OF PROPOSED TEF & VF ANTENNAS
+43.20m A.G.L.

U/S OF PROPOSED TEF & VF ANTENNAS
+41.10m A.G.L.

PROPOSED TEF ELTEK 'PERCY' O/D PSU
& ERS RACK ON NEW FREESTANDING
FRAME AT LOWER LEVEL

EXISTING VF 2No. HUAWEI 3900L
CABINETS AND 1No. TSC ENCLOSURE ON
FREESTANDING FRAME AT LOWER LEVEL
(BEHIND)

PROPOSED 2No. VF ANTENNAS ON NEW WALL-MOUNTED
CHS SUPPORT POLE. PROPOSED 3No. VF FILTERS
MOUNTED ON SUPPORT POLE. PROPOSED GPS MODULE
FIXED TO SUPPORT POLE

PROPOSED 2No. TEF ANTENNAS ON NEW
WALL-MOUNTED CHS SUPPORT POLE. PROPOSED
2No. TEF COMBINERS MOUNTED ON SUPPORT POLE.
PROPOSED GPS MODULE FIXED TO SUPPORT POLE


EXISTING 2No. VF ANTENNAS TO BE REMOVED AND
REPLACED WITH PROPOSED 2No. VF ANTENNAS ON
NEW WALL-MOUNTED CHS SUPPORT POLE. PROPOSED
3No. VF FILTERS MOUNTED ON SUPPORT POLE

PROPOSED 2No. TEF ANTENNAS ON NEW
WALL-MOUNTED CHS SUPPORT POLE. PROPOSED
2No. TEF COMBINERS MOUNTED ON SUPPORT POLE

PARAPET LEVEL
+44.60m A.G.L.

MAIN ROOF LEVEL
+43.90m A.G.L.

LOWER ROOF LEVEL
+40.90m A.G.L.

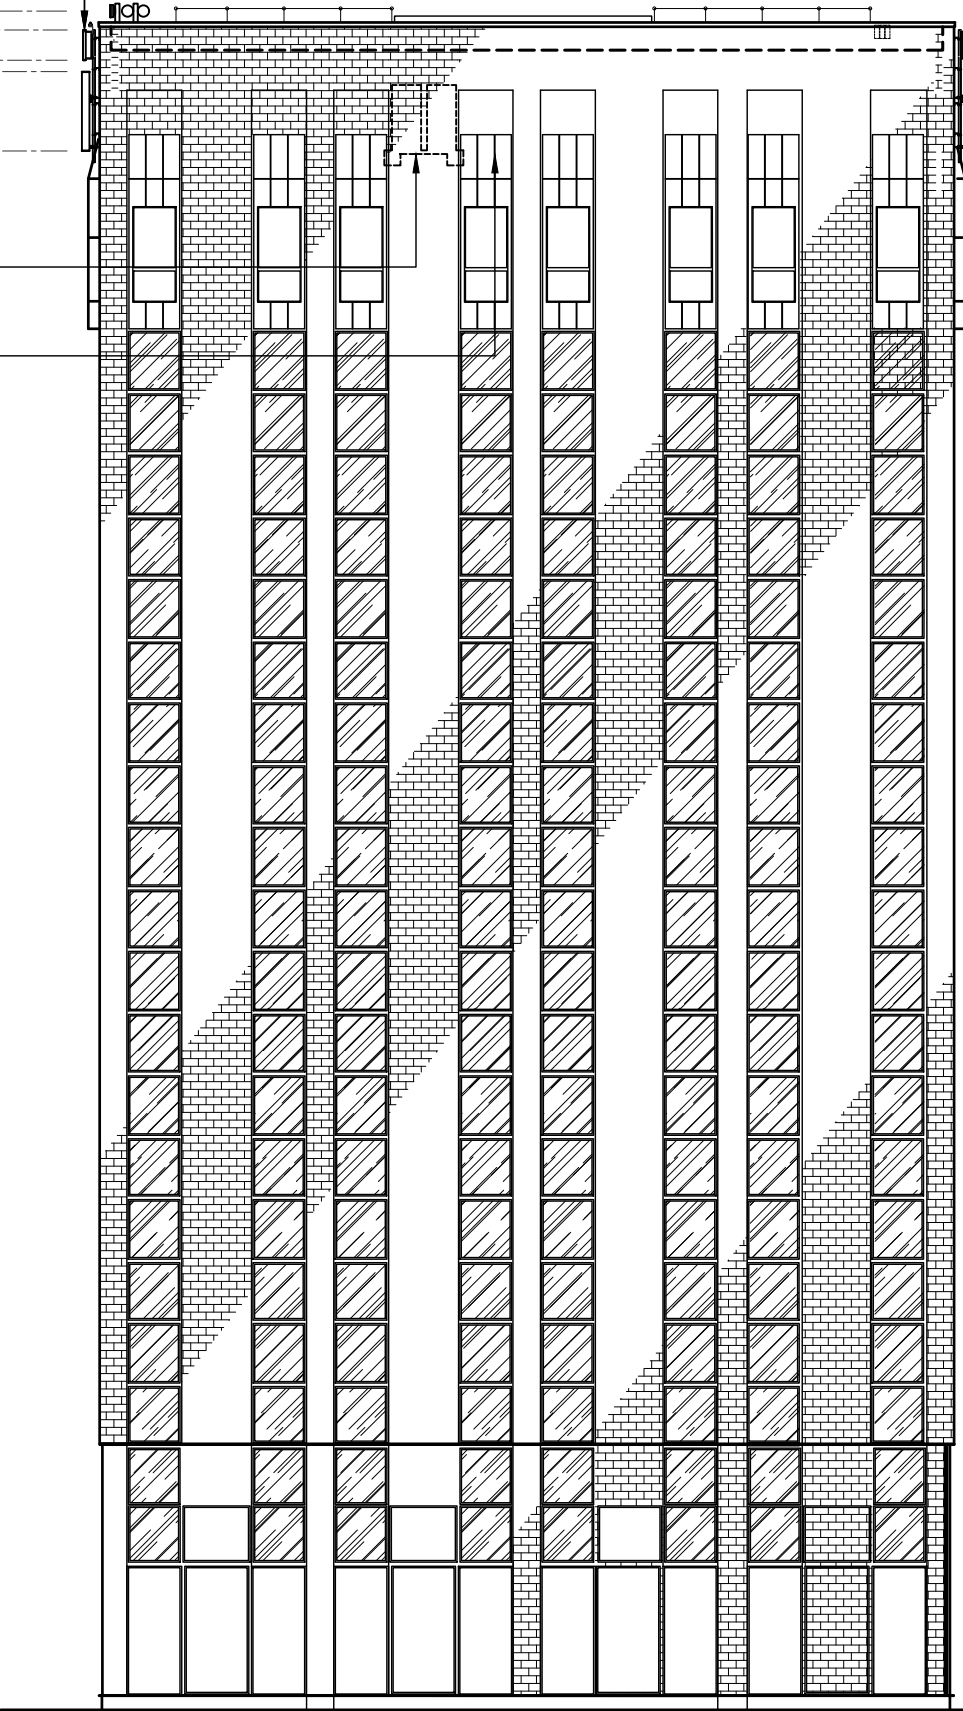

G.L.

PROPOSED SOUTH EAST ELEVATION

(1:200)

The drawings comply with TEF & Vodafone Standard ICNIRP guidelines.
Designed in accordance with CORNERSTONE document: SDN0008

ALL DIMENSIONS ARE IN mm UNLESS NOTED OTHERWISE

N.G.R | E: 383637 N: 398148

NOTES:

REV	MODIFICATION	BY	CH	DATE
B	S2 Relocated / Dishes Added	CS	MC	28.10.21
A	Issued for Approval	CS	MC	05.08.21



Unit E, Madison Place, Northampton Road,
Manchester, M40 5AG
Tel: 0161 785 4500
Fax: 0161 785 4501
Web: www.clarke-telecom.com




CORNERSTONE - BEACON 3

Cell Name	Opt.
CENTURION HOUSE	A

Cell ID No		
CORNERSTONE	TEF	VF
129400_26 E307802	092661	79290

Site Address / Contact Details		
DEANS_GATE MANCHESTER GREATER MANCHESTER M3 3WR		

Drawing Title: PROPOSED SE SITE ELEVATION				
Purpose of issue: PLANNING				Dwg Rev:
Drawing Number: 305				B
Surveyed By: DW		Original Sheet Size: A3		Pack Issue:
Drawn: CS	Date: 05.08.21	Checked: MC	Date: 05.08.21	B

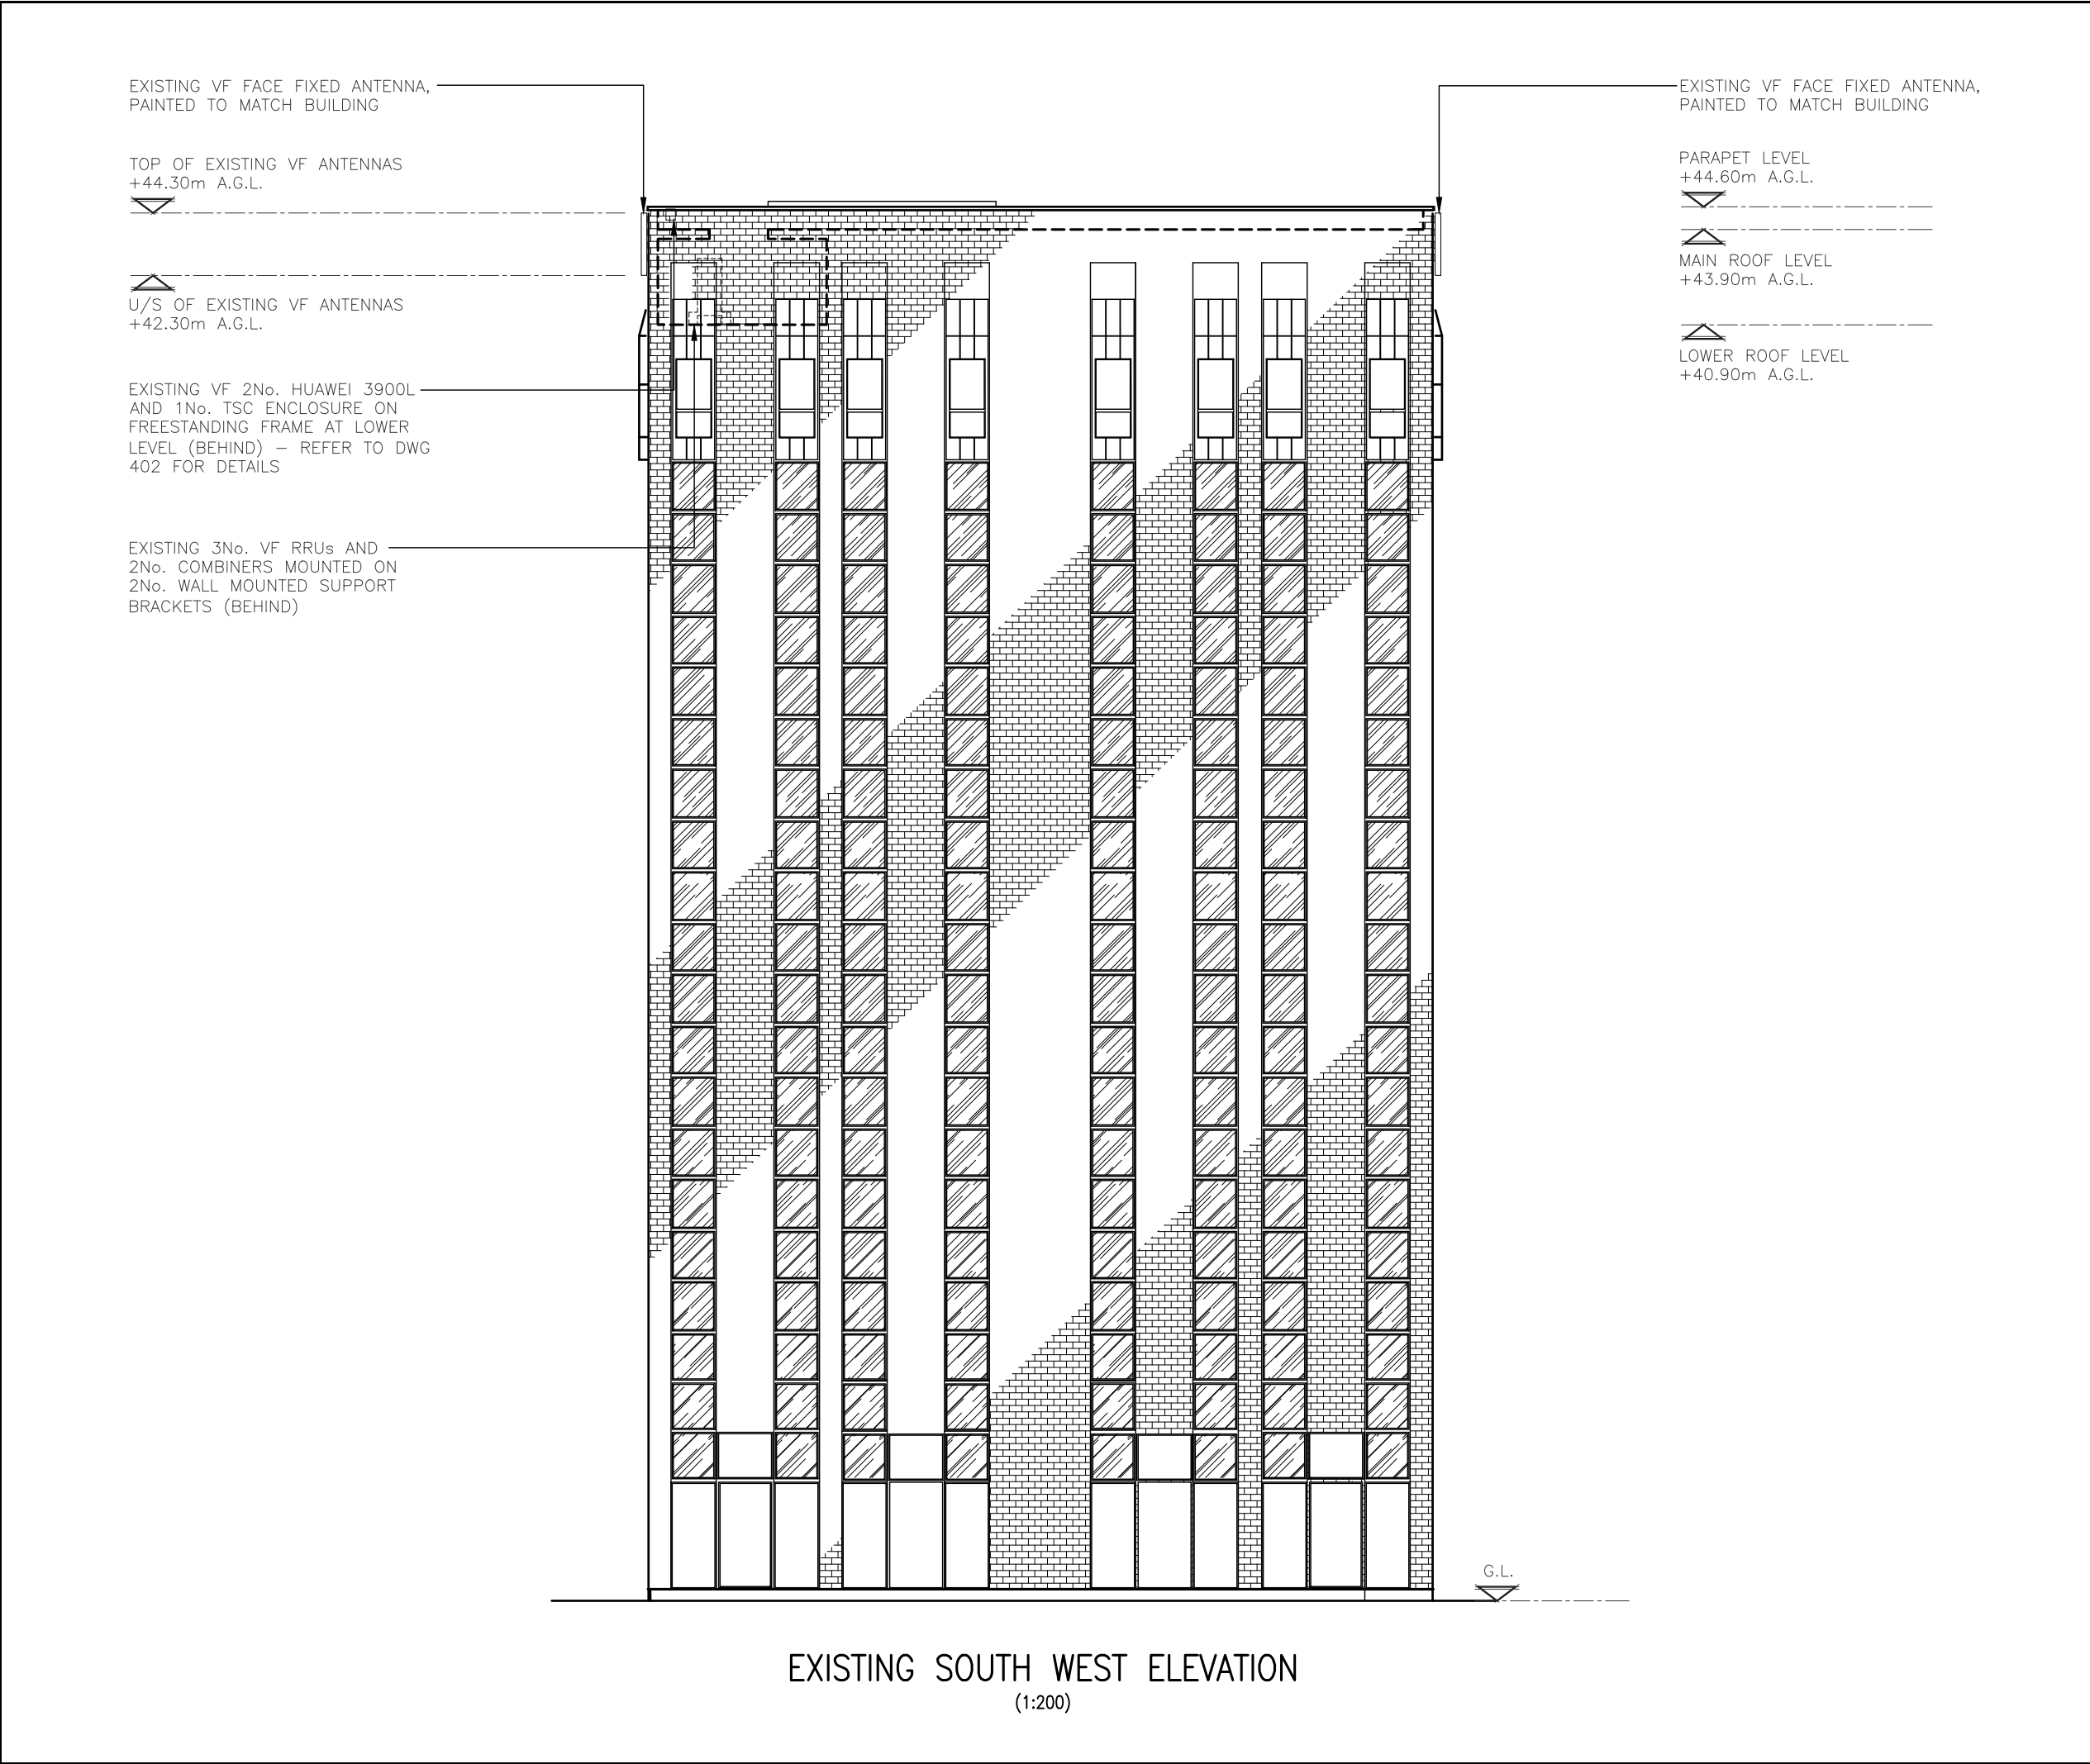

ALL DIMENSIONS ARE IN mm UNLESS NOTED OTHERWISE

N.G.R

E: 383637

N: 398148

NOTES:

A	Issued for Approval	CS	MC	05.08.21
REV	MODIFICATION	BY	CH	DATE

CLARKE
telecom

Unit E, Madison Place, Northampton Road,
Manchester, M40 5AG
Tel: 0161 785 4500
Fax: 0161 785 4501
Web: www.clarke-telecom.com


O₂

CORNERSTONE - BEACON 3

Cell Name			Opt.
CENTURION HOUSE			A
Cell ID No			
CORNERSTONE	TEF	VF	
129400_26 E307802	092661	79290	
Site Address / Contact Details			
DEANS_GATE MANCHESTER GREATER MANCHESTER M3 3WR			

Drawing Title:
EXISTING SW SITE ELEVATION

Purpose of issue:			Dwg Rev:
PLANNING			
Drawing Number:			A
306			
Surveyed By:		Original Sheet Size:	Pack Issue:
DW		A3	
Drawn:	Date:	Checked:	Date:
CS	05.08.21	MC	05.08.21
			B

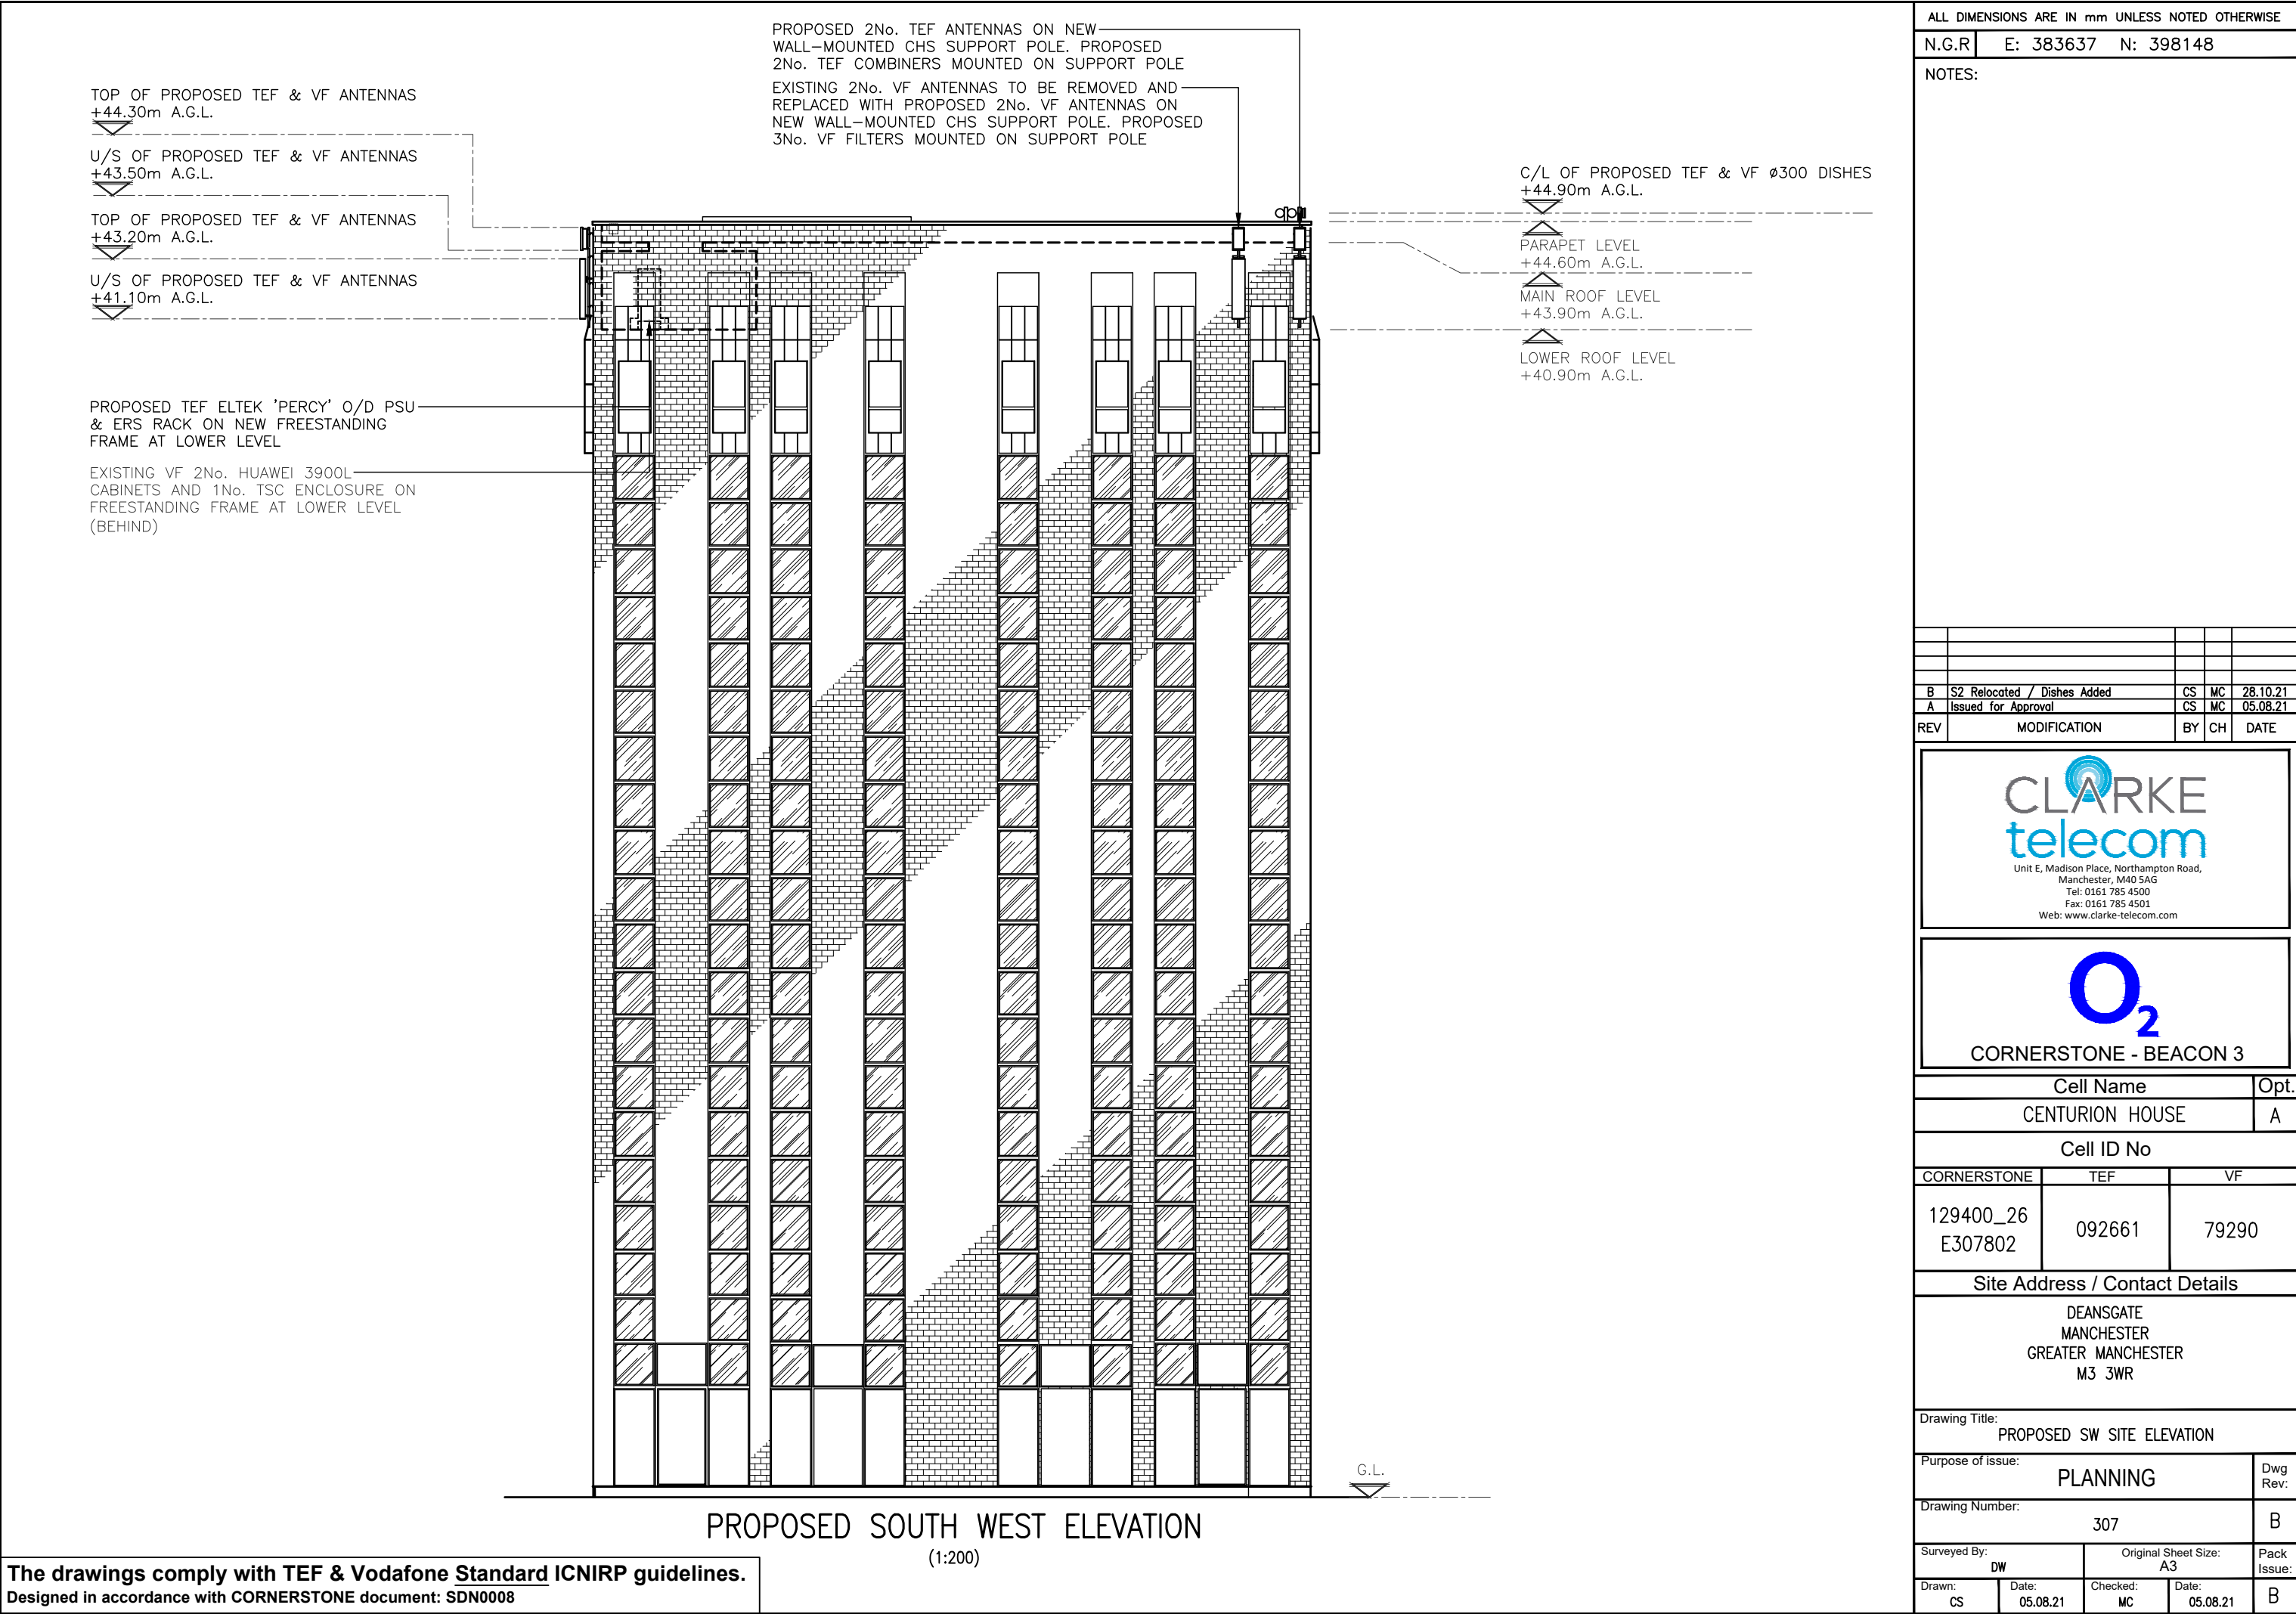

ALL DIMENSIONS ARE IN mm UNLESS NOTED OTHERWISE

N.G.R | E: 383637 N: 398148

NOTES:

B	S2 Relocated / Dishes Added	CS	MC	28.10.21
A	Issued for Approval	CS	MC	05.08.21
REV	MODIFICATION	BY	CH	DATE



Unit E, Madison Place, Northampton Road,
Manchester, M40 5AG
Tel: 0161 785 4500
Fax: 0161 785 4501
Web: www.clarke-telecom.com



CORNERSTONE - BEACON 3

Cell Name	Opt.
CENTURION HOUSE	A

Cell ID No		
CORNERSTONE	TEF	VF
129400_26 E307802	092661	79290

Site Address / Contact Details		
DEANS_GATE MANCHESTER GREATER MANCHESTER M3 3WR		

Drawing Title: PROPOSED SW SITE ELEVATION				
Purpose of Issue: PLANNING				Dwg Rev:
Drawing Number: 307				B
Surveyed By: DW		Original Sheet Size: A3		Pack Issue:
Drawn: CS	Date: 05.08.21	Checked: MC	Date: 05.08.21	B

The drawings comply with TEF & Vodafone Standard ICNIRP guidelines.
Designed in accordance with CORNERSTONE document: SDN0008