




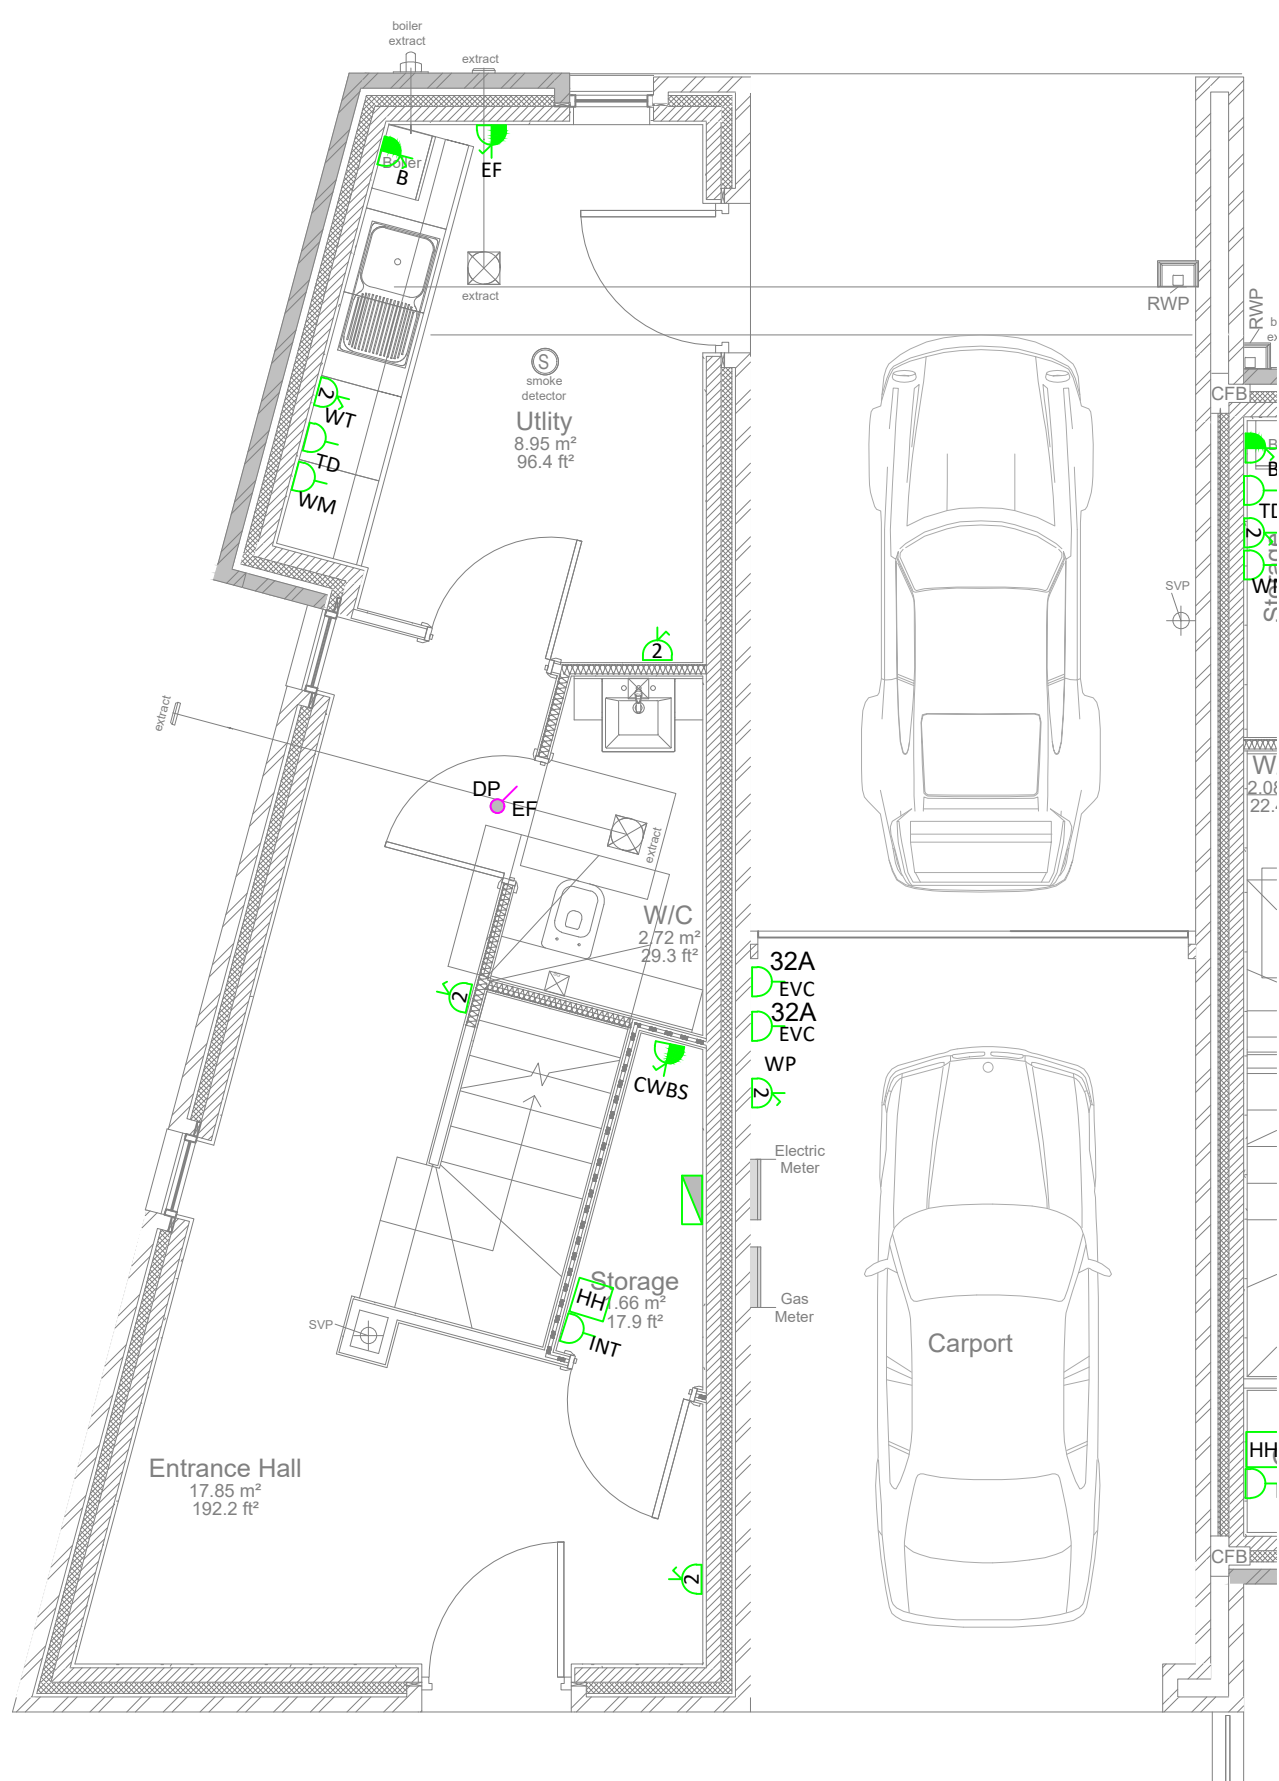

Proposed Second Floor Small Power Layout.
Scale 1:50

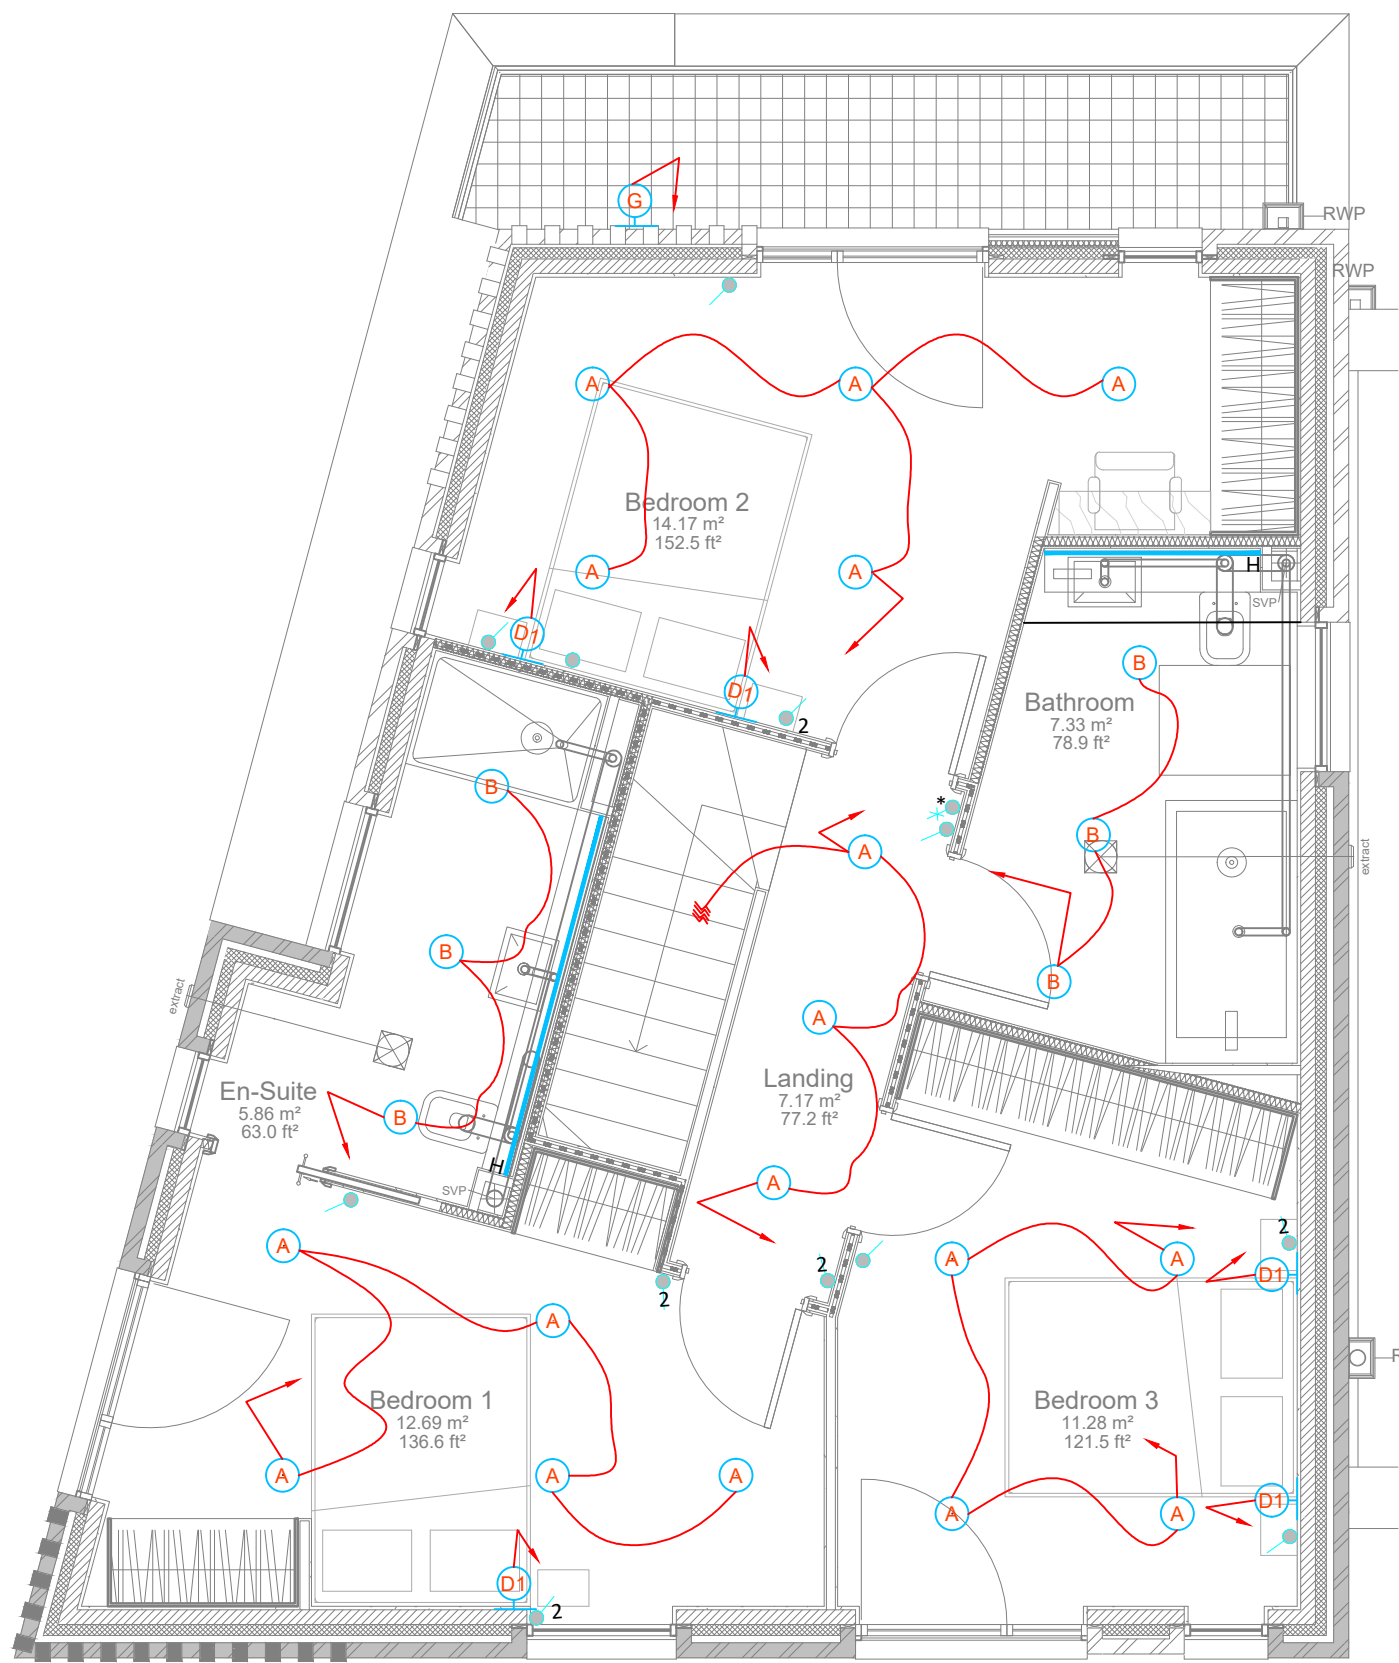

Proposed Second Floor Lighting Layout.
Scale 1:50

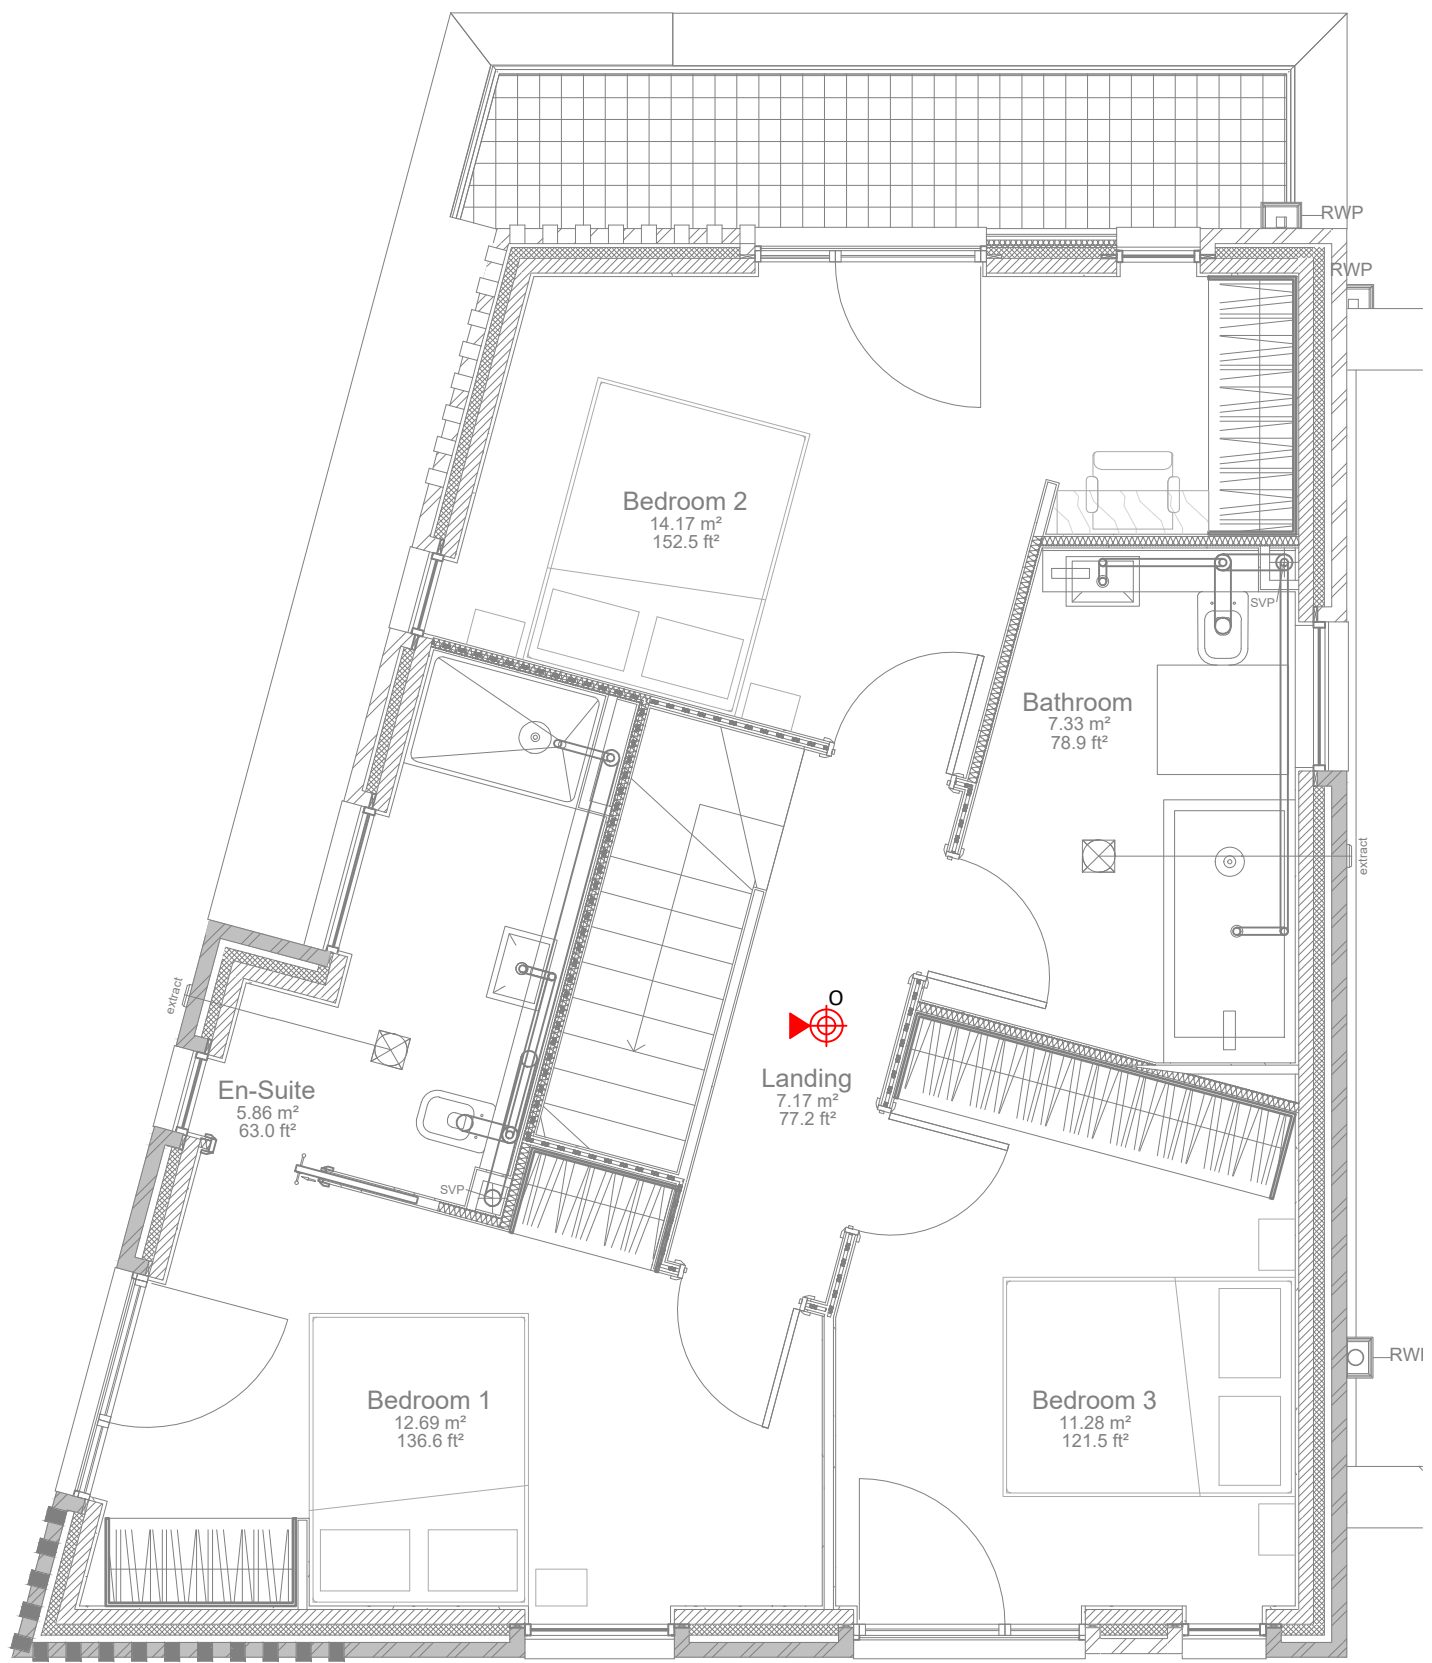

Proposed Second Floor Fire & Security Layout.
Scale 1:50

LEGEND - SMALL POWER AND DATA

- CONSUMER UNIT (Metal Clad / Dual RCD)
- TELEPHONE OUTLET
- DOUBLE SOCKET OUTLET
- USB TWIN SWITCHED SOCKET OUTLET c/w USB POWER OUTLETS
- SINGLE SOCKET OUTLET
- SINGLE SOCKET OUTLET (UN-SWITCHED)
- 13A SWITCHED FUSED CONNECTION UNIT
- FLEX OUTLET
- BT FIBRE HOME HUB
- SHAVESOCKET OUTLET-TO BE TAKEN FROM LIGHTING CIRCUIT
- UTILITY METER
- WIRED DOOR BELL
- DOUBLE POLE SWITCH SERVING WC EXTRACT FAN
- LL - LOW LEVEL
- WM - WASHING MACHINE
- TD - TUMBLE DRYER
- FF - FRIDGE/FREEZER
- E - EXTRACT HOOD
- O - OVEN
- H - HOB
- DW - DISHWASHER
- INT - INTRUDER PANEL
- HL - HIGH LEVEL
- TR - CTOWEL RAIL
- EVC - ELECTRIC VEHICLE CHARGING
- WP - WEATHERPROOF

LEGEND - LIGHTING

- 6W RECESSED LED DOWNLIGHT FIRE RATED
- 6W RECESSED IP65 RATED LED DOWNLIGHT FIRE RATED
- LED SURFACE MOUNTED UNDER UNIT LUMINAIRE
- LED WALL MOUNTED LUMINAIRE
- LED WALL MOUNTED LUMINAIRE
- LED PIR IP65 RATED WALL MOUNTED LUMINAIRE
- LED IP65 RATED WALL MOUNTED LUMINAIRE
- BATHROOM MIRROR LIGHT CW BUILT IN PIR
- LED IP65 RATED LINEAR LUMINAIRE
- LIGHTING CONTROL SWITCH - 'N' DENOTES NUMBER OF GANGS - 'X' DENOTES NUMBER OF WAYS - 'I' DENOTES INTERMEDIATE
- MOTION SENSOR

LEGEND - FIRE ALARM

- GRADE D LD1 OPTICAL SMOKE ALARM WITH SOUNDER
- GRADE D LD1 HEAT DETECTOR WITH SOUNDER
- INTRUDER ALARM PIR
- INTRUDER ALARM DOOR CONTACT
- INTRUDER ALARM SHOCK SENSOR
- INTRUDER ALARM KEYPAD
- INTRUDER ALARM BELL BOX

NOTES

- THIS LAYOUT SHALL BE READ IN CONJUNCTION WITH ALL OTHER LAYOUTS, MECHANICAL, ELECTRICAL, ARCHITECTURAL & STRUCTURAL.
- THIS LAYOUT SHALL BE READ IN CONJUNCTION WITH THE ELECTRICAL SPECIFICATION.
- THIS LAYOUT SHOWS AN INTENT/PROPOSAL; THE CONTRACTS OBLIGATION AND DESIGN RESPONSIBILITY ARE DEFINED IN THE SPECIFICATION.
- ALL OPENING WINDOWS TO BE PROVIDED WITH INTRUDER ALARM SHOCK SENSORS AND CONTACTS.
- ALL DOORS TO BE PROVIDED WITH INTRUDER ALARM SHOCK SENSORS AND CONTACTS.
- ALL NON-OPENING WINDOWS TO BE PROVIDED WITH SHOCK SENSORS.
- EXTRACT FANS IN EN-SUITES TO BE SWITCHED INDIVIDUALLY. EXTRACT FAN IN DOWNSTAIRS WC TO BE SWITCHED WITH LIGHTING

dbd Ltd.

13 Walshaw Road
Bury,
Lancashire,
BL9 5 1LP
Tel:- 0161 7648400
Fax:- 0161 7648402
Email: consult@dbdsolutions.co.uk
Web: www.dbdsolutions.co.uk



ISSUE
PRELIMINARY

P2	13-01-21	RENAMED TO TYPE B	CJJ
P1	01-12-20	PRELIMINARY ISSUE	CJJ
rev	date	amendment	by

CLIENT
KAMANI PROJECTS LTD


PROJECT
88 SCHOOL LANE, DIDSBUY, MANCHESTER
TYPE B
PROPOSED RESIDENTIAL DEVELOPMENT

TITLE
ELECTRICAL SERVICES LAYOUT
SECOND FLOOR

SCALE: 1:50 @ A1 DRAWN: CJJ

DATE: NOV 2020 CHECKED: D.B

DRAWING No: 9695-E01 Sht 2 of 2 REV P2

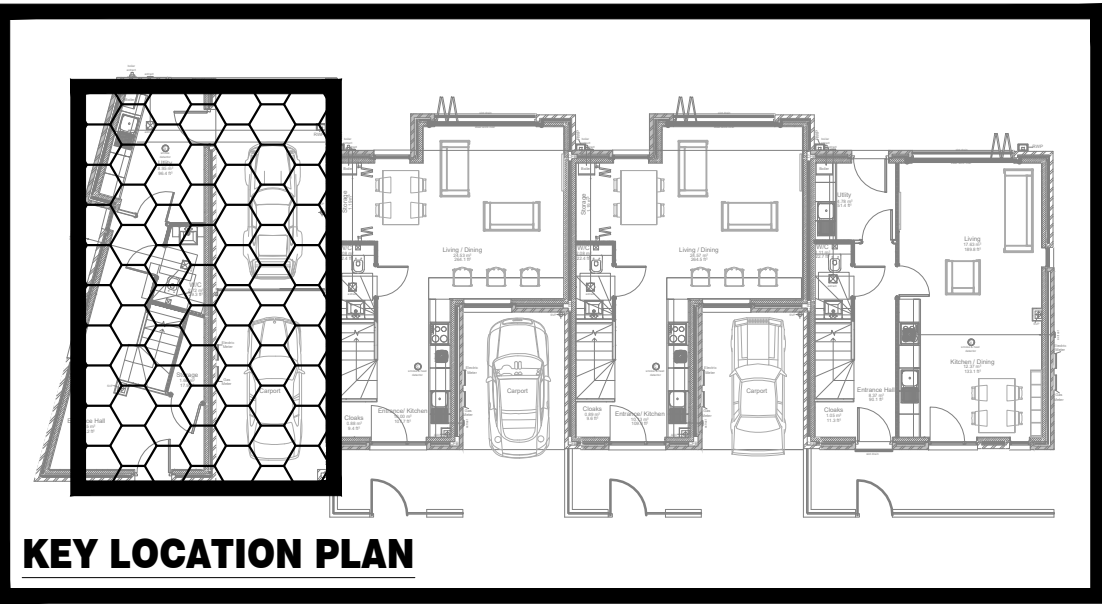

KEY LOCATION PLAN