


Last saved by: OWNER(2020-12-21) Last Plotted: 2021-01-04  
Filename: C:\USERS\OWNER\HURSTWOOD\FILESTORE - BOLTON PROJECTS\PROJECTS\C3435 - GRANADA STUDIOS OFFICES\02 MECHANICAL\04 DRAWINGS\02-GROUND FLOOR - VENT.DWG

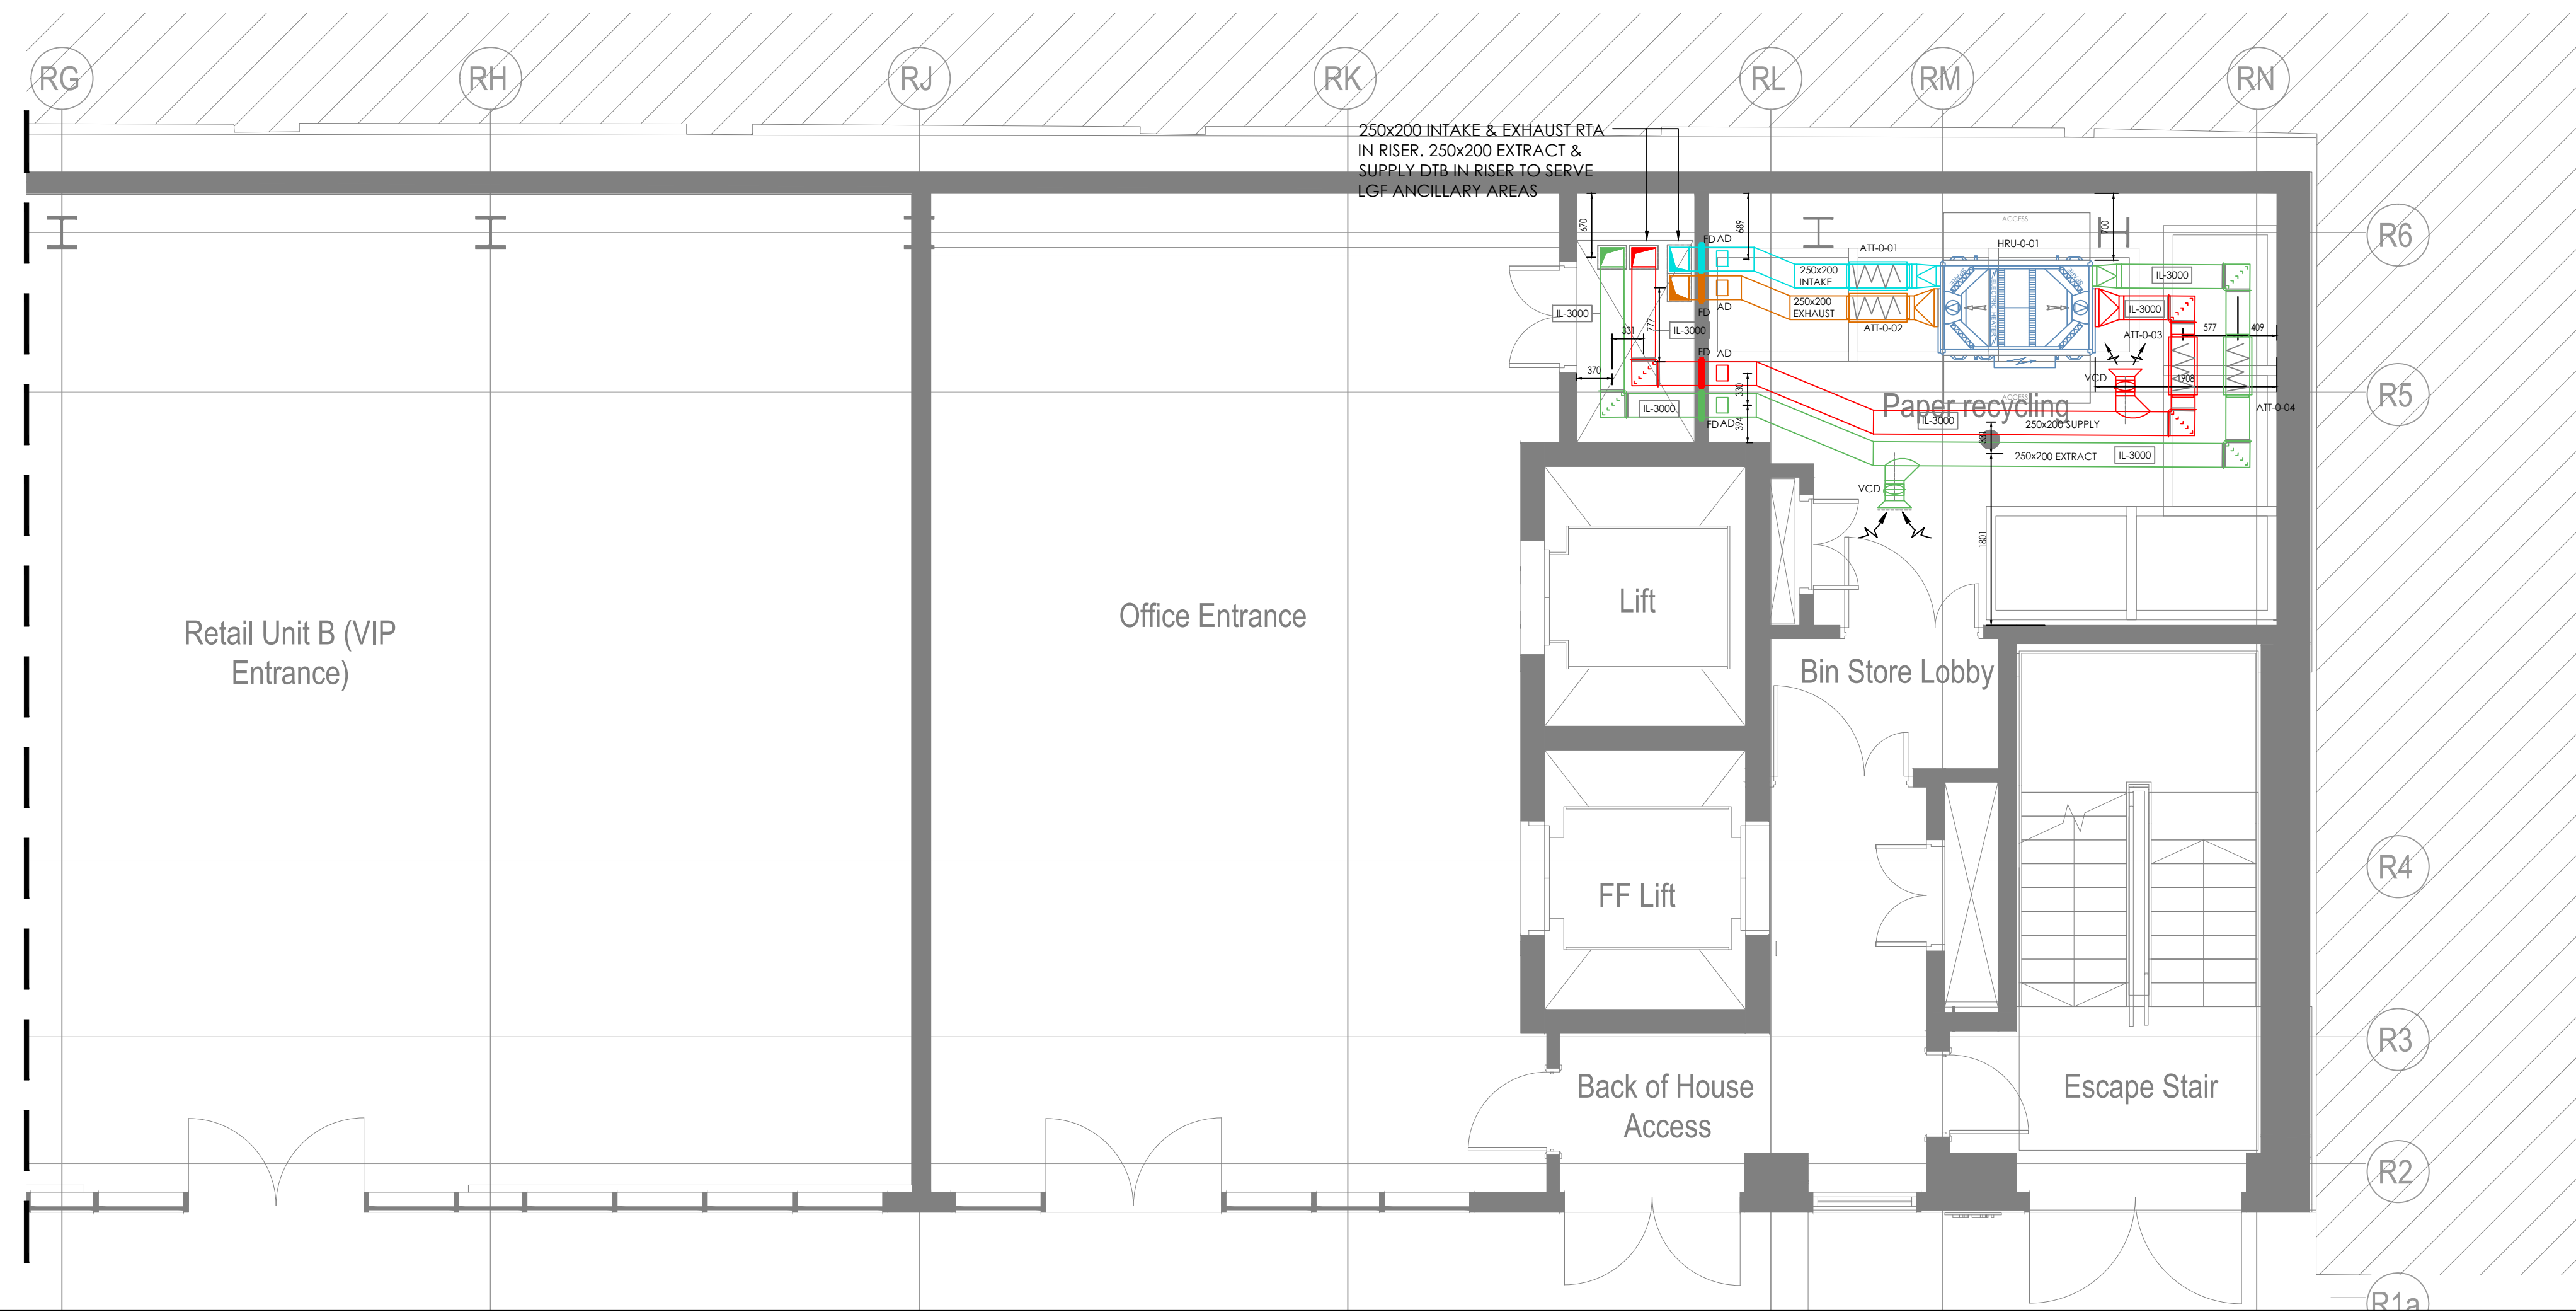



© This drawing is copyright protected, and remains the property of hurstwood environmental consulting. it must not be reproduced, used, disclosed or transmitted to third parties in any form without prior written permission.

### VENTILATION NOTES

1. ALL GENERAL SUPPLY AND EXTRACT DUCTWORK SHALL BE MANUFACTURED AND INSTALLED IN ACCORDANCE WITH THE HVCA SPECIFICATION DW144 LOW PRESSURE CLASS A
2. ALL EXTERNAL SUPPLY AND RETURN AIR DUCTWORK SHALL BE INSULATED, FINISHED ALUMINIUM CLAD AND IDENTIFIED
3. ALL INVERT LEVELS TAKEN TO CENTERLINE OF SERVICES

| REV | CHK | DATE     | Description                                   |
|-----|-----|----------|-----------------------------------------------|
| C2  | PC  | 21.12.20 | CONSTRUCTION ISSUE                            |
| C1  | PC  | 04.10.20 | CONSTRUCTION ISSUE                            |
| P2  | PC  | 03.08.20 | STAGE 4 - PRELIMINARY - COMMENTS INCORPORATED |
| P1  | PC  | 12.04.20 | STAGE 4 - PRELIMINARY ISSUE                   |

Architectural X-Ref Drawings:  
FF&E X-Ref Drawings:

Drawing Status: **CONSTRUCTION**

Design & Construction By: **Bowmer & Kirkland** MEP Contractor: **VAUGHAN**

 **hurstwood environmental**  
Consulting Engineers  
www.hurstwood-eng.co.uk

**Bolton Office**

Altra  
Spa Road  
Bolton  
BL1 4AG  
T: 01204 770 041  
E: bolton@hurstwood-eng.co.uk

**Liverpool Office**

23 Goodlass Road  
Speke  
Liverpool  
L24 9HJ  
T: 0151 728 3360  
E: liverpool@hurstwood-eng.co.uk

**London Office**

344 Gray's Inn Road  
Bloomsbury  
London  
WC1X 8BP  
T: 0203 755 3711  
E: london@hurstwood-eng.co.uk

|                                                |                  |               |           |
|------------------------------------------------|------------------|---------------|-----------|
| Drawn: R Jordan                                | Chkd: P Chambers | App: M Jordan | <b>A1</b> |
| Date: APR 2020                                 | Scale: 1:50      |               |           |
| Client: BOWMER AND KIRKLAND                    |                  |               |           |
| Project: OLD GRANADA STUDIOS - ZONE 6          |                  |               |           |
| Drawing Title: VENTILATION LAYOUT GROUND FLOOR |                  |               |           |
| Project No: 63050-VAU-Z6-GF-DR-N-5701          |                  |               | Rev: C2   |