




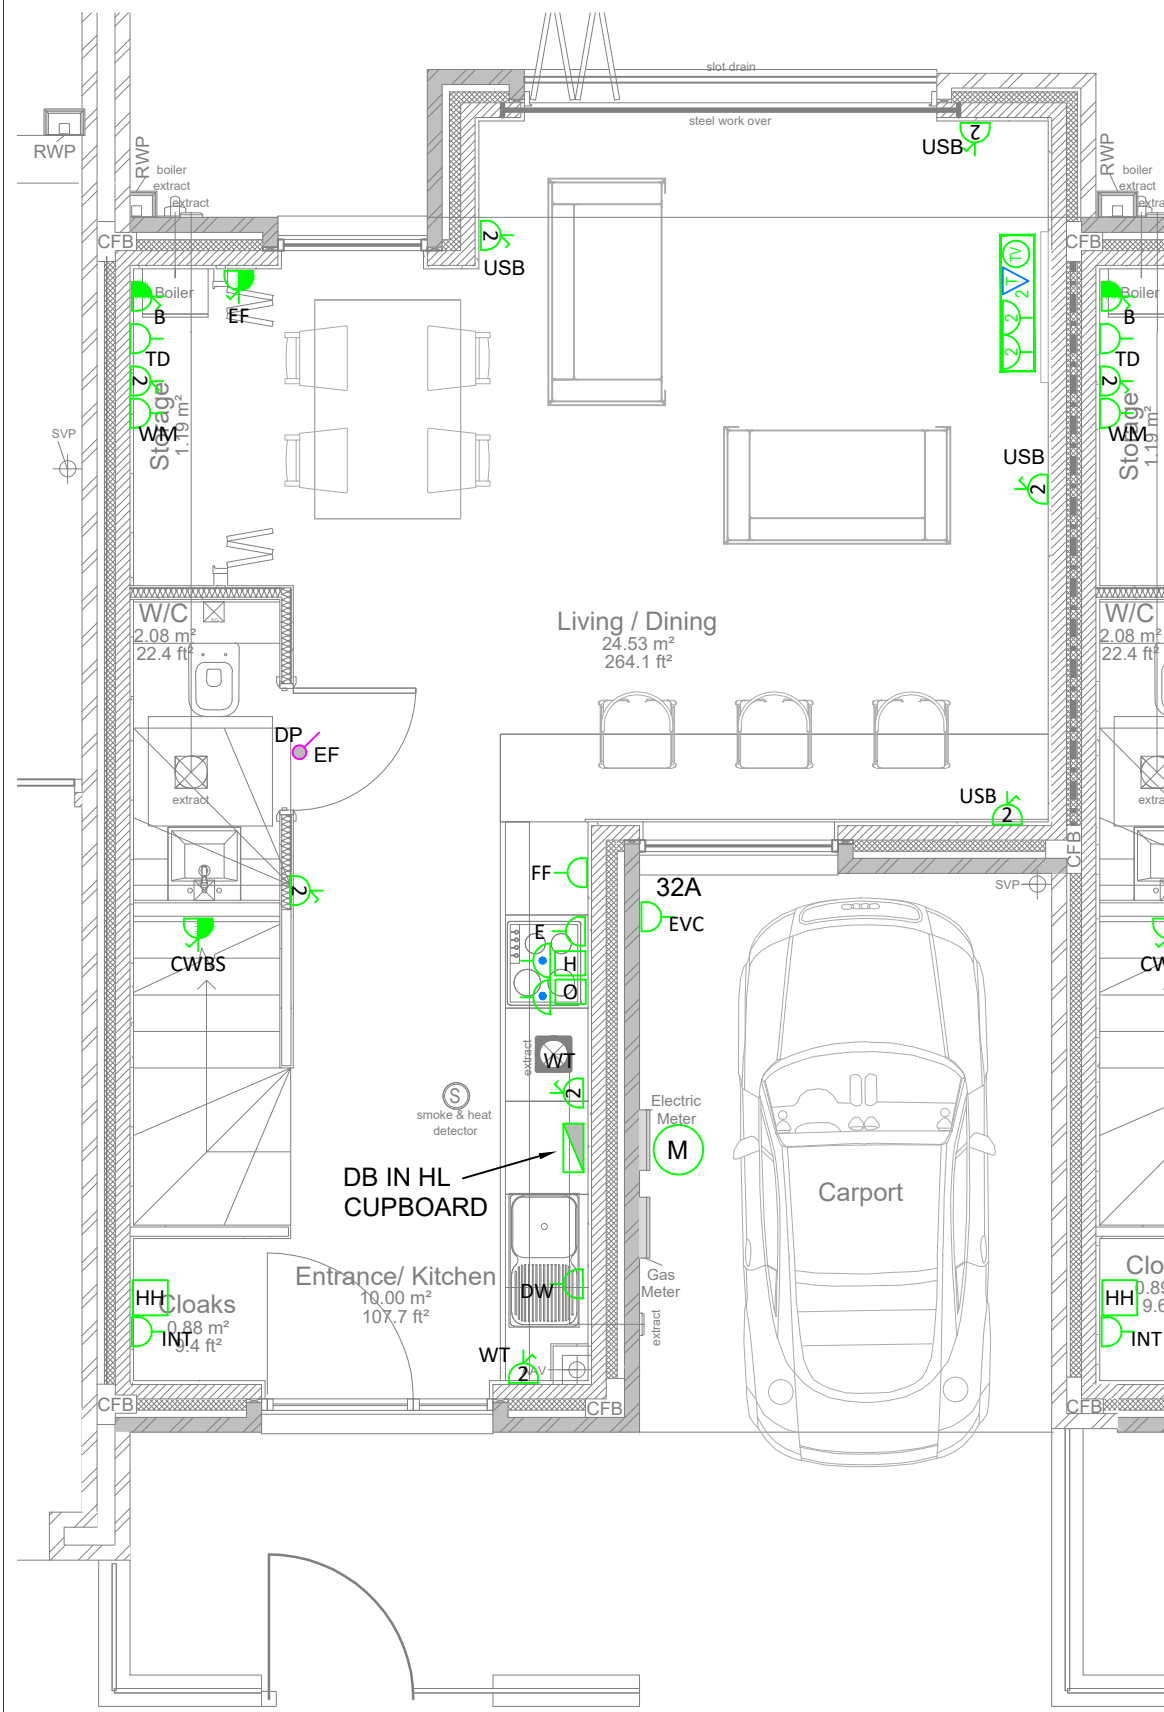


Proposed Ground Floor Small Power Layout.
Scale 1:50

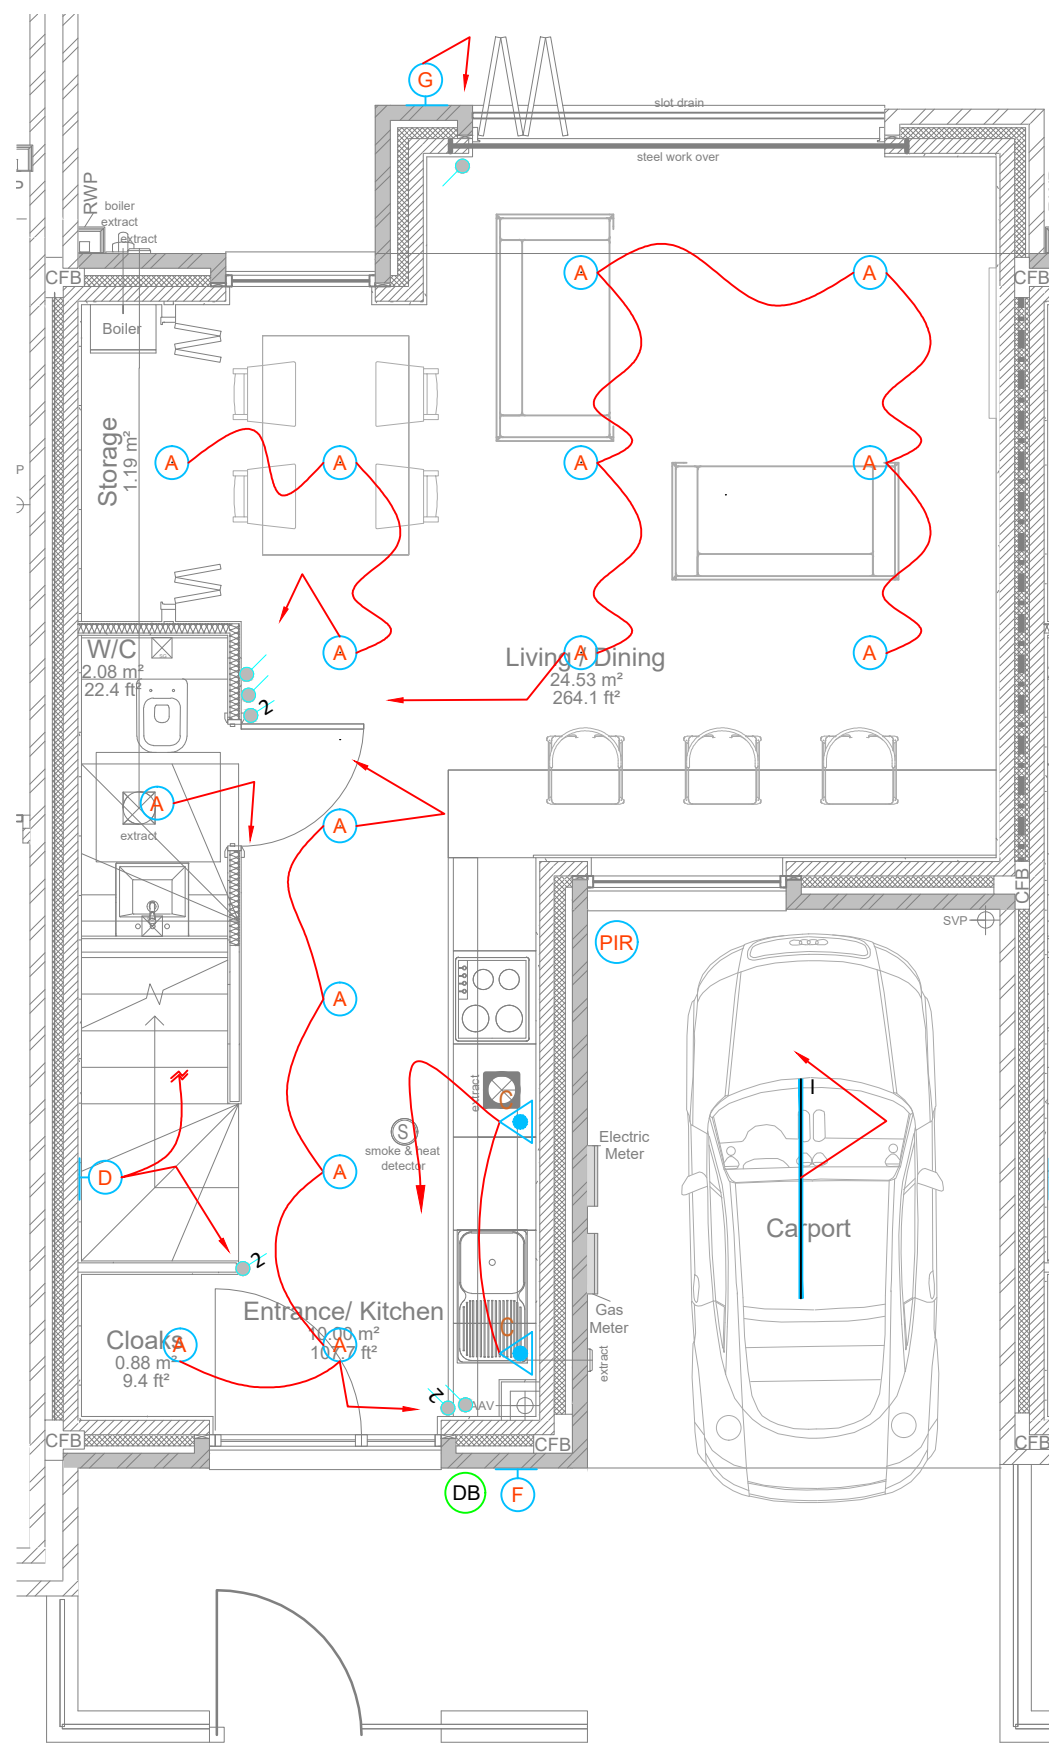


Proposed Ground Floor Lighting Layout.
Scale 1:50

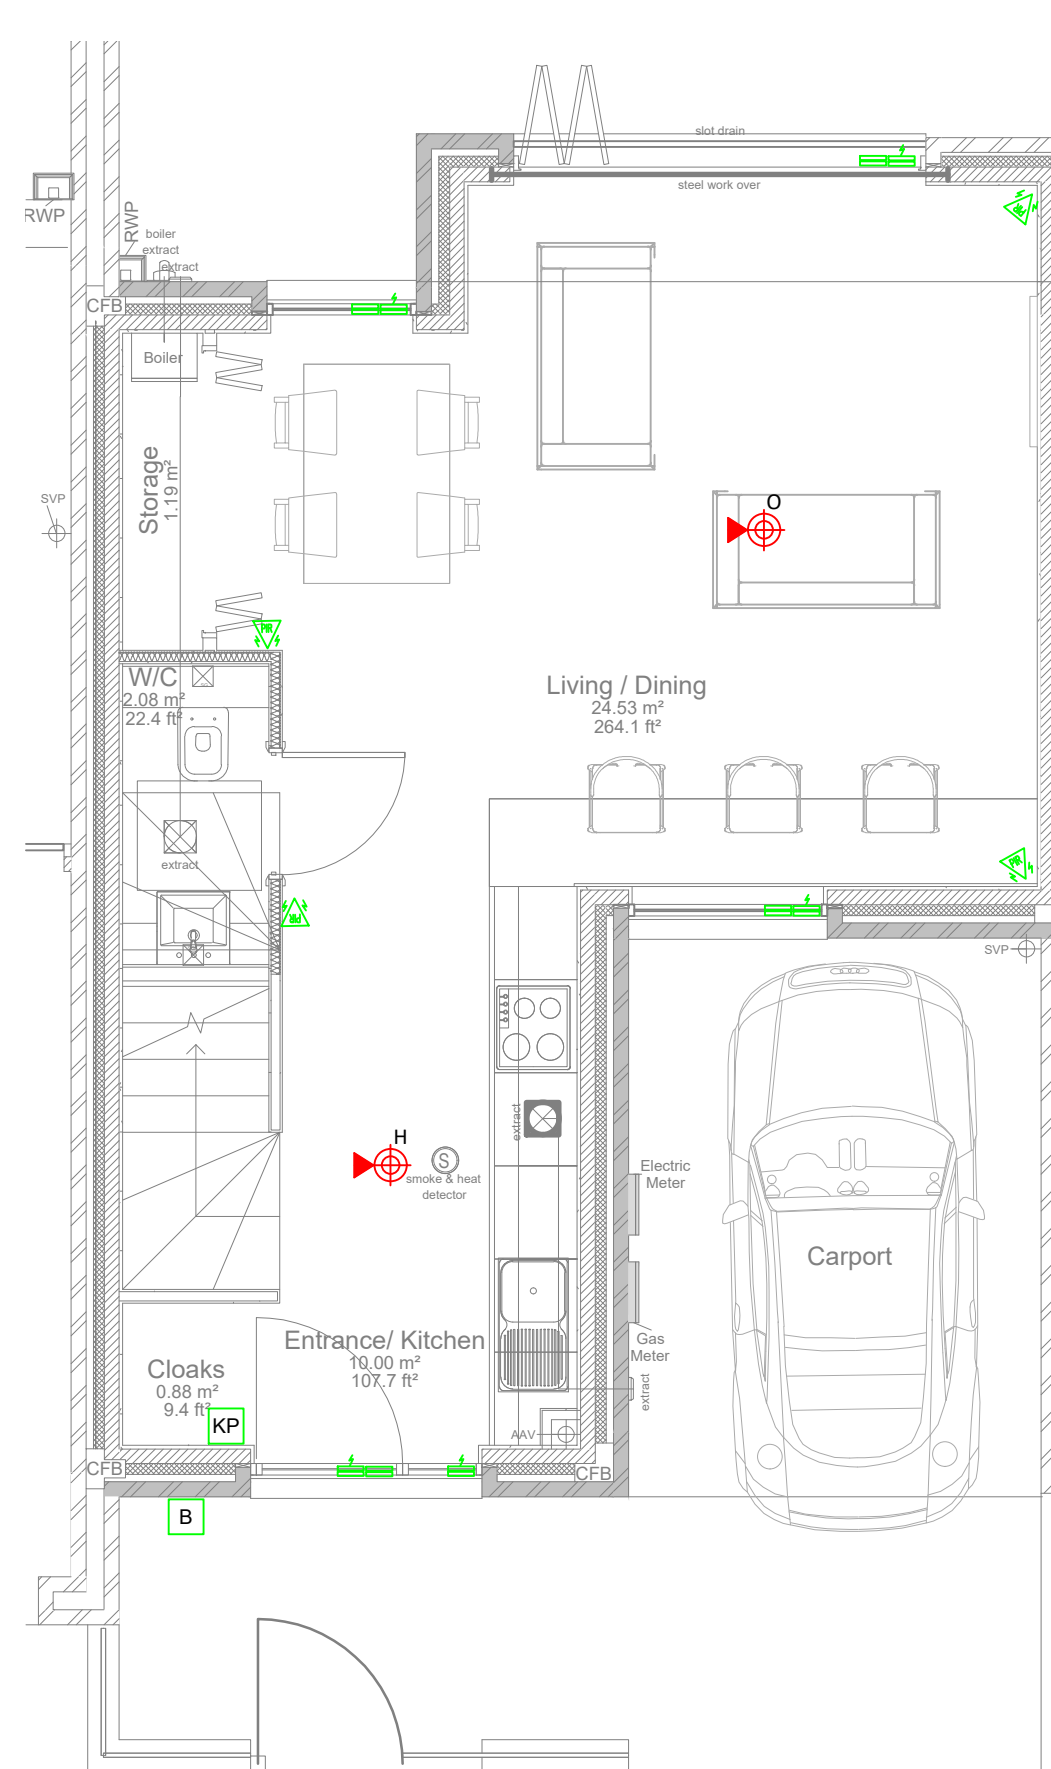


Proposed Ground Floor Fire & Security Layout.
Scale 1:50

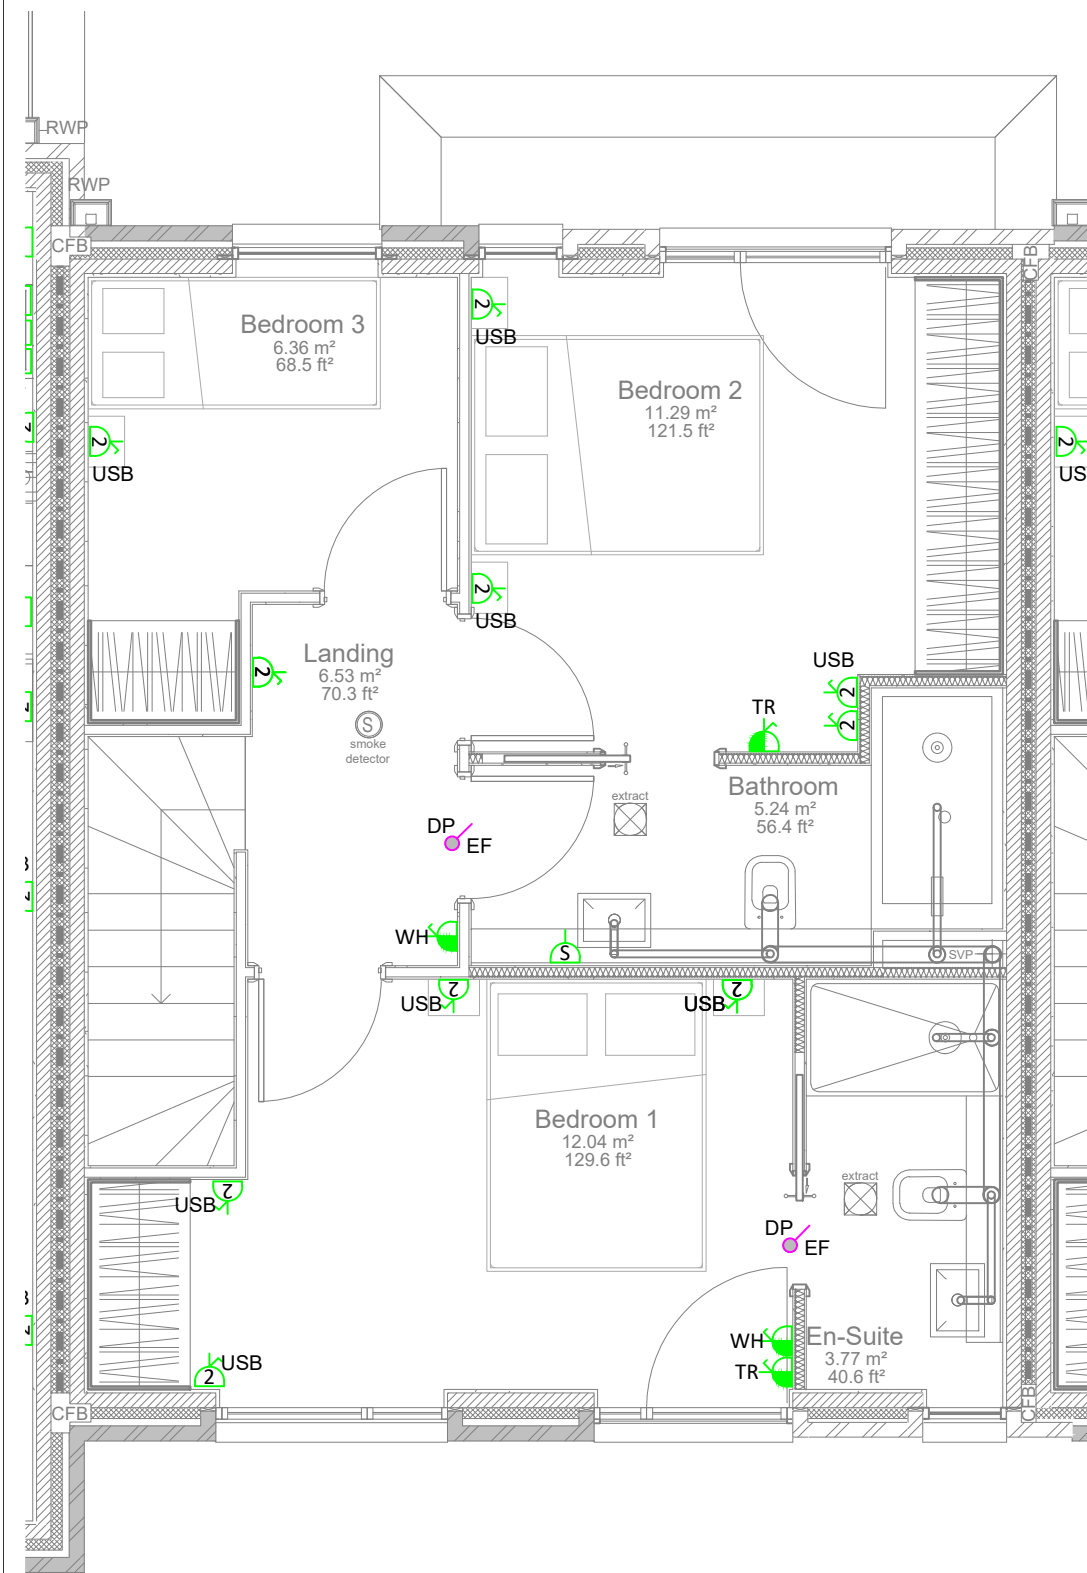

Proposed First Floor Small Power Layout.
Scale 1:50

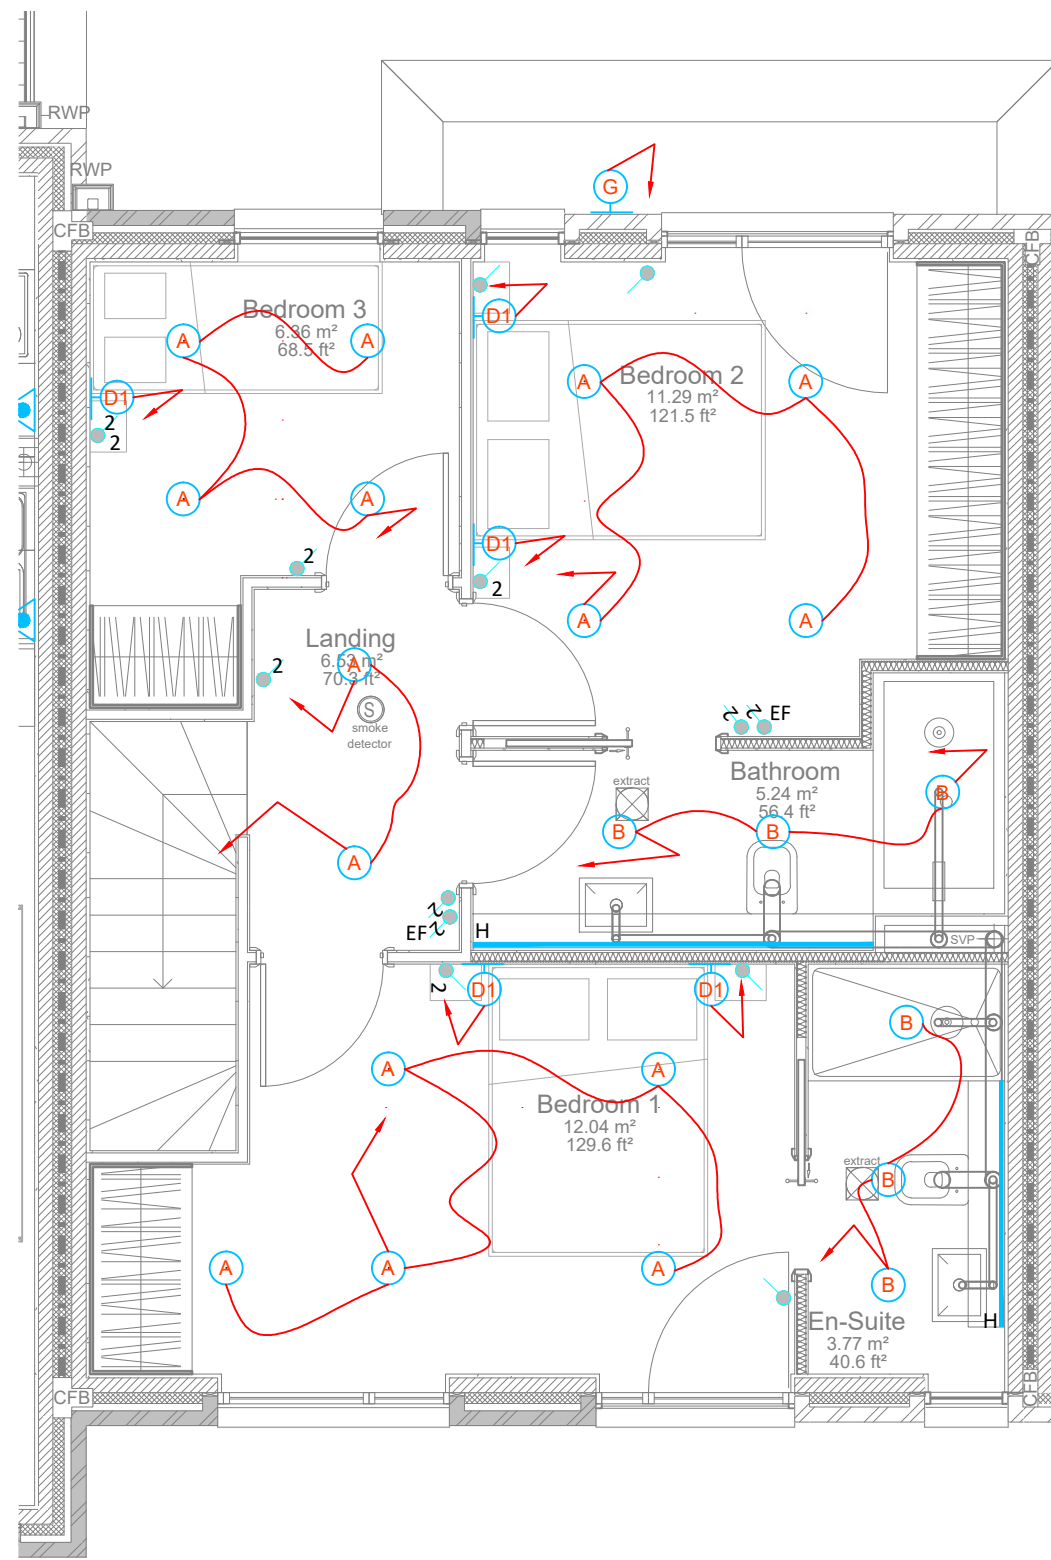

Proposed First Floor Lighting Layout.
Scale 1:50

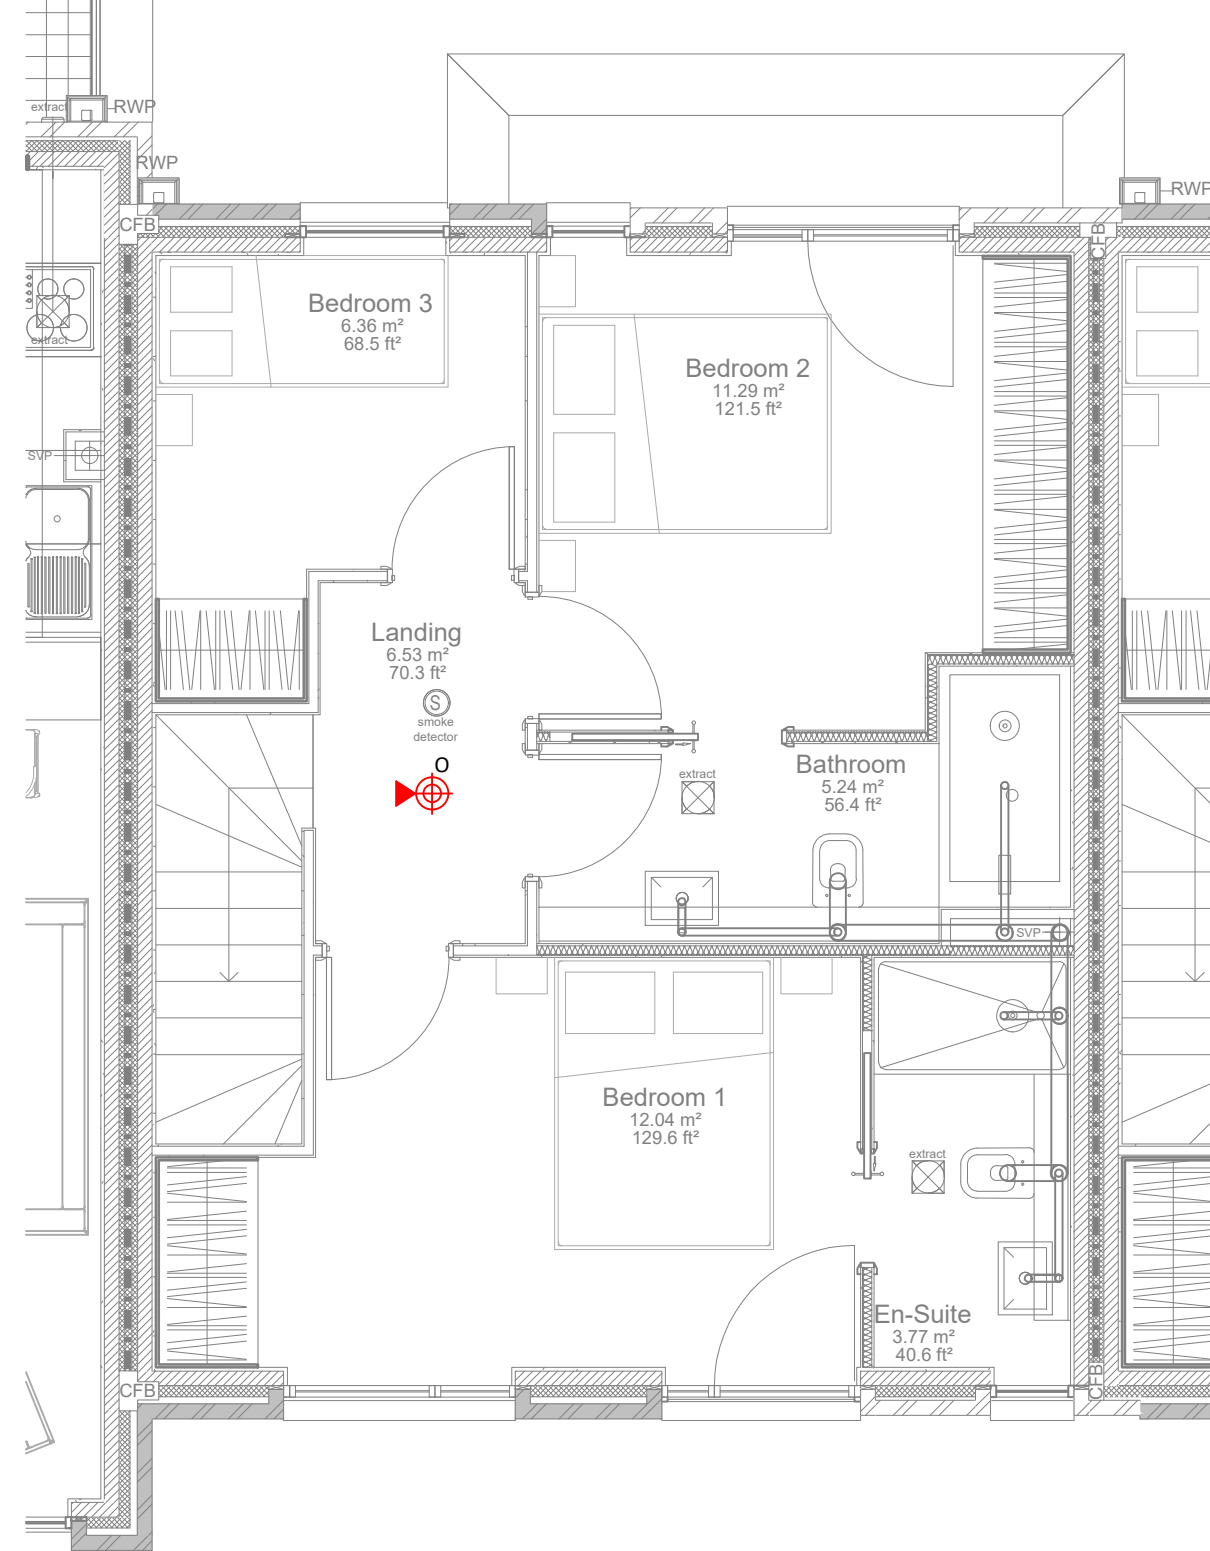

Proposed First Floor Fire & Security Layout.
Scale 1:50

LEGEND - SMALL POWER AND DATA

- CONSUMER UNIT (Metal Clad / Dual RCD)
- TELEPHONE OUTLET
- DOUBLE SOCKET OUTLET
- TWIN SWITCHED SOCKET OUTLET c/w USB POWER OUTLETS
- SINGLE SOCKET OUTLET
- SINGLE SOCKET OUTLET (UN-SWITCHED)
- 13A SWITCHED FUSED CONNECTION UNIT
- FLEX OUTLET
- BT FIBRE HOME HUB
- SHAVESOCKET OUTLET-TO BE TAKEN FROM LIGHTING CIRCUIT
- UTILITY METER
- WIRED DOOR BELL
- DOUBLE POLE SWITCH SERVING WC EXTRACT FAN

- LL - LOW LEVEL
- WM - WASHING MACHINE
- TD - TUMBLE DRYER
- FF - FRIDGE/FREEZER
- E - EXTRACT HOOD
- O - OVEN
- HOB - HOB
- DW - DISHWASHER
- INT - INTRUDER PANEL
- HL - HIGH LEVEL
- TR - CTOWEL RAIL
- EVC - ELECTRIC VEHICLE CHARGING
- WP - WEATHERPROOF

LEGEND - LIGHTING

- 6W RECESSED LED DOWNLIGHT FIRE RATED
- 6W RECESSED IP65 RATED LED DOWNLIGHT FIRE RATED
- LED SURFACE MOUNTED UNDER UNIT LUMINAIRE
- LED WALL MOUNTED LUMINAIRE
- LED WALL MOUNTED LUMINAIRE
- LED PIR IP65 RATED WALL MOUNTED LUMINAIRE
- LED IP65 RATED WALL MOUNTED LUMINAIRE
- BATHROOM MIRROR LIGHT CW BUILT IN PIR
- LED IP65 RATED LINEAR LUMINAIRE
- LIGHTING CONTROL SWITCH
- 'H' DENOTES NUMBER OF GANGS
- 'X' DENOTES NUMBER OF WAYS
- 'I' DENOTES INTERMEDIATE
- MOTION SENSOR

LEGEND - FIRE ALARM

- GRADE D LD1 OPTICAL SMOKE ALARM WITH SOUNDER
- GRADE D LD1 HEAT DETECTOR WITH SOUNDER
- INTRUDER ALARM PIR
- INTRUDER ALARM DOOR CONTACT
- INTRUDER ALARM DOOR CONTACT
- INTRUDER ALARM KEYPAD
- INTRUDER ALARM BELL BOX

NOTES

- THIS LAYOUT SHALL BE READ IN CONJUNCTION WITH ALL OTHER LAYOUTS, MECHANICAL, ELECTRICAL, ARCHITECTURAL & STRUCTURAL.
- THIS LAYOUT SHALL BE READ IN CONJUNCTION WITH THE ELECTRICAL SPECIFICATION.
- THIS LAYOUT SHOWS AN INTENT/PROPOSAL; THE CONTRACTS OBLIGATION AND DESIGN RESPONSIBILITY ARE DEFINED IN THE SPECIFICATION.
- ALL OPENING WINDOWS TO BE PROVIDED WITH INTRUDER ALARM SHOCK SENSORS AND CONTACTS.
- ALL DOORS TO BE PROVIDED WITH INTRUDER ALARM SHOCK SENSORS AND CONTACTS.
- ALL NON-OPENING WINDOWS TO BE PROVIDED WITH SHOCK SENSORS.
- EXTRACT FANS IN EN-SUITES TO BE SWITCHED INDIVIDUALLY. EXTRACT FAN IN DOWNSTAIRS WC TO BE SWITCHED WITH LIGHTING

dbd Ltd.

13 Walshaw Road
Bury,
Lancashire.
BL9 1LP
Tel:- 0161 7648400
Fax:- 0161 7648402
Email: consult@dbdsolutions.co.uk
Web: www.dbdsolutions.co.uk



ISSUE

PRELIMINARY

P2	13-01-21	RENAMED TO TYPE B	CJJ
P1	03-12-20	PRELIMINARY ISSUE	CJJ
rev	date	amendment	by

CLIENT

KAMANI PROJECTS LTD

PROJECT

88 SCHOOL LANE, DIDSURY, MANCHESTER
TYPE C
PROPOSED RESIDENTIAL DEVELOPMENT

TITLE

ELECTRICAL SERVICES LAYOUT
GROUND FLOOR & FIRST FLOOR

SCALE:

1:50 @ A1

DRAWN:

CJJ

DATE:

NOV 2020

CHECKED:


D.B

DRAWING No:

9695-E02

REV

P2

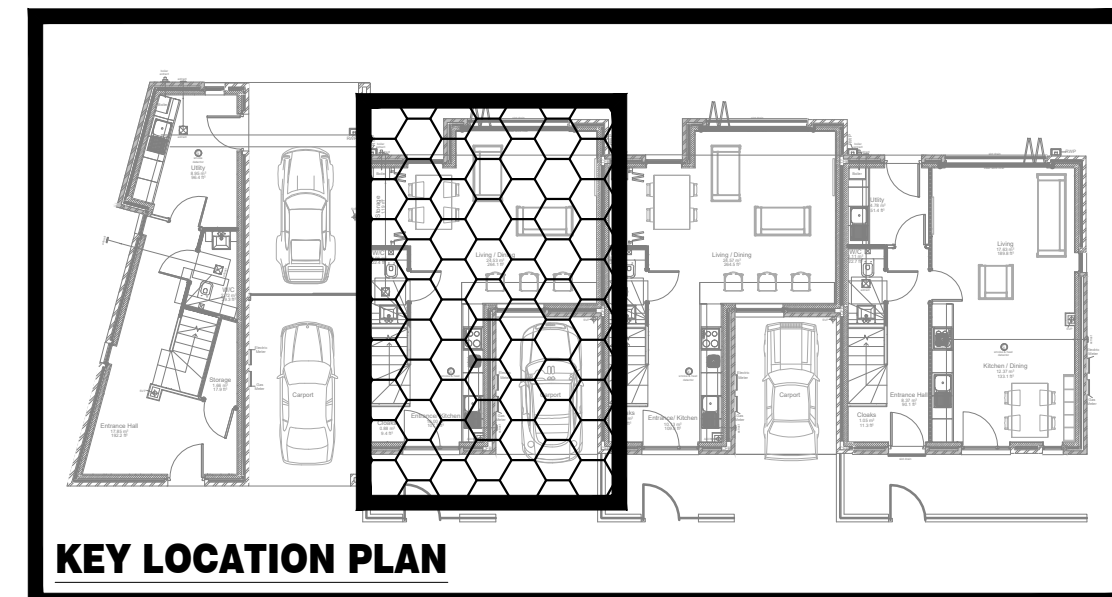

KEY LOCATION PLAN