



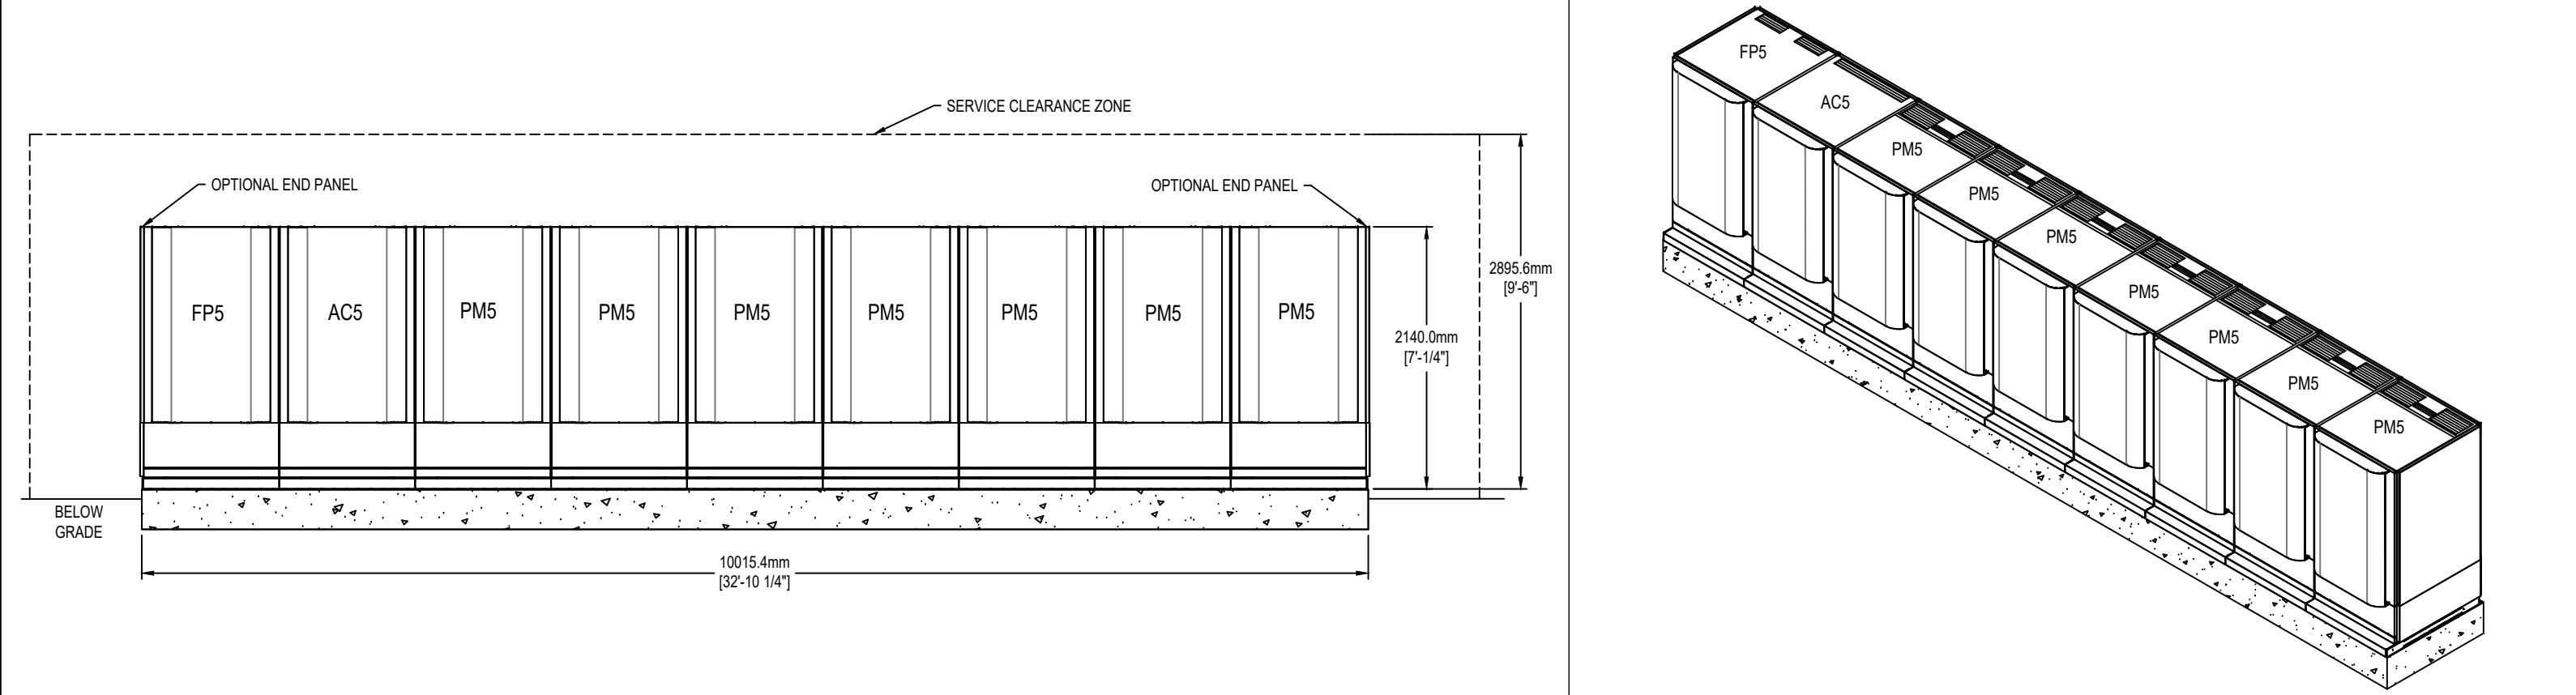

|   |                 |              |   |                |              |
|---|-----------------|--------------|---|----------------|--------------|
| 3 | FRONT ELEVATION | SCALE<br>NTS | 1 | ISOMETRIC VIEW | SCALE<br>NTS |
|---|-----------------|--------------|---|----------------|--------------|

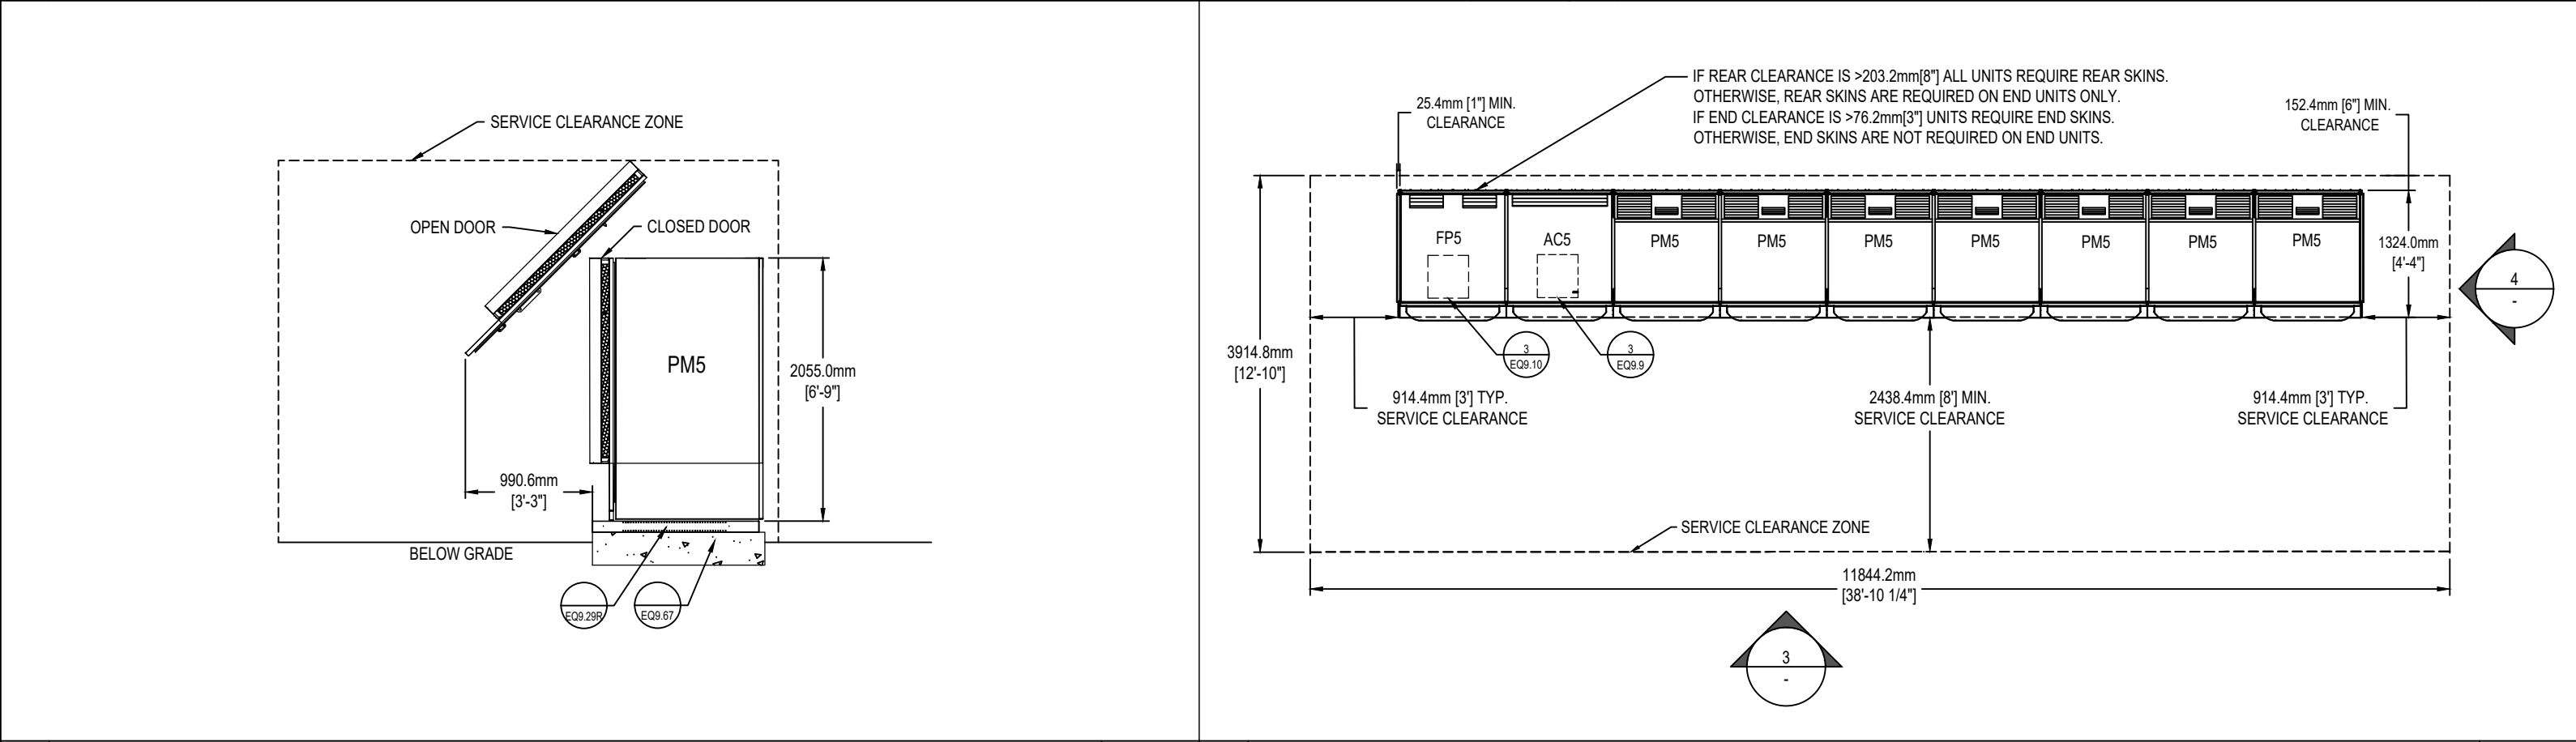

|   |                |              |   |           |              |
|---|----------------|--------------|---|-----------|--------------|
| 4 | SIDE ELEVATION | SCALE<br>NTS | 2 | PLAN VIEW | SCALE<br>NTS |
|---|----------------|--------------|---|-----------|--------------|

| REV | DATE     | BY | NOTES                     | REV | DATE | BY | NOTES |
|-----|----------|----|---------------------------|-----|------|----|-------|
| 1   | 9/30/13  | TM | UPDATES FOR NEW PRODUCTS. |     |      |    |       |
| 2   | 8/15/15  | CL | MINOR UPDATES.            |     |      |    |       |
| 3   | 05/30/19 | MK | DETAILS REFINED.          |     |      |    |       |
| 4   | 5/5/2020 | YB | METRIC UNITS ADDED.       |     |      |    |       |

**Bloomenergy™**  
4353 N 1st Street, San Jose, CA 95134  
Tel: 408.543.1500 Fax: 408.543.1501  
[www.bloomenergy.com](http://www.bloomenergy.com)

Bloom Energy Corporation all rights reserved. This document is for reference only and may not be used without the written permission of Bloom Energy. Any reproduction in part or as a whole without written permission of Bloom Energy is prohibited. Bloom Energy reserves the right change or modify without notice, the design, the product specifications, and/or the contents of this document without incurring any obligations either with respect to equipment previously sold or in the process of construction. It remains the contractors responsibility to ensure the version issued, supplemental to the IFC construction drawing set, are the relevant drawings for the project.

**ENERGY SERVER PRODUCT  
INSTALLATION DRAWINGS**  
  
PROPRIETARY - SUBJECT TO NDA

DRAWING TITLE:  
**ES5 LINEAR-E 7X PM5 ENERGY  
SERVER CONFIGURATION-RIGHT**  
  
SITE ID: -    SET REV:D    DOC-1006809

DATE:  
07/08/2021  
  
SCALE:  
NTS  
  
DRAWING NUMBER:  
EQ9.32R