




SITE LOCATION

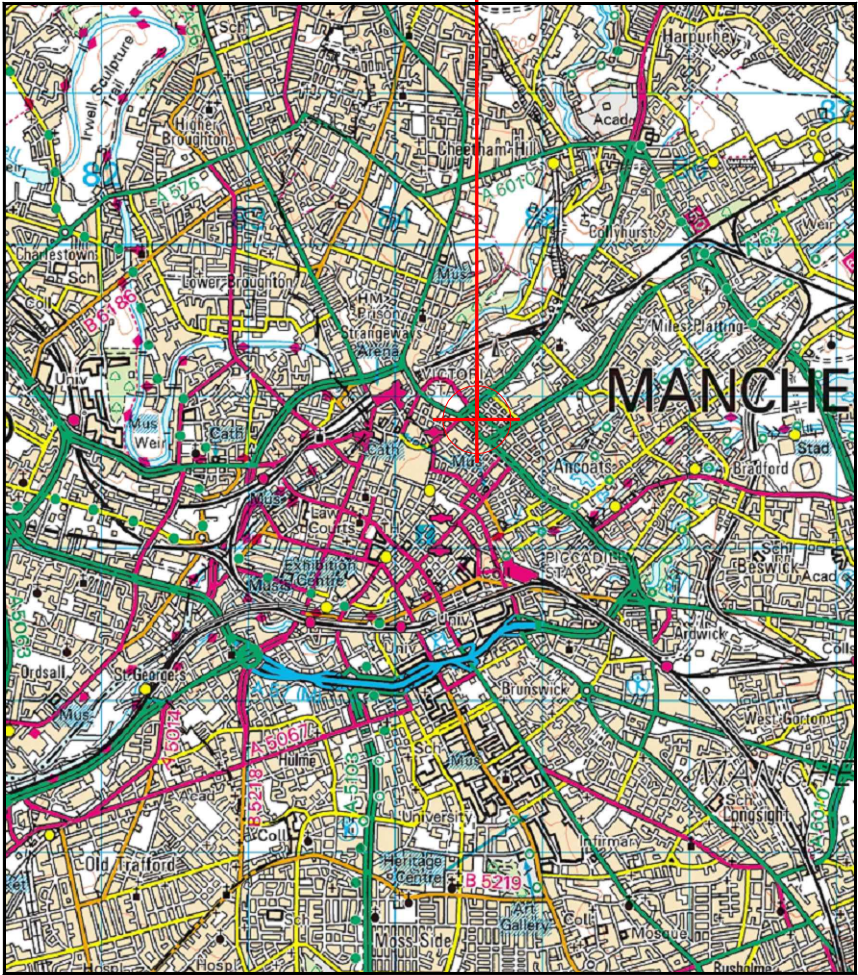


Reproduced by permission of Ordnance Survey on behalf of the Controller of Her Majesty's Stationery Office All rights reserved. © Crown Copyright licence no. 100022432

SITE AREA PLAN

 Scale 1:50,000

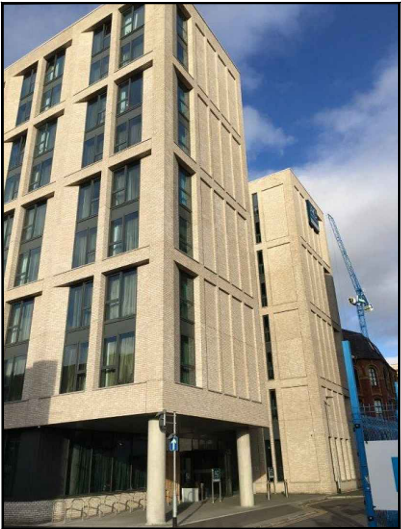

SITE PHOTOGRAPH

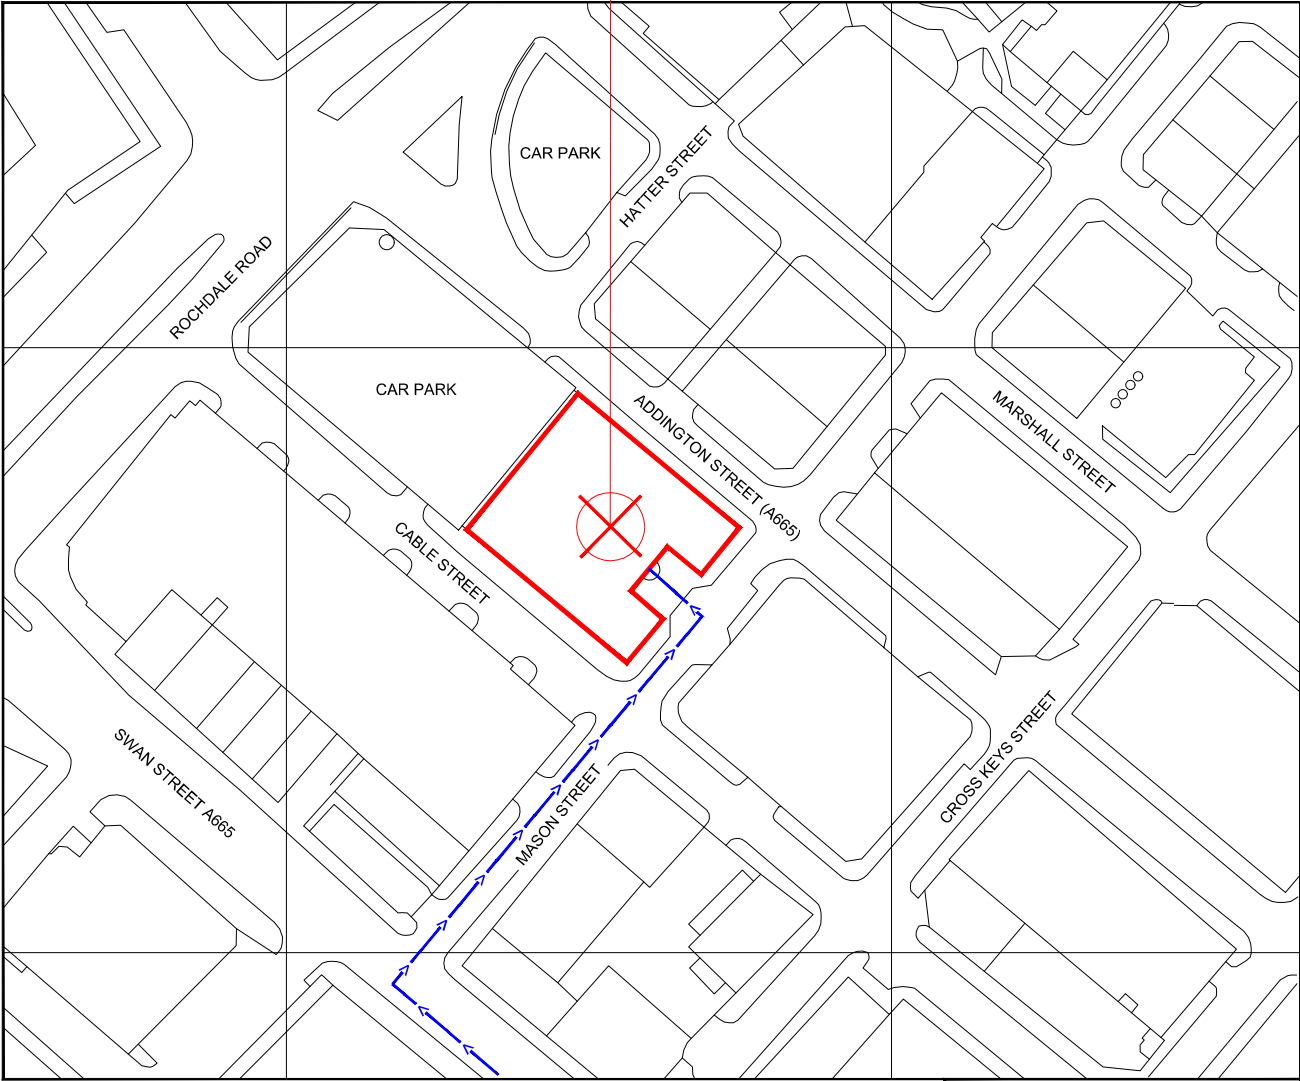


Reproduced by permission of Ordnance Survey on behalf of the Controller of Her Majesty's Stationery Office. All rights reserved. © Crown Copyright licence no. 100022432

NGR E: 384555 N: 398867

SITE LOCATION PLAN

 Scale 1:1250



GOOGLE MAPS QR CODE

GOOGLE MAP - [Hyperlink to map of the site](#)

GOOGLE STREETVIEW - [Hyperlink to streetview of the site](#)

NOTES:

1. ALL DIMENSIONS IN MM UNLESS OTHERWISE NOTED.

From East end of the A57(M) continue onto the A635 and then A665. Continue past the junction with the A62 for approx 150m and turn right onto Mason Street. Site is on the left hand side after 70m.

Site Provider's
Property Boundary:



Access Route To Site:



Access Route:



Master:	MBNL / EE / H3G:	Project:	Purpose of Issue:	Issue:
M004	MBNL	NTQ	Planning	D
Date:	07.12.21	Revision / Upgrade Description:		
Drawn:	L.COLEBOURN	Antenna colour added, to be RAL 7035 at LPA request		
Checked:	A.FANNING			
Approved:	P.CONVERY			
Master:	MBNL / EE / H3G:	Project:	Purpose of Issue:	Issue:
M003	MBNL	NTQ	Planning	C
Date:	01.03.21	Revision / Upgrade Description:		
Drawn:	A.FANNING	Dish location amended		
Checked:	P.CONVERY			
Approved:	P.CONVERY			
Master:	MBNL / EE / H3G:	Project:	Purpose of Issue:	Issue:
M002	MBNL	NTQ	Planning	B
Date:	05.02.21	Revision / Upgrade Description:		
Drawn:	A.FANNING	Site Design Solution Amended to H3b		
Checked:	P.CONVERY			
Approved:	P.CONVERY			
Master:	MBNL / EE / H3G:	Project:	Purpose of Issue:	Issue:
M001	MBNL	NTQ	Planning	A
Date:	12.01.21	Revision / Upgrade Description:		
Drawn:	J. BOOTE	First Issue		
Checked:	J. STOCKDALE			
Approved:	J. STOCKDALE			



Hutchison 3G UK Limited
Star House, 20 Grenfell Road
Madderhead, SL8 1EH
Tel: 01628 765 000
Fax: 01628 765 001



Hatfield Business Park
Hatfield
Hertfordshire
AL10 9BW
Tel: 01707 315000
Fax: 01707 319001



Mobile Broadband Network Limited
Sixth Floor, Thames Tower, Station Road, Reading, RG1 1LX

Design Consultant & Principal Contractor:



WHP Telecoms
Unit 1 Maple Park,
Low Fields Avenue, Leeds
LS12 6HH

Tel: 01133023550
e-mail: info@whptelecoms.com

Site Name:	AC HOTEL BY MARRIOTT RT		
Site ID:	1570005		
Address:	AC HOTEL BY MARRIOTT, 15 MASON STREET, MANCHESTER, GREATER MANCHESTER, M4 5FT		
Title:	002 SITE LOCATION PLAN		
Project:	NTQ		
Purpose of Issue:	GENERAL ARRANGEMENT		
EE Cell ID:	MBNL Cell ID:	3UK Cell ID:	
79787	MAN435	-	
Master Drawing No:			Issue:
1570005_MAN435_79787_M004			D



Asset Reference	Asset Description:	Asset Status:	Antenna / Dish / MHA / RRU / Equipment Access Description:	Asset Reference	Asset Description:	Asset Status:	Antenna / Dish / MHA / RRU / Equipment Access Description:
A1-A2	Antenna	Proposed	Rigger access only	RA1-2	RRU	Proposed	Unrestricted access
B1-B2	Antenna	Proposed	Rigger access only	RB1-2	RRU	Proposed	Unrestricted access
C1-C2	Antenna	Proposed	Rigger access only	RC1-2	RRU	Proposed	Unrestricted access
CAB1-6	Cabinet	Proposed	Unrestricted access	AMPA1-6	MHA	Proposed	Rigger access only
TD1	Dish	Proposed	Rigger access only	AMPB1-6	MHA	Proposed	Rigger access only
TD2	Dish	Proposed	Rigger access only	AMPC1-6	MHA	Proposed	Rigger access only
TD3	Dish	Proposed	Rigger access only	BB1-8	BOB Bottom	Proposed	Unrestricted access
TD4	Dish	Proposed	Rigger access only	AR1-12	Active Router	Proposed	Rigger access only
				PR1-18	Passive Router	Proposed	Unrestricted access
				RRU BTM 1-24	RRU Cabinet Level	Proposed	Unrestricted access

NOTES:
1. ALL DIMENSIONS IN MM UNLESS OTHERWISE NOTED.

SHARED CONFIGURATION SITE

RF CONFIG H3b

Master:	MBNL / EE / H3G:	Project:	Purpose of Issue:	Issue:
M004	MBNL	NTQ	Planning	D
Date:	07.12.21	Revision / Upgrade Description:		
Drawn:	L.COLEBOURN	Antenna colour added, to be RAL 7035 at LPA request		
Checked:	A.FANNING			
Approved:	P.CONVERY			
Master:	MBNL / EE / H3G:	Project:	Purpose of Issue:	Issue:
M003	MBNL	NTQ	Planning	C
Date:	01.03.21	Revision / Upgrade Description:		
Drawn:	A.FANNING	Dish location amended		
Checked:	P.CONVERY			
Approved:	P.CONVERY			
Master:	MBNL / EE / H3G:	Project:	Purpose of Issue:	Issue:
M002	MBNL	NTQ	Planning	B
Date:	05.02.21	Revision / Upgrade Description:		
Drawn:	A.FANNING	Site Design Solution Amended to H3b		
Checked:	P.CONVERY			
Approved:	P.CONVERY			
Master:	MBNL / EE / H3G:	Project:	Purpose of Issue:	Issue:
M001	MBNL	NTQ	Planning	A
Date:	12.01.21	Revision / Upgrade Description:		
Drawn:	J. BOOTE	First Issue		
Checked:	J. STOCKDALE			
Approved:	J. STOCKDALE			



Hutchison 3G UK Limited
Star House, 20 Grenfell Road
Maidenhead, SL6 1EH
Tel: 01628 765 000
Fax: 01628 765 001



Hatfield Business Park
Hatfield
Hertfordshire
AL10 9BW
Tel: 01707 315000
Fax: 01707 319001



Mobile Broadband Network Limited
Sixth Floor, Thames Tower, Station Road, Reading, RG1 1LX

Design Consultant & Principal Contractor:



WHP Telecoms
Unit 1 Maple Park,
Low Fields Avenue, Leeds
LS12 6HH

Tel: 01133023550
e-mail: info@whptelecoms.com

Site Name:
AC HOTEL BY MARRIOTT RT

Site ID:
1570005

Address:
AC HOTEL BY MARRIOTT,
15 MASON STREET,
MANCHESTER,
GREATER MANCHESTER,
M4 5FT

Title:
003 ACCESS PLAN

Project:
NTQ

Purpose of Issue:
GENERAL ARRANGEMENT

EE Cell ID:	MBNL Cell ID:	3UK Cell ID:
79787	MAN435	-

Master Drawing No:	Issue:
1570005_MAN435_79787_M004	D

CAB 1-6 BB1-8 PR1-18 RRU BTM 1-24

A1-A2 RA1-2 AMP A1-6 AR1-4

TD 4

TD 1&2

C1-C2 RC1-2 AMP C1-6 AR9-12

TD 3

B1-B2 RB1-2 AMP B1-6 AR5-8


ACCESS PLAN
Scale 1:200



100mm

50mm

10mm

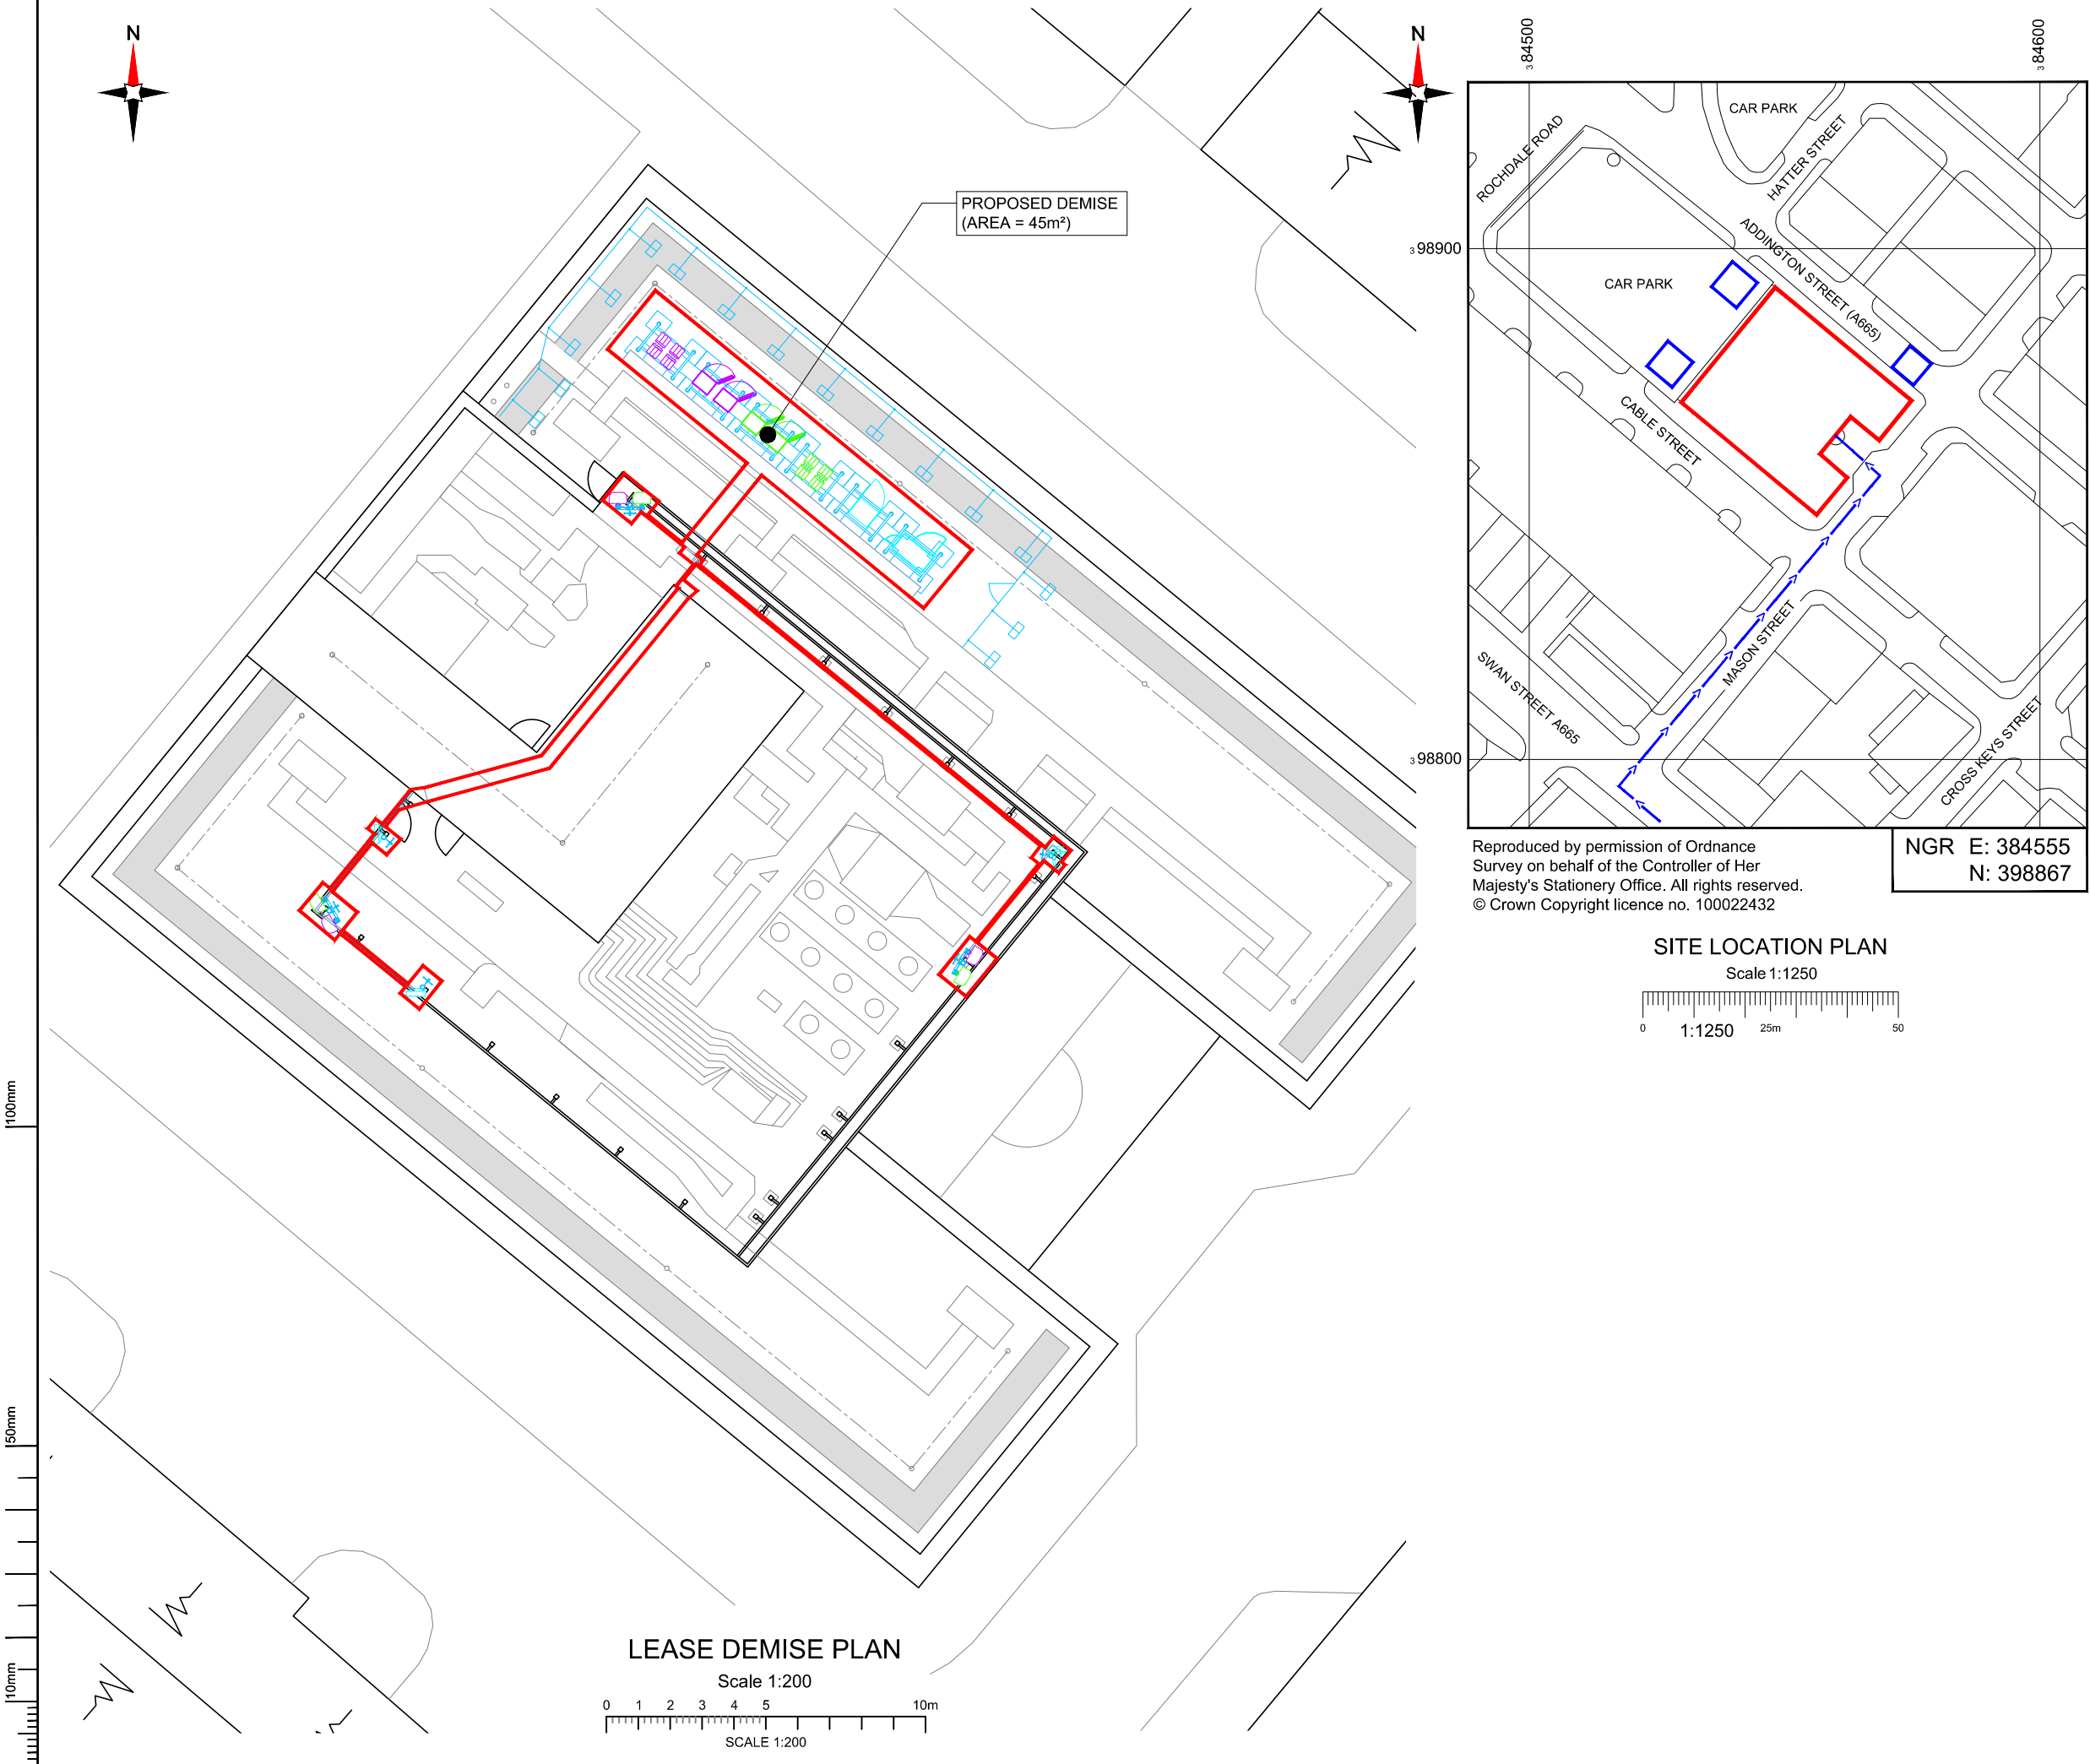

NEW CODE:

Demise:	Outlined in Red	
Access Route:	Solid Brown	
Set Down Area:	Outlined in Blue	

Master:	MBNL / EE / H3G:	Project:	Purpose of Issue:	Issue:
M004	MBNL	NTQ	Planning	D
Date:	07.12.21	Revision / Upgrade Description:		
Drawn:	L.COLEBOURN	Antenna colour added, to be RAL 7035 at LPA request		
Checked:	A.FANNING			
Approved:	P. CONVERY			
Master:	MBNL / EE / H3G:	Project:	Purpose of Issue:	Issue:
M003	MBNL	NTQ	Planning	C
Date:	01.03.21	Revision / Upgrade Description:		
Drawn:	A.FANNING	Dish location amended		
Checked:	P. CONVERY			
Approved:	P. CONVERY			
Master:	MBNL / EE / H3G:	Project:	Purpose of Issue:	Issue:
M002	MBNL	NTQ	Planning	B
Date:	05.02.21	Revision / Upgrade Description:		
Drawn:	A.FANNING	Site Design Solution Amended to H3b		
Checked:	P. CONVERY			
Approved:	P. CONVERY			
Master:	MBNL / EE / H3G:	Project:	Purpose of Issue:	Issue:
M001	MBNL	NTQ	Planning	A
Date:	12.01.21	Revision / Upgrade Description:		
Drawn:	J. BOOTE	First Issue		
Checked:	J. STOCKDALE			
Approved:	J. STOCKDALE			

Hutchison 3G UK Limited
Star House, 20 Grenfell Road
Maidenhead, SL6 1EH
Tel: 01628 765 000
Fax: 01628 765 001

H3G Base Station Information line:
0845 6043000
Available 9am-6pm Monday to Friday

Hatfield Business Park
Hatfield
Hertfordshire
AL10 9BW

Tel: 01707 315000
Fax: 01707 319001

Mobile Broadband Network Limited
Sixth Floor, Thames Tower, Station Road, Reading, RG1 1LX

Design Consultant & Principal Contractor:

WHP Telecoms
Unit 1 Maple Park,
Low Fields Avenue, Leeds
LS12 6HH

Tel: 01133023550
e-mail: info@whptelecoms.com

Site Name:

AC HOTEL BY MARRIOTT RT

Site ID:

1570005

Address:

AC HOTEL BY MARRIOTT,
15 MASON STREET,
MANCHESTER,
GREATER MANCHESTER,
M4 5FT

Title:

004 LEASE DEMISE

Project:

NTQ

Purpose of Issue:

GENERAL ARRANGEMENT


EE Cell ID:	MBNL Cell ID:	3UK Cell ID:
79787	MAN435	-

Master Drawing No:

1570005_MAN435_79787_M004

Issue:

D

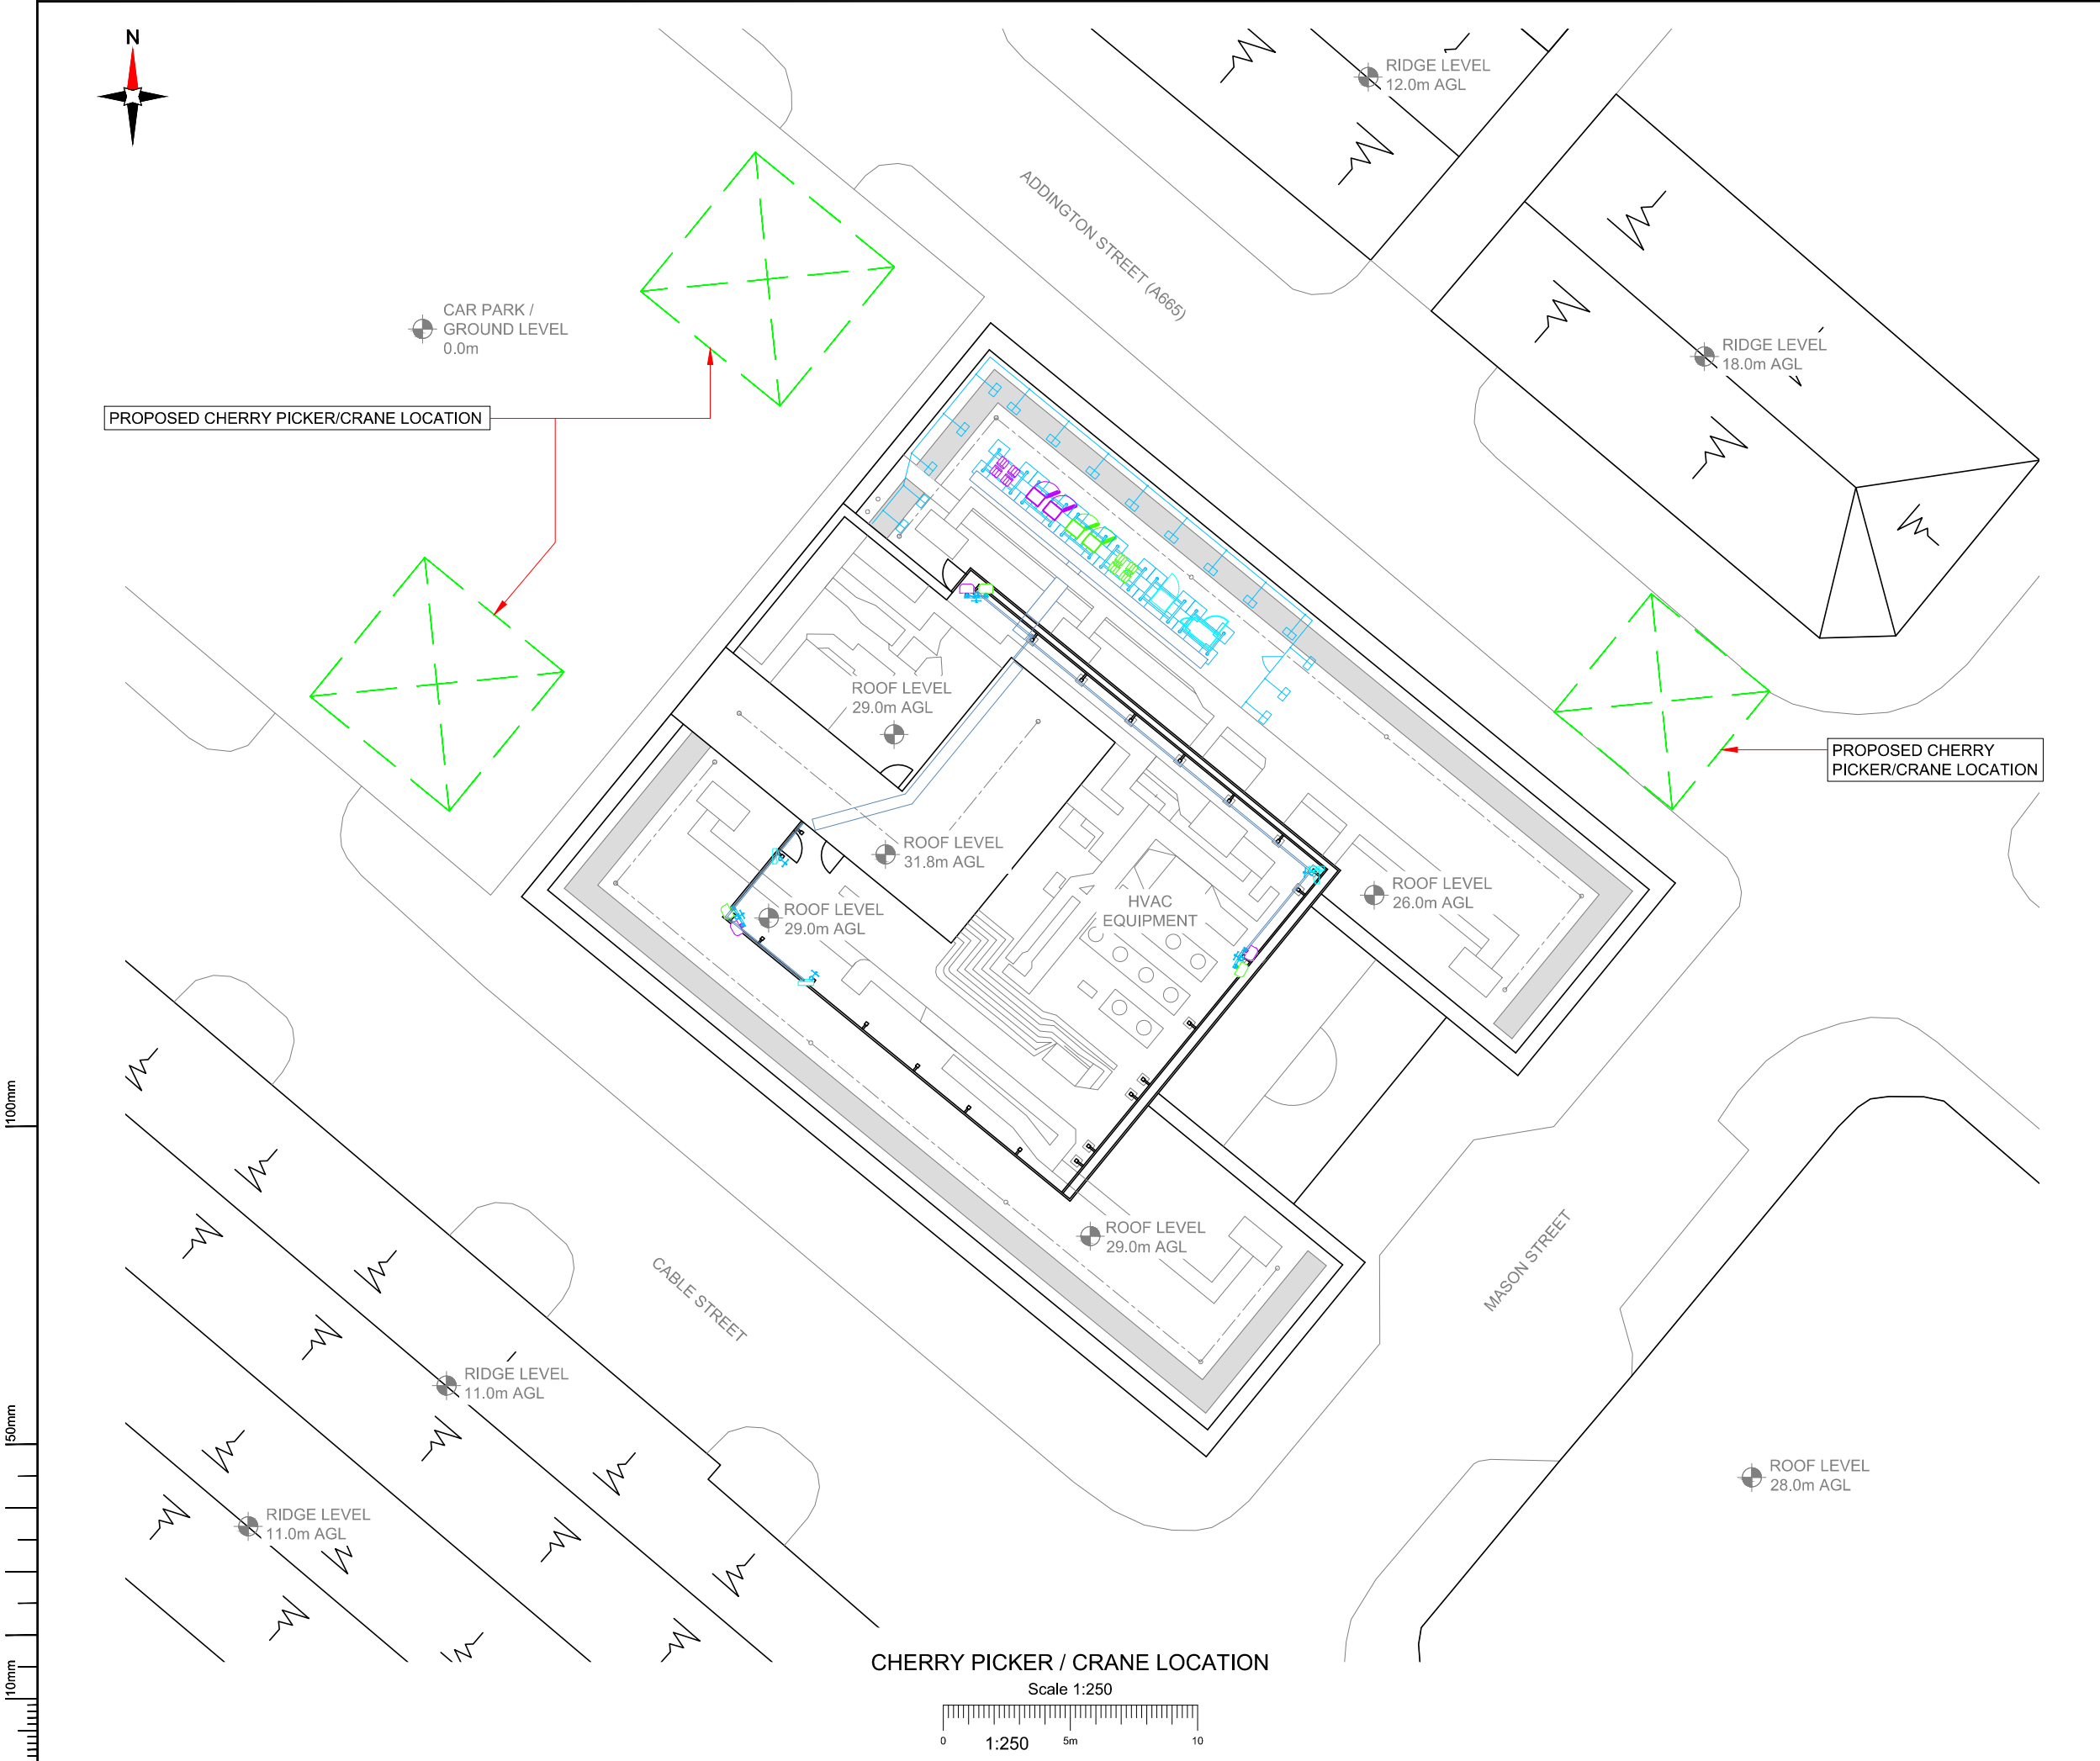

NOTES:

1. ALL DIMENSIONS IN MM UNLESS OTHERWISE NOTED.

PROPOSED CRANE OR CHERRY PICKER LOCATION:

Master:	MBNL / EE / H3G:	Project:	Purpose of Issue:	Issue:
M004	MBNL	NTQ	Planning	D
Date:	07.12.21	Revision / Upgrade Description:		
Drawn:	L.COLEBOURN	Antenna colour added, to be RAL 7035 at LPA request		
Checked:	A.FANNING			
Approved:	P.CONVERY			
Master:	MBNL / EE / H3G:	Project:	Purpose of Issue:	Issue:
M003	MBNL	NTQ	Planning	C
Date:	01.03.21	Revision / Upgrade Description:		
Drawn:	A.FANNING	Dish location amended		
Checked:	P.CONVERY			
Approved:	P.CONVERY			
Master:	MBNL / EE / H3G:	Project:	Purpose of Issue:	Issue:
M002	MBNL	NTQ	Planning	B
Date:	05.02.21	Revision / Upgrade Description:		
Drawn:	A.FANNING	Site Design Solution Amended to H3b		
Checked:	P.CONVERY			
Approved:	P.CONVERY			
Master:	MBNL / EE / H3G:	Project:	Purpose of Issue:	Issue:
M001	MBNL	NTQ	Planning	A
Date:	12.01.21	Revision / Upgrade Description:		
Drawn:	J. BOOTE	First Issue		
Checked:	J. STOCKDALE			
Approved:	J. STOCKDALE			

Hutchison 3G UK Limited
Star House, 20 Grenfell Road
Maidenhead, SL6 1EH
Tel: 01628 765 000
Fax: 01628 765 001

H3G Base Station Information line:
0845 6043000
Available 9am-5pm Monday to Friday

Hatfield Business Park
Hatfield
Hertfordshire
AL10 9BW

Tel: 01707 315000
Fax: 01707 319001

MBNL Mobile Broadband Network Limited
Sixth Floor, Thames Tower, Station Road, Reading, RG1 1LX

Design Consultant & Principal Contractor:

WHP Telecoms
Unit 1 Maple Park,
Low Fields Avenue, Leeds
LS12 6HH

Tel: 01133023550
e-mail: info@whptelecoms.com

Site Name:

AC HOTEL BY MARRIOTT RT

Site ID:

1570005

Address:

AC HOTEL BY MARRIOTT,
15 MASON STREET,
MANCHESTER,
GREATER MANCHESTER,
M4 5FT

Title:

005 CHERRY PICKER & CRANE LOCATION

Project:

NTQ

Purpose of Issue:

GENERAL ARRANGEMENT


EE Cell ID:	MBNL Cell ID:	3UK Cell ID:
79787	MAN435	-

Master Drawing No:

1570005_MAN435_79787_M004

Issue:

D

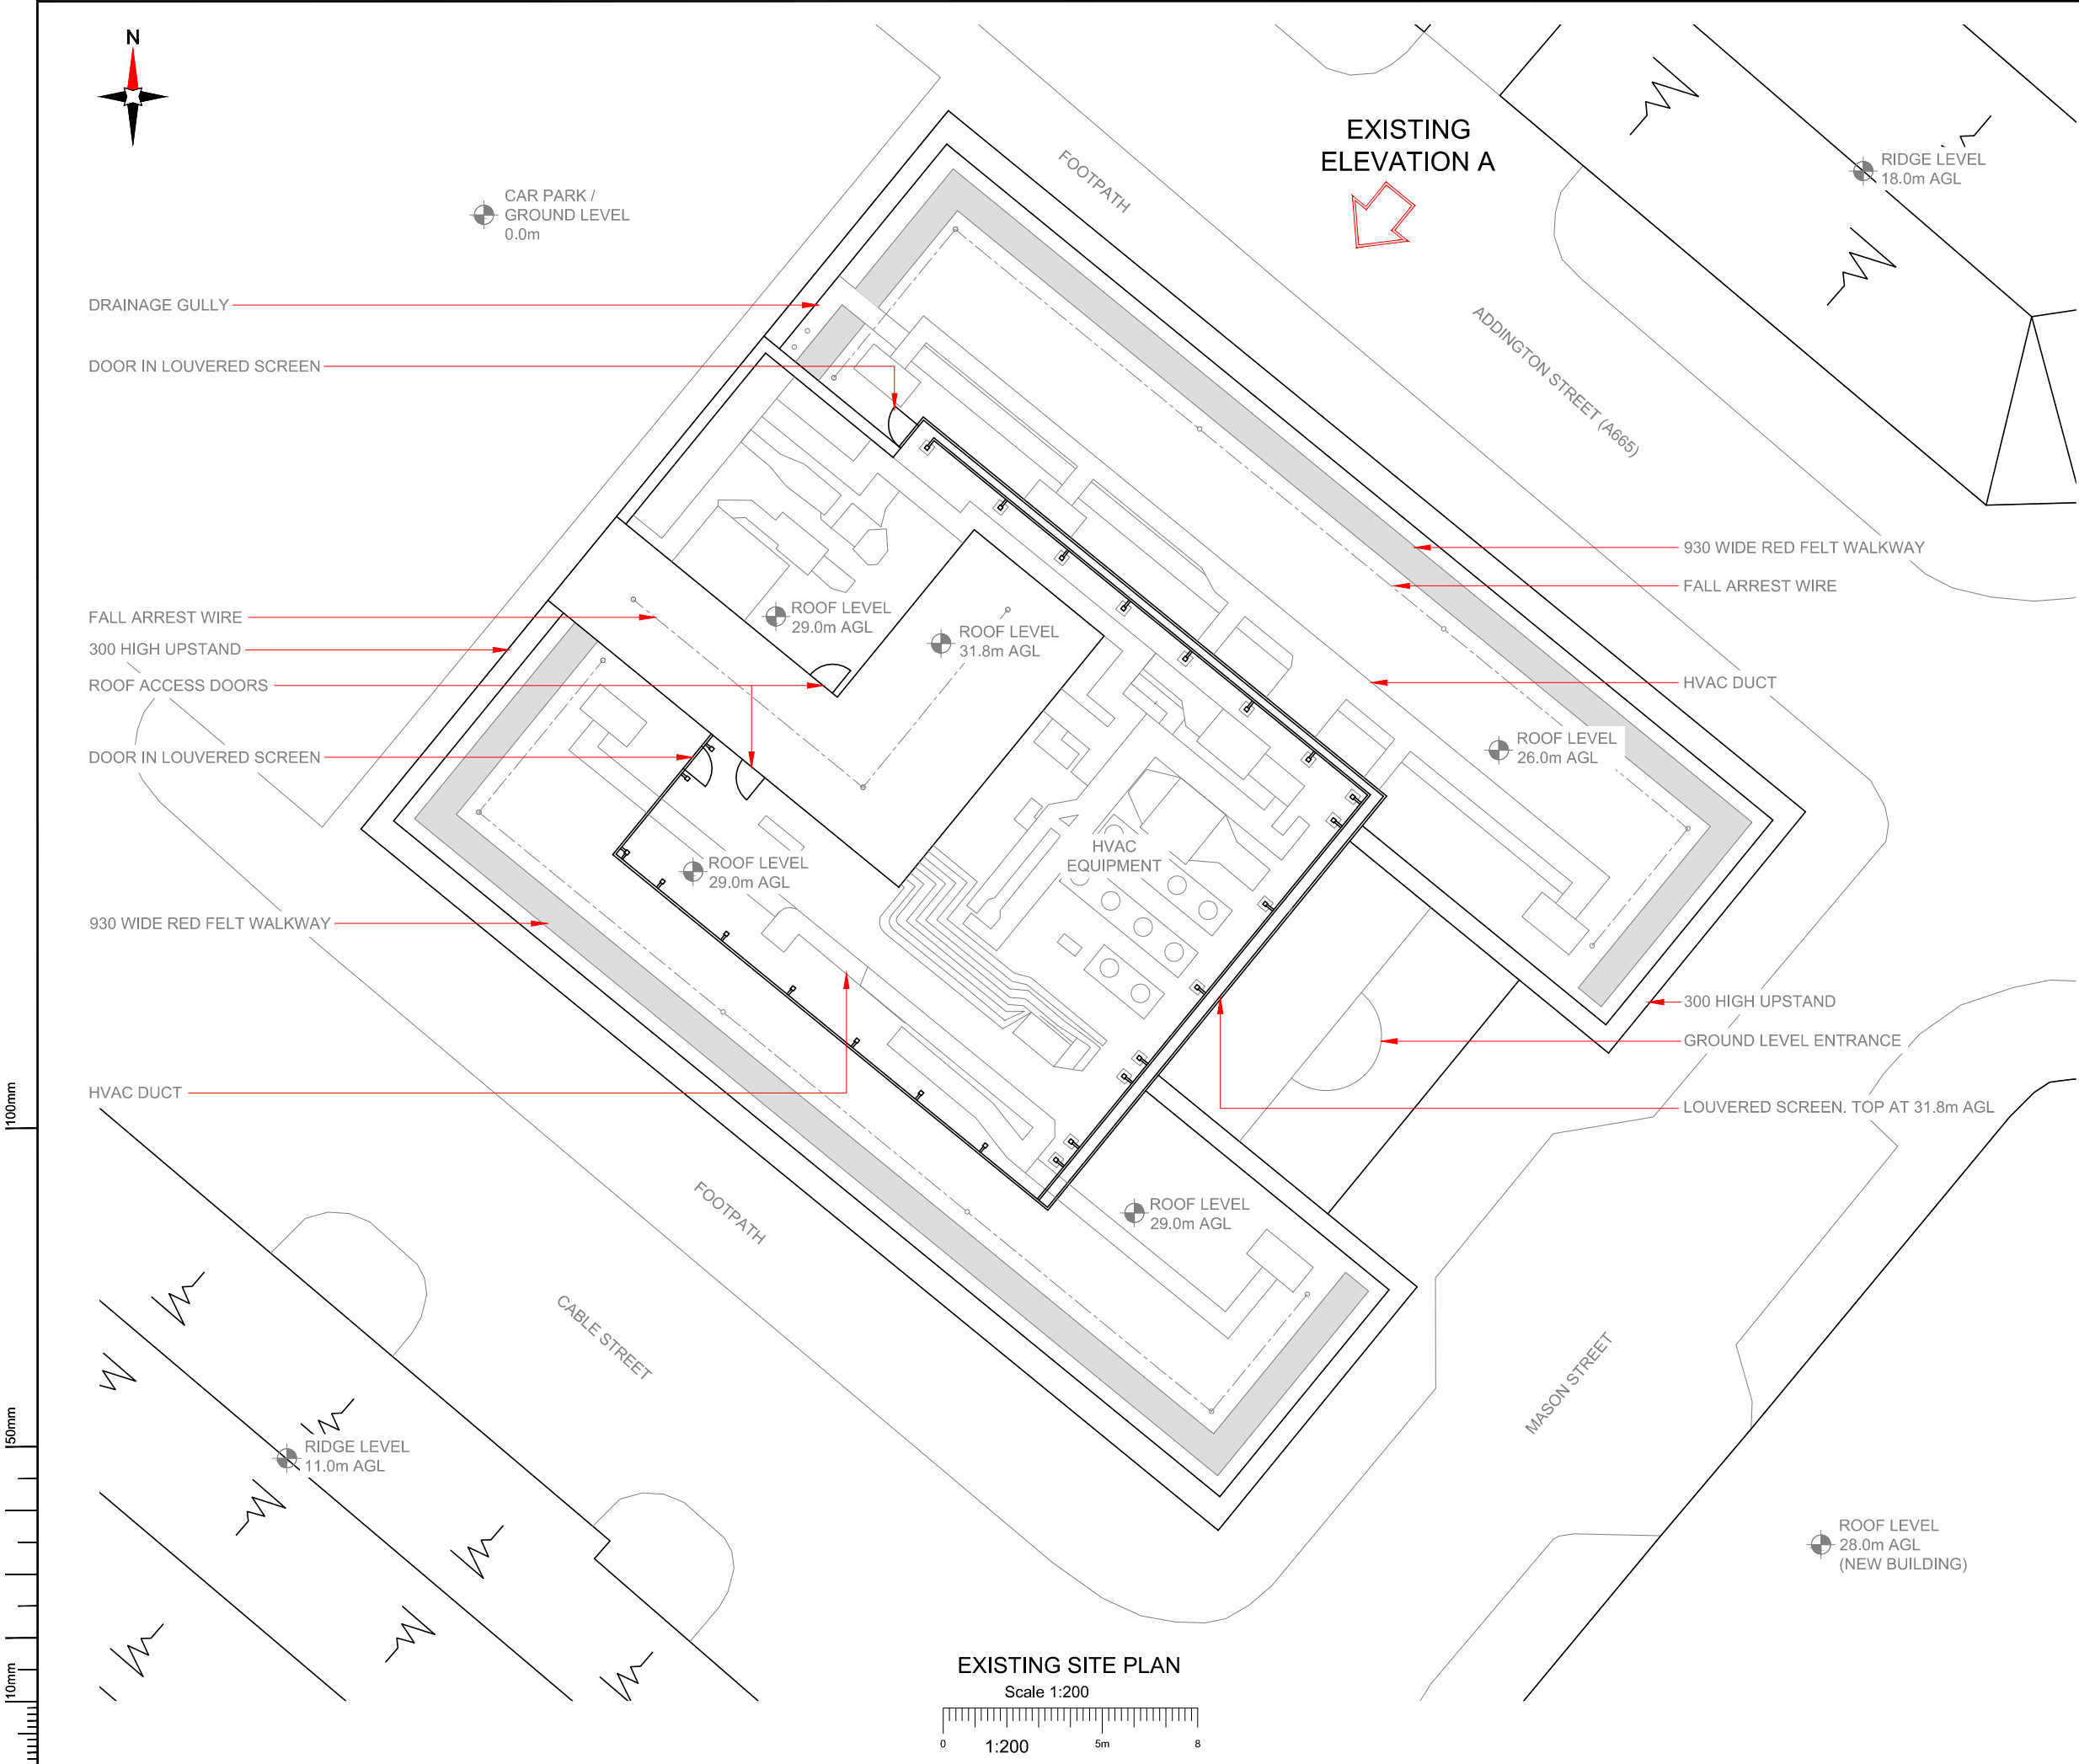

- NOTES:
- ALL DIMENSIONS IN MM UNLESS OTHERWISE NOTED.

Master:	MBNL / EE / H3G:	Project:	Purpose of Issue:	Issue:
M004	MBNL	NTQ	Planning	D
Date:	07.12.21	Revision / Upgrade Description:		
Drawn:	L.COLEBOURN	Antenna colour added, to be RAL 7035 at LPA request		
Checked:	A.FANNING			
Approved:	P.CONVERY			
Master:	MBNL / EE / H3G:	Project:	Purpose of Issue:	Issue:
M003	MBNL	NTQ	Planning	C
Date:	01.03.21	Revision / Upgrade Description:		
Drawn:	A.FANNING	Dish location amended		
Checked:	P.CONVERY			
Approved:	P.CONVERY			
Master:	MBNL / EE / H3G:	Project:	Purpose of Issue:	Issue:
M002	MBNL	NTQ	Planning	B
Date:	05.02.21	Revision / Upgrade Description:		
Drawn:	A.FANNING	Site Design Solution Amended to H3b		
Checked:	P.CONVERY			
Approved:	P.CONVERY			
Master:	MBNL / EE / H3G:	Project:	Purpose of Issue:	Issue:
M001	MBNL	NTQ	Planning	A
Date:	12.01.21	Revision / Upgrade Description:		
Drawn:	J. BOOTE	First Issue		
Checked:	J. STOCKDALE			
Approved:	J. STOCKDALE			



Hutchison 3G UK Limited
Star House, 20 Grenfell Road
Maidenhead, SL6 1EH
Tel: 01628 765 000
Fax: 01628 765 001



Hatfield Business Park
Hatfield
Hertfordshire
AL10 9BW
Tel: 01707 315000
Fax: 01707 319001



Mobile Broadband Network Limited
Sixth Floor, Thames Tower, Station Road, Reading, RG1 1LX

Design Consultant & Principal Contractor:



WHP Telecoms
Unit 1 Maple Park,
Low Fields Avenue, Leeds
LS12 6HH

Tel: 01133023550
e-mail: info@whptelecoms.com

Site Name:
AC HOTEL BY MARRIOTT RT

Site ID:
1570005

Address:
**AC HOTEL BY MARRIOTT,
15 MASON STREET,
MANCHESTER,
GREATER MANCHESTER,
M4 5FT**

Title:
100 EXISTING SITE PLAN

Project:
NTQ

Purpose of Issue:
GENERAL ARRANGEMENT


EE Cell ID:	MBNL Cell ID:	3UK Cell ID:
79787	MAN435	-

Master Drawing No:	Issue:
1570005_MAN435_79787_M004	D

100mm


50mm

10mm

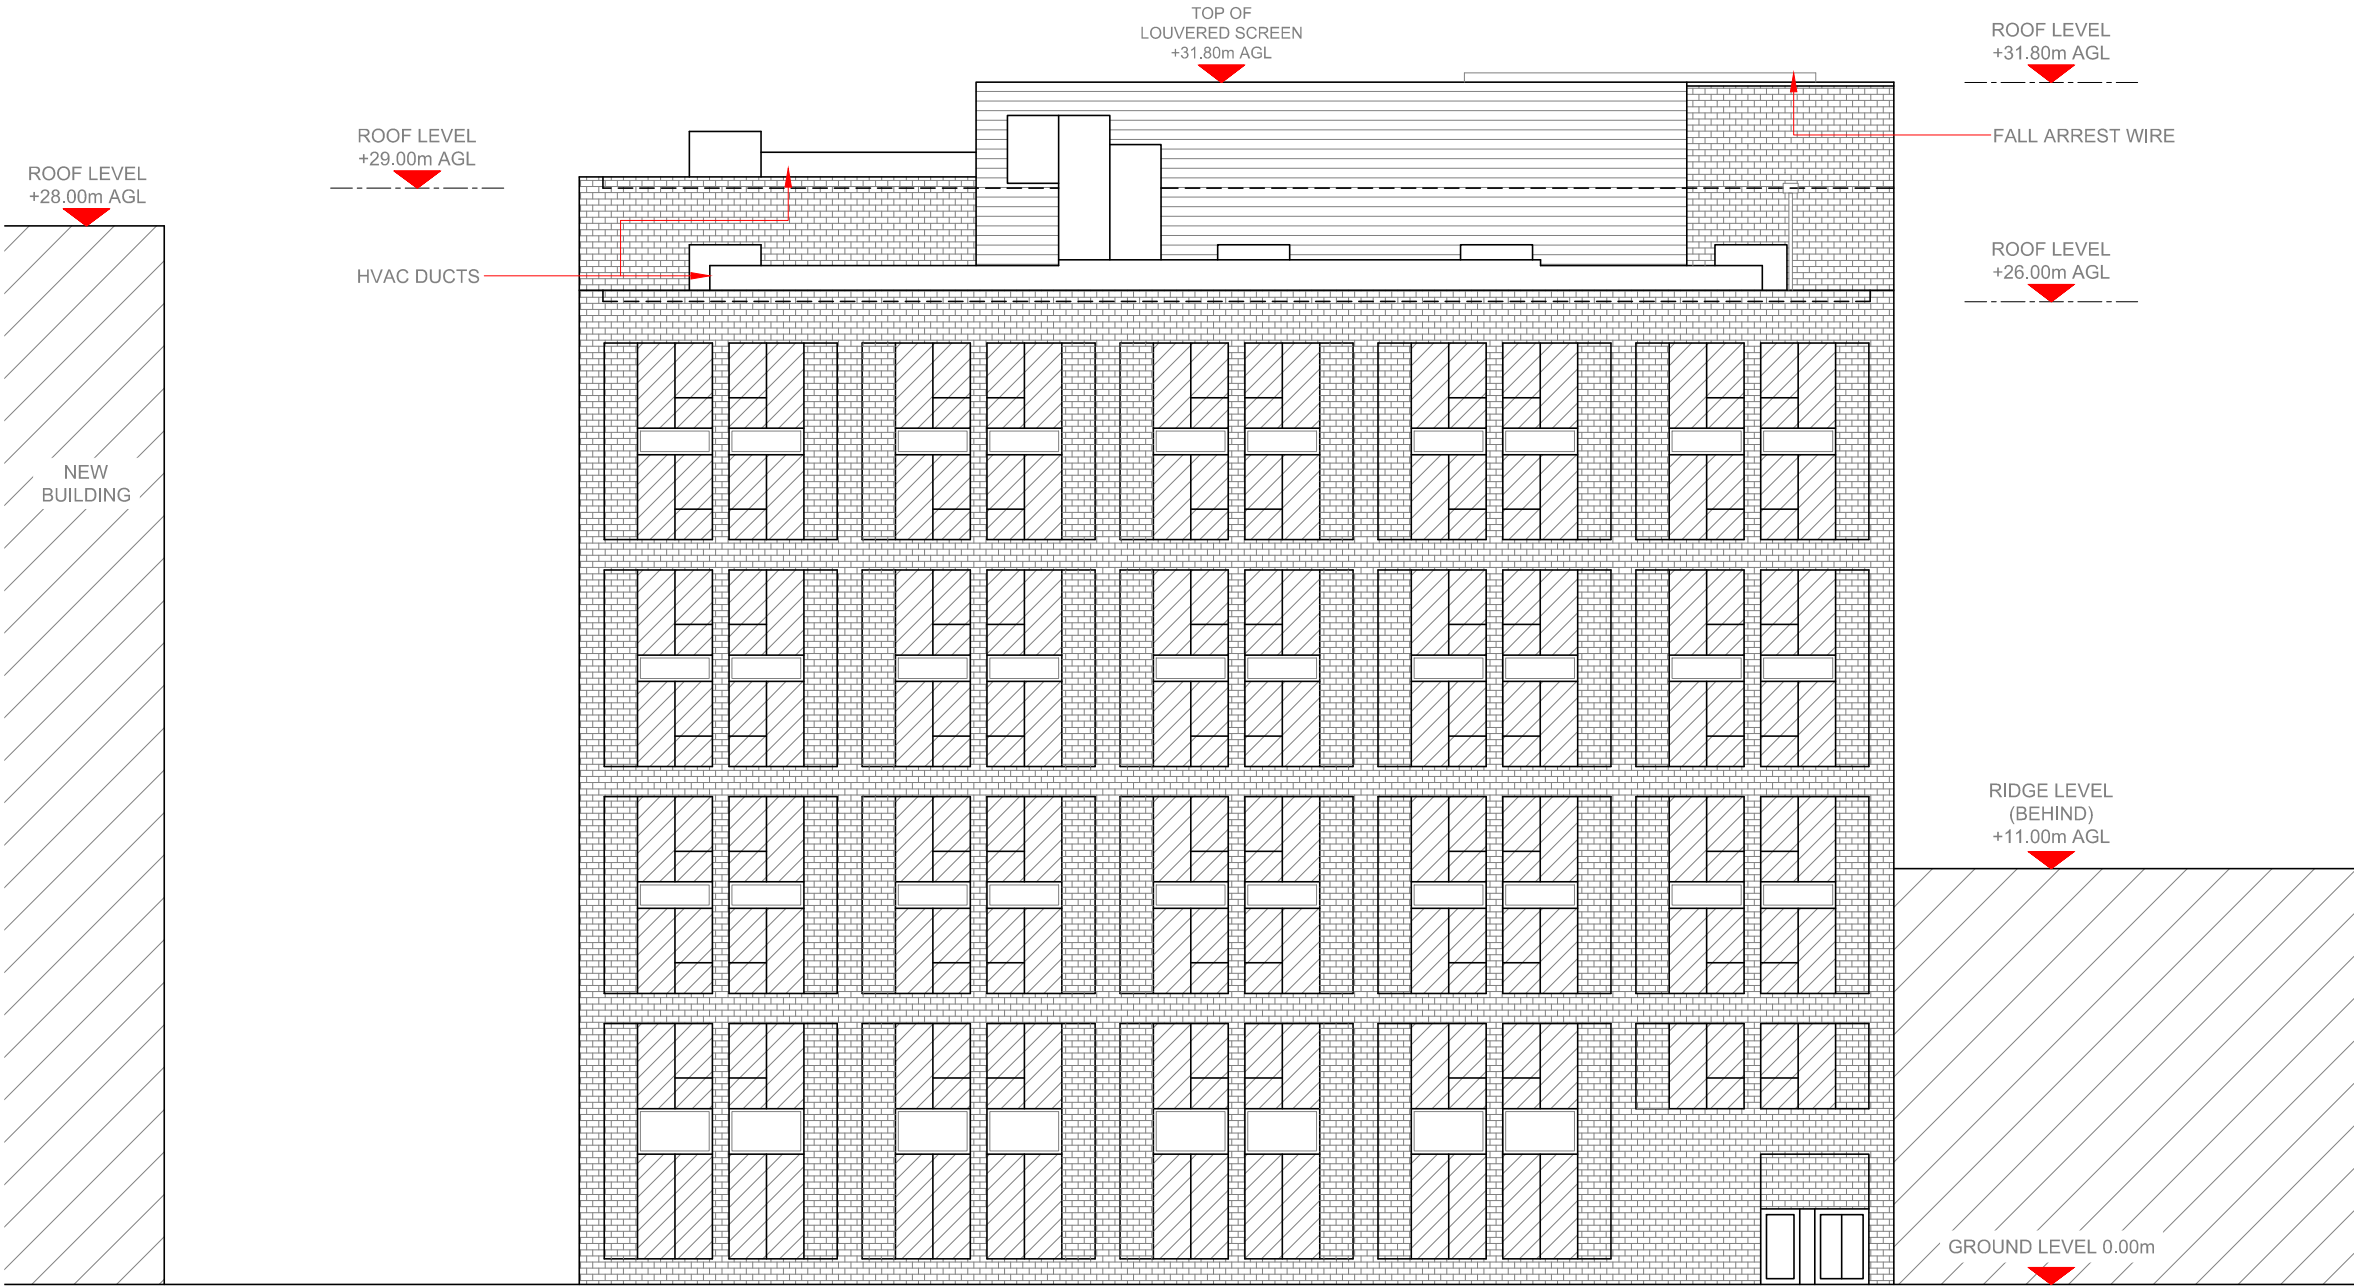

EXISTING ELEVATION A

 Scale 1:200



NOTES:

1. ALL DIMENSIONS IN MM UNLESS OTHERWISE NOTED.

Master:	MBNL / EE / H3G:	Project:	Purpose of Issue:	Issue:
M004	MBNL	NTQ	Planning	D
Date:	07.12.21	Revision / Upgrade Description:		
Drawn:	L.COLEBOURN	Antenna colour added, to be RAL 7035 at LPA request		
Checked:	A.FANNING			
Approved:	P.CONVERY			
Master:	MBNL / EE / H3G:	Project:	Purpose of Issue:	Issue:
M003	MBNL	NTQ	Planning	C
Date:	01.03.21	Revision / Upgrade Description:		
Drawn:	A.FANNING	Dish location amended		
Checked:	P.CONVERY			
Approved:	P.CONVERY			
Master:	MBNL / EE / H3G:	Project:	Purpose of Issue:	Issue:
M002	MBNL	NTQ	Planning	B
Date:	05.02.21	Revision / Upgrade Description:		
Drawn:	A.FANNING	Site Design Solution Amended to H3b		
Checked:	P.CONVERY			
Approved:	P.CONVERY			
Master:	MBNL / EE / H3G:	Project:	Purpose of Issue:	Issue:
M001	MBNL	NTQ	Planning	A
Date:	12.01.21	Revision / Upgrade Description:		
Drawn:	J. BOOTE	First Issue		
Checked:	J. STOCKDALE			
Approved:	J. STOCKDALE			



Hutchison 3G UK Limited
Star House, 20 Grenfell Road
Mordenhead, SL8 1EH
Tel: 01628 765 000
Fax: 01628 765 001



Hatfield Business Park
Hatfield
Hertfordshire
AL10 9BW
Tel: 01707 315000
Fax: 01707 319001



Mobile Broadband Network Limited
Sixth Floor, Thames Tower, Station Road, Reading, RG1 1LX

Design Consultant & Principal Contractor:



WHP Telecoms
Unit 1 Maple Park,
Low Fields Avenue, Leeds
LS12 6HH

Tel: 01133023550
e-mail: info@whptelecoms.com

Site Name:
AC HOTEL BY MARRIOTT RT

Site ID:
1570005

Address:
**AC HOTEL BY MARRIOTT,
15 MASON STREET,
MANCHESTER,
GREATER MANCHESTER,
M4 5FT**


Title:
150 EXISTING ELEVATION A

Project:
NTQ

Purpose of Issue:
GENERAL ARRANGEMENT

EE Cell ID:	MBNL Cell ID:	3UK Cell ID:
79787	MAN435	-

Master Drawing No:	Issue:
1570005_MAN435_79787_M004	D

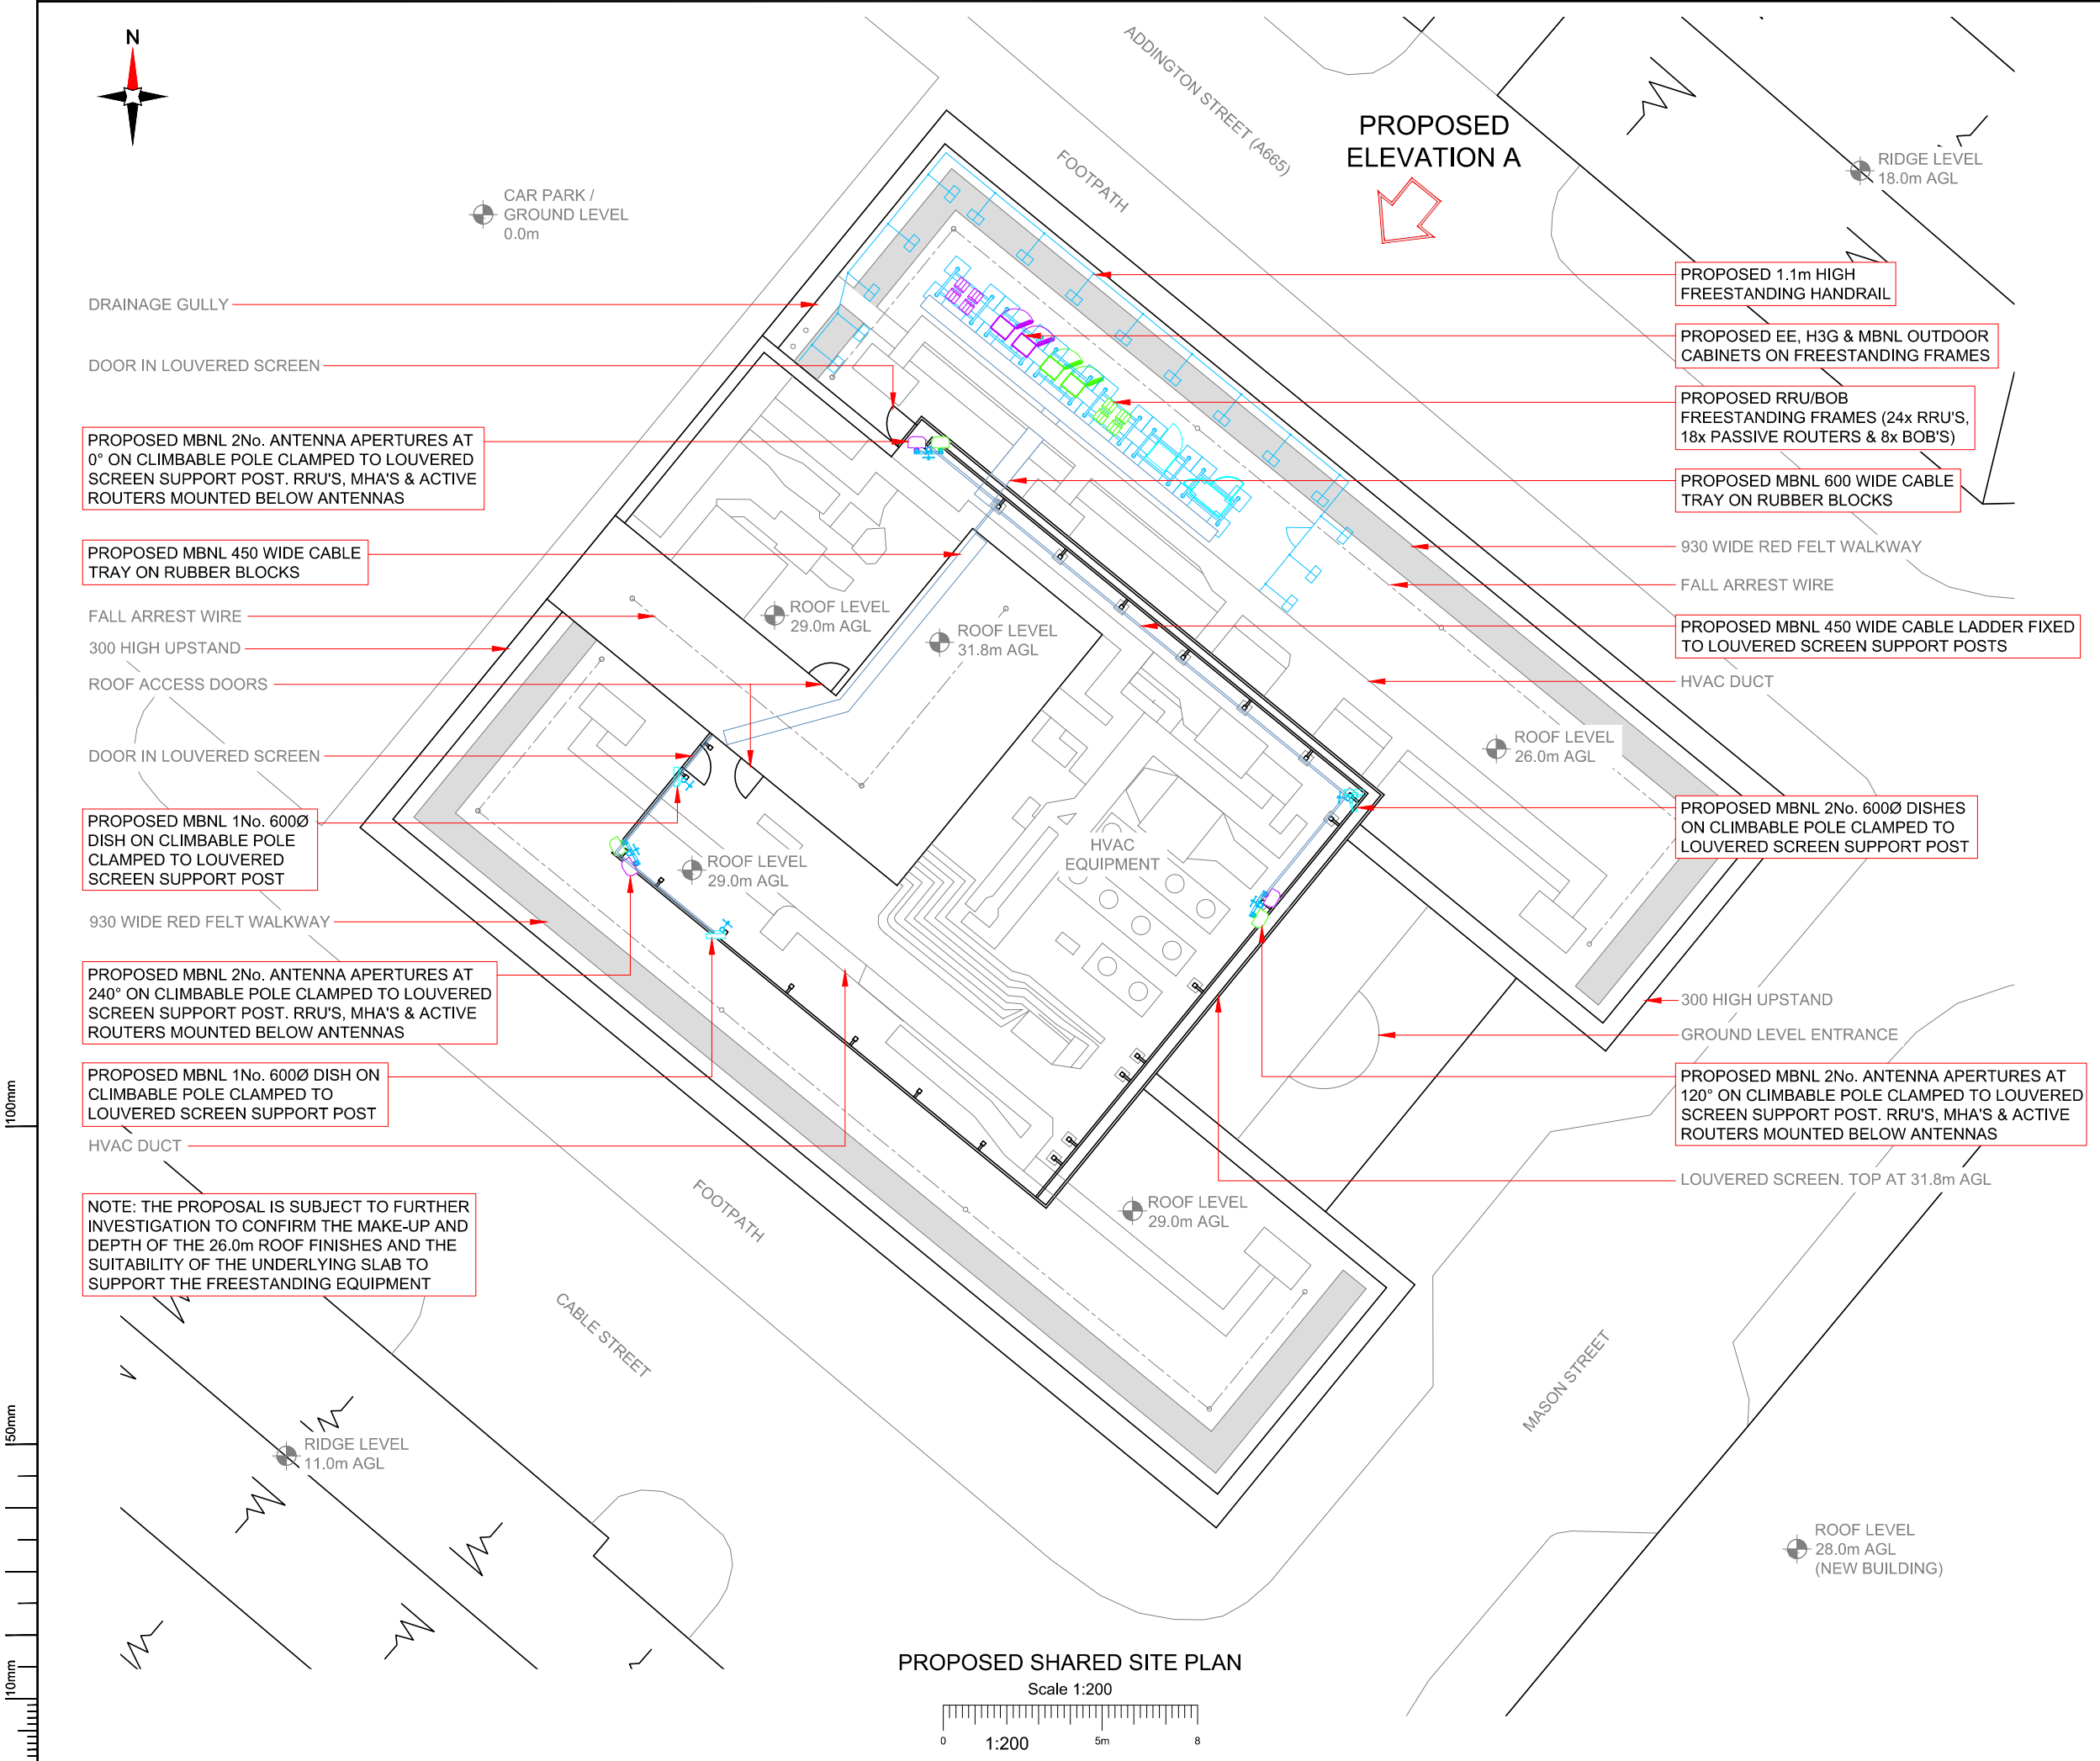

NOTES:

1. ALL DIMENSIONS IN MM UNLESS OTHERWISE NOTED.

NOTE:


ANTENNAS TO BE COLOURED LIGHT GREY RAL 7035

SHARED CONFIGURATION SITE

RF CONFIG	H3b
-----------	-----

Master:	MBNL / EE / H3G:	Project:	Purpose of Issue:	Issue:
M004	MBNL	NTQ	Planning	D
Date:	07.12.21	Revision / Upgrade Description:		
Drawn:	L.COLEBOURN	Antenna colour added, to be RAL 7035 at LPA request		
Checked:	A.FANNING			
Approved:	P.CONVERY			
Master:	MBNL / EE / H3G:	Project:	Purpose of Issue:	Issue:
M003	MBNL	NTQ	Planning	C
Date:	01.03.21	Revision / Upgrade Description:		
Drawn:	A.FANNING	Dish location amended		
Checked:	P.CONVERY			
Approved:	P.CONVERY			
Master:	MBNL / EE / H3G:	Project:	Purpose of Issue:	Issue:
M002	MBNL	NTQ	Planning	B
Date:	05.02.21	Revision / Upgrade Description:		
Drawn:	A.FANNING	Site Design Solution Amended to H3b		
Checked:	P.CONVERY			
Approved:	P.CONVERY			
Master:	MBNL / EE / H3G:	Project:	Purpose of Issue:	Issue:
M001	MBNL	NTQ	Planning	A
Date:	12.01.21	Revision / Upgrade Description:		
Drawn:	J. BOOTE	First Issue		
Checked:	J. STOCKDALE			
Approved:	J. STOCKDALE			
	Hutchison 3G UK Limited Star House, 20 Grenfell Road Macclesfield, SL6 1EH Tel: 01628 765 000 Fax: 01628 765 001 H3G Base Station Information line: 0845 6043000 Available 9am-6pm Monday to Friday		Hatfield Business Park Hatfield Hertfordshire AL10 9BW Tel: 01707 315000 Fax: 01707 319001	
 Mobile Broadband Network Limited Sixth Floor, Thames Tower, Station Road, Reading, RG1 1LX				
Design Consultant & Principal Contractor:				
		WHP Telecoms Unit 1 Maple Park, Low Fields Avenue, Leeds LS12 6HH Tel: 01133023550 e-mail: info@whptelecoms.com		
Site Name:				
AC HOTEL BY MARRIOTT RT				
Site ID:				
1570005				
Address:				
AC HOTEL BY MARRIOTT, 15 MASON STREET, MANCHESTER, GREATER MANCHESTER, M4 5FT				
Title:				
200 PROPOSED SHARED SITE PLAN				
Project:				
NTQ				
Purpose of Issue:				
GENERAL ARRANGEMENT				
EE Cell ID:		MBNL Cell ID:		3UK Cell ID:
79787		MAN435		-
Master Drawing No:				Issue:
1570005_MAN435_79787_M004				D

100mm
50mm
10mm

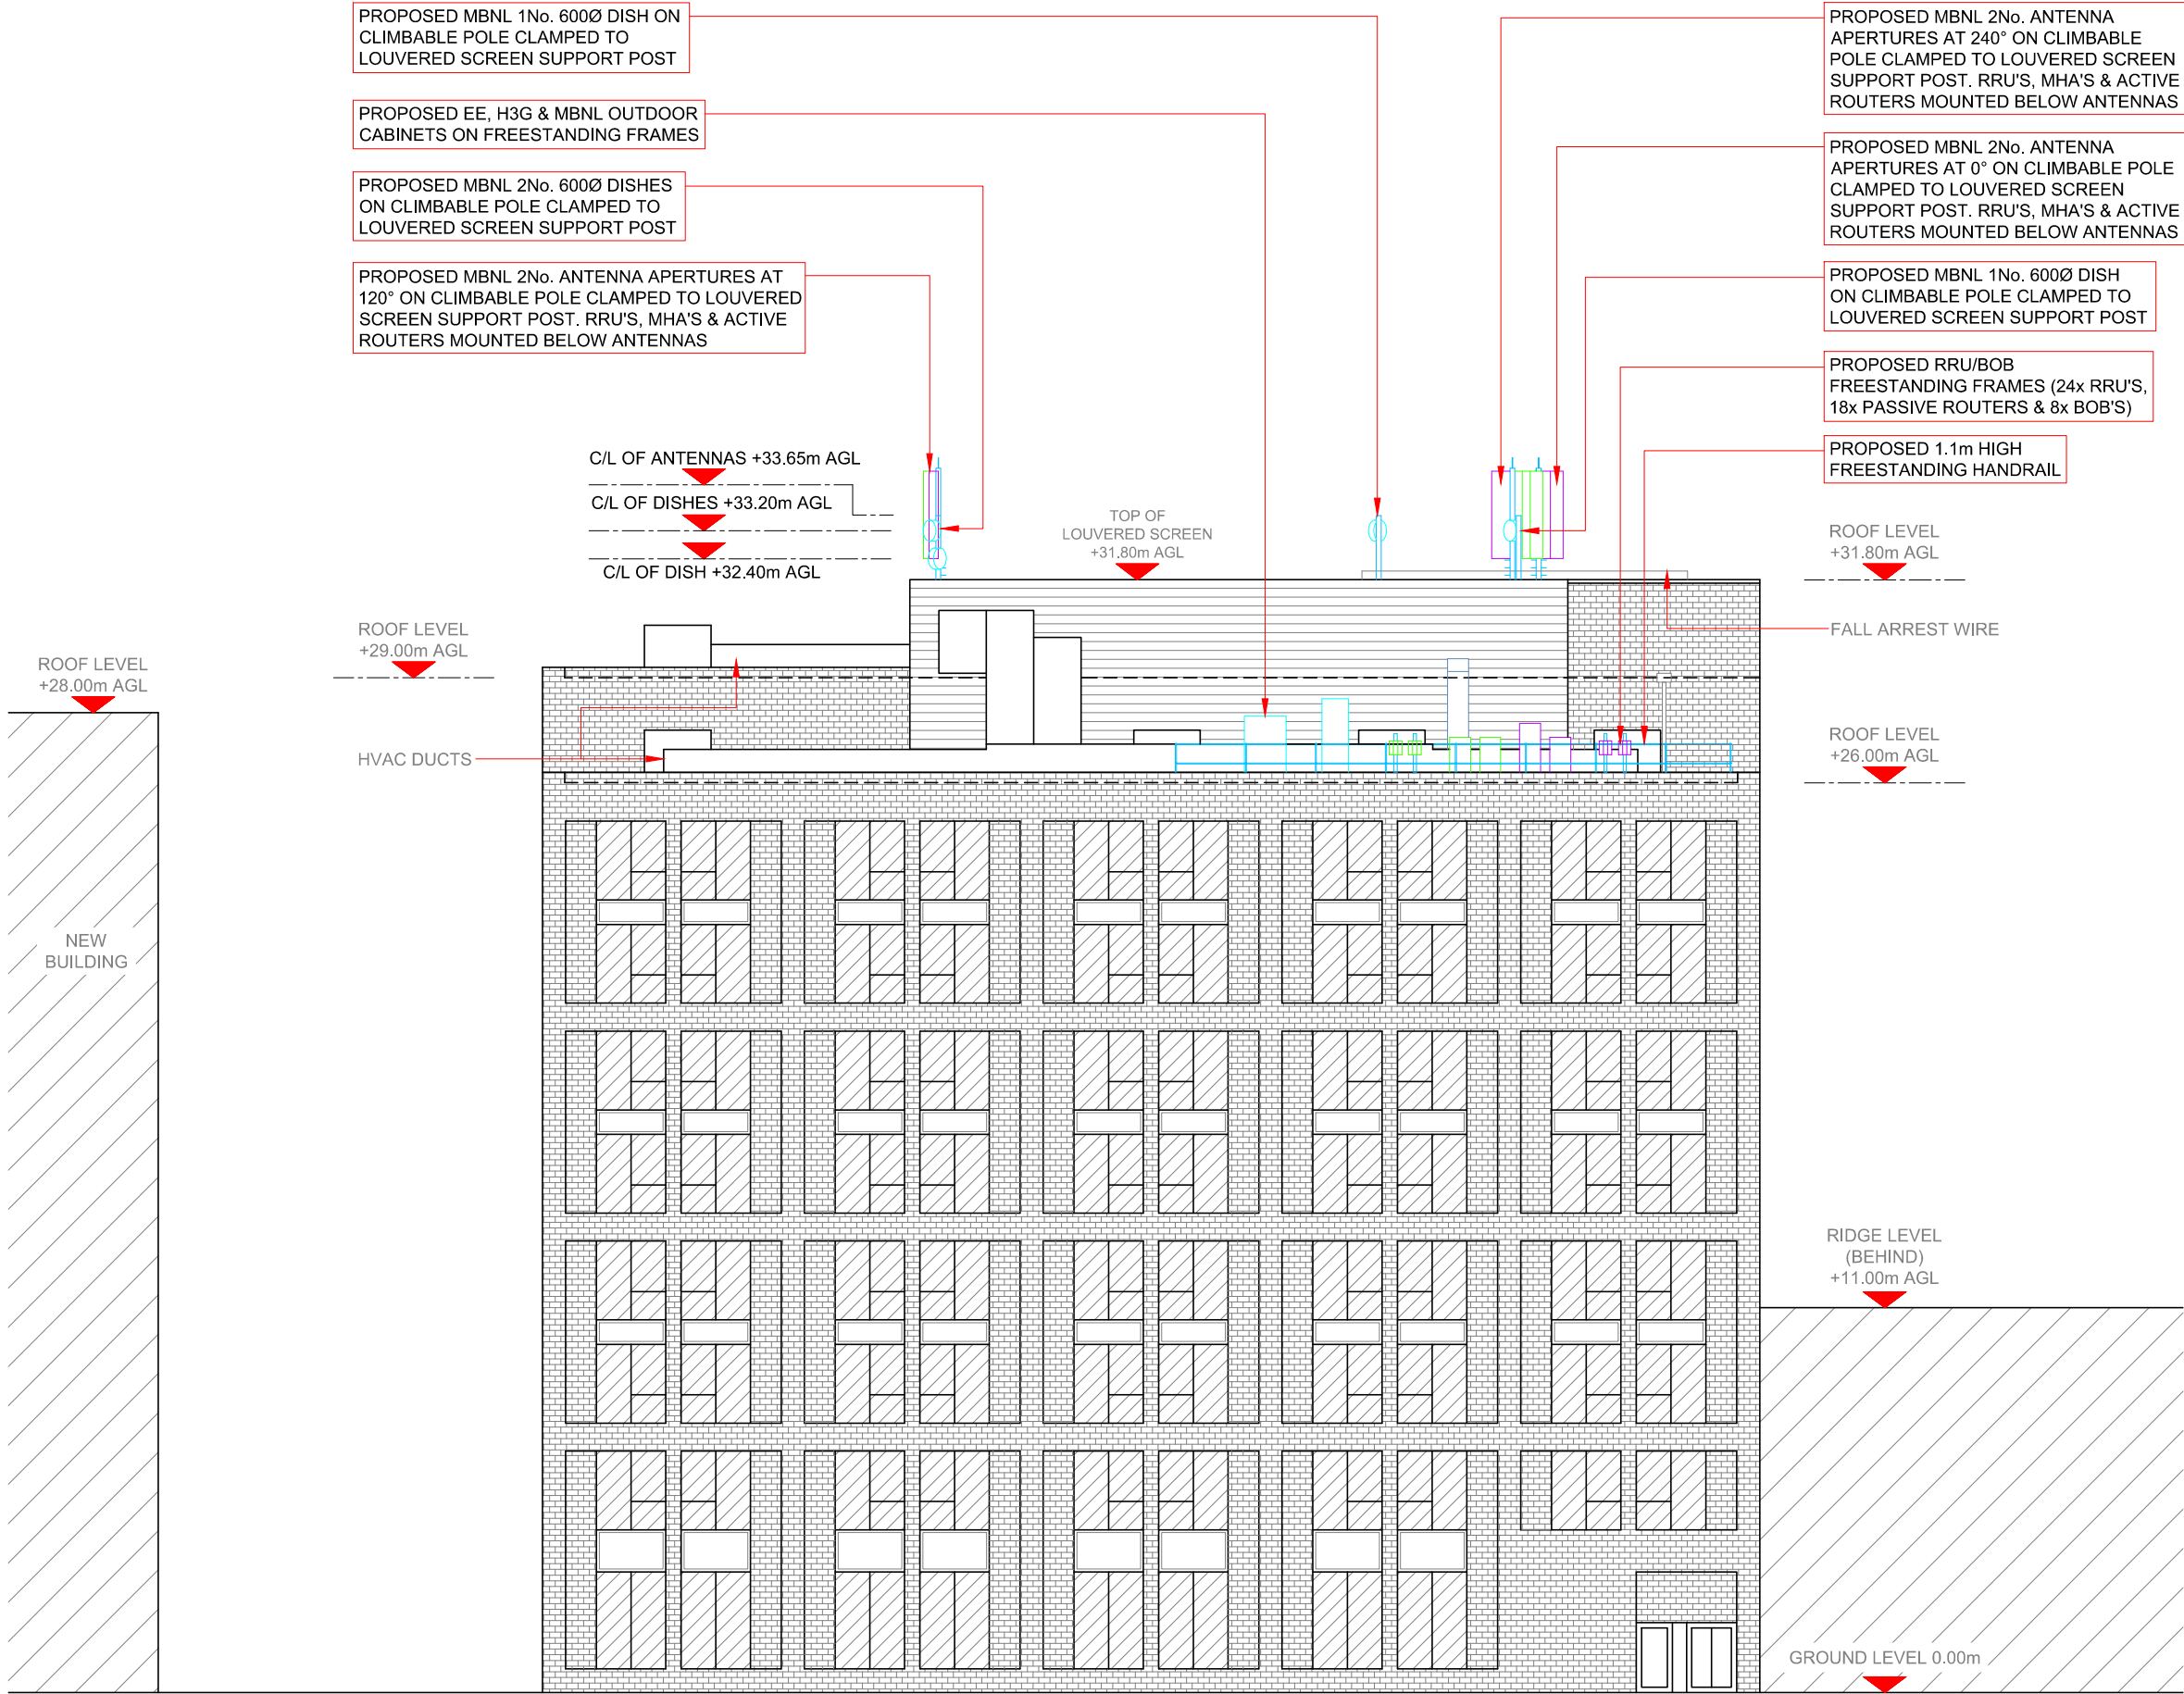

PROPOSED SHARED ELEVATION A
Scale 1:200
0 1:200 5m 8

NOTES:
1. ALL DIMENSIONS IN MM UNLESS OTHERWISE NOTED.

NOTE:
ANTENNAS TO BE COLOURED LIGHT GREY RAL 7035

SHARED CONFIGURATION SITE

RF CONFIG H3b

Master:	MBNL / EE / H3G:	Project:	Purpose of Issue:	Issue:
M004	MBNL	NTQ	Planning	D
Date:	07.12.21	Revision / Upgrade Description:		
Drawn:	L.COLEBOURN	Antenna colour added, to be RAL 7035 at LPA request		
Checked:	A.FANNING			
Approved:	P.CONVERY			
Master:	MBNL / EE / H3G:	Project:	Purpose of Issue:	Issue:
M003	MBNL	NTQ	Planning	C
Date:	01.03.21	Revision / Upgrade Description:		
Drawn:	A.FANNING	Dish location amended		
Checked:	P.CONVERY			
Approved:	P.CONVERY			
Master:	MBNL / EE / H3G:	Project:	Purpose of Issue:	Issue:
M002	MBNL	NTQ	Planning	B
Date:	05.02.21	Revision / Upgrade Description:		
Drawn:	A.FANNING	Site Design Solution Amended to H3b		
Checked:	P.CONVERY			
Approved:	P.CONVERY			
Master:	MBNL / EE / H3G:	Project:	Purpose of Issue:	Issue:
M001	MBNL	NTQ	Planning	A
Date:	12.01.21	Revision / Upgrade Description:		
Drawn:	J. BOOTE	First Issue		
Checked:	J. STOCKDALE			
Approved:	J. STOCKDALE			



Hutchison 3G UK Limited
Star House, 20 Grenfell Road
Mordenhead, S16 1EH
Tel: 01628 765 000
Fax: 01628 765 001

H3G Base Station Information Line:
0845 6043000
Available: 9am-5pm Monday to Friday



Hatfield Business Park
Hatfield
Hertfordshire
AL10 9BW

Tel: 01707 315000
Fax: 01707 319001



Mobile Broadband Network Limited
Sixth Floor, Thames Tower, Station Road, Reading, RG1 1LX

Design Consultant & Principal Contractor:



WHP Telecoms
Unit 1 Maple Park,
Low Fields Avenue, Leeds
LS12 6HH

Tel: 01133023550
e-mail: info@whptelecoms.com

Site Name:
AC HOTEL BY MARRIOTT RT

Site ID:
1570005

Address:
**AC HOTEL BY MARRIOTT,
15 MASON STREET,
MANCHESTER,
GREATER MANCHESTER,
M4 5FT**

Title:
250 PROPOSED SHARED ELEVATION A

Project:
NTQ

Purpose of Issue:
GENERAL ARRANGEMENT

EE Cell ID: 79787	MBNL Cell ID: MAN435	3UK Cell ID: -
-----------------------------	--------------------------------	--------------------------

Master Drawing No: 1570005_MAN435_79787_M004	Issue: D
--	--------------------

Max Configuration Antenna Aperture Schedule & RF Equipment Capacity																	
Antenna Aperture ID	Antenna Aperture Size (Length x Width x Depth)	Aperture Height C/L	Aperture Max Weight (kg)	Proposed Bearing	Tech:	Operator: Shared/ EE/H3G	Antenna Aperture Coordinates		RRU No. Max Size & Weight L=500mm W=400mm D=150mm Weight=25kg	MHA No. Max Size & Weight L=300mm W=300mm D=150mm Weight=10kg	Main Feeder			BOB Max Size & Weight (300x300x250mm & 5kg)		Active Router No. Max Size & Weight (370x260x150mm & 10kg)	Passive Router No. Max Size & Weight (350x220x150mm & 10kg)
							Eastings	Northings			Size	Length	No.	No. Top	No. Bottom		
A1	2500x550x350mm	33.65m	100kg	0°	2G/3G/4G/5G	EE	-	-	1	3	LDF5-50	20.0m	6	-	2	2	3
A2	2500x550x350mm	33.65m	100kg	0°	2G/3G/4G/5G	H3G	-	-	1	3	LDF5-50	20.0m	6	-	1	2	3
B1	2500x550x350mm	33.65m	100kg	120°	2G/3G/4G/5G	EE	-	-	1	3	LDF7-50	38.0m	6	-	2	2	3
B2	2500x550x350mm	33.65m	100kg	120°	2G/3G/4G/5G	H3G	-	-	1	3	LDF7-50	38.0m	6	-	1	2	3
C1	2500x550x350mm	33.65m	100kg	240°	2G/3G/4G/5G	EE	-	-	1	3	LDF7-50	36.0m	6	-	2	2	3
C2	2500x550x350mm	33.65m	100kg	240°	2G/3G/4G/5G	H3G	-	-	1	3	LDF7-50	36.0m	6	-	-	2	3

NOTE:
THERE MAY BE UP TO 2 ANTENNAS PER APERTURE
SUBJECT TO SITE SPECIFIC RADIO DESIGN

NOTE:
ANTENNAS TO BE COLOURED LIGHT GREY RAL 7035

Passive Infrastructure Equipment Capacity		
A	B	C
H3b	H3b	H3b

STATUS KEY:

Installed:

Existing

Retain:

Existing and to remain

Relocate:

Existing and to be relocated

Remove:

Existing to be removed from site

Proposed:

New on site

Master:	MBNL / EE / H3G:	Project:	Purpose of Issue:	Issue:
M004	MBNL	NTQ	Planning	D
Date:	07.12.21	Revision / Upgrade Description:		
Drawn:	L.COLEBOURN	Antenna colour added, to be RAL 7035 at LPA request		
Checked:	A.FANNING			
Approved:	P.CONVERY			
Master:	MBNL / EE / H3G:	Project:	Purpose of Issue:	Issue:
M003	MBNL	NTQ	Planning	C
Date:	01.03.21	Revision / Upgrade Description:		
Drawn:	A.FANNING	Dish location amended		
Checked:	P.CONVERY			
Approved:	P.CONVERY			
Master:	MBNL / EE / H3G:	Project:	Purpose of Issue:	Issue:
M002	MBNL	NTQ	Planning	B
Date:	05.02.21	Revision / Upgrade Description:		
Drawn:	A.FANNING	Site Design Solution Amended to H3b		
Checked:	P.CONVERY			
Approved:	P.CONVERY			
Master:	MBNL / EE / H3G:	Project:	Purpose of Issue:	Issue:
M001	MBNL	NTQ	Planning	A
Date:	12.01.21	Revision / Upgrade Description:		
Drawn:	J. BOOTE	First Issue		
Checked:	J. STOCKDALE			
Approved:	J. STOCKDALE			



Hutchison 3G UK Limited
Star House, 20 Grenfell Road
Maidenhead, SL6 1EH
Tel: 01628 765 000
Fax: 01628 765 001

H3G Base Station Information line:
0845 6043000
Available 9am-6pm Monday to Friday



Hatfield Business Park
Hatfield
Hertfordshire
AL10 9BW

Tel: 01707 315000
Fax: 01707 319001

MBNL Mobile Broadband Network Limited
Sixth Floor, Thames Tower, Station Road, Reading, RG1 1LX

Design Consultant & Principal Contractor:



WHP Telecoms
Unit 1 Maple Park,
Low Fields Avenue, Leeds
LS12 6HH

Tel: 01133023550
e-mail: info@whptelecoms.com

Site Name:

AC HOTEL BY MARRIOTT RT

Site ID:

1570005

Address:

AC HOTEL BY MARRIOTT,
15 MASON STREET,
MANCHESTER,
GREATER MANCHESTER,
M4 5FT

Title:

301 PROPOSED SHARED ANTENNA
SCHEDULE & LINE CONFIGURATION

Project:

NTQ

Purpose of Issue:

GENERAL ARRANGEMENT

EE Cell ID:

79787

MBNL Cell ID:

MAN435

3UK Cell ID:

-

Master Drawing No:

1570005_MAN435_79787_M004

Issue:

D

Support Structure Schedule										
Structure ID	Status	Equipment Description / Type	Structure Manufacturer	Height AGL (m)	Colour (RAL Colour)	Headframe Details	Foundation / Support Grillage / Host Structure Details	Support Bolt Details	MBNL Ref:	Comments
ST1	Proposed	Climbable Poles	Bespoke	-	GALVANISED	-	Screen Support Posts	-	-	5No. Required
ST2	Proposed	Cabinet Freestanding Frame	TBC	-	GALVANISED	-	Freestanding	-	-	4No. Required. Frame size / details / manufacturer TBC.
ST3	Proposed	RRU/BOB Freestanding Frame	TBC	-	GALVANISED	-	Freestanding	-	-	2No. Required. Frame size / details / manufacturer TBC.

--

Equipment Schedule													
Equipment ID	Quantity	Status	Equipment Description / Type	Equipment Manufacturer	Dimensions (W x D x H)	Weight (kg)	Colour (RAL Colour)	Material	Location	Power	Power cable length (m)	MBNL Ref:	Comments
CAB1	1	PROPOSED	MK5B LINK AC	-	1200x600x1600	-	GREY	STEEL	OUTDOOR	-	-	-	ON FREESTANDING FRAME
CAB2	1	PROPOSED	EE/H3G - FURO	ICD	750x600x2100	-	GREY	STEEL	OUTDOOR	-	-	-	ON FREESTANDING FRAME
CAB3	1	PROPOSED	EE - APM5930	HUAWEI	600x480x1000	-	GREY	STEEL	OUTDOOR	-	-	-	ON 200 PLINTH ON FREESTANDING FRAME
CAB4	1	PROPOSED	EE - BTS3900A	HUAWEI	600x480x1400	-	GREY	STEEL	OUTDOOR	-	-	-	ON 200 PLINTH ON FREESTANDING FRAME
CAB5	1	PROPOSED	H3G - APM5930	HUAWEI	600x480x1000	-	GREY	STEEL	OUTDOOR	-	-	-	ON 200 PLINTH ON FREESTANDING FRAME
CAB6	1	PROPOSED	H3G - APM5930	HUAWEI	600x480x1000	-	GREY	STEEL	OUTDOOR	-	-	-	ON 200 PLINTH ON FREESTANDING FRAME

--

POWER SCHEDULE					
Supply Status	Type	Supplier	Supply Type	Location	Comments
PROPOSED	LANDLORD	TBC	TBC	MK5B LINK/AC CABINET	ELECTRICAL SURVEY REQUIRED TO CONFIRM TAKE-OFF POINT & SUB-MAIN CABLE ROUTE TO ROOF.

--

STATUS KEY:

Installed:

Existing

Retain:

Existing and to remain

Relocate:

Existing and to be relocated

Remove:

Existing to be removed from site

Proposed:

New on site

LOCATION KEY:

Outdoor:

Located outside

Indoor:

Located within an equipment cabin or equipment room

Internal:

located inside a cabinet or item of equipment

Master: M004

Date:

Drawn: L.COLEBOURN

Checked: A.FANNING

Approved: P.CONVERY

MBNL / EE / H3G:

MBNL

Project: NTQ

Purpose of Issue: Planning

Issue: D

Revision / Upgrade Description:
Antenna colour added, to be RAL 7035 at LPA request

Master: M003

Date:

Drawn: A.FANNING

Checked: P.CONVERY

Approved: P.CONVERY

MBNL / EE / H3G:

MBNL

Project: NTQ

Purpose of Issue: Planning

Issue: C

Revision / Upgrade Description:
Dish location amended

Master: M002

Date:

Drawn: A.FANNING

Checked: P.CONVERY

Approved: P.CONVERY

MBNL / EE / H3G:

MBNL

Project: NTQ

Purpose of Issue: Planning

Issue: B

Revision / Upgrade Description:
Site Design Solution Amended to H3b

Master: M001

Date:

Drawn: J. BOOTE

Checked: J. STOCKDALE

Approved: J. STOCKDALE

MBNL / EE / H3G:

MBNL

Project: NTQ

Purpose of Issue: Planning

Issue: A

Revision / Upgrade Description:
First Issue



Hutchison 3G UK Limited
Star House, 20 Grenfell Road
Mordenhead, SL6 1EH
Tel: 01628 765 000
Fax: 01628 765 001

H3G Base Station Information line:
0845 6043000
Available 9am-6pm Monday to Friday



Hatfield Business Park
Hatfield
Hertfordshire
AL10 9BW

Tel: 01707 315000
Fax: 01707 319001



Mobile Broadband Network Limited
Sixth Floor, Thames Tower, Station Road, Reading, RG1 1LX



WHP

WHP Telecoms

Unit 1 Maple Park,
Low Fields Avenue, Leeds
LS12 6HH

Tel: 01133023550
e-mail: info@whptelecoms.com

Site Name:

AC HOTEL BY MARRIOTT RT

Site ID:

1570005

Address:

AC HOTEL BY MARRIOTT,
15 MASON STREET,
MANCHESTER,
GREATER MANCHESTER,
M4 5FT

Title:

305 EQUIPMENT SCHEDULE &
SUPPORT STRUCTURE DETAILS

Project:

NTQ

Purpose of Issue:

GENERAL ARRANGEMENT

EE Cell ID:

79787

MBNL Cell ID:

MAN435

3UK Cell ID:

-

Master Drawing No:

1570005_MAN435_79787_M004

Issue:

D