

REVISIONS

Rev	Date	Description
Rev A:	14.01.16	Revised with updated site plan
Rev B:	14.03.16	Revised with updated site plan
Rev C:	14.07.17	Revised with updated site plan and courtyard lighting
Rev D:	26/05/17	Revised with updated site plan
Rev E:	Sept 17	Plan up-dated to latest site plan design. DMM
Rev F:	Nov 17	Plan up-dated to latest site plan design. DMM
Rev G:	Dec18	Text corrected. SS
Rev H:	13/09/19	Plan up-dated. DMM
Rev J:	22/10/19	Plan up-dated following survey. DMM
Rev K:	30/10/19	Extra bollards and ducting added as per Planners requirements. DMM
Rev L:	23/07/21	Strand C lighting added DMM
Rev M:	03/09/21	Strand light re-located. DM
Rev N:	12/11/21	Strand light changed to Size 4 Stirrup Mounted Gladstone Lantern. DMM



- Service Run
- Private Connection
- Upstand Lights
- Pier Mounted Lights
- Private Pier Lights
- Bollards Lights
- Lighting Columns
- Bulkhead Lighting

WARNING
Critical Dimensions required by Consultants/
Contractors/ Subcontractors must not be scaled
from this drawing. Dimensions required are to be
obtained from the drawing office

Didsbury Campus Site Plan showing Street Lighting and

105- 00- 4005-N

Scale 1:500 @A1 Date Oct15
Drawn BE Checked

MMU-Didsbury Campus,
Wilmslow Road,
Didsbury,
Manchester, M20 2RR

P.J.Livesey Living Space Ltd
Ashburton Park
Ashburton Road West
Trafford Park
Manchester M17 1AF
Tel : 0161 873 7878
Fax : 0161 848 8671
design@pjilivesey.co.uk


COPYRIGHT
This Drawing may not be used or reproduced in
any way without the written consent of the
P.J.Livesey Group Limited

The P. J. Livesey Group Ltd

www.pjlivesey-group.co.uk



Size 4 Stirrup Mounted
Gladstone
Lantern

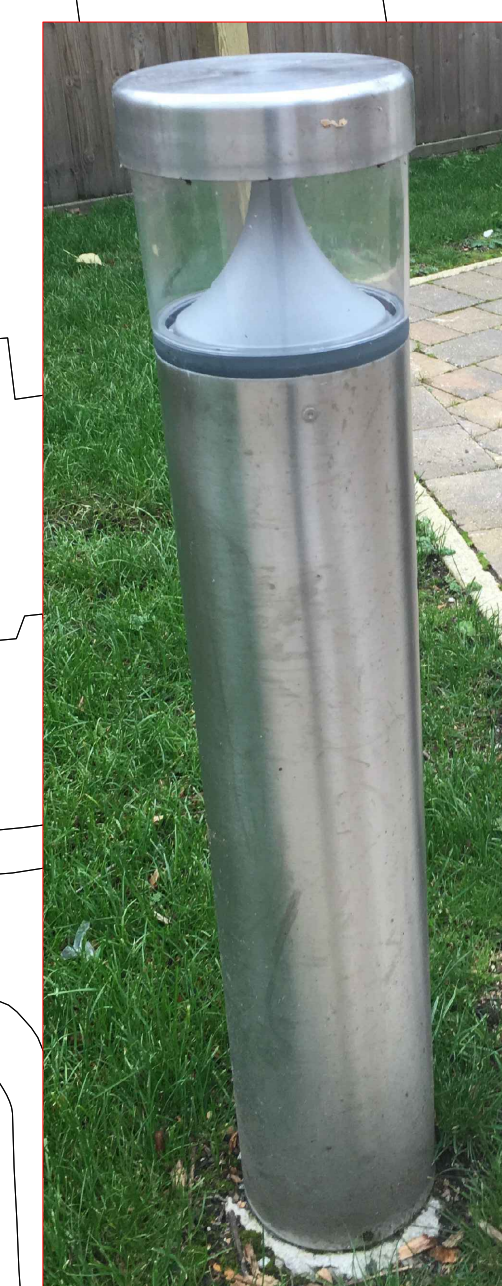

New bollard lighting
(Kingfisher Deco 2.0)



Existing Lights to be
refurbished



Scale 1:500
0m 25m 50m

105-00-4005-Lighting.dwg

Last Saved By: diane.magee