



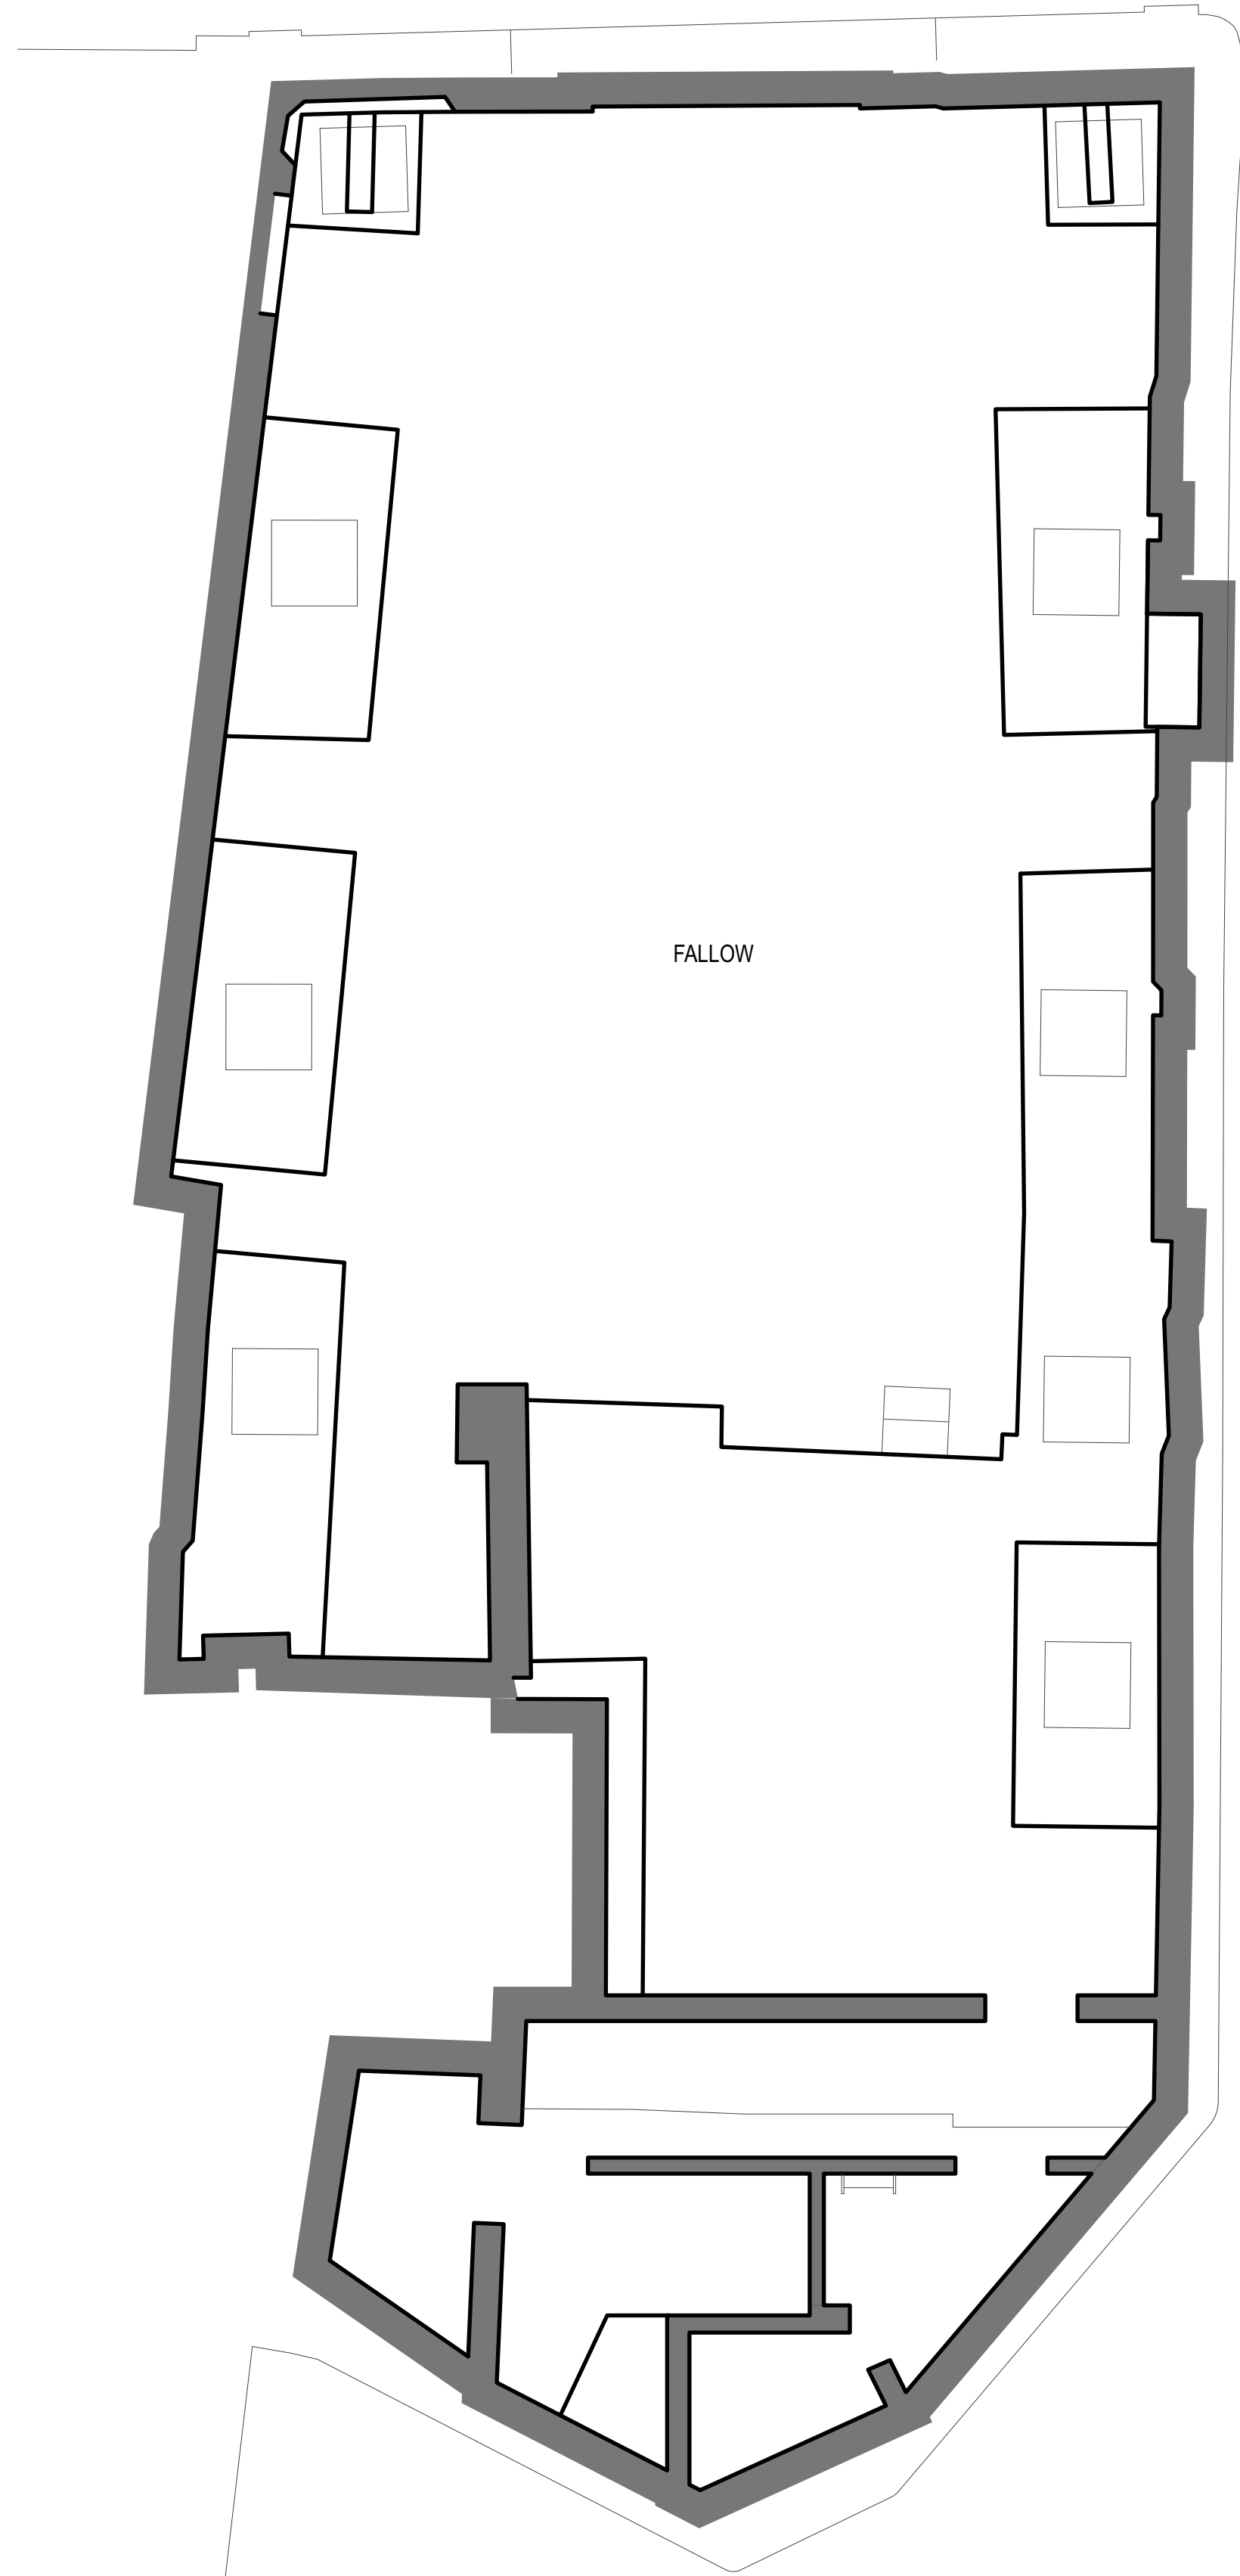

BASEMENT PLAN
1:50 @ A1

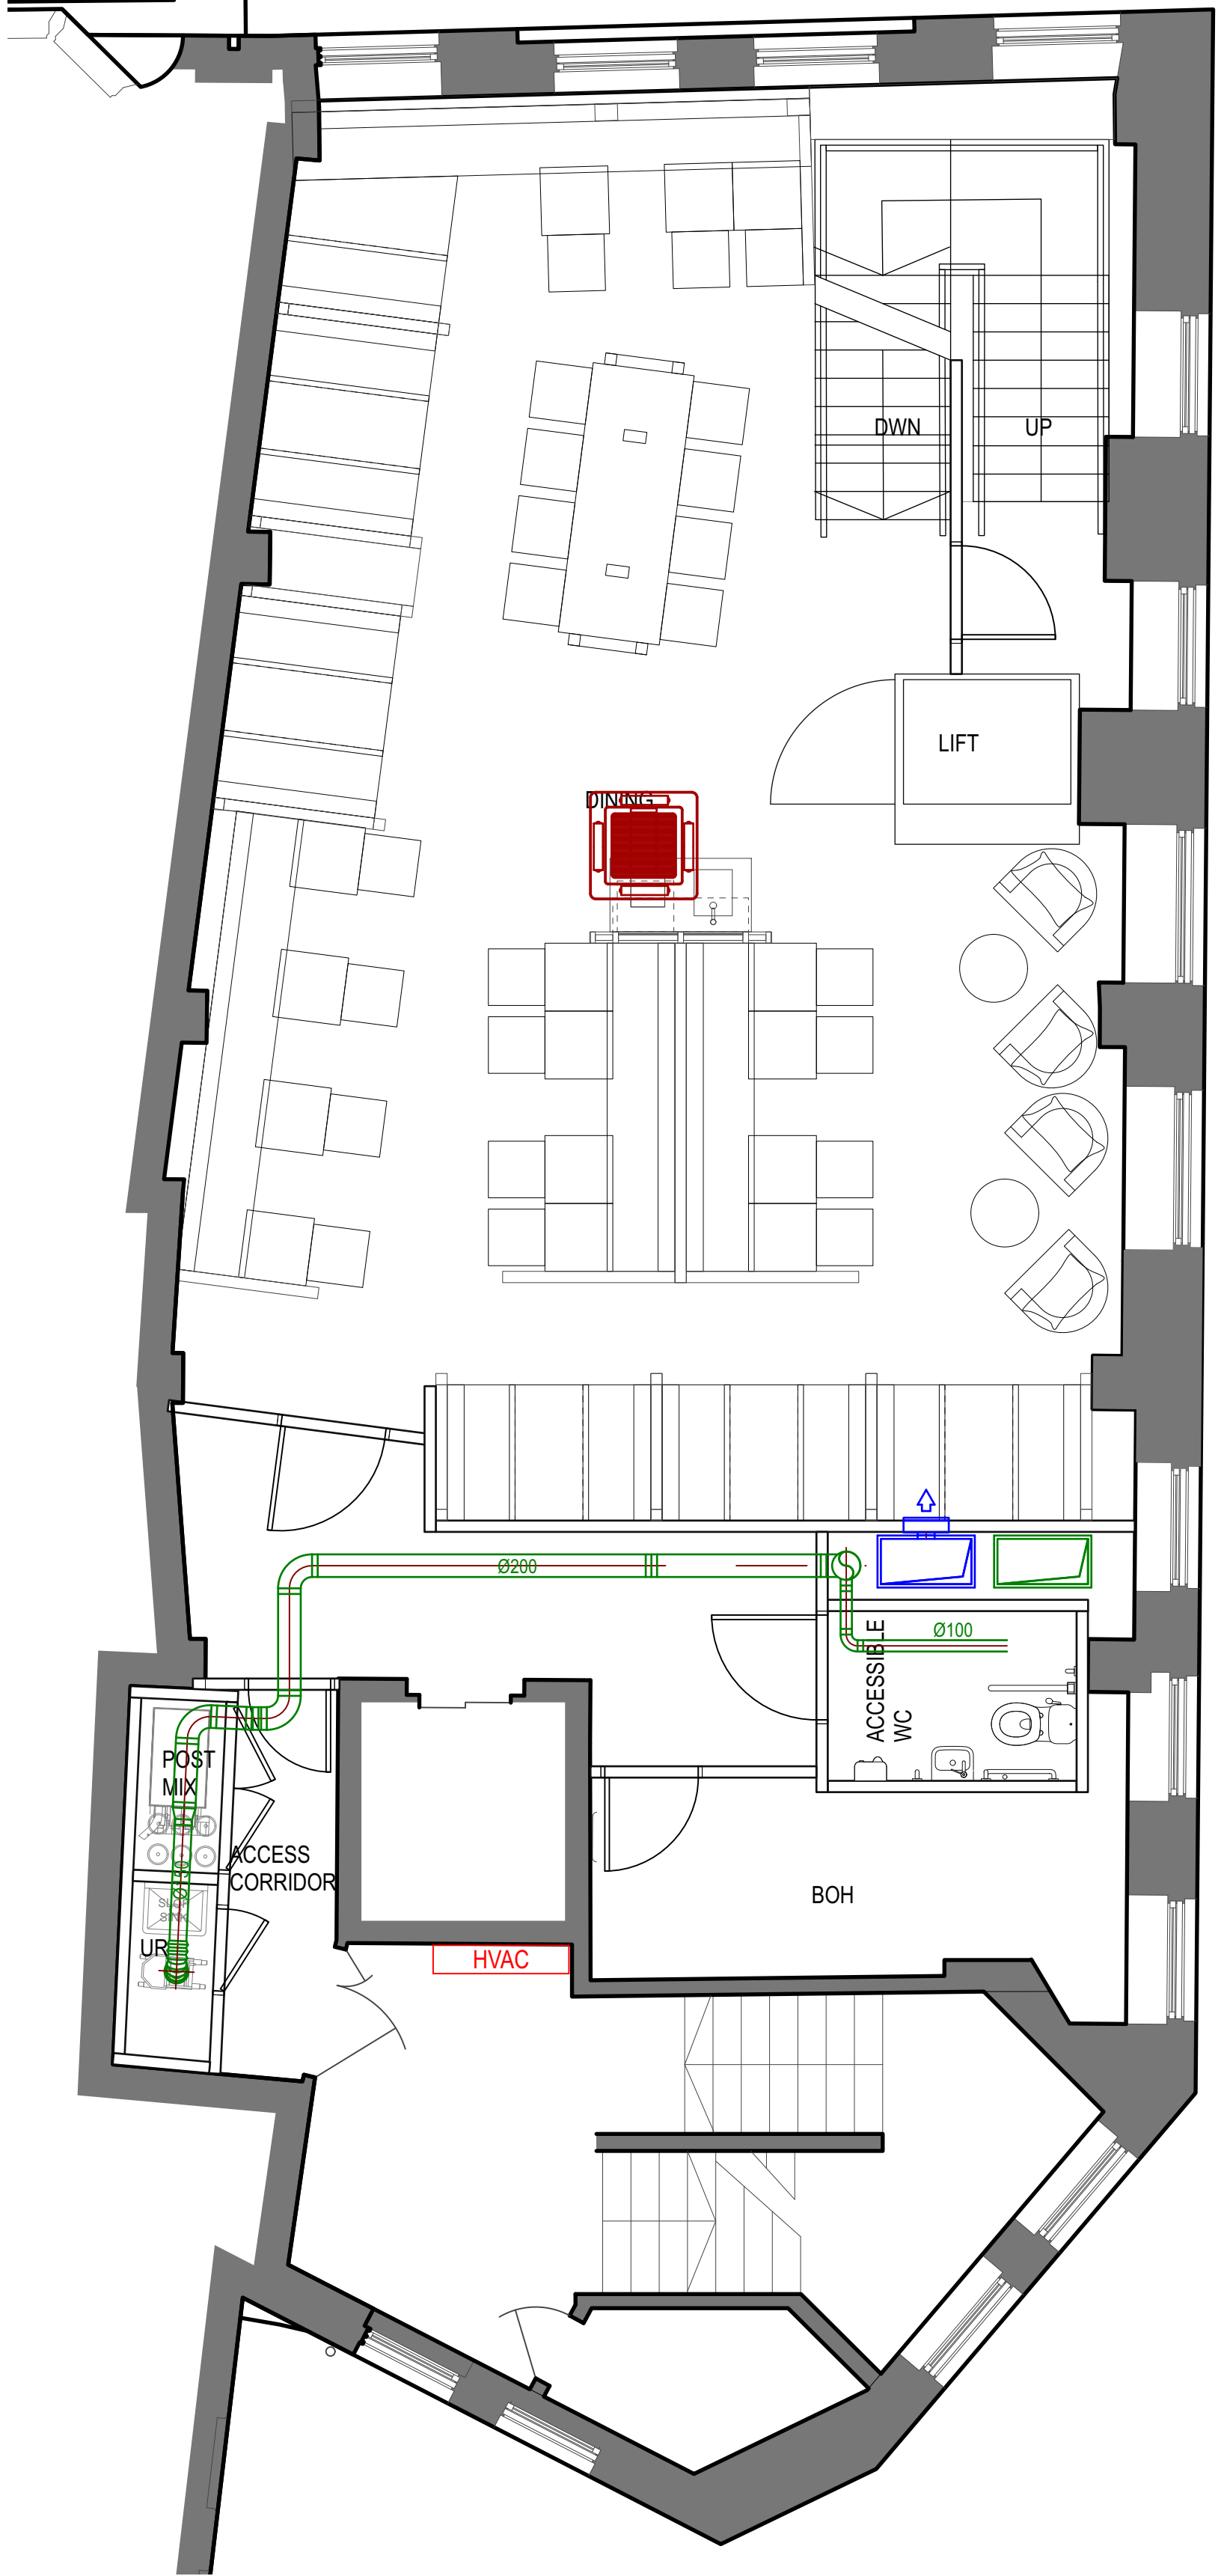

GROUND FLOOR PLAN
1:50 @ A1



FIRST FLOOR PLAN
1:50 @ A1

0 1 5 M

KEY

- HVAC - SUPPLY AIR DUCTWORK
- HVAC - AIR EXTRACTION DUCTWORK
- HVAC - AIR CONDITIONING DUCTWORK

NOTE:


ALL DUCTWORK FORMED FROM
LIGHTWEIGHT ALUMINIUM SHEETS




Project	Jollibee	Scale	1:50	Date	27/10/2021
Client	Manchester	Drawing Number	20028-P101		
Drawing	Planning Proposed Plans: B - L01	Drawn By	JG	Checked By	PA
e. hello@applied.studio w. applied.studio t. +44 (0) 20 8150 6616					

P2 25/11/2021 HVAC
P1 01/11/2021 PLANNING


Do not scale from
drawing, all dimensions
to be checked on site.
Report omissions and
discrepancies to the
architect immediately

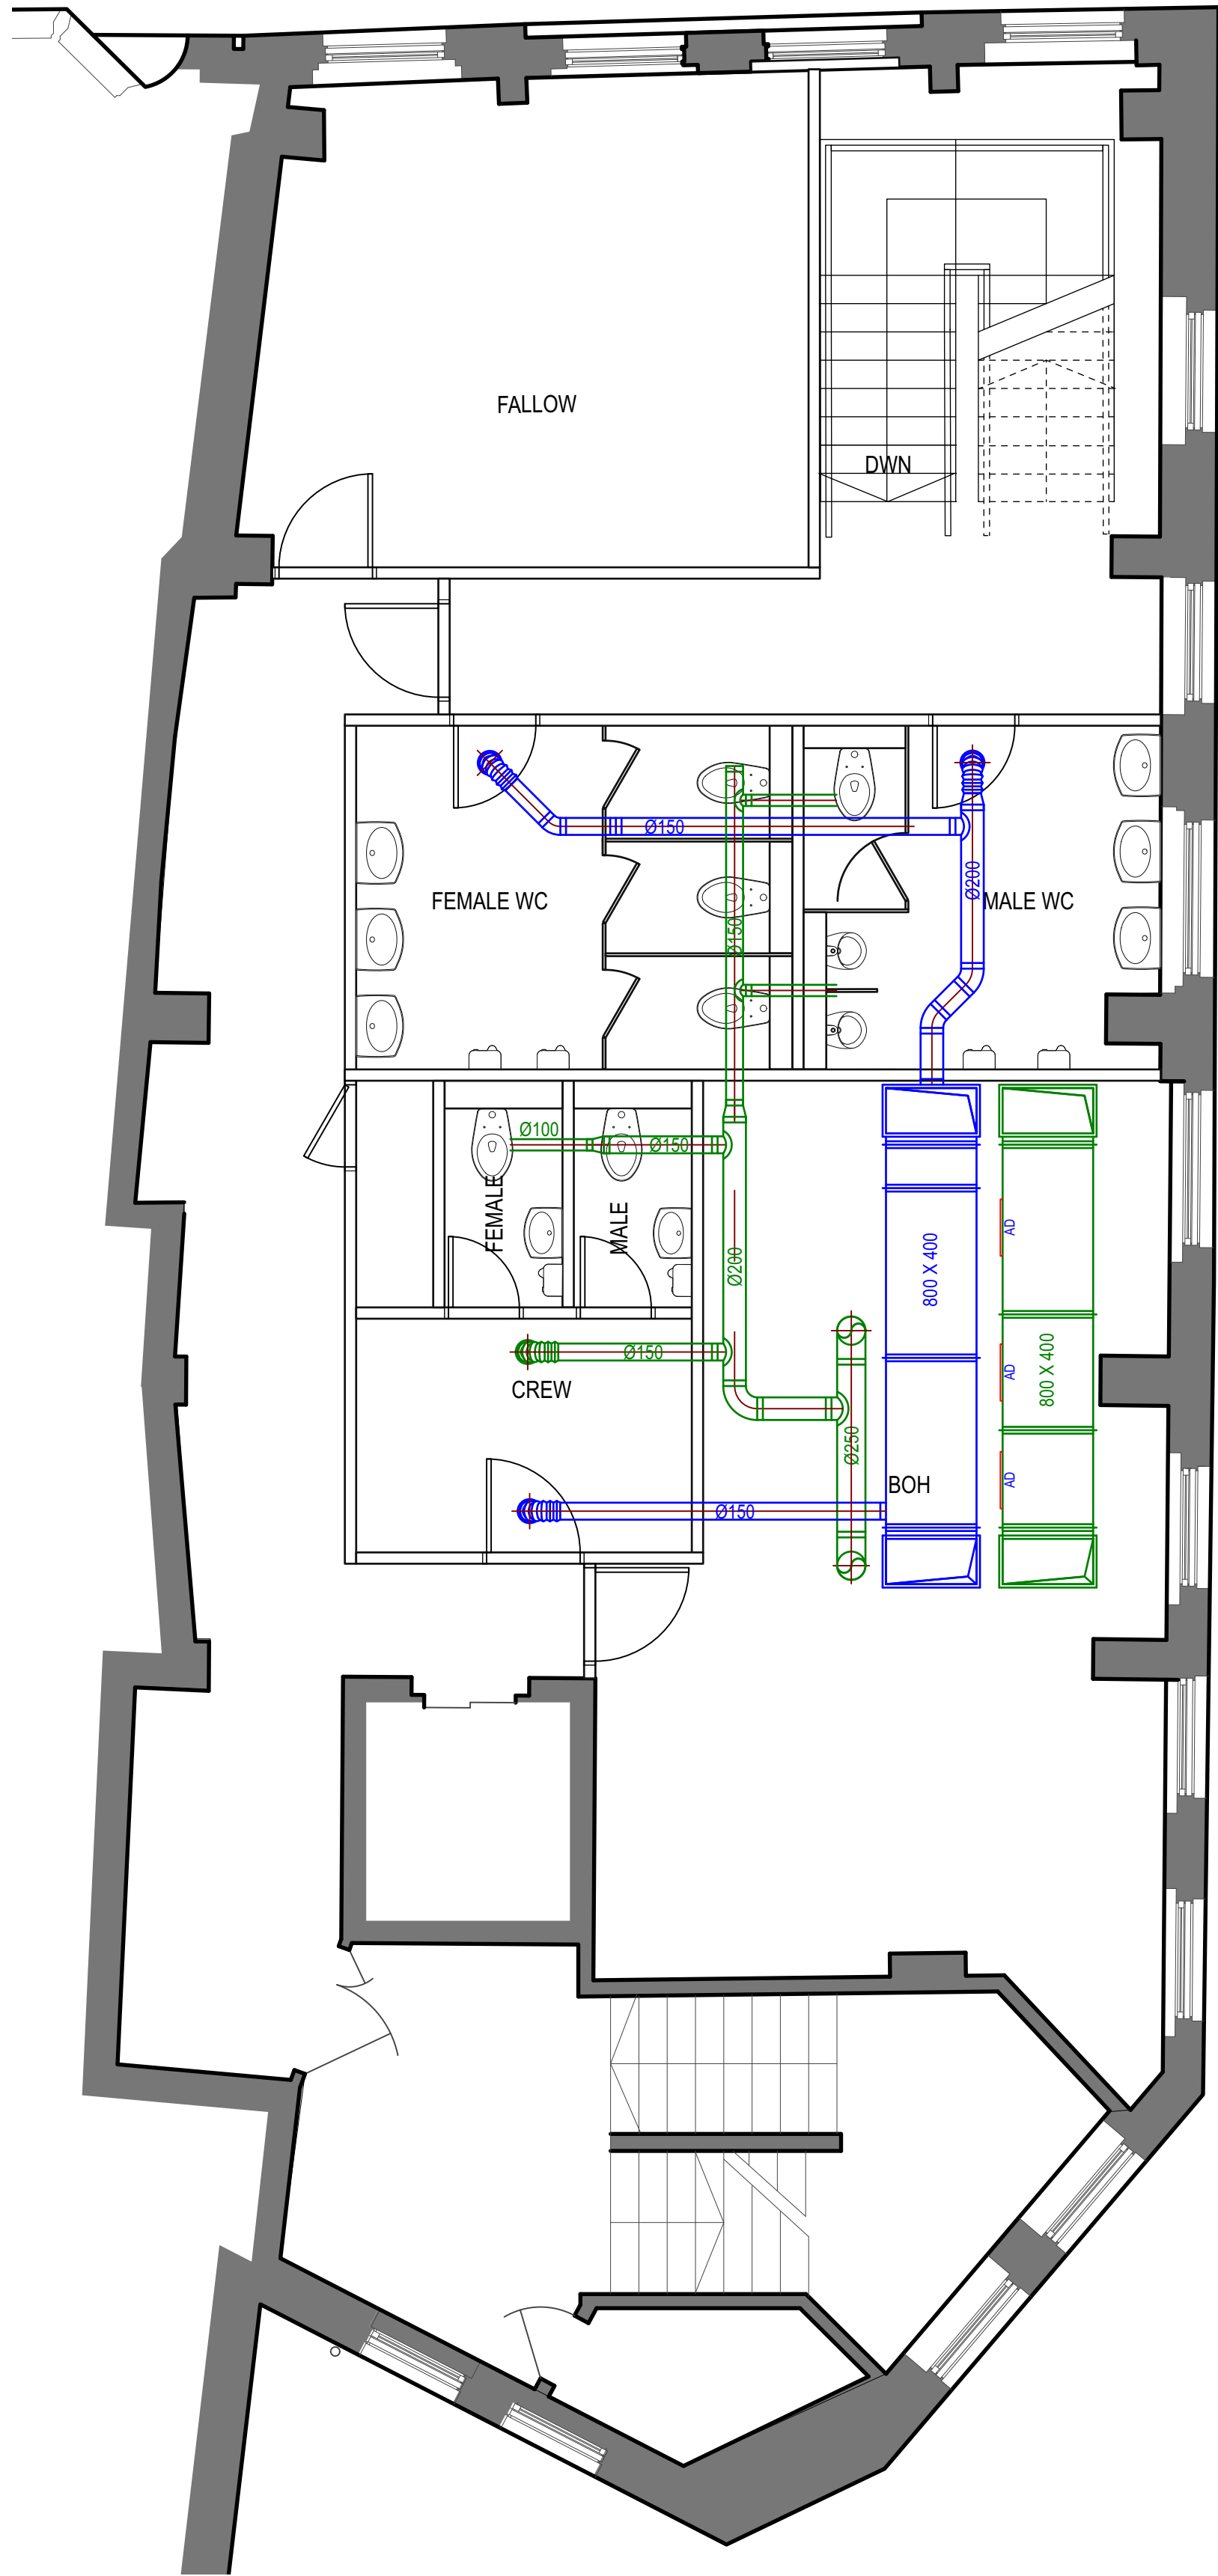

SECOND FLOOR PLAN
1:50 @ A1

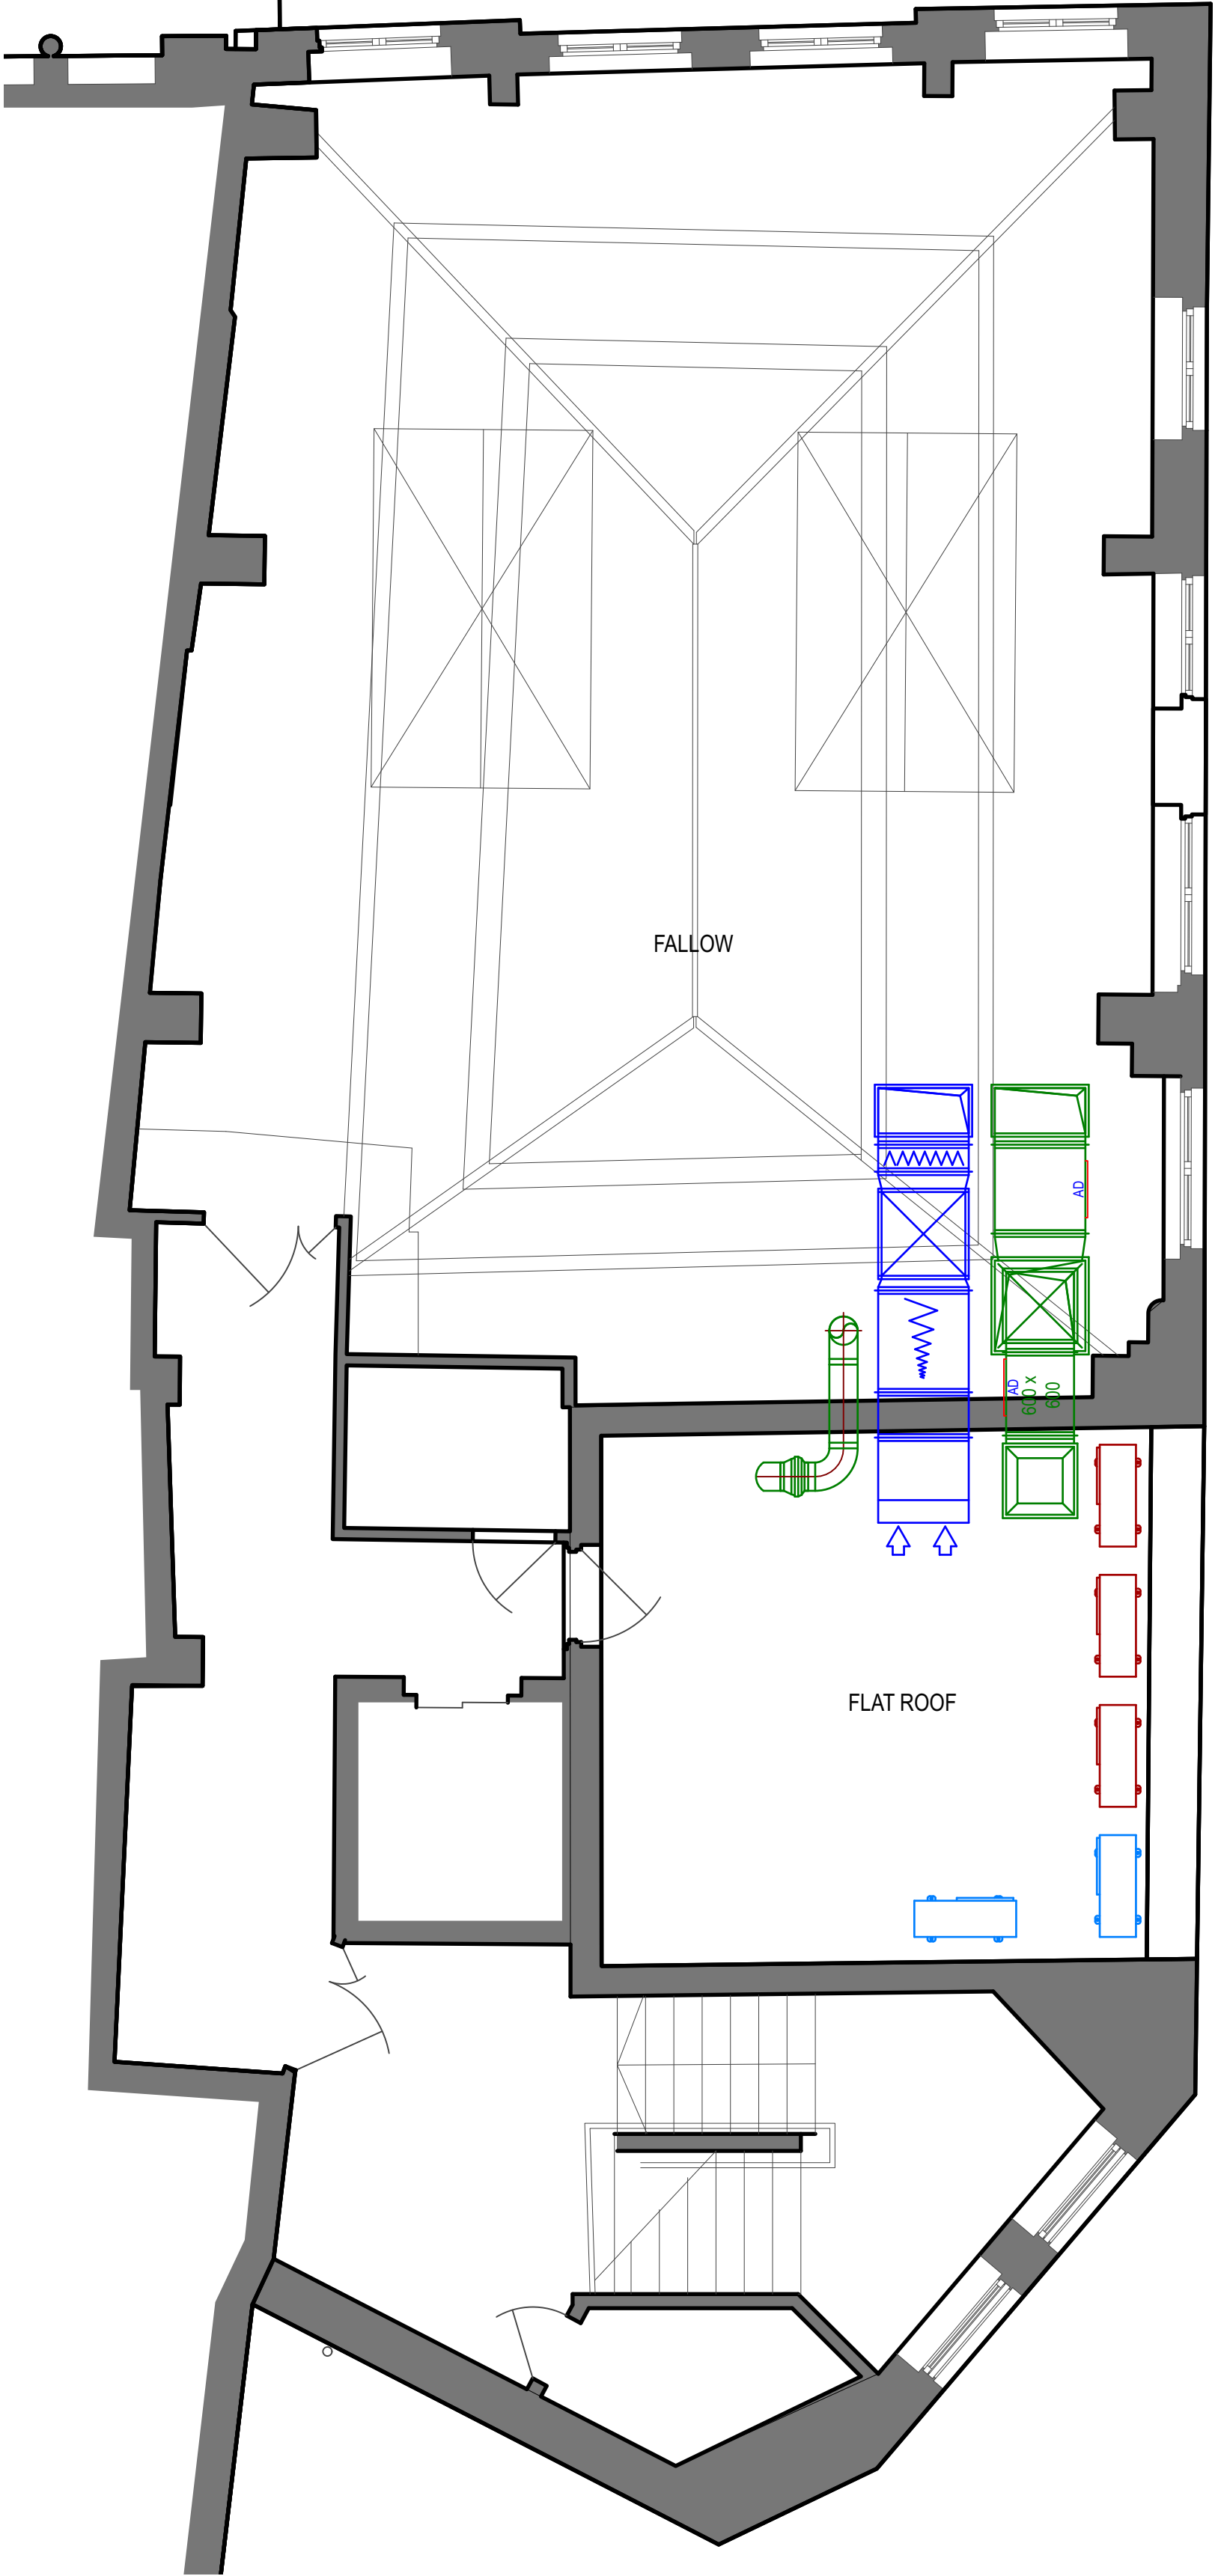

THIRD FLOOR PLAN
1:50 @ A1

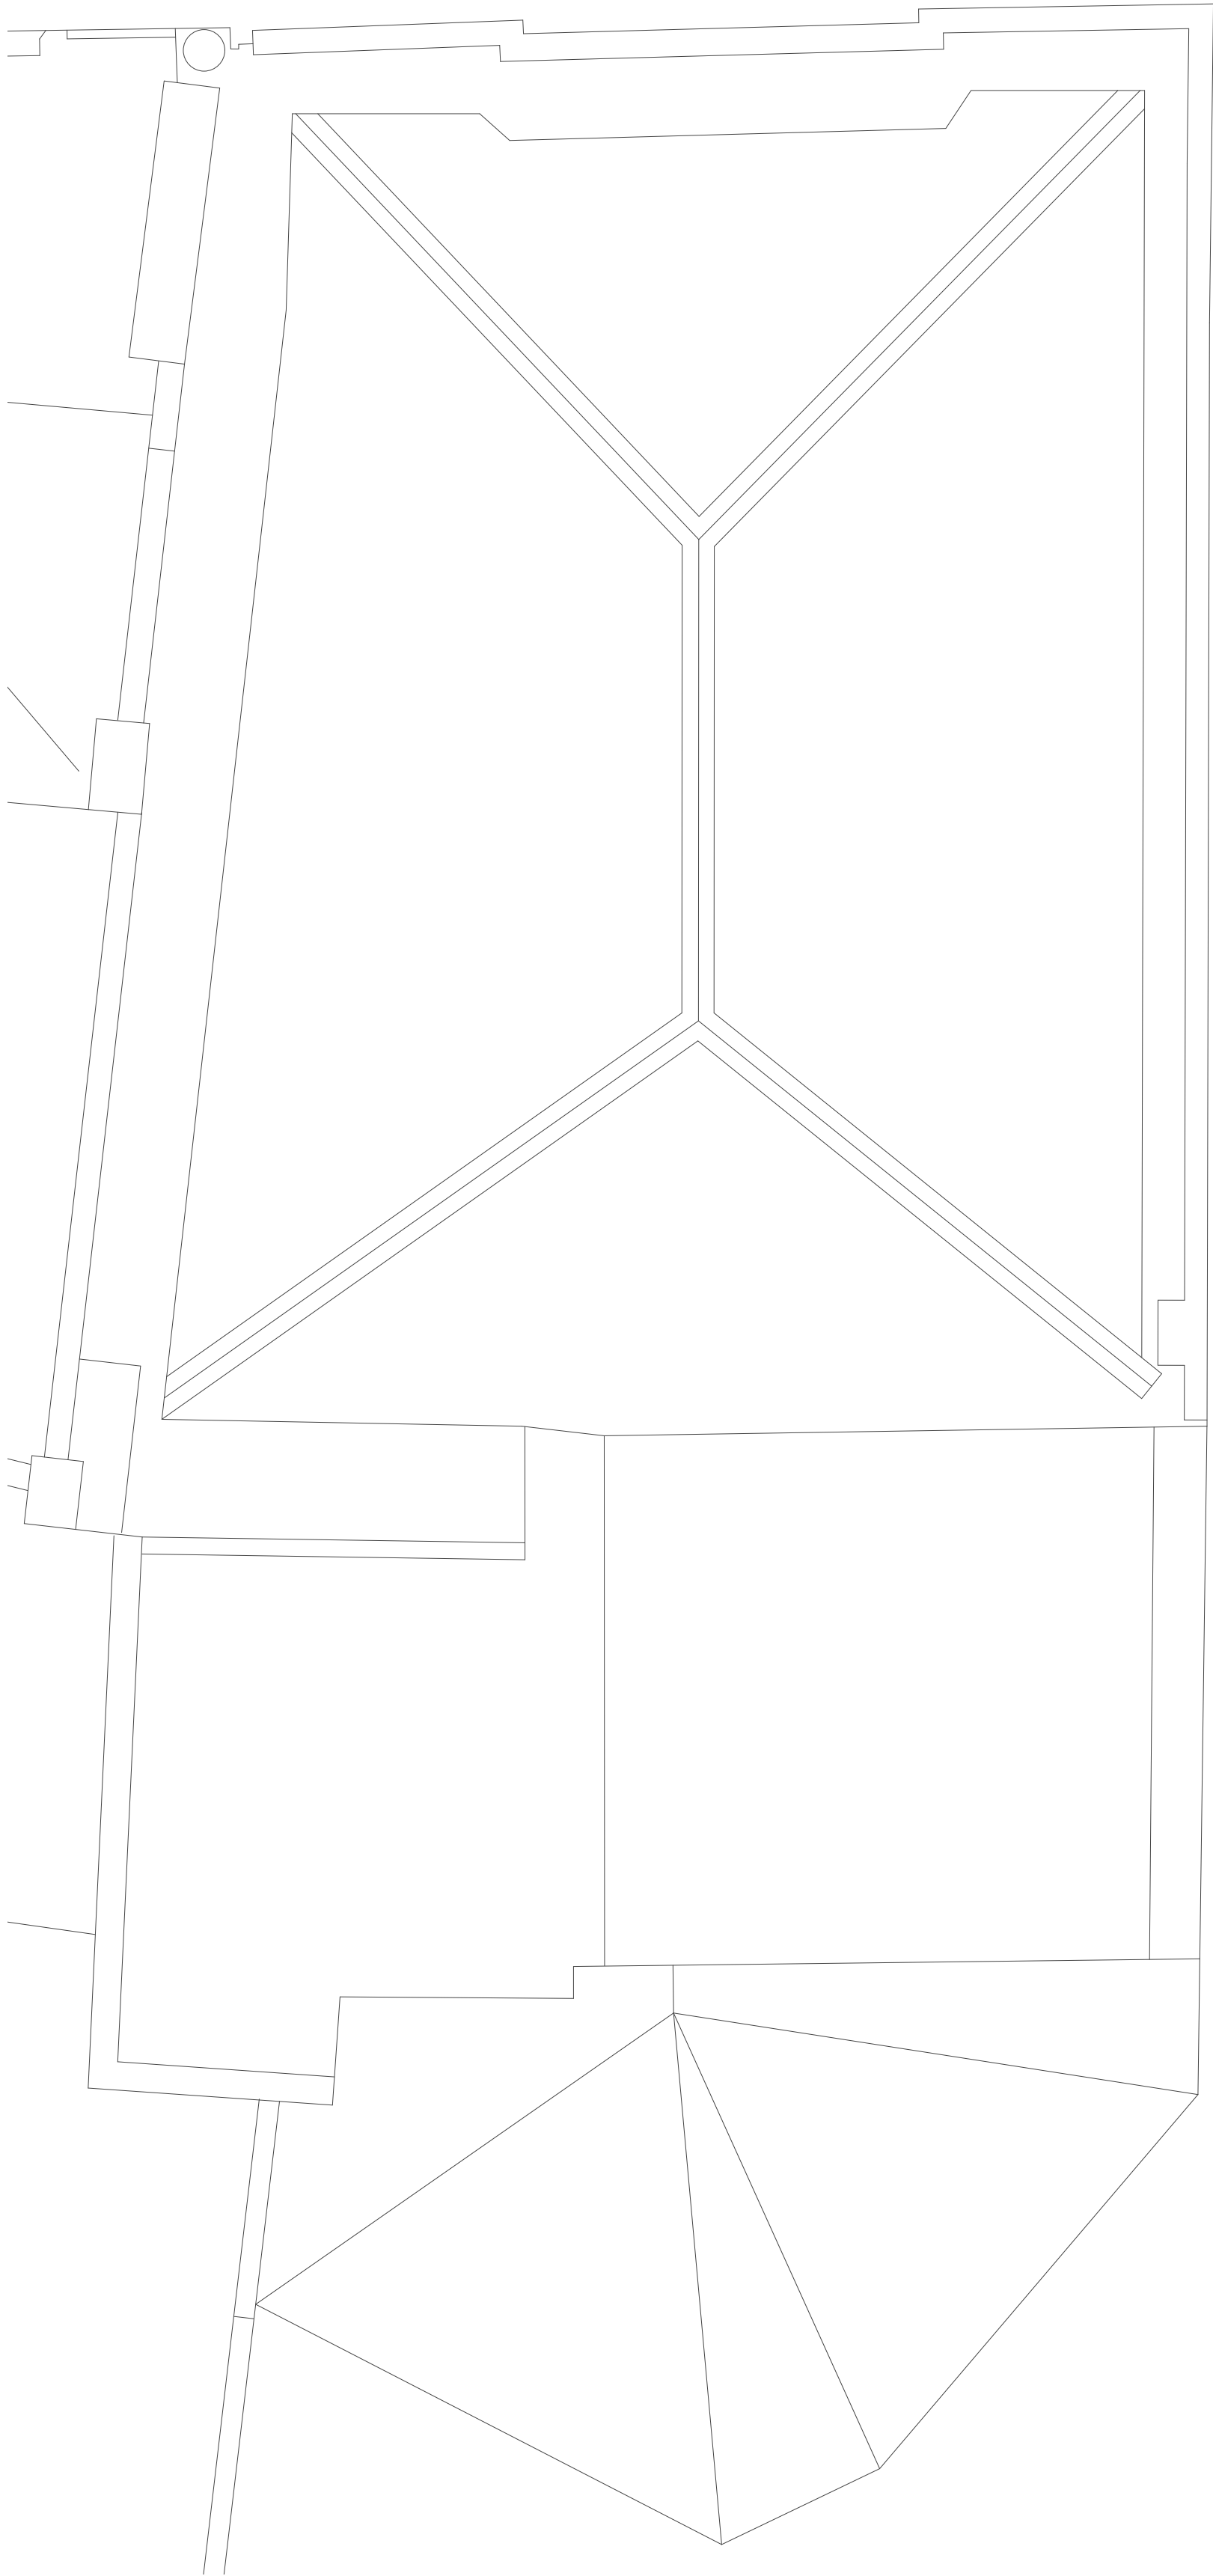

ROOF PLAN
1:50 @ A1

KEY

- HVAC - SUPPLY AIR DUCTWORK
- HVAC - AIR EXTRACTION DUCTWORK
- HVAC - AIR CONDITIONING DUCTWORK

NOTE:

ALL DUCTWORK FORMED FROM
LIGHTWEIGHT ALUMINIUM SHEETS



Do not scale from
drawing, all dimensions
to be checked on site.
Report omissions and
discrepancies to the
architect immediately

Project	Jollibee
Client	Manchester
Drawing	Planning Proposed Plans: L02-03 ROOF

Scale	1:50	Date	27/10/2021
Drawing Number	20028-P102		
Drawn By	JG	Checked By	PA
e. hello@applied.studio w. applied.studio t. +44 (0) 20 8150 6616			

P2 25/11/2021 HVAC
P1 01/11/2021 PLANNING