


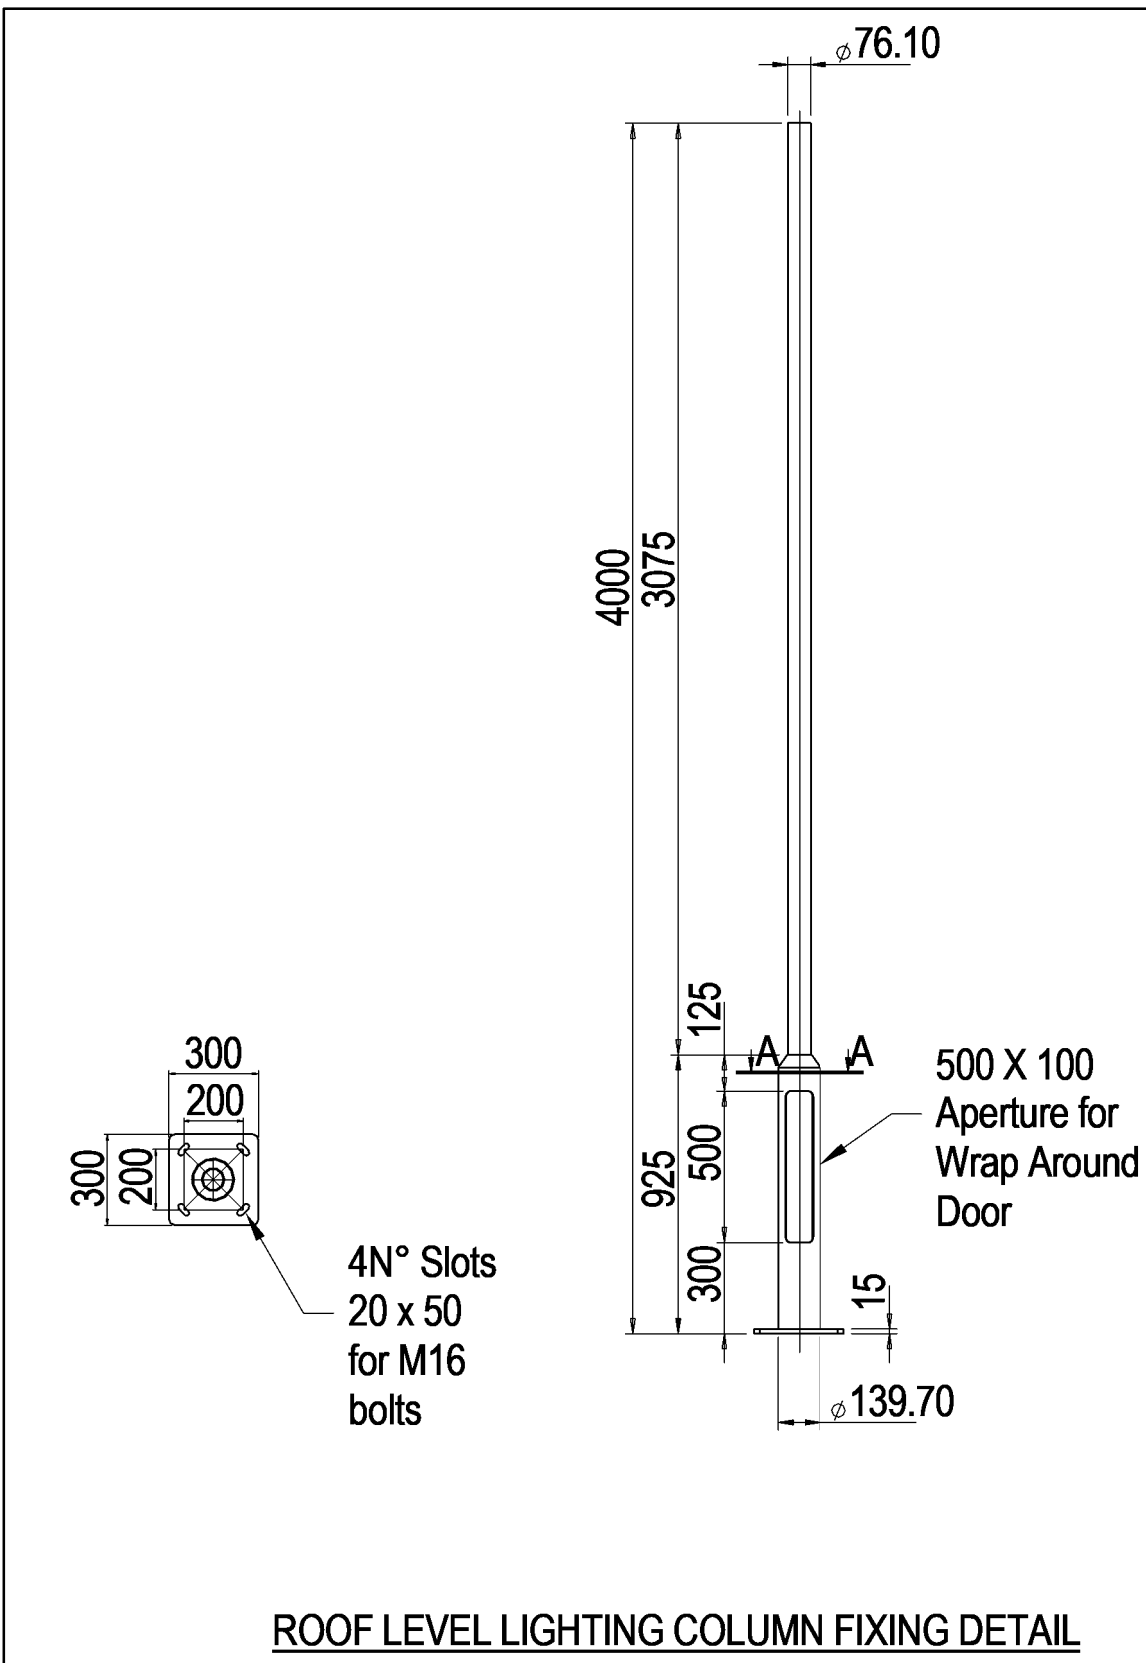

- NOTES - ALL LIGHTING NOTES**
1. ALL SUPPORT SYSTEMS & BRACKETRY SHALL BE DESIGNED & CO-ORDINATED WITH THE BUILDING FABRIC & MECHANICAL SERVICES BY THE ELECTRICAL CONTRACTOR.
 2. STEEL CLIPS SHALL BE USED FOR ALL POWER CABLING WHERE CLIPPED TO LADDER OR TRAY.
 3. THE ELECTRICAL CONTRACTOR SHALL BE RESPONSIBLE TO ENSURE THAT THE ELECTRICAL INSTALLATION FULLY COMPLES WITH BS7671 - 18TH EDITION.
 4. THE ELECTRICAL CONTRACTOR SHALL BE RESPONSIBLE TO ENSURE THAT THE EMERGENCY LIGHTING SYSTEM FULLY COMPLES WITH BS5266.
 5. ALL LIGHTING ON SHAW CIRCUITS IS TO BE CONTROLLED VIA LOCAL TIMECLOCK WITHIN CENTRAL RISER CUPBOARD.
 6. LIGHTING ON LEVEL 04 & 03 ARE TO BE CONTROLLED VIA TIMECLOCK WITH A 50% SPLIT IN LUMINANCES. 50% OF THE LUMINANCES WILL BE TURNED OFF BETWEEN THE HOURS SET BY THE TRUST WITH 50% OF THE FITTINGS ON DOWNED OF THE DURATION SET BY THE TRUST.
 7. NON 24HR FITTINGS ARE TO BE CONTROLLED VIA LOCAL PIR MOUNTED ON TRUNKING SYSTEM.
- LIGHTING LEGEND**
- A THORLUX 23W THORPROOF 1000mm SURFACE MOUNTED LINEAR FITTING
 - B THORLUX 30W THORPROOF 1000mm SURFACE MOUNTED LINEAR FITTING
 - C THORLUX 15W COBALT WALL MOUNTED FITTING
 - D THORLUX 31W STARBAM FLOODLIGHT FITTING ON 4M COLUMN WITH SHROUD CASING
 - E HOSTWAVE 50W FORUM MOUNTED LIFE EMERGENCY SURFACE MOUNTED FITTING
 - F THORLUX 63W STARBAM FLOODLIGHT FITTING
 - EXIT HOSTWAVE KUBUS PIR EMERGENCY EXIT FITTING WITH DIRECTIONAL ARROWS
 - LR LIGHTING GRIDSWITCH ASSEMBLY
 - SM LONG RANGE SURFACE MOUNTED PIR PRESENCE DETECTOR
 - LC TIME CLOCK
 - LC LIGHTING CONTRACTOR
 - PC EXTERNAL WALL MOUNTED PHOTO CELL

002	UNDERCROFT LIGHTING ADDED & REVISED LIGHTING CIRCUITS AMENDED	AC	RB
001	CONSTRUCTION ISSUE	OK	KH
P02	STAGE 4 - FOR STAKEHOLDER PRESENTATION	AC	RB
P01	PRELIMINARY ISSUE	AC	RB
Rev	Amendment	By Date	By Date

HE

Simm

ENGINEERING EXCELLENCE

HEAD OFFICE
Suite 5 & 6, Sprinkler House
141 Saffron Street
Liverpool L6 5SH

Tel: 0151 707 3222
Email: info@hesimm.co.uk
hesimm.co.uk

Project Name:
THE CHRISTIE TIERED CAR PARK

Sheet Title:
LEVEL 04 & 03
PROPOSED LIGHTING LAYOUT

Scale (@ A0):
1:100

Drawn:
AC

RIBA Stage:
5

Status:
A5

BS1192 Document Number:
TCP-HES-XX-ZZ-DR-E-630003

Revision:
C02