

Principal Designer | Principal Contractor



Architect | Lead Designer

EBL
ENGIE Buildings Limited

Project | PFI Partners

**Catalyst Healthcare (Manchester)
Limited**





Employer | End User


Manchester University
NHS Foundation Trust

[illegible]

CODE	
STATUS	
BIM	
OTHER	

PROJECT

DESCRIPTION

VE20-050 Proposed AMR Laboratory

Proposed Variation Works

North Elevation

CLIENT _____

Manchester University NHS Foundation Trust

DRAWN BY
SS

RIBA STAGE S1	
------------------	--


DATE
13/08/20

SCALE (@ A1)
1 : 50

PROJECT NUMBER	VE20-050
----------------	----------

DRAWING NUMBER	2050-EVW-Z6-XX-DR-A-12-200
----------------	----------------------------

REV

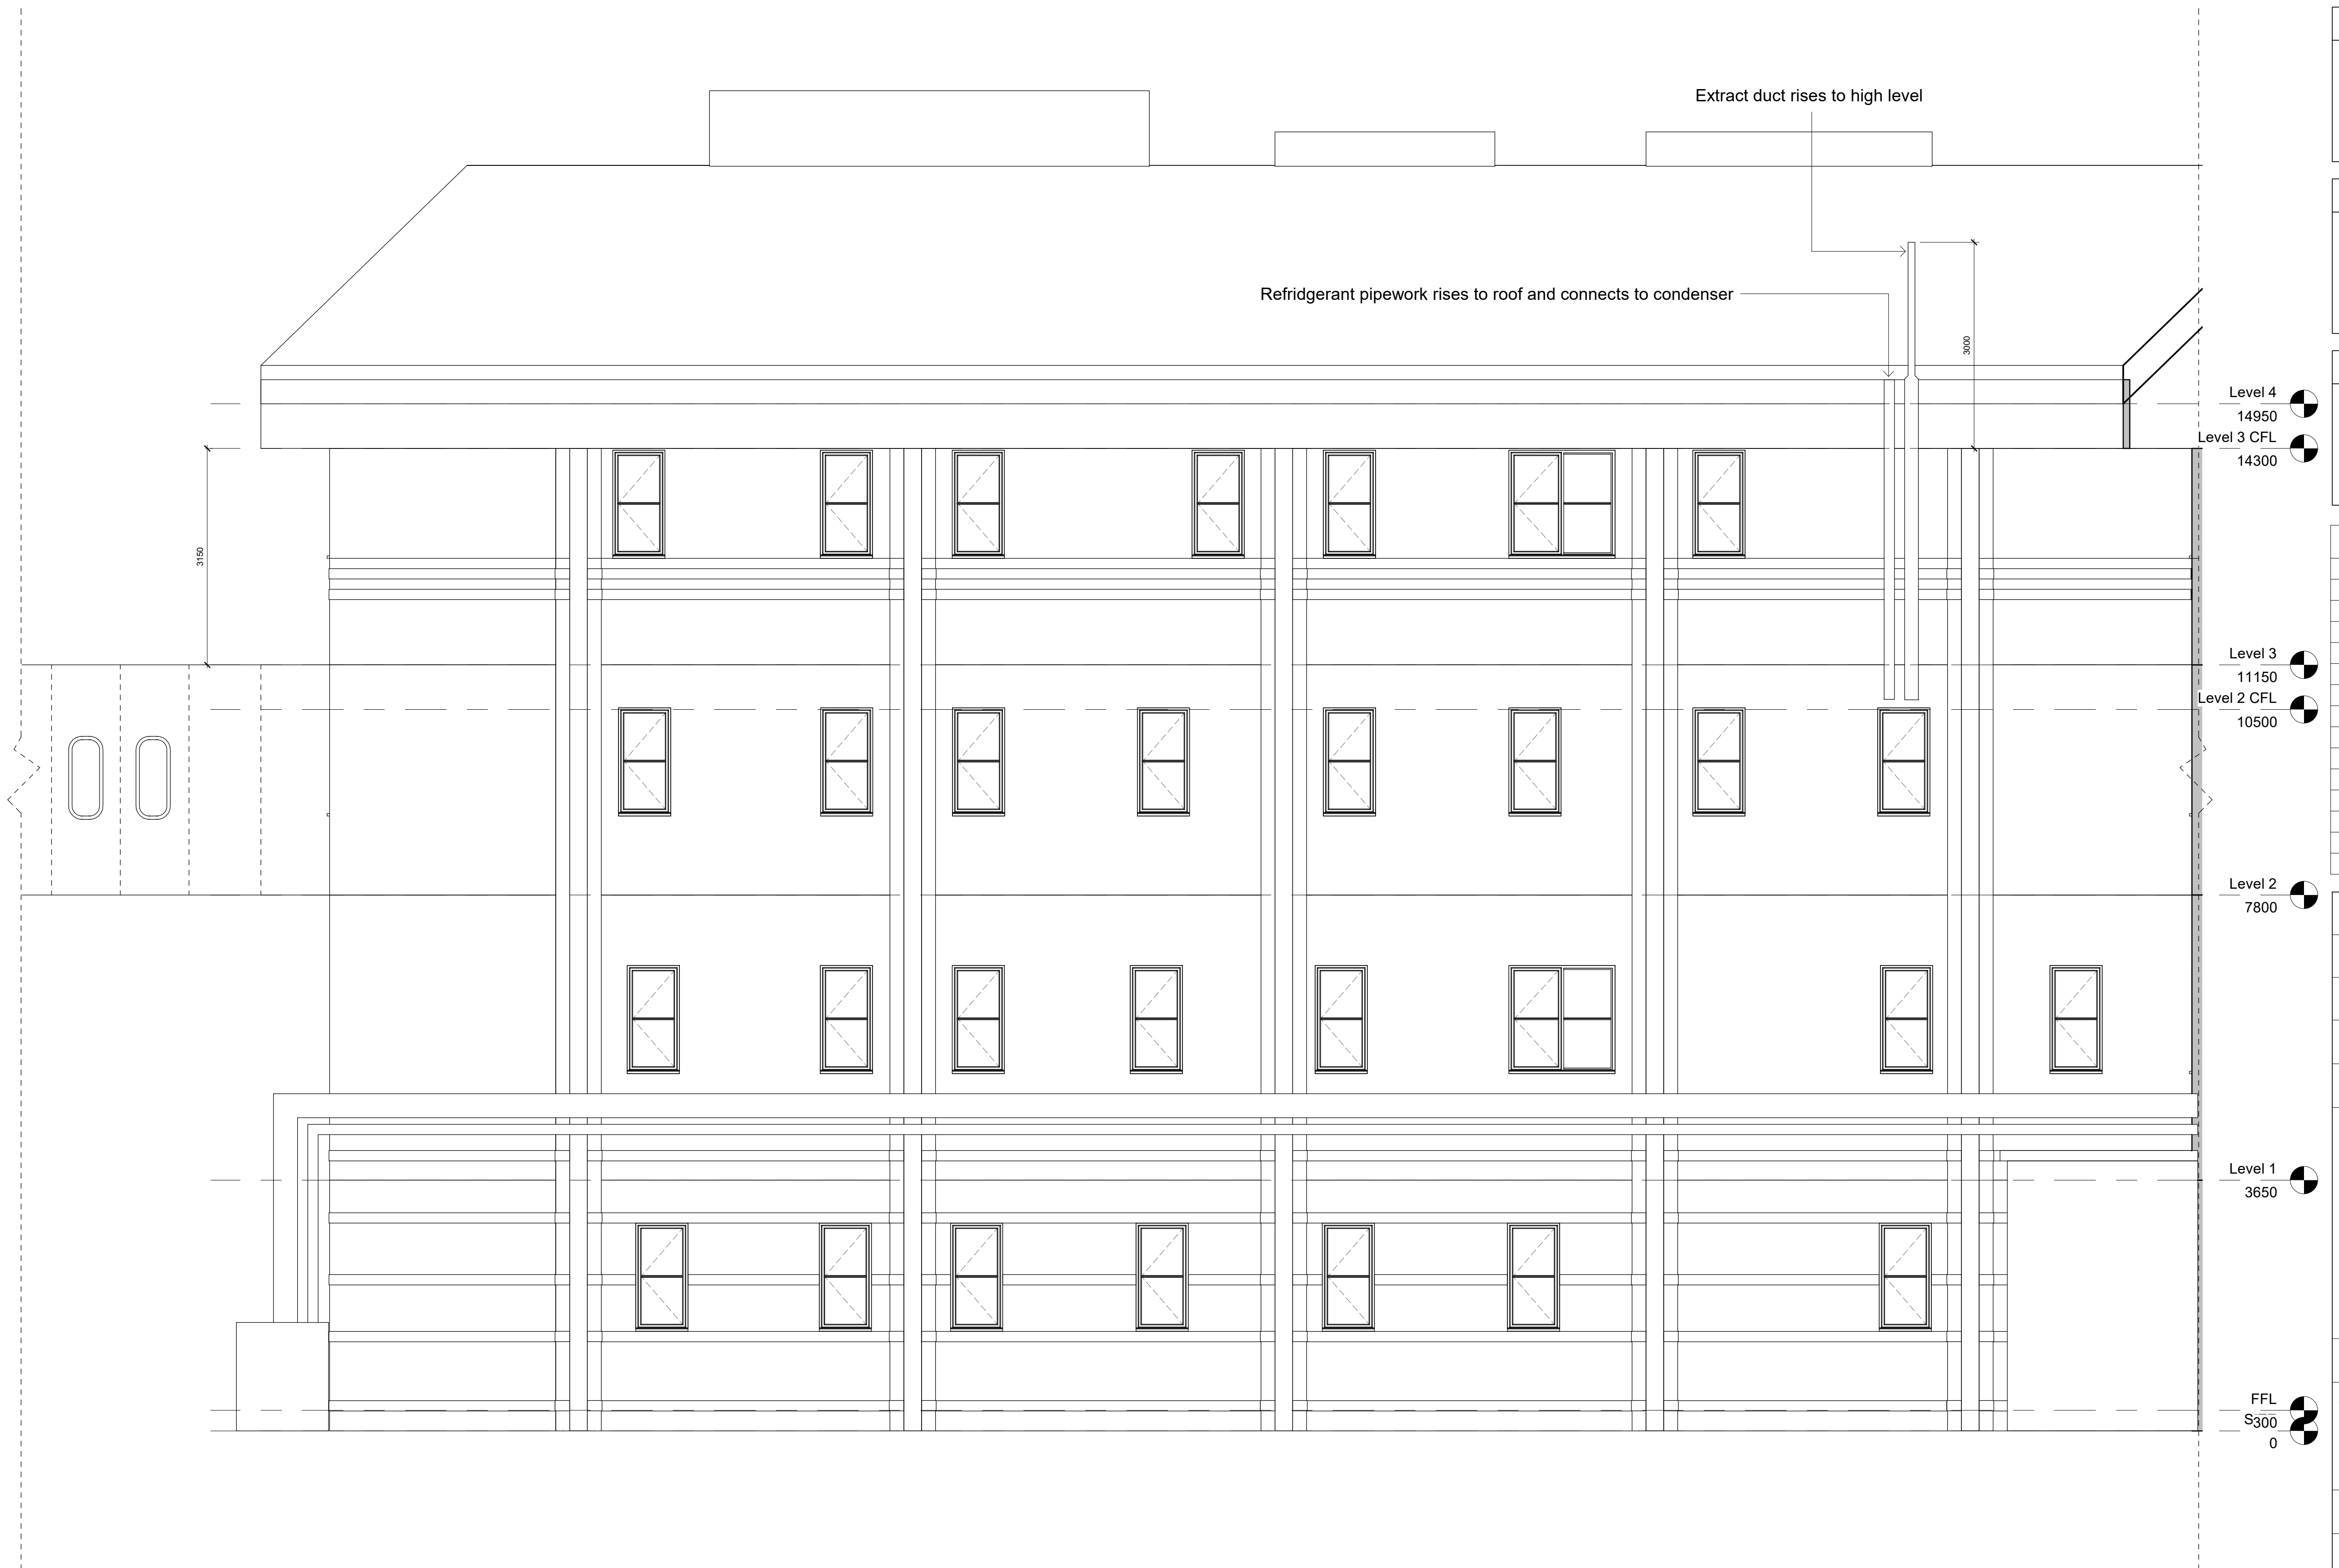

THIS DRAWING IS COPYRIGHT. ALL DIMENSIONS MUST BE CHECKED ON SITE. ONLY FIGURED DIMENSIONS ARE TO BE WORKED FROM. DISCREPANCIES MUST BE REPORTED IMMEDIATELY BEFORE PROCEEDING. IF IN DOUBT ASK