

Job No.	Drawing No.	Rev
PA1484	VMM-TCE-XX-XX-DR-M-50001	C1

COPYRIGHT:
The copyright of this drawing is vested in TACE. It shall not be used or reproduced without permission for any purpose.
Do NOT scale from this drawing, work only to figured dimensions.
All dimensions in millimetres unless otherwise stated.
This drawing has been created electronically, do not modify by hand.

Ventilation Notes


- This drawing shall be read in conjunction with all other services, Architectural drawings, project specifications and contract documentation.
- All ductwork to DW144/DW154 (where applicable).
- Flex to be used only straight-all bends to be rigid.
- Fire collars to be located in accordance with fire strategy drawing requirements.
- All diffusers and grilles to be supported by structure.
- In positions of restricted headroom, ducts may be supported with flat bar formed to duct shape with fixings at sides on bent lugs.
- All references to specific manufacturers are made for design specification purposes, installed equipment should be of equal standard and approved.
- All Heat Recovery Units to be fitted with 22mm condensate drains.
- The mechanical ventilation heat recovery unit shall be arranged with interlocks, to initiate a 'boosted' level of ventilation as follows:
 - A switch interlock in each kitchen and a built in humidistat located as part of the central fan. The humidistat will monitor the air in the extract ducts and operate automatically as and when the air quality requires changing. This is to run on for a programmed period of time once the switch has been switched off.
- The fan unit shall be complete with a local wall mounted isolator, located conveniently within the storage cupboard.
- A minimum of 4ach/hr shall be provided to provide purge ventilation in line with Part F of the building regulations.

Ventilation Legend

-  Supply Air Flow
-  Extract Air Flow
-  PIR Detector
-  Volume control damper (M = Motorised)
-  Fire damper
-  Attenuator (CT = Cross talk)
-  Controller for heat recovery units

Supply diffuser installed horizontally in bulkhead

Supply diffuser installed horizontally in bulkhead

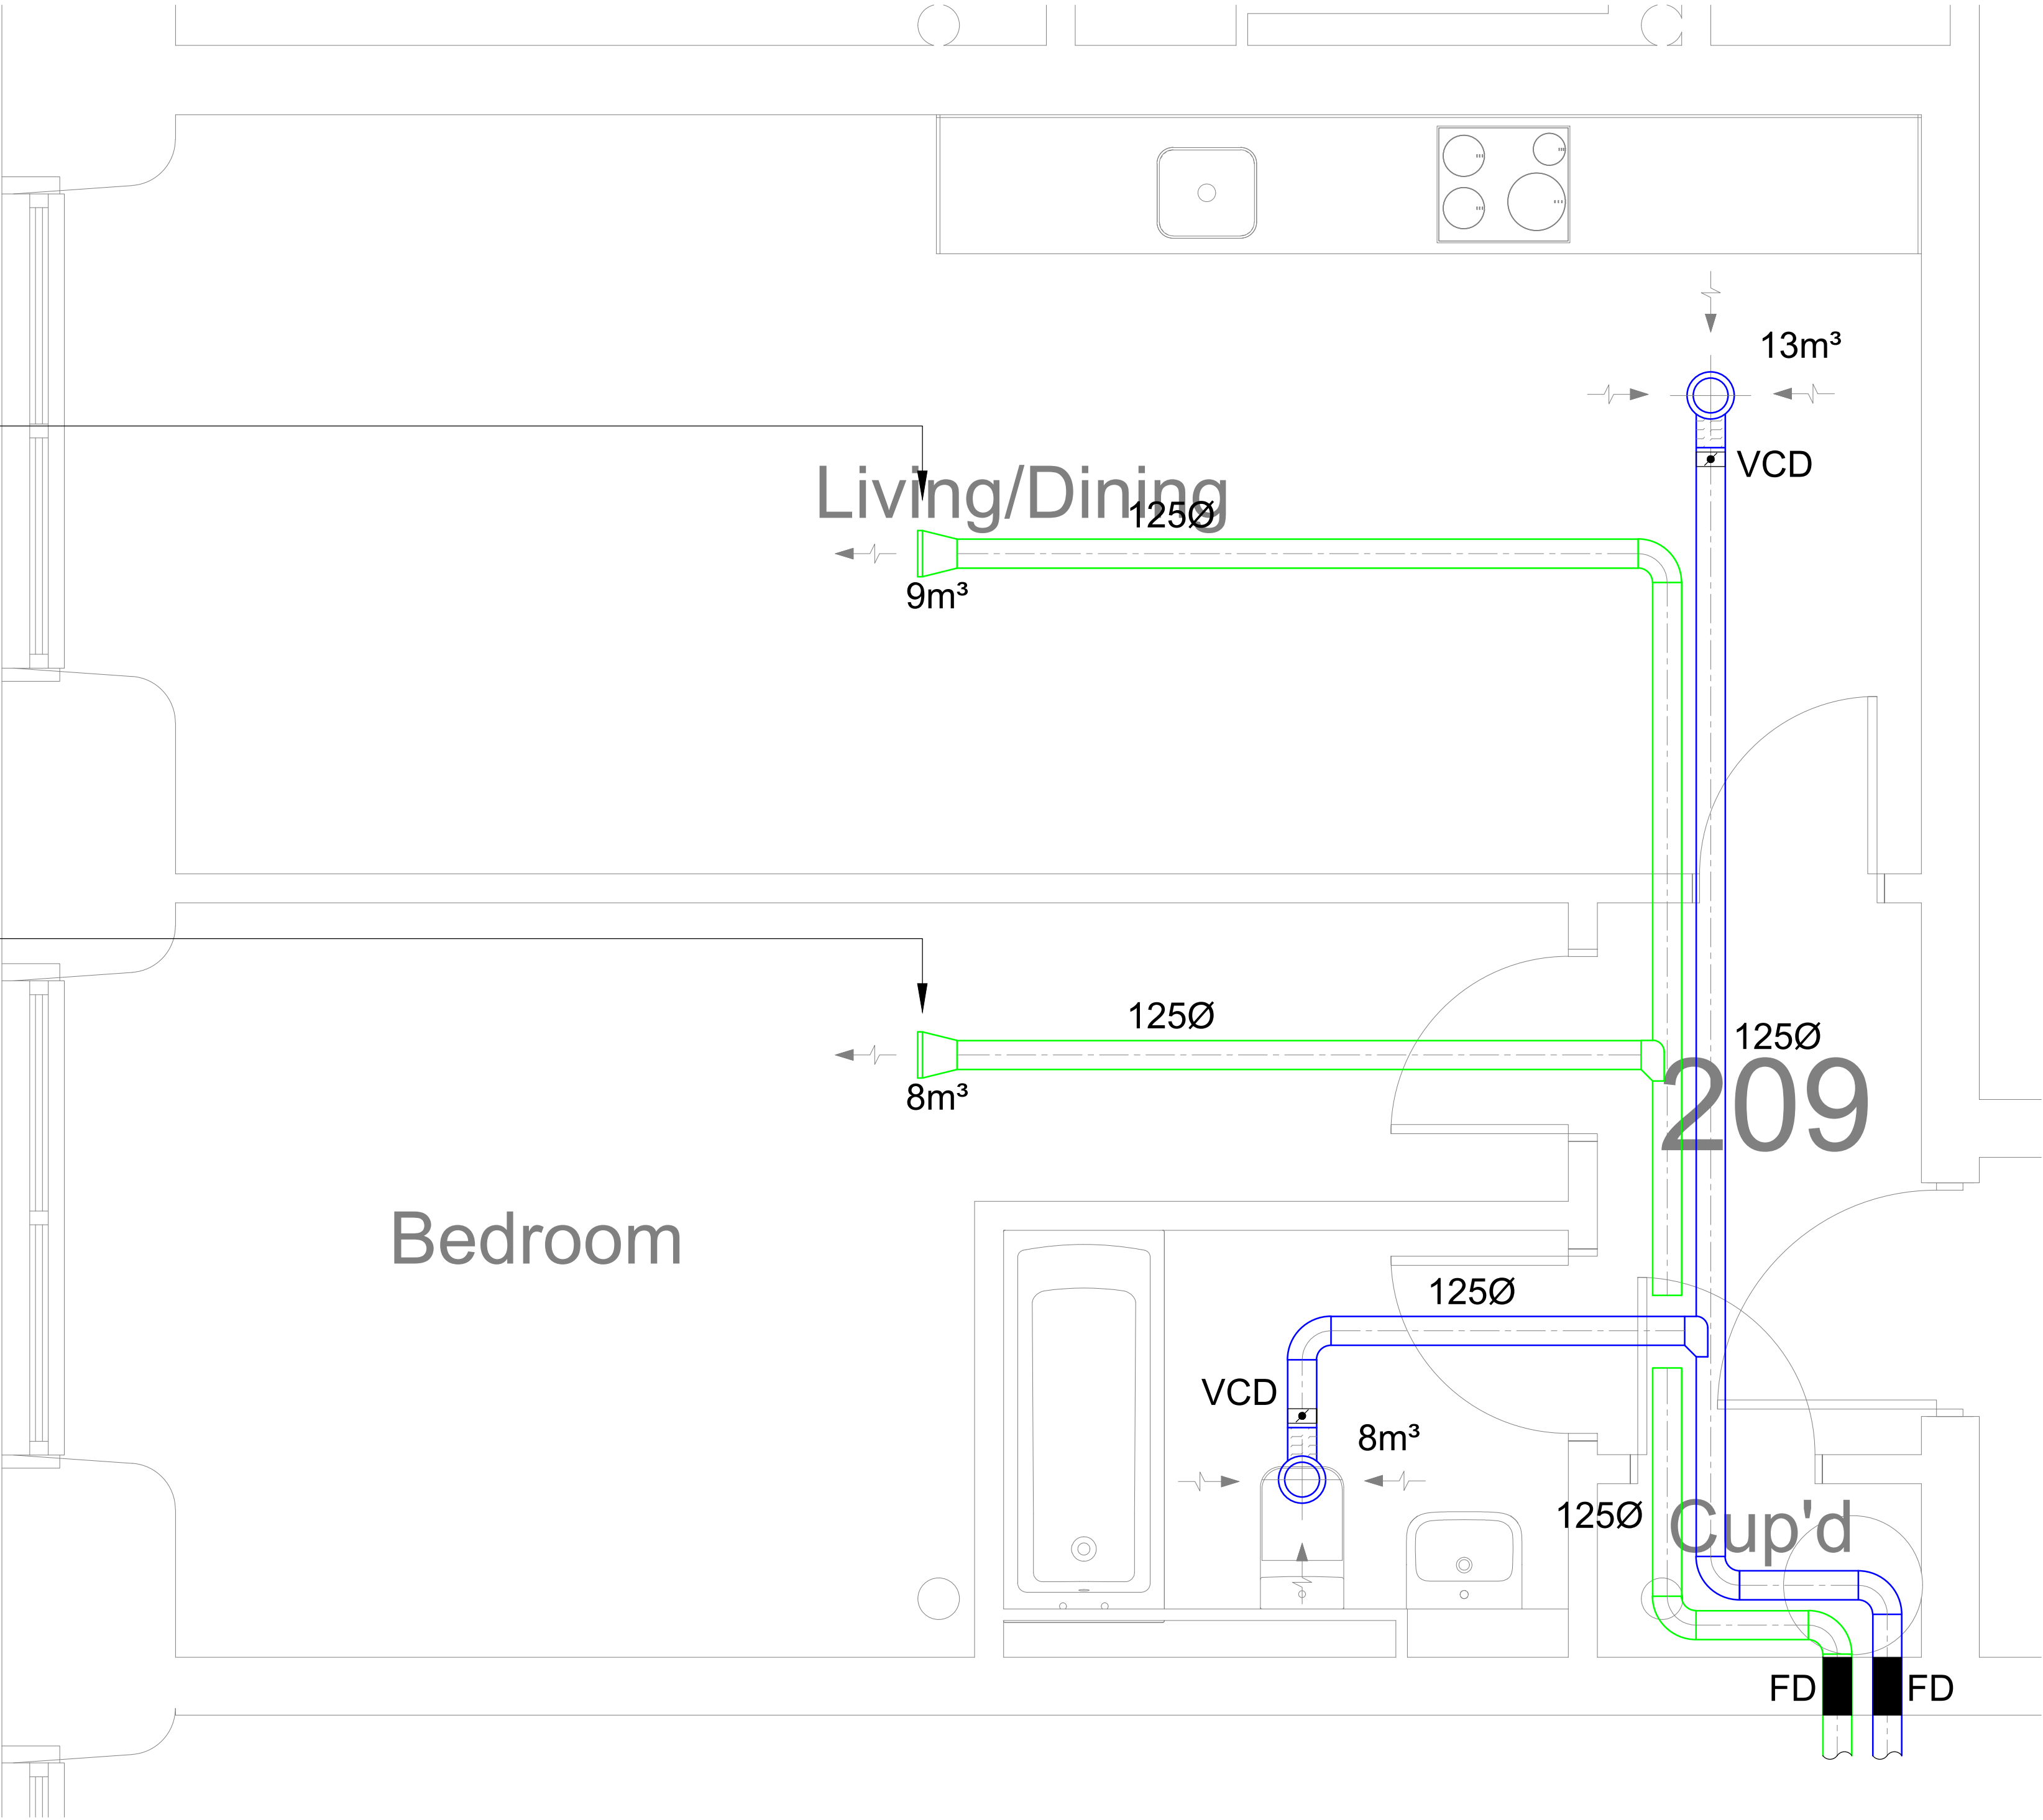

C1	NG	19.03.21	Contract Issue.
Rev	By	Date	Description



TACE
THE ASSOCIATES CONSULTING ENGINEERS
Portland House
Stanley Green Business Park
Oak Green
Cheshire Holmes
Cheshire
SK9 6QZ
T: 0161 486 0429
F: 0161 486 0488
E: info@tace.co.uk
W: www.tace.co.uk

Client

FRP Advisory

Project

Victoria Mill Manchester

Drawing Title

Typical 1 Bedroom Apartment
Ventilation Layout
Type A

Drawn	Date	Cad File
EI	06.01.21	VMM-TCE-XX-XX-DR-M-50001 Rev C1.dwg
Checked	Date	External Ref.
JM	06.01.21	-
Approved	Date	Scale
JM	06.01.21	1:20 at A1

Job No.	Drawing No.	Rev
PA1484	VMM-TCE-XX-XX-DR-M-50001	C1