


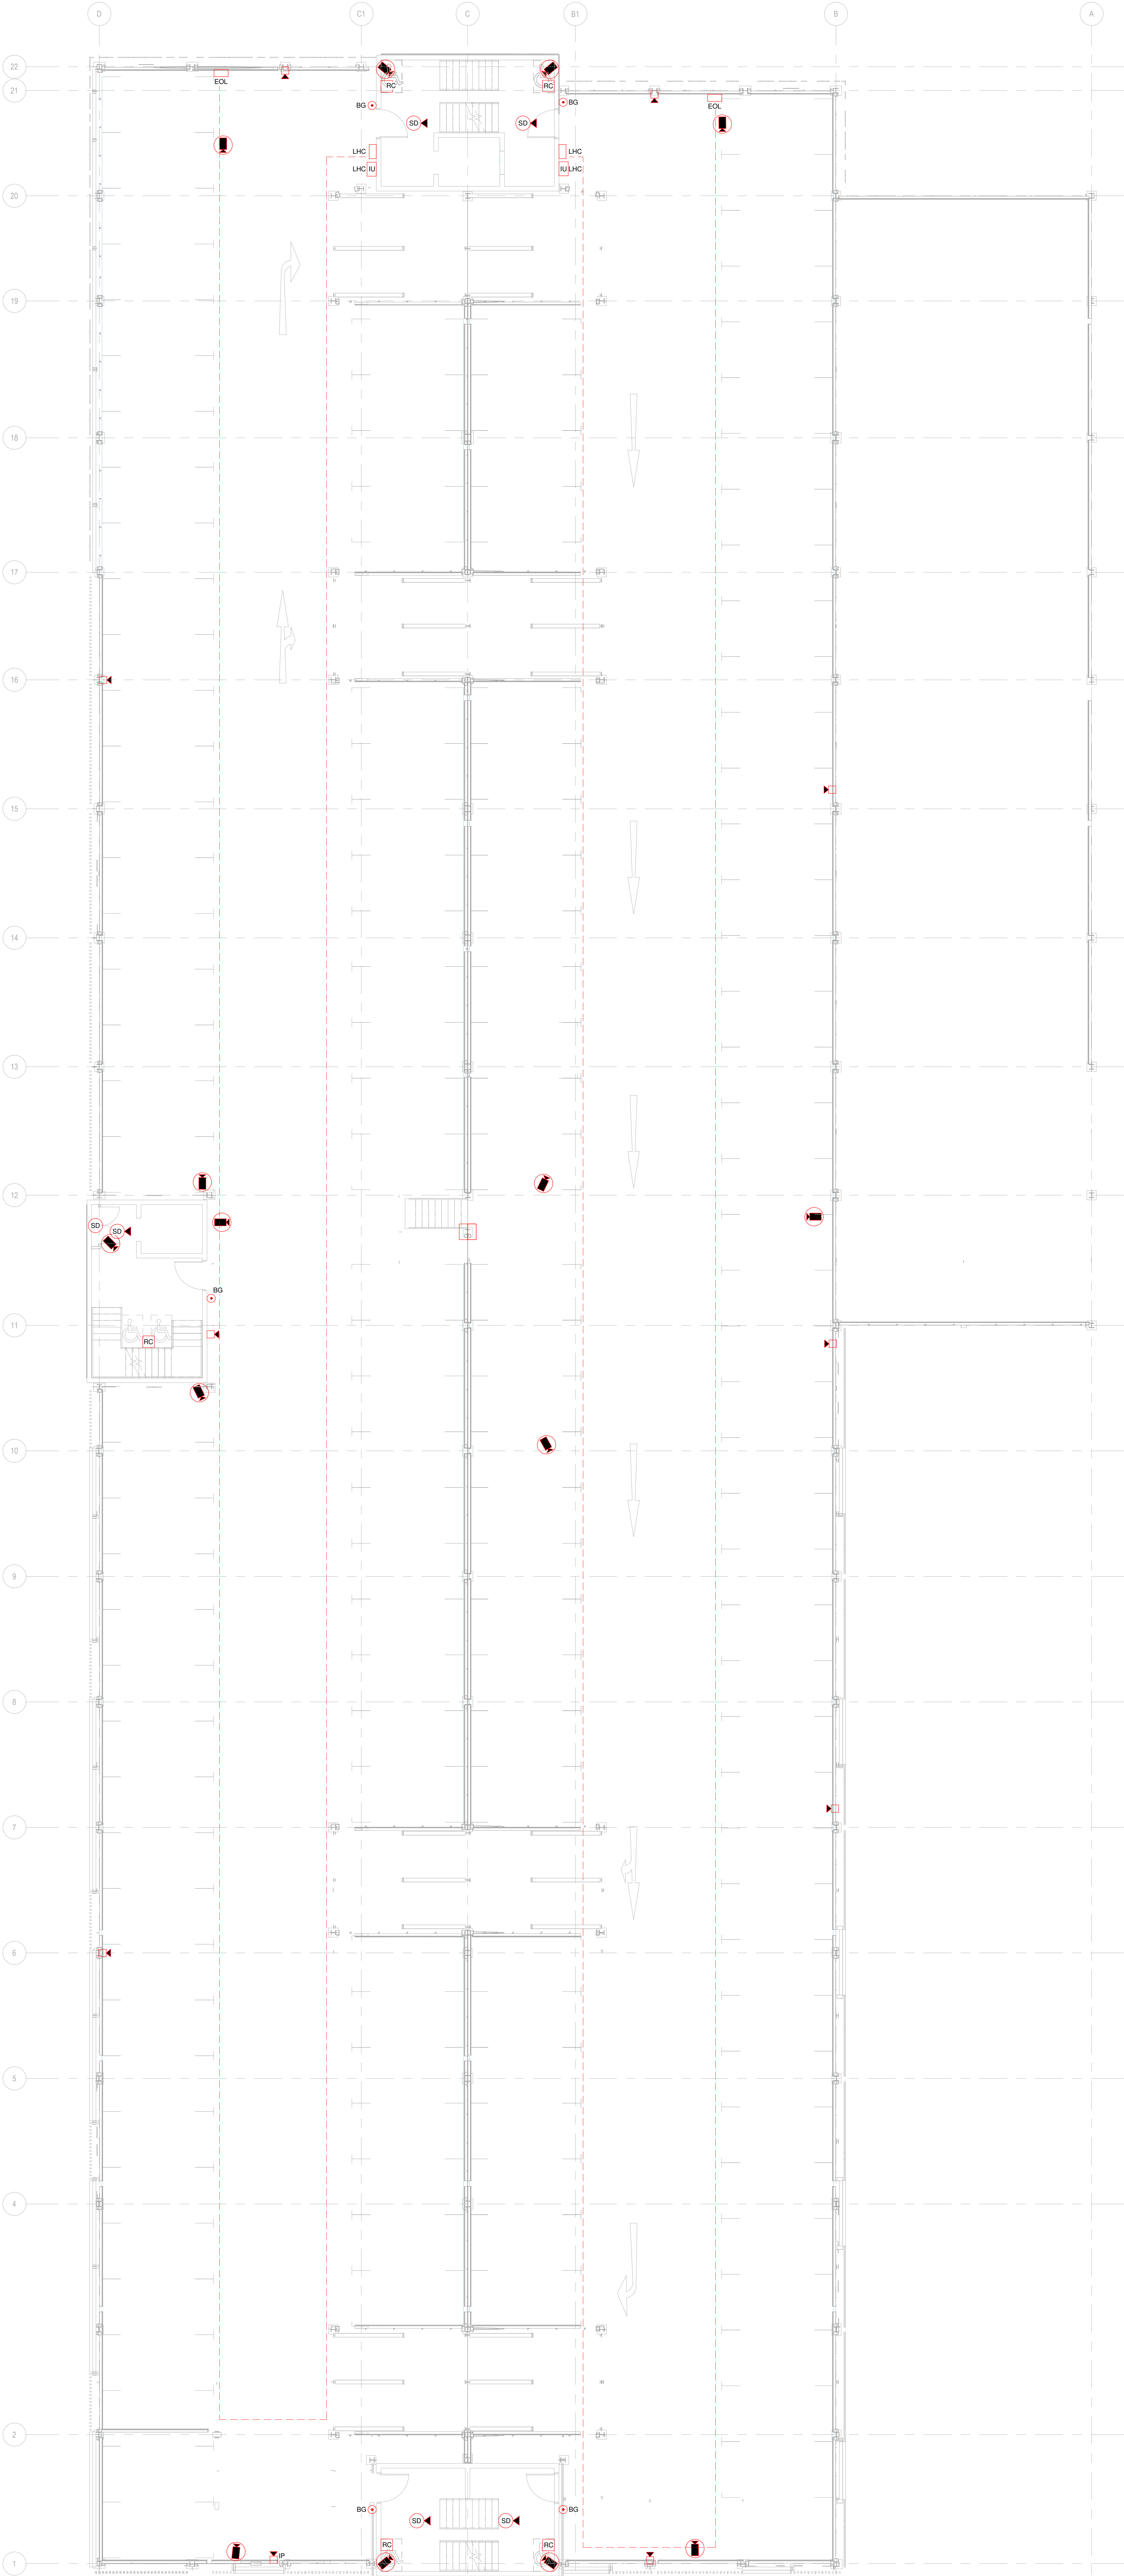

THIS DRAWING IS THE COPYRIGHT OF HE SIMM
IT IS NOT BE LOANED, REPRODUCED OR COPIED FOR ANY PURPOSE WITHOUT THE WRITTEN CONSENT OF HE SIMM. IT IS NOT TO BE USED FOR ANY OTHER PROJECT OR FOR ANY OTHER PURPOSE WITHOUT THE WRITTEN CONSENT OF HE SIMM.
THESE DRAWINGS ARE NOT TO BE USED FOR ANY OTHER PROJECT OR FOR ANY OTHER PURPOSE WITHOUT THE WRITTEN CONSENT OF HE SIMM.

NOTES - AT FIRE ALARM & SECURITY NOTES

1. ALL SUPPORT SYSTEMS & BRACKETRY SHALL BE DESIGNED & CO-ORDINATED WITH THE BUILDING FABRIC & MECHANICAL SERVICES BY THE ELECTRICAL CONTRACTOR.
2. STEEL CLIPS SHALL BE USED FOR ALL POWER CABLES WHERE CLIPPED TO LADDER OR TRAY.
3. THE ELECTRICAL CONTRACTOR SHALL BE RESPONSIBLE TO ENSURE THAT THE FIRE ALARM SYSTEM FULLY COMPLIES WITH BS5839.
4. THE ELECTRICAL CONTRACTOR SHALL BE RESPONSIBLE TO ENSURE THAT THE DOOR ENTRY ACCESS SYSTEM FULLY COMPLIES WITH BS6869.

FIRE ALARM & SECURITY LEGEND

- SD SMOKE DETECTOR WITH SOUNDER BASE
- HD SMOKE DETECTOR
- HD HEAT DETECTOR WITH SOUNDER BASE
- HD HEAT DETECTOR
- BG BREAK GLASS UNIT
- BG BREAK GLASS UNIT (IP65 RATED)
- EOL DOOR ENTRY SYSTEM - EMERGENCY PUSH TO RELEASE (GREEN) UNIT
- EOL DOOR ACCESS SYSTEM - GREEN MUSHROOM HEADED PUSH TO EXIT BUTTON
- LHC WALL MOUNTED FIRE ALARM SYSTEM
- LHC WALL MOUNTED FIRE ALARM SYSTEM (IP65 RATED)
- LHC FIRE ALARM INTERFACE UNIT FOR DOOR ACCESS
- LHC FIRE ALARM INTERFACE UNIT FOR LIFT
- LHC FIRE ALARM INTERFACE UNIT FOR MECHANICAL PLANT
- LHC FIRE ALARM INTERFACE UNIT FOR FIRE ALARM ASPIRATOR
- LHC FIRE ALARM INTERFACE UNIT FOR LINEAR HEAT CONTROLLER
- DRP DISABLED REFUGE PANEL
- FAP FIRE ALARM PANEL
- LHC LINEAR HEAT CONTROLLER
- EOL LINEAR HEAT END OF LINE
- IP INTRUDER ALARM PANEL
- ACP ACCESS CONTROL PANEL (FINAL LOCATION TBC)
- RC DISABLED REFUGE INTERCOM UNIT
- ML DOOR ACCESS SYSTEM - DOOR HOLD MAG LOCK UNIT
- DC SECURITY/INTRUDER ALARM CONCEALED DOOR CONTACT
- DOOR ACCESS SYSTEM - WALL MOUNTED FOR READER
- CCTV CAMERA
- HP EMERGENCY HELP POINT
- LINEAR HEAT TAPE

C01	CONSTRUCTION ISSUE	OK	RB
P02	STAGE 4 - FOR STAKEHOLDER PRESENTATION	AC	RB
P01	PRELIMINARY ISSUE	AC	RB
Rev	Amendment	By	Date

HE Simm
ENGINEERING EXCELLENCE

HEAD OFFICE
Sutton 5 & 6, Spinnaker House
141 Sefton Street
Liverpool L8 5SN

Tel: 0151 707 3322
Email: info@hesimm.co.uk
hesimm.co.uk

Project Name:
THE CHRISTIE TIERED CAR PARK

Sheet Title:
LEVEL 02 & 01
PROPOSED FIRE ALARM & SECURITY LAYOUT

Scale (@ A0): 1:100
Drawn: OK
RIBA Stage: 5
Status: A5
Revision: C01

BS1192 Document Number:
TCP-HES-XX-ZZ-DR-E-670002