



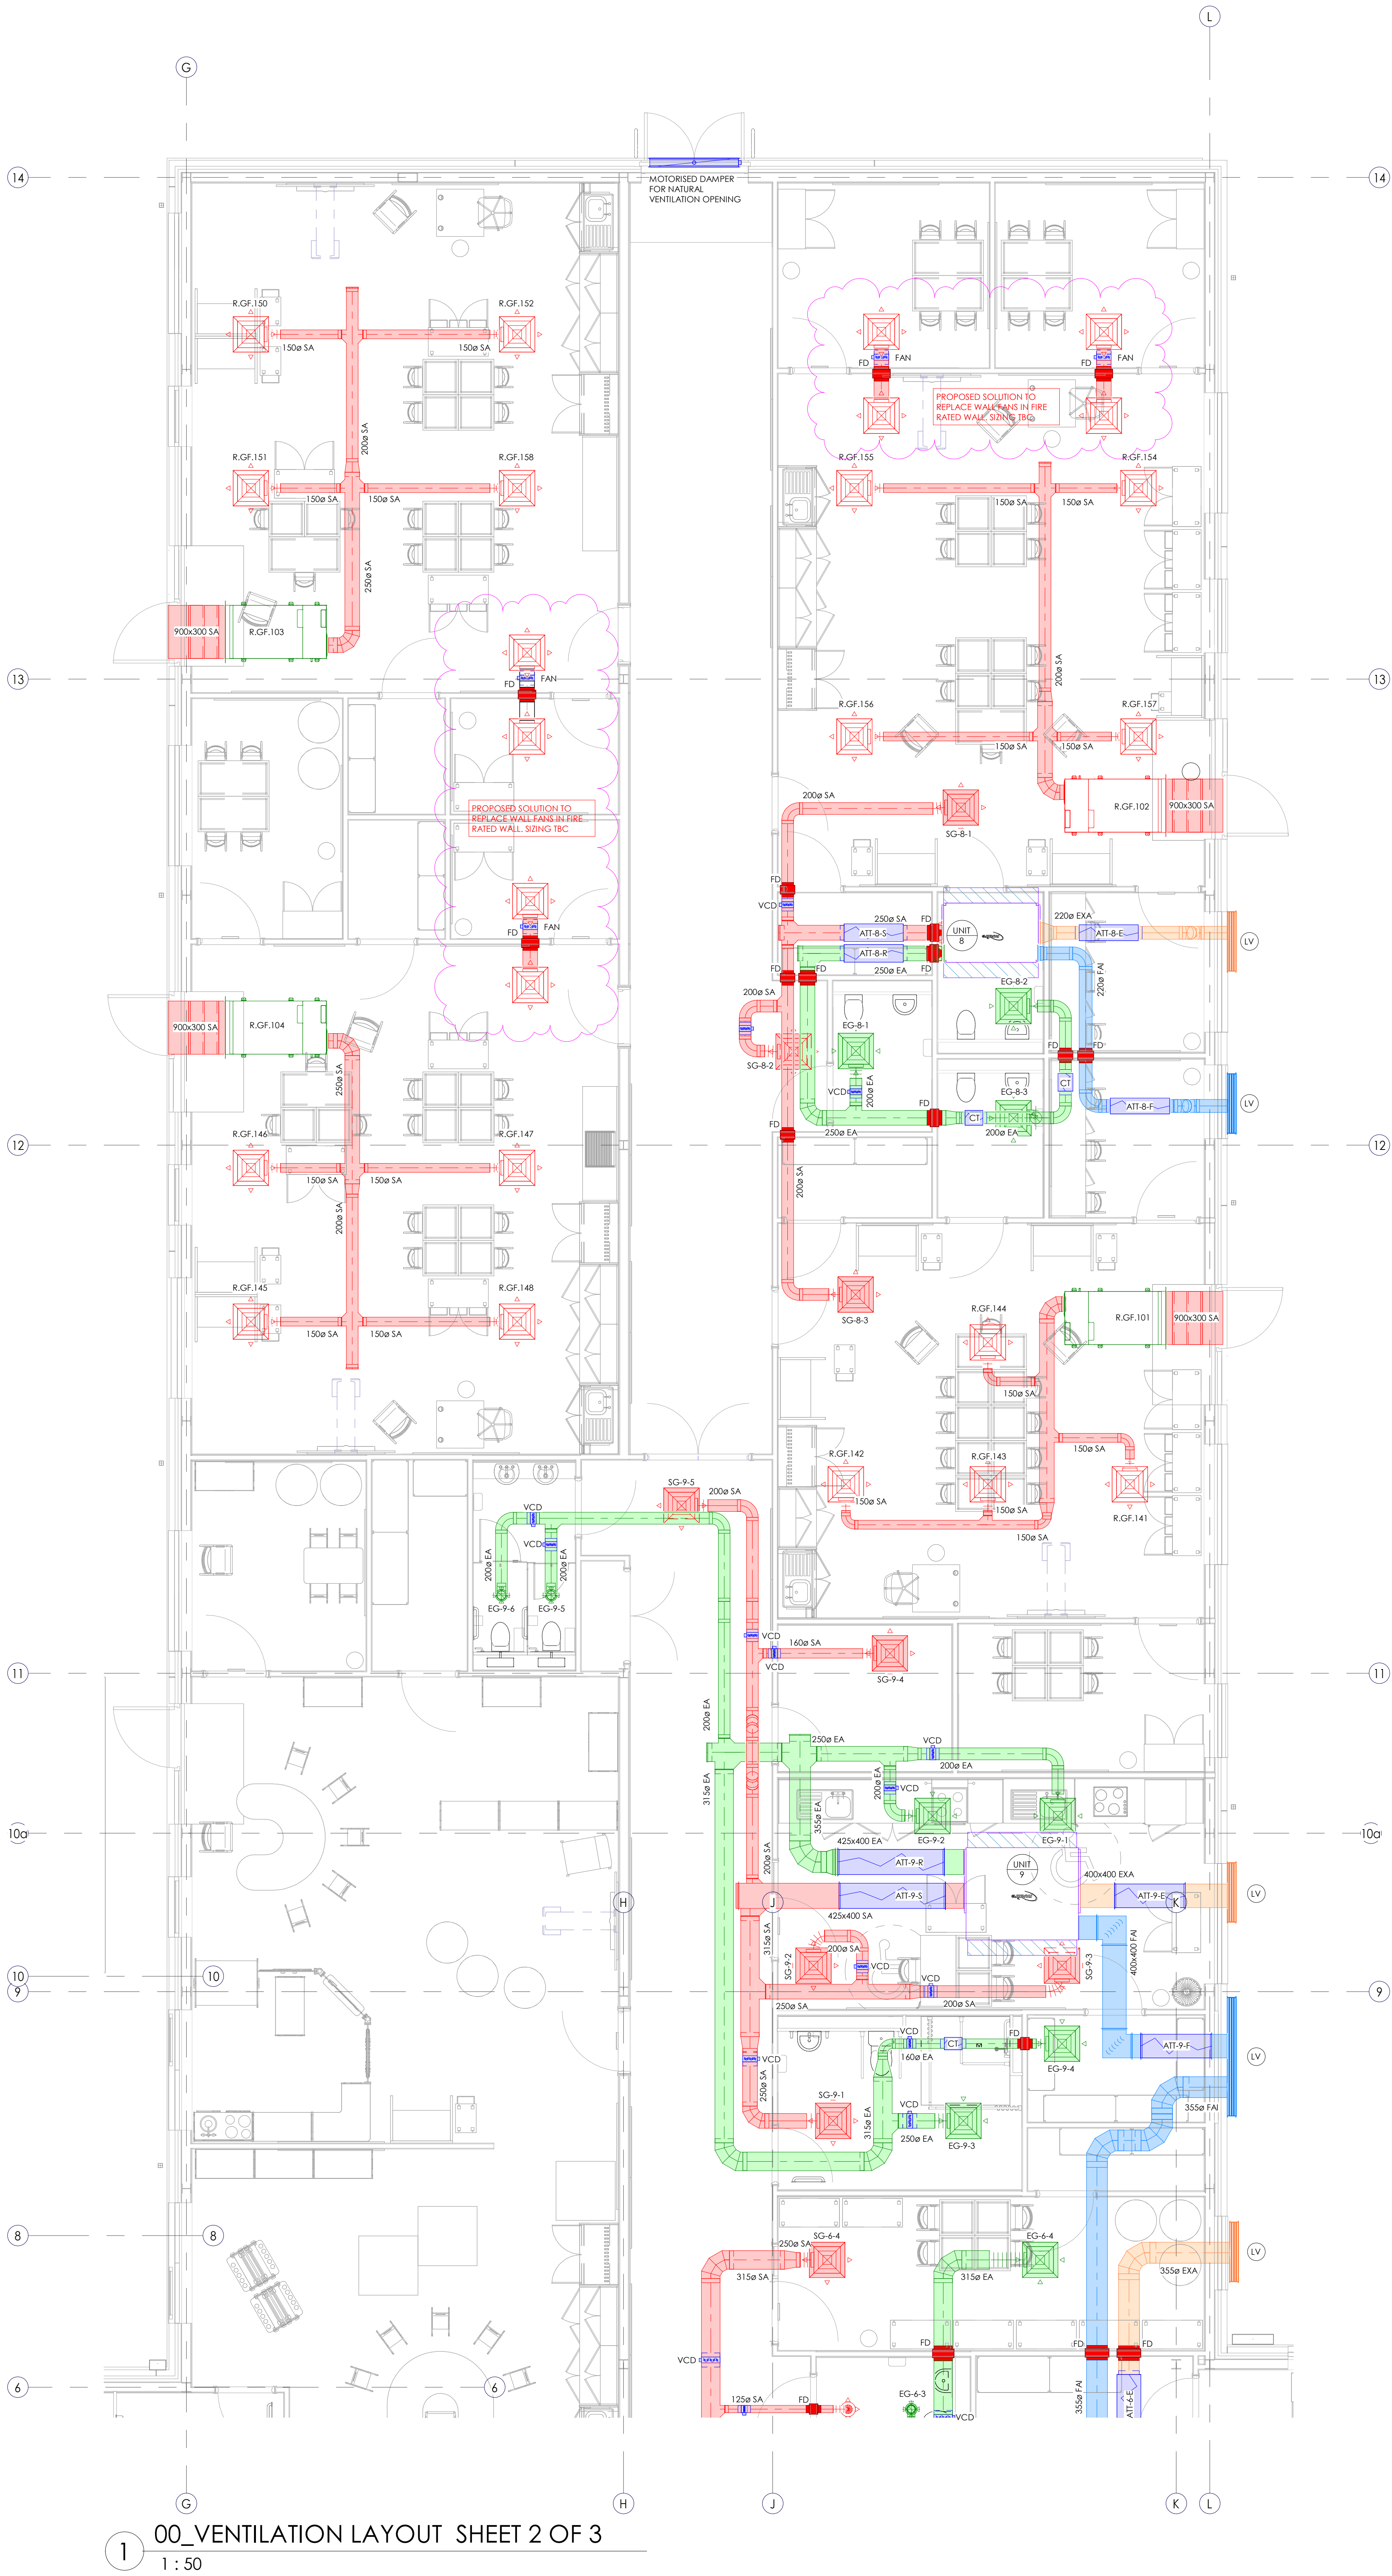

1

00_VENTILATION LAYOUT SHEET 2 OF 3

1 : 50

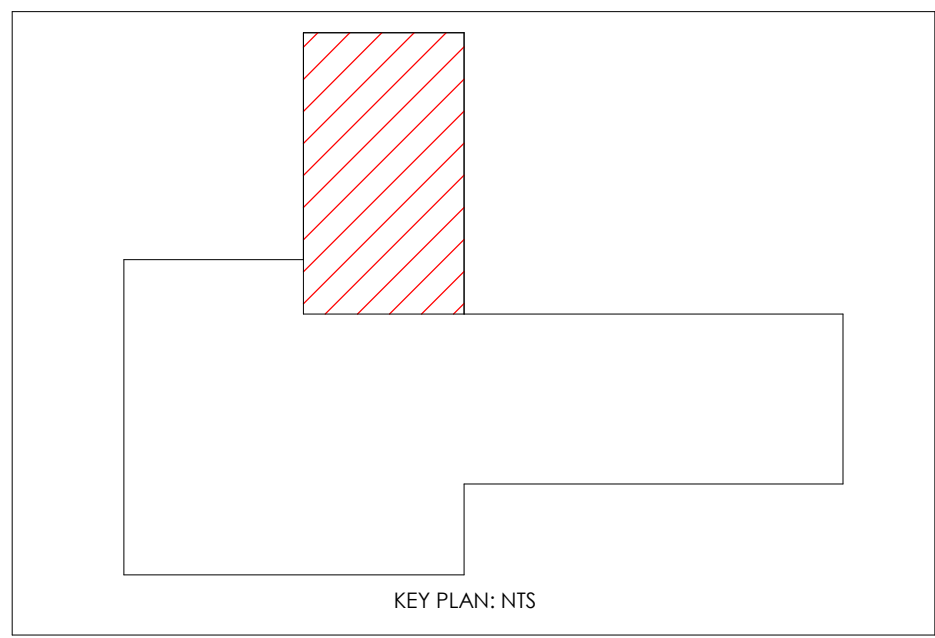

P1

18.06.21

PRELIMINARY ISSUE

PM

RG

RG

Rev

Date

Description

Dm

Chk

App

Drawing Status:

PRELIMINARY

Tilbury Douglas

PIPETECH

SERVICES LTD

CRM

Electrical Services Ltd

HE

hurstwood environmental

Consulting Engineers

www.hurstwood-eng.co.uk

■ Bolton Office

Alto

Spot Road

Bolton

Bk1 4AG

T: 01204 790 041

E: bolton@hurstwood-eng.co.uk

■ Liverpool Office

23 Goodlass Road

Speke

Liverpool

L24 9PU

T: 0151 728 2360

E: liverpool@hurstwood-eng.co.uk

■ London Office

54 Gray's Inn Road

Bloombury

London

WC1A 8BP

T: 0203 755 3711

E: london@hurstwood-eng.co.uk

Drawn:

PM

Chkd:

RG

App:

RG

Date:

JUNE 2021

Scale:

As indicated

Revit Version:

2019

Project:

PROSPECT HOUSE, PRIMARY SCHOOL

MANCHESTER

Drawing Title:

VENTILATION LAYOUT

GROUND FLOOR

SHEET 2 OF 3

Drawing No:

FS0831-HEC-B1-GF-DR-M-5702

Rev

P1

Project Code

Originator

Volume

Level

Type

Role

Number

18/06/2021 17:06:14