


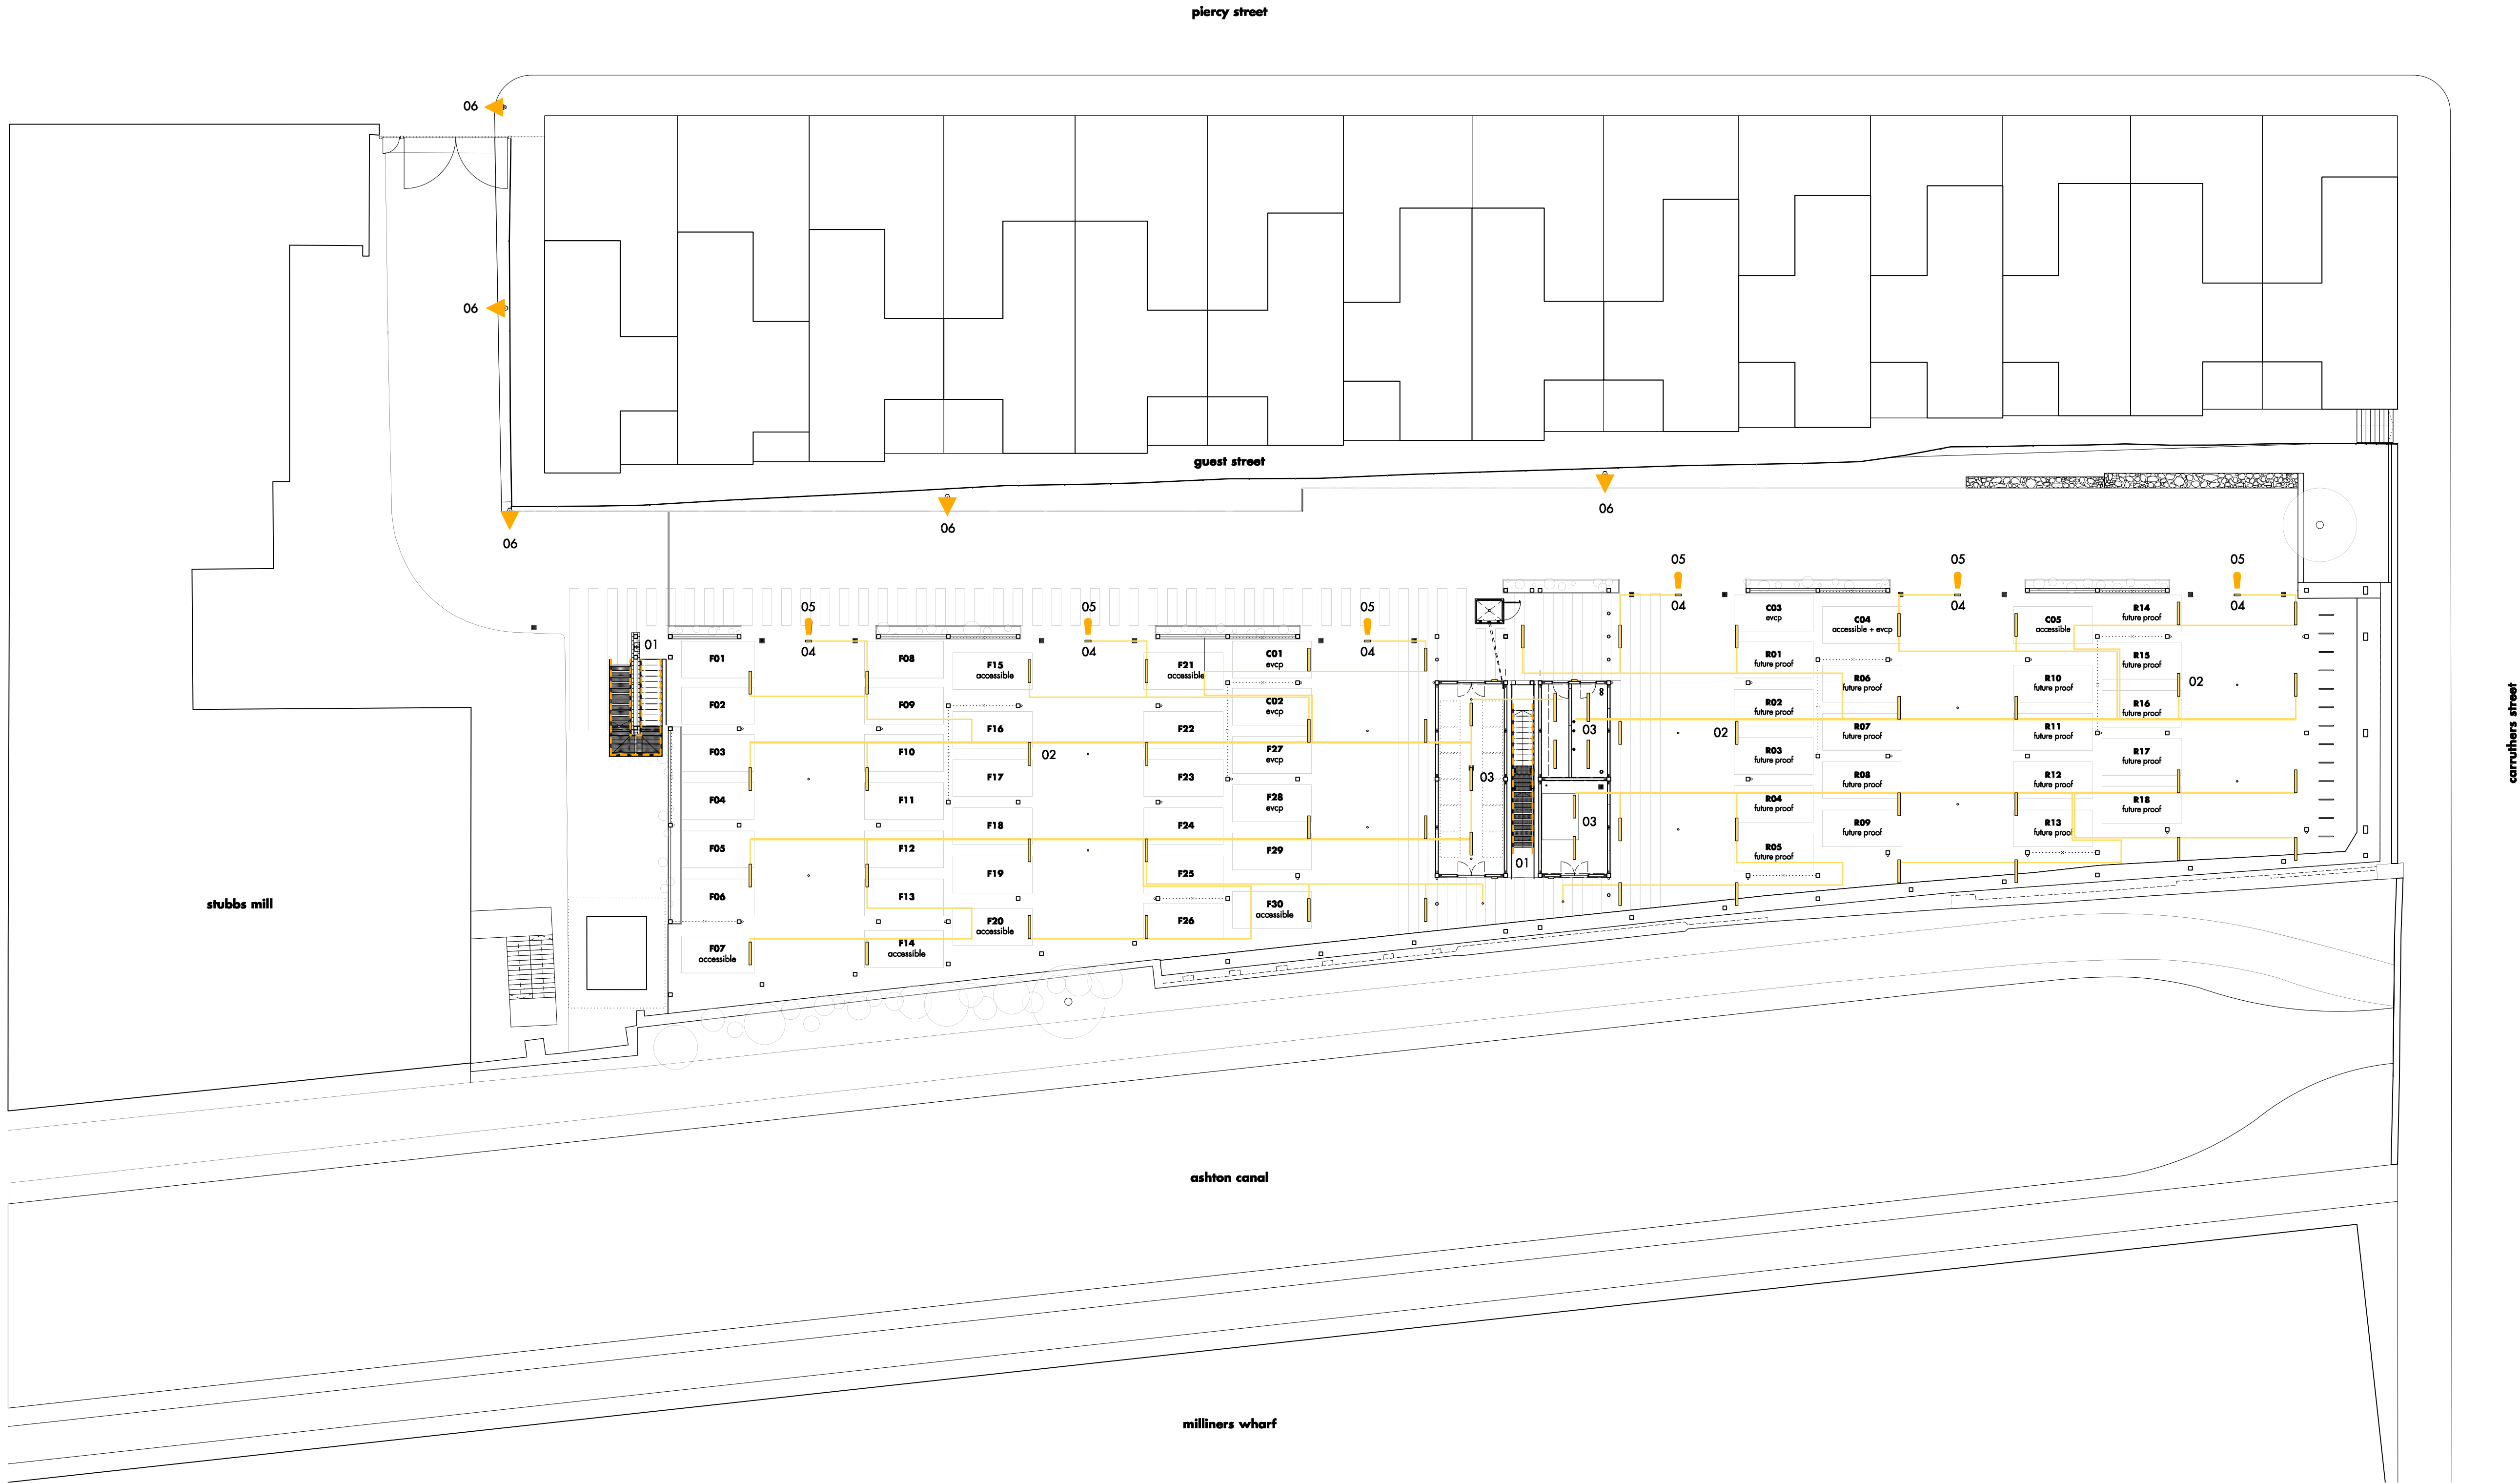

- 01 staircase to podium level
 - handrail led down lighting
- 02 car park soffit surface mounted led strip lighting
 - IP65 LED luminaire
- 03 plant room soffit surface mounted led strip lighting
 - IP65 LED luminaire
- 04 emergency exit illuminated signage
- 05 down lighting illuminare to ground
 - fixing to podium frame level
- 06 existing column lighting
- 07 podium bollard lighting
- 08 wall mounted lighting
- 09 entrance downlight

- • planning condition issue
rev • description

09 07 21 • hw • rt
issued • drawn • checked

shedkm

+44 (0)151 709 8211
+44 (0)207 253 8881

project	stubbs mews
client	urban splash
drawing number	SM-S5 (00) 115 •
scale	1:200 @ a1
status	information

site plan - lower ground lighting

do not scale from this drawing • all dimensions are to be set out and checked on site prior to starting construction • any discrepancy found between information given on this drawing and that given elsewhere or recorded on site shall be brought to the attention of the project architect immediately